



SATHYABAMA

INSTITUTE OF SCIENCE AND TECHNOLOGY
(DEEMED TO BE UNIVERSITY)

Accredited with “A” grade by NAAC | 12B Status by UGC | Approved by AICTE

Jeppiaar Nagar, Rajiv Gandhi Salai, Chennai – 600 119

www.sathyabama.ac.in

SCHOOL OF BUILDING AND ENVIRONMENT
DEPARTMENT OF ARCHITECTURE
PRACTICAL TRAINING PORTFOLIO
(18SAR45023) **JAN 2023 – APR 2023**

Name of the Student : **DHULIPALLA VENKATA SAI PRANAV**

Batch : **2018 - 2023**

Reg No. : **38210024**

Semester : **X**



SATHYABAMA

INSTITUTE OF SCIENCE AND TECHNOLOGY
(DEEMED TO BE UNIVERSITY)

Accredited with “A” grade by NAAC | 12B Status by UGC | Approved by AICTE

Jeppiaar Nagar, Rajiv Gandhi Salai, Chennai – 600 119

www.sathyabama.ac.in

SCHOOL OF BUILDING AND ENVIRONMENT

DEPARTMENT OF ARCHITECTURE

VIVA-VOCE EXAMINATION

This is to certify that the practical training 18SAR5023 is the work of _____ who had undergone training in _____ (Name of the Firm) has been monitored by the continuous assessment during JANUARY 2023 to APRIL 2023.

Dr.Devyani Gangopadhyay
DEAN

Submitted for Viva voce Examination held on _____

Internal Examiner

External Examiner



SATHYABAMA

INSTITUTE OF SCIENCE AND TECHNOLOGY
(DEEMED TO BE UNIVERSITY)

Accredited with “A” grade by NAAC | 12B Status by UGC | Approved by AICTE

Jeppiaar Nagar, Rajiv Gandhi Salai, Chennai – 600 119

www.sathyabama.ac.in

DECLARATION

I, _____ hereby declare that the Training Report **JANUARY 2023 to APRIL 2023** done by me under the guidance of **Ar. _____** is submitted in partial fulfillment of the requirements for the completion of practical training session.

DATE :

PLACE :

SIGNATURE OF CANDIDATE

ACKNOWLEDGEMENT

I am pleased to acknowledge my sincere thanks to **Board of Management of SATHYABAMA** for their kind encouragement in doing this practical training and for completing it successfully. I am grateful to them.

I convey my thanks to **Dr. Devyani Gangopadhyay**, Dean, School of Building and Environment and **Ar.Sarath Chandra Kanth**, Design Chair, Department of Architecture for having been a constant source of support and encouragement.

I wish to express my thanks to all Teaching and Non-teaching staff members of the Department of who were helpful in many ways for the completion of the project.

I also wish to thank **Ar._____**, for the experience of interning at their firm.

JOINING LETTER

DEEJOS®

24-Mar-2023

To,

Head of the Department,
School of Architecture,
Sathyabama University,
Chennai.

SUBJECT: Confirmation of Internship.

Sir,

We hereby confirm that SAI PRANAV (38210024) 5th Year B.Arch student of your institution has been confirmed the professional training in our organization for the period of 90 days from 2th January 2023.

Thanking you,
Yours faithfully,



SuparnaAnup Paul

Reg. No: CA/2017/83475

Principal Architect

DEEJOS Engineers and Contractors Private Limited

MONTHLY REPORT



PROFESSIONAL PRACTICAL TRAINING REPORT 2023

(Monthly Progress to be documented and submitted to the HOD by the Architect in charge of Trainee of the Organization)

1. Name of the Office / Organization : DEEJOS ENGINEERING & CONTRACTORS PVT. LTD.
2. Address & Contact Number : PLATINA, GACHIBOWLI HYDERABAD - 500032.
3. Name of the Student : PRANAV. D.
4. Duration : From 02-01-2023 To 02-02-2023
5. Total No. of days : 25 DAYS.
6. Evaluation of Performance Criteria shall be on

Description of works	Excellent	Good	Fair	Poor	NA
Office Culture Comprehension	✓				
Participation in the Office	✓				
Reading of Drawings	✓				
Presentation Techniques	✓				
Model Making		✓			
Understanding of Construction Details		✓			
Drafting Skills (Manual/Computer)	✓				
Site Supervision / Client Interaction Skills		✓			
Time Schedule Adherence	✓				
Other Computer Skills	✓				
Files and Office Maintenance		✓			
Coordination with other Consultants	✓				
Overall Grading*	EXCELLENT.				

* Note: Kindly grade the student as per his/her overall performance in the office during the assessment month*

7. Any other Remarks:

Signature of the Head of the Office / Organization (With Seal)



PROFESSIONAL PRACTICAL TRAINING REPORT 2023

(Monthly Progress to be documented and submitted to the HOD by the Architect in charge of Trainee of the Organization)

1. Name of the Office / Organization : DEEJOS ENGINEERING & CONTRACTOR PVT. LTD.
2. Address & Contact Number : THE PLATINA, HYDERABAD. 8850330798
3. Name of the Student : PRANAV
4. Duration : From 3-02-2023 To 02-03-2023
5. Total No. of days : 23 DAYS.
6. Evaluation of Performance Criteria shall be on

Description of works	Excellent	Good	Fair	Poor	NA
Office Culture Comprehension		✓			
Participation in the Office		✓			
Reading of Drawings	✓				
Presentation Techniques		✓			
Model Making		✓			
Understanding of Construction Details		✓			
Drafting Skills (Manual/Computer)	✓				
Site Supervision / Client Interaction Skills		✓			
Time Schedule Adherence	✓				
Other Computer Skills		✓			
Files and Office Maintenance	✓				
Coordination with other Consultants	✓				
Overall Grading*	GOOD.				


* Note: Kindly grade the student as per his/her overall performance in the office during the assessment month*

7. Any other Remarks:

Signature of the Head of the Office / Organization (With Seal)



MONTHLY REPORT

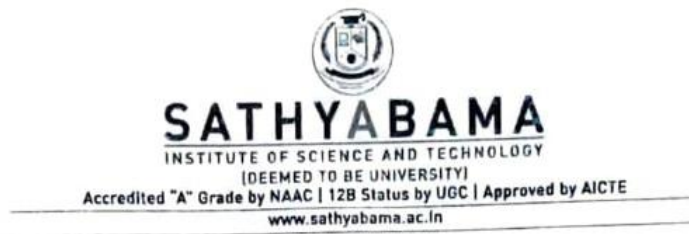

PROFESSIONAL PRACTICAL TRAINING REPORT 2023

(Monthly Progress to be documented and submitted to the HOD by the Architect in charge of Trainee of the Organization)



- Name of the Office / Organization : DEEJOS ENGINEERING & CONTRACTORS PVT LTD
- Address & Contact Number : HYDERABAD.
- Name of the Student : SAI PRANAV
- Duration : From 03-03-2023 To 03-04-2023
- Total No. of days : 25 25
- Evaluation of Performance Criteria shall be on

Description of works	Excellent	Good	Fair	Poor	NA
Office Culture Comprehension	✓				
Participation in the Office	✓				
Reading of Drawings	✓				
Presentation Techniques	✓				
Model Making		✓			
Understanding of Construction Details		✓			
Drafting Skills (Manual/Computer)	✓				
Site Supervision / Client Interaction Skills		✓			
Time Schedule Adherence	✓				
Other Computer Skills	✓				
Files and Office Maintenance	✓				
Coordination with other Consultants	✓				
Overall Grading*	84/90				

* Note: Kindly grade the student as per his/her overall performance in the office during the assessment month*

7. Any other Remarks:

Signature of the Head of the Office / Organization (With Seal)

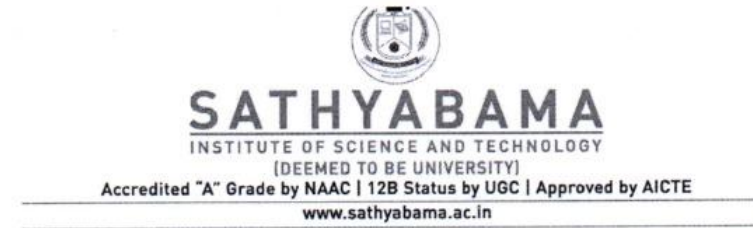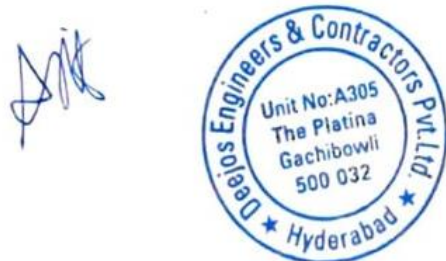

PROFESSIONAL PRACTICAL TRAINING REPORT 2023

(Monthly Progress to be documented and submitted to the HOD by the Architect in charge of Trainee of the Organization)

- Name of the Office / Organization : DEEJOS ENGINEERING & CONTRACTORS PVT LTD.
- Address & Contact Number : HYDERABAD.
- Name of the Student : SAI PRANAV
- Duration : From 4-04-2023 To 25-04-2023.
- Total No. of days : 17
- Evaluation of Performance Criteria shall be on

Description of works	Excellent	Good	Fair	Poor	NA
Office Culture Comprehension	✓				
Participation in the Office	✓				
Reading of Drawings	✓				
Presentation Techniques	✓				
Model Making		✓			
Understanding of Construction Details		✓			
Drafting Skills (Manual/Computer)	✓				
Site Supervision / Client Interaction Skills	✓				
Time Schedule Adherence	✓				
Other Computer Skills	✓				
Files and Office Maintenance	✓				
Coordination with other Consultants	✓				
Overall Grading*	85/90				

* Note: Kindly grade the student as per his/her overall performance in the office during the assessment month*

7. Any other Remarks:

Signature of the Head of the Office / Organization (With Seal)



WORK DAIRY

DATE	WORK DONE
02-01-2023	East Facing Villa Plan
03-01-2023	East Facing Villa Plan
04-01-2023	East Facing Villa Plan
05-01-2023	East Facing Villa Plan
06-01-2023	West Facing Villa Plan
07-01-2023	West Facing Villa Plan
08-01-2023	Sunday
09-01-2023	Took Leave
10-01-2023	Took Leave
11-01-2023	Prem Kumar 3D Elevation (option 1)
12-01-2023	Prem Kumar 3D Elevation (option 2)
13-01-2023	Prem Kumar 3D Elevation (option 2)
14-01-2023	Prem Kumar 3D Elevation (option 3)
15-01-2023	Sunday
16-01-2023	Pongal Holiday
17-01-2023	Prem Kumar 3D Elevation (option 3)
18-01-2023	Mr. Masthan Electrical & Plumbing Drawing
19-01-2023	Mr. Masthan Electrical & Plumbing Drawing
20-01-2023	Mr. Masthan Electrical & Plumbing Drawing
21-01-2023	West Facing Villa Plan
22-01-2023	Sunday
23-01-2023	Mr. Prabhu Plumbing
24-01-2023	Mr. Prabhu Plumbing (corrections)
25-01-2023	Mr. Masthan Electrical & Plumbing (corrections)
26-01-2023	Republic Day Holiday
27-01-2023	Mr. Poovarasana Raja 3D Elevation
28-01-2023	Mr. Poovarasana Raja 3D Elevation
29-01-2023	Sunday
30-01-2023	Mr. Poovarasana Raja 3D Elevation
31-01-2023	Mr. Cyril 2D Elevation
01-02-2023	Mr. Cyril 2D Elevation
02-02-2023	Mr. Cyril 2D Elevation
03-02-2023	Mr. Cyril 2D Elevation
04-02-2023	Mr. Cyril 2D Elevation
05-02-2023	Sunday
06-02-2023	Mr. Raina Base Model
07-02-2023	Mr. Raina Base Model
08-02-2023	Mrs. Lavanya Schematic Drawing (Option 1)
09-02-2023	Mrs. Lavanya Schematic Drawing (Option 1)
10-02-2023	Mrs. Lavanya Schematic Drawing (Option 1)
11-02-2023	Mr. Murugan 3D Elevation
12-02-2023	Sunday
13-02-2023	Mr. Murugan 3D Elevation
14-02-2023	Mr. Murugan 3D Elevation

DATE	WORK DONE
15-02-2023	Mr. Murugan 3D Elevation
16-02-2023	Mr. Murugan 3D Elevation Render
17-02-2023	Mrs. Lavanya Schematic Drawing (Option 2)
18-02-2023	Mrs. Lavanya Schematic Drawing (Option 2)
19-02-2023	Sunday
20-02-2023	Mrs. Lavanya Schematic Drawing (Option 2)
21-02-2023	Took Leave
22-02-2023	Took Leave
23-02-2023	Mrs. Lavanya Schematic Drawing (Option 2)
24-02-2023	Mr. Rajaguru Plumbing Drawing
25-02-2023	Mrs. Lavanya Schematic Drawing (corrections)
26-02-2023	Sunday
27-02-2023	Searched References For Given Base Model
28-02-2023	Mr. Vinod 2D Elevation
01-03-2023	Took Leave
02-03-2023	Took Leave
03-03-2023	Mr. Vinod 2D Elevation
04-03-2023	Worked on Ramprasad Schematic Drawing
05-03-2023	Sunday
06-03-2023	Worked on Ramprasad Schematic Drawing
07-03-2023	Took Leave
08-03-2023	Sivagami sundari- base model
09-03-2023	sivagami sundari- 3D elevation
10-03-2023	sivagami sundari- 3D elevation
11-03-2023	Poovarasana raja- 3D elevation
12-03-2023	Sunday
13-03-2023	Poovarasana raja- 3D elevation
14-03-2023	Thayanithi- paint board, Anand 3d elevation
15-03-2023	Anand 3d elevation
16-03-2023	visiting card design, Sasi kumar plumbing drawing
17-03-2023	Anand 3d elevation , Mr. Vasanth Madipakkam excel sheet
18-03-2023	MH Raja electrical drawing
19-03-2023	Sunday
20-03-2023	MH Raja electrical drawing, Sasi kumar plumbing drawing
21-03-2023	MH Raja electrical drawing, Sasi kumar plumbing drawing
22-03-2023	Ugadi Holiday
23-03-2023	Pradeep plumbing
24-03-2023	Pradeep plumbing, Sivagami Sundari Half Layout
25-03-2023	Pradeep Electrical
26-03-2023	Sunday
27-03-2023	Pradeep Electrical
28-03-2023	MH Raja 3d elevation
29-03-2023	MH Raja 3d elevation, Satish kumar base model
30-03-2023	Satish kumar base model
31-03-2023	Satish kumar Elevation

WORK DAIRY

DATE	WORK DONE
01-04-2023	Satish kumar Elevation
02-04-2023	Sunday
03-04-2023	Vivek Anand electrical, sivagami sundari half layout
04-04-2023	Vivek Anand electrical
05-04-2023	Vivek Anand electrical
06-04-2023	Mr. Ramprasad elevation references
07-04-2023	Satish kumar Half Layout Rendering
08-04-2023	Kanhaiya Kumar- Mood Board, Mr. Vasanth pergola design
09-04-2023	Sunday
10-04-2023	Sivagami sundari half layout
11-04-2023	Took Leave
12-04-2023	Poovarasana Raja 2d Elevation
13-04-2023	Poovarasana Raja 2d Elevation, Poovarasana Raja Electrical
14-04-2023	Poovarasana Raja 2d Elevation, Prem Kumar Rendering
15-04-2023	Poovarasana Raja Plumbing
16-04-2023	Sunday
17-04-2023	Prem Kumar 2d Elevation, Prem Kumar 3d rendering
18-04-2023	Prem kumar 2d Elevation
19-04-2023	Prem kumar 2d Elevation
20-04-2023	Dinesh kumar half layout
21-04-2023	Dinesh kumar half layout
22-04-2023	Ramzan Holiday
23-04-2023	Sunday
24-04-2023	Dinesh kumar half layout rendering
25-04-2023	Prem kumar 2d Elevation

Seal of the firm

Name & Signature of the Architect

CONSOLIDATED CERTIFICATE

DEEJOS[®]

26-04-2023
Chennai

To,
The Head of the Department,
Architecture Department,
Sathyabama Institute of Science and Technology,
Jepplaar Nagar, Rajiv Gandhi Salai, Chennai - 600 119

SUB: INTERNSHIP COMPLETION LETTER.

We are pleased to announce that Mr. Sai Pranav, a student at Sathyabama Institute of Science and Technology, has successfully completed his internship with us from January 02, 2023 to April 25, 2023.

Throughout his internship, Mr. Sai Pranav was tasked with a variety of activities, including schematic concept development, drafting, 3D elevation designs, and interiors. He demonstrated a keen ability to learn and develop his skills, and his performance and dedication to his work were exceptional.

His association with us was extremely productive, we wish him all the best in his future endeavors.

For DEEJOS Engineers and Contractors Pvt. Ltd.



(Authorized Signatory)

Regd. Address: **DEEJOS** Engineers & Contractors Pvt Ltd., First floor, No:1, C.L.C Works Road, Chrompet, Chennai - 600 044.
CIN : U45203TN2008PTC068974 GSTIN : 33AACCD9616N2ZC 72008 60084 projects@deejos.com www.deejos.com

DEEJOS[®]

Performance Factors		Rating out of 10
Disciplines	Scheme Approval/ Presentation	8
	Model Making	7
	Working Drawings	8
	Interiors	8
Attributes	Attendance/ Punctuality	8
	Enthusiasm for Experience	8
	Adherence to schedule	8
	Understanding client requirements	8
	Communication Skill	8
	Listening and interpretation, Establishing rapport	8

	Exceptional	Good	Average	Poor
Overall Performance		✓		

 Principal Architect 
(Suparna Paul)
(CA/2017/83475)

Regd. Address: **DEEJOS** Engineers & Contractors Pvt Ltd., First floor, No:1, C.L.C Works Road, Chrompet, Chennai - 600 044.
CIN : U45203TN2008PTC068974 GSTIN : 33AACCD9616N2ZC 72008 60084 projects@deejos.com www.deejos.com

ABOUT THE FIRM:

DEEJOS Architects is a premier Construction and Architectural firm founded in 2008 by **Mr. Dennis Ebenezar**, a first-generation entrepreneur who has a passion for design and construction. With over **15 years** of experience in providing turnkey construction services for residential projects. DEEJOS Architects has become a household name in the construction industry in India.

The company has its head office in Chennai, with additional branches in Bangalore, Coimbatore, Pondicherry, and Hyderabad. This geographical reach enables **DEEJOS Architects** to cater to clients across South India, offering its services to a broad client base

DEEJOS Architects has completed over 750 residential projects to date, with a team of over 2000+ skilled and dedicated labourers. The company's projects range from individual homes and apartments to large-scale housing developments, each one designed and executed to meet the specific requirements of the client.

The company's success lies in its ability to provide a high level of service and quality to clients. The team of architects and designers work closely with clients to understand their needs and preferences, and create a design that is not only aesthetically pleasing but also functional and sustainable.

DEEJOS uses cutting-edge technology and software for project management, internal communications and to create detailed **3D models** of each project, giving clients a realistic view of what their finished home will look like. The company is also committed to using **eco-friendly materials and energy efficient systems, making its projects environmentally responsible**

CONTENTS

1. MR. ANAND RESIDENCE
2. MR. CYRIL RESIDENCE
3. MR. DINESH KUMAR RESIDENCE
4. MRS. LAVANYA RESIDENCE
5. MR. MASTHAN RESIDENCE
6. MR. MH. RAJA RESIDENCE
7. MR. MURUGAN RESIDENCE
8. MR. POOVARASAN RAJA RESIDENCE
9. MR. PRABJU RESIDENCE
10. MR. PRADHEEP RESIDENCE

11. MR. PREM KUMAR RESIDENCE
12. MR. RAINA RESIDENCE
13. MR. RAJAGURU RESIDENCE
14. MR. RAMPRASAD COMMERCIAL BUILDING
15. MR. SASI KUMAR RESIDENCE
16. MR. SATHISH KUMAR RESIDENCE
17. MRS. SIVAGAMI SUNDARI RESIDENCE
18. MR. VASANTH RESIDENCE
19. MR. VINOD RESIDENCE
20. MR. VIVEK ANAND RESIDENCE





OPTION 1

DRAWING TITLE:

Mr. Anand Residence 3D
Elevation

CLIENT:

Mr. Anand

ARCHITECTURAL DESIGNERS:

**DEEJOS ENGINEERS AND
CONTRACTORS PVT Ltd**

2nd floor, C.L.C. Road, Chrompet,
Chennai-600 044,
Mobile: +91-8110000384
Email: projects@deejos.com

SIGNATURE & SEAL:

ORIENTATION:





OPTION 2

DRAWING TITLE:

Mr. Anand Residence 3D
Elevation

CLIENT:

Mr. Anand

ARCHITECTURAL DESIGNERS:


**DEEJOS ENGINEERS AND
CONTRACTORS PVT Ltd**

2nd floor, C.L.C. Road, Chrompet,
Chennai-600 044,
Mobile: +91-8110000384
Email: projects@deejos.com

SIGNATURE & SEAL:

ORIENTATION:



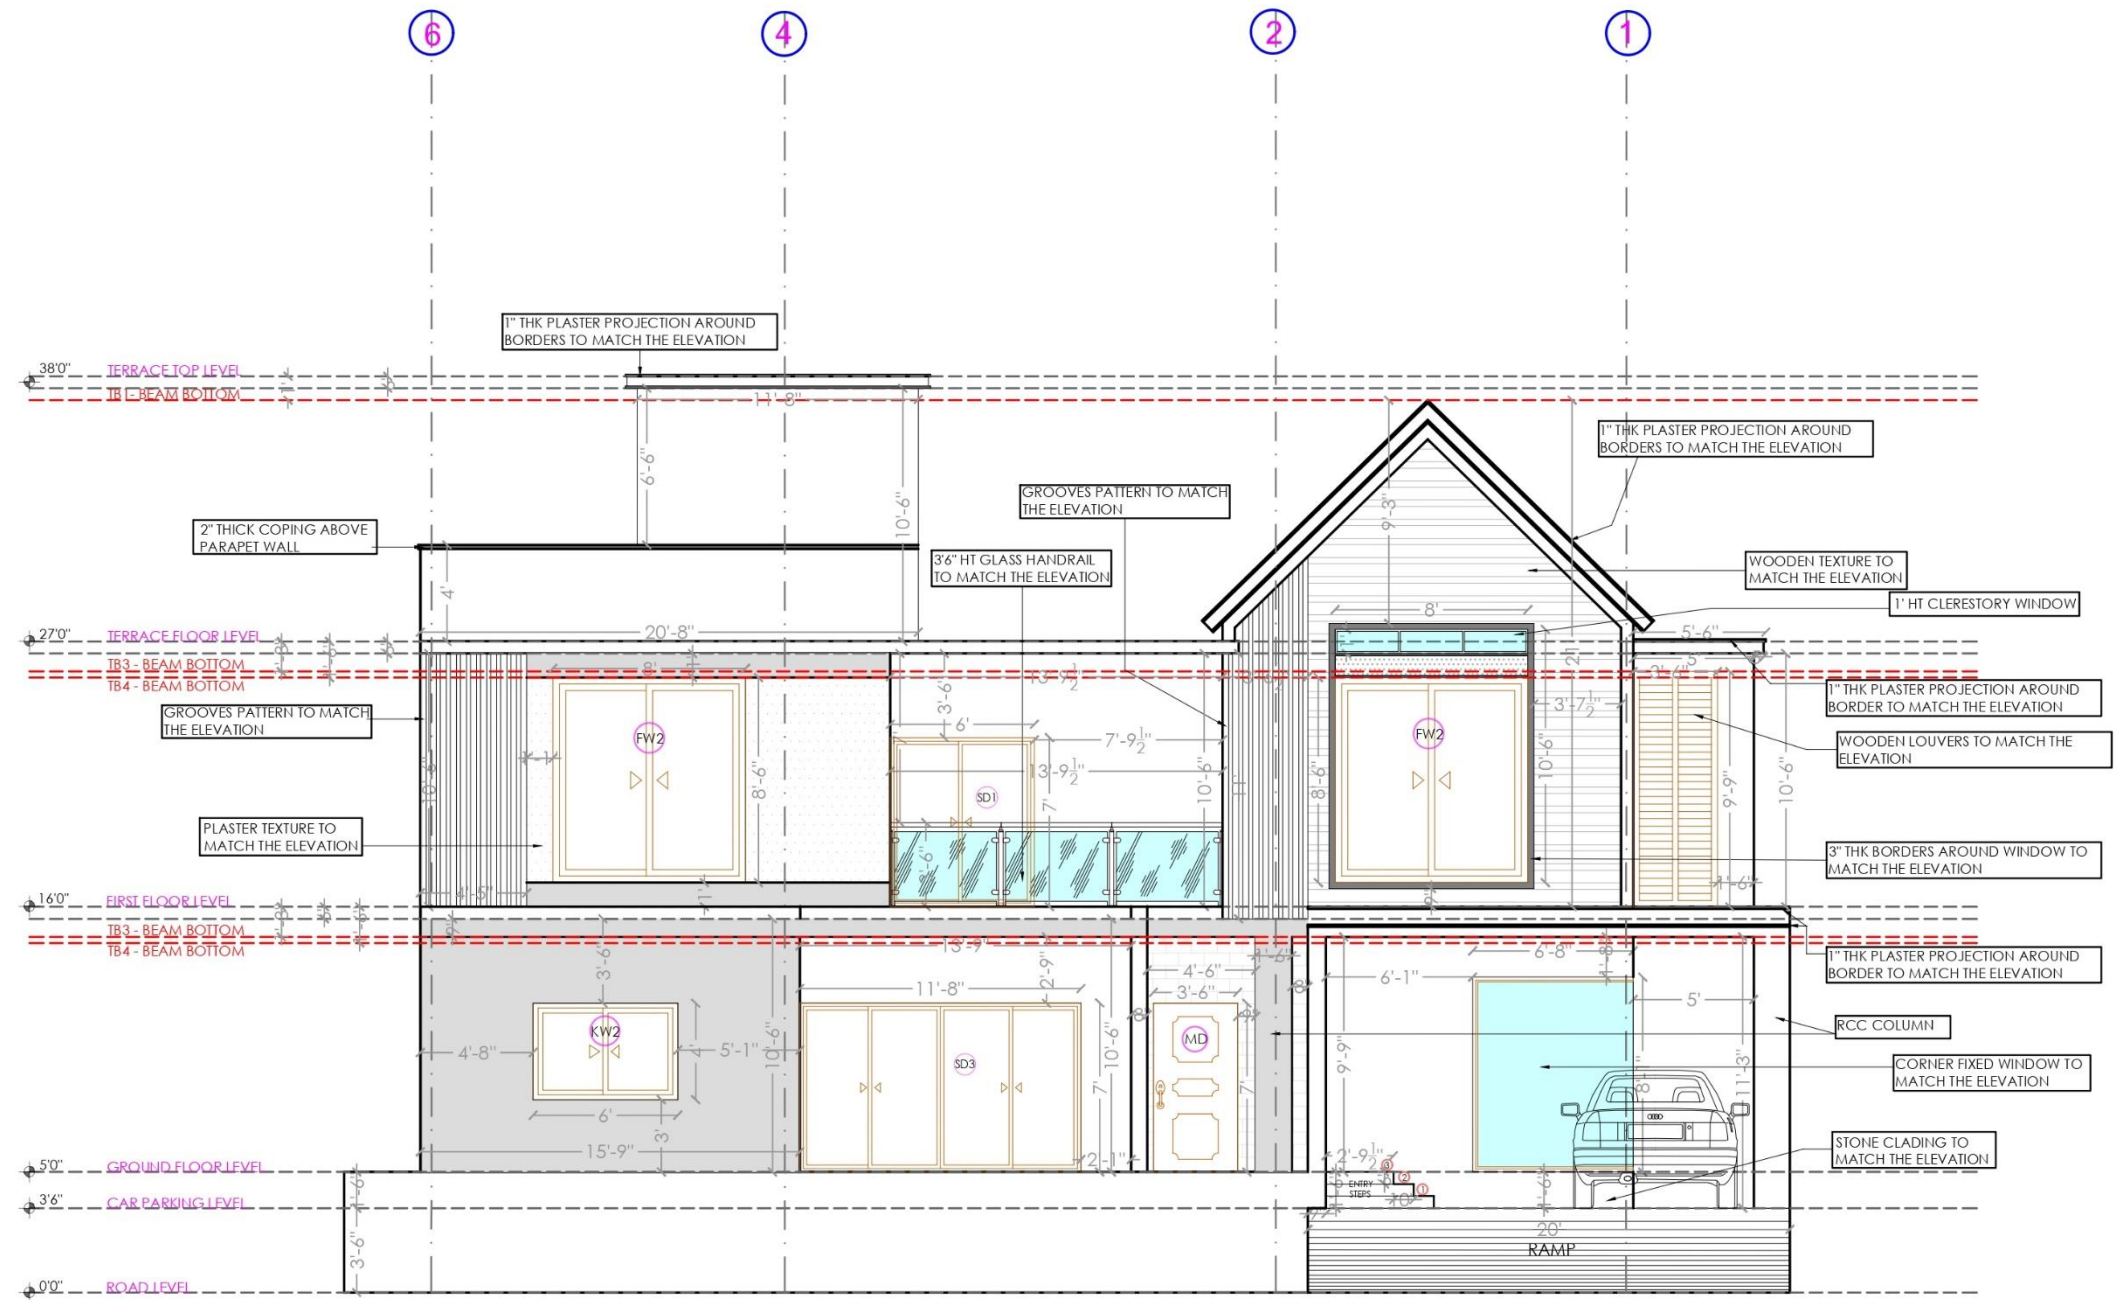

WEST ELEVATION

DRAWING TITLE:

Mr. Cyril Residence 2D
Elevation

CLIENT:

Mr. Cyril


ARCHITECTURAL DESIGNERS:


**DEEJOS ENGINEERS AND
CONTRACTORS PVT Ltd**

2nd floor, C.L.C. Road, Chrompet,
Chennai-600 044,
Mobile: +91-8110000384
Email: projects@deejos.com

SIGNATURE & SEAL:

ORIENTATION:

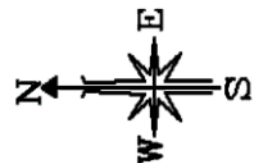

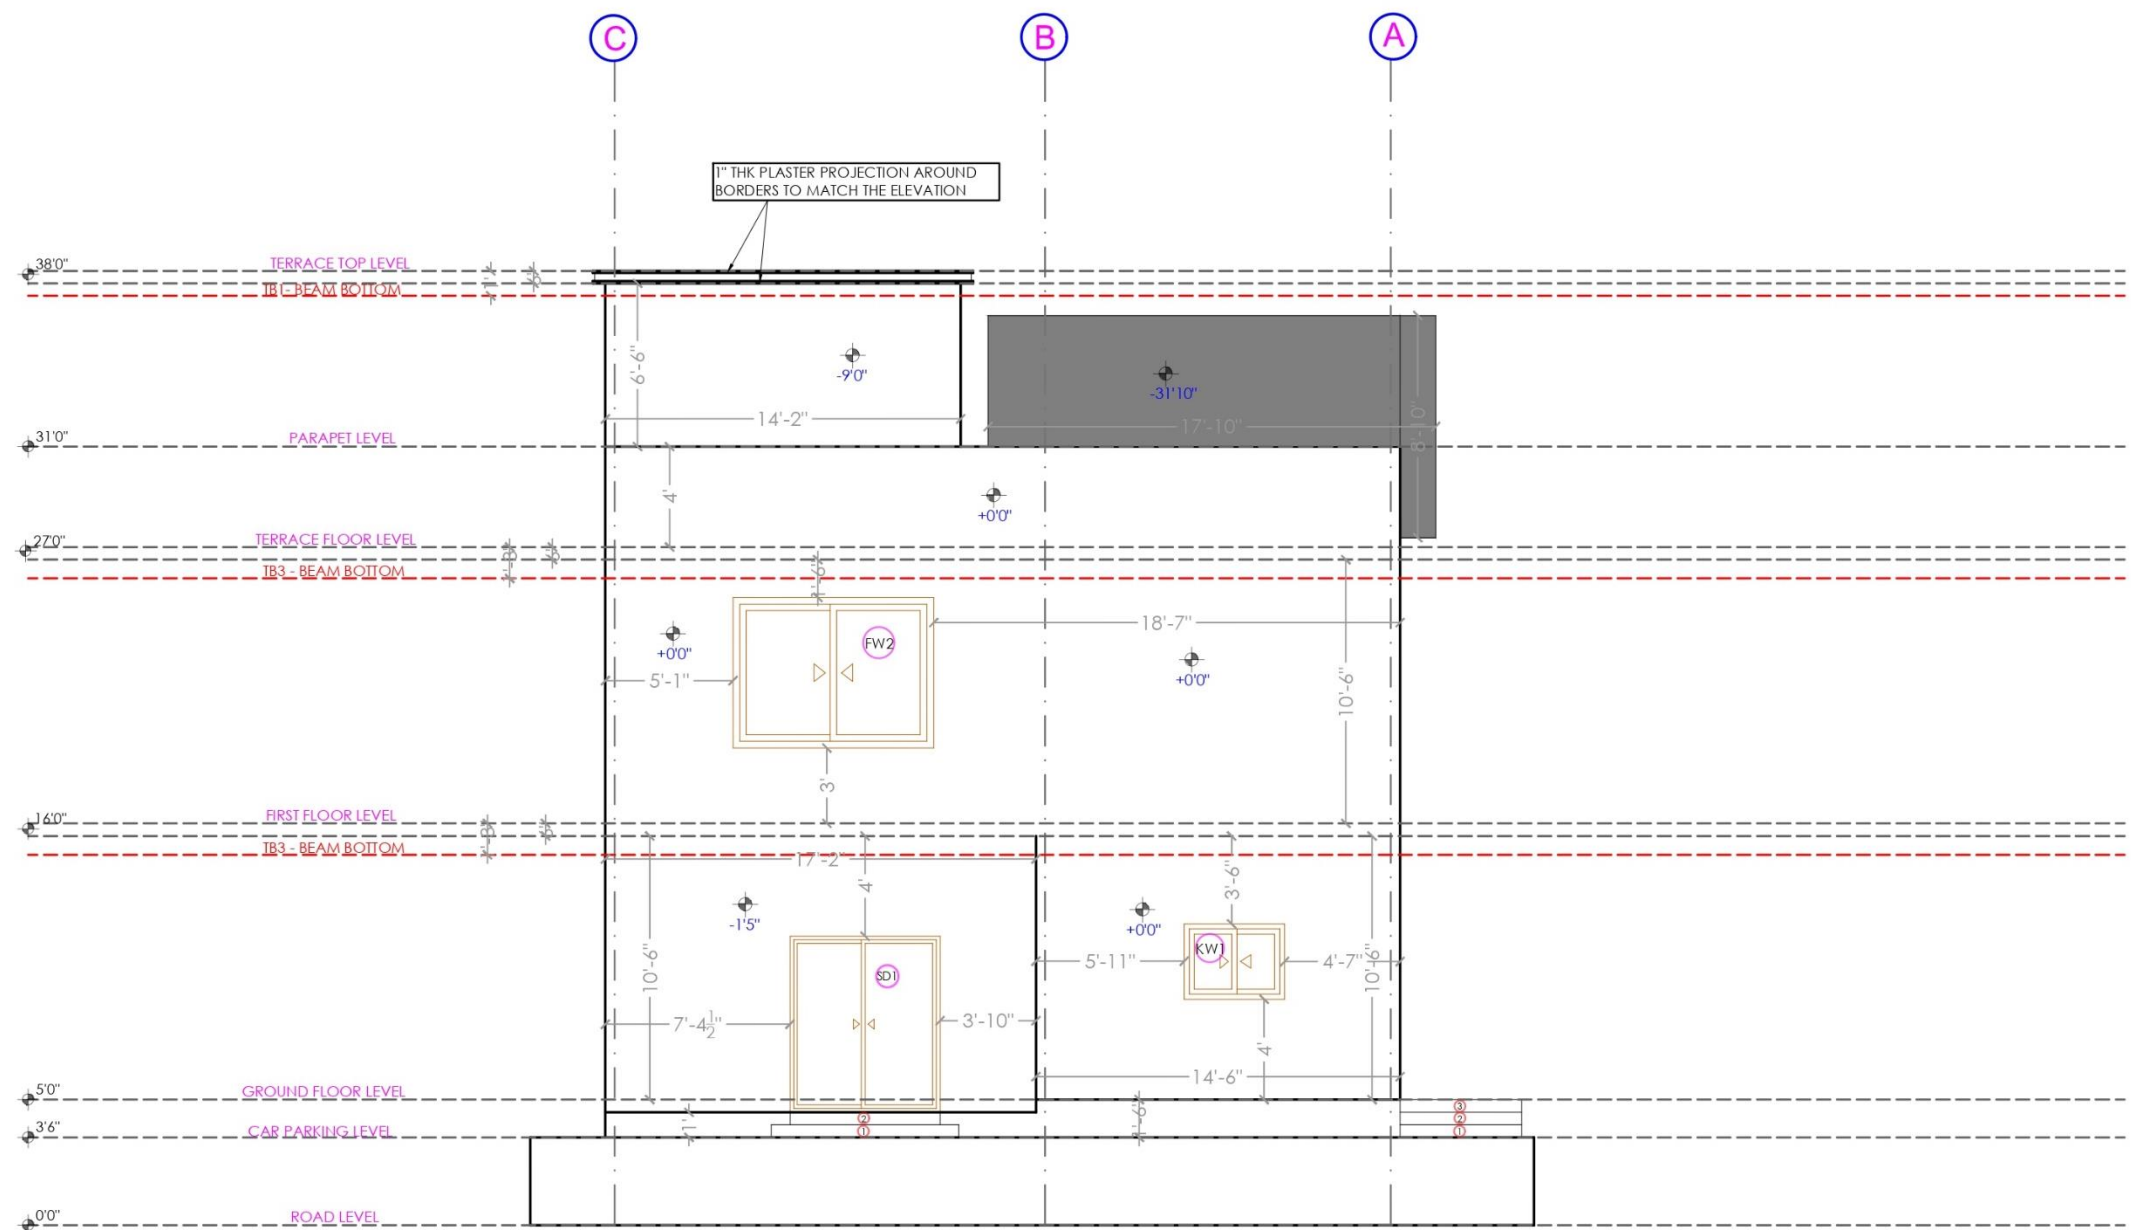

NORTH ELEVATION

DRAWING TITLE:

Mr. Cyril Residence 2D
Elevation

CLIENT:

Mr. Cyril


ARCHITECTURAL DESIGNERS:

**DEEJOS ENGINEERS AND
CONTRACTORS PVT Ltd**

2nd floor, C.L.C. Road, Chrompet,
Chennai-600 044,
Mobile: +91-8110000384
Email: projects@deejos.com

SIGNATURE & SEAL:

ORIENTATION:

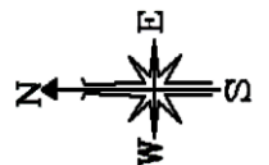



GROUND FLOOR

DRAWING TITLE:

Mr. Dinesh Kumar Residence
Half Layout

CLIENT:

Mr. Dinesh Kumar

ARCHITECTURAL DESIGNERS:

**DEEJOS ENGINEERS AND
CONTRACTORS PVT Ltd**

2nd floor, C.L.C. Road, Chrompet,
Chennai-600 044,
Mobile: +91-8110000384
Email: projects@deejos.com

SIGNATURE & SEAL:

ORIENTATION:





FIRST FLOOR

DRAWING TITLE:

Mr. Dinesh Kumar Residence
Half Layout

CLIENT:

Mr. Dinesh Kumar

ARCHITECTURAL DESIGNERS:


**DEEJOS ENGINEERS AND
CONTRACTORS PVT Ltd**

2nd floor, C.L.C. Road, Chrompet,
Chennai-600 044,
Mobile: +91-8110000384
Email: projects@deejos.com


SIGNATURE & SEAL:

ORIENTATION:



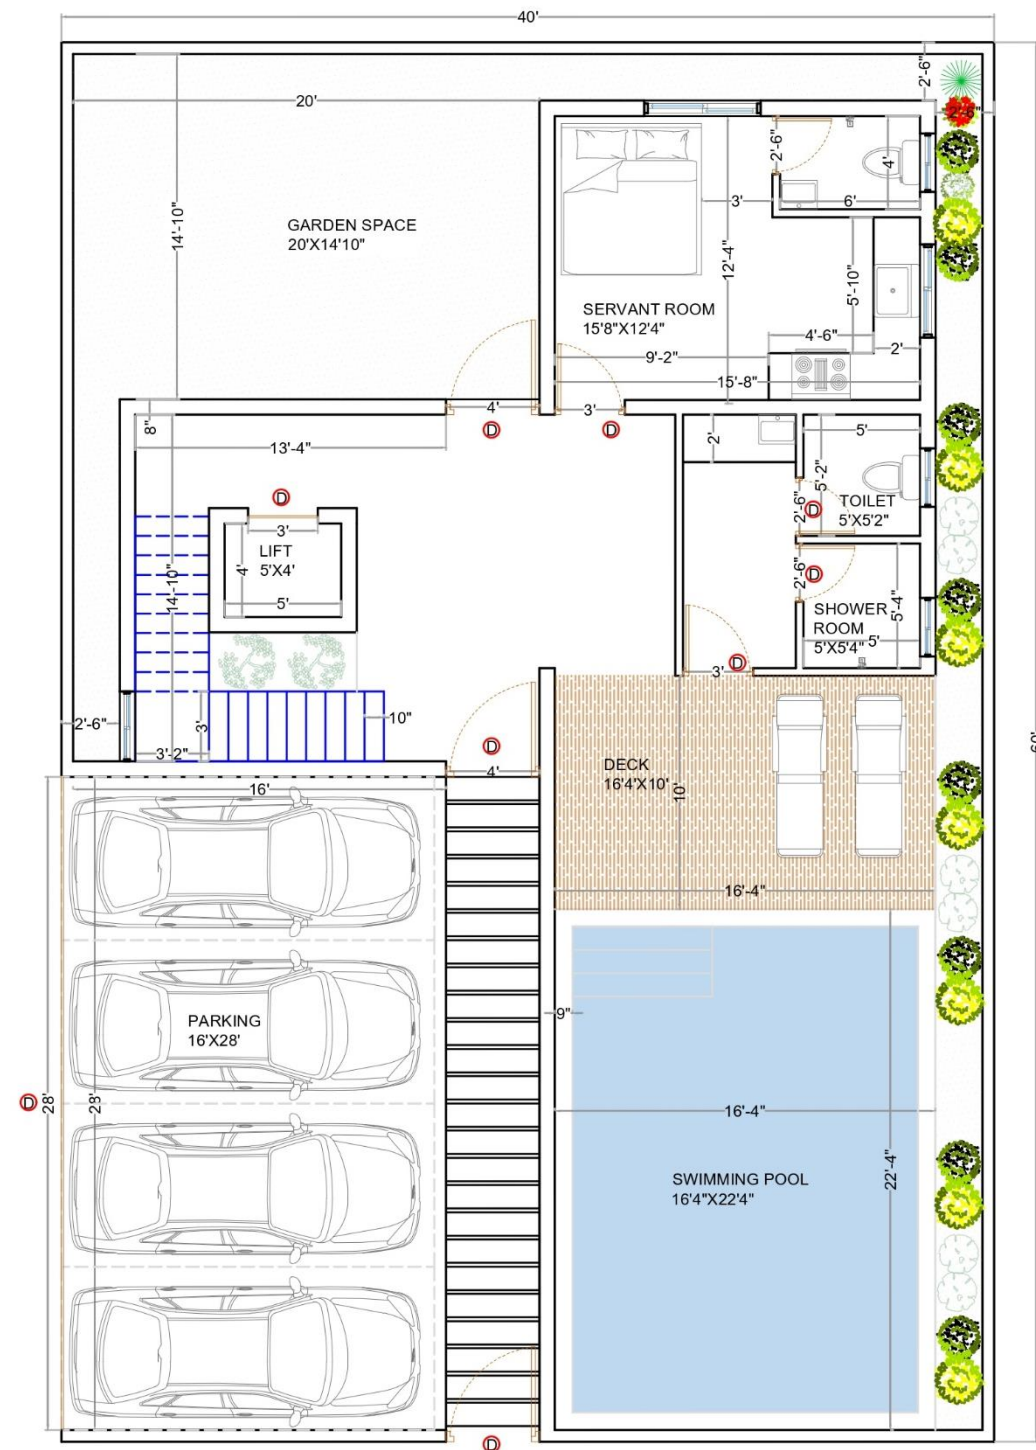

GROUND FLOOR

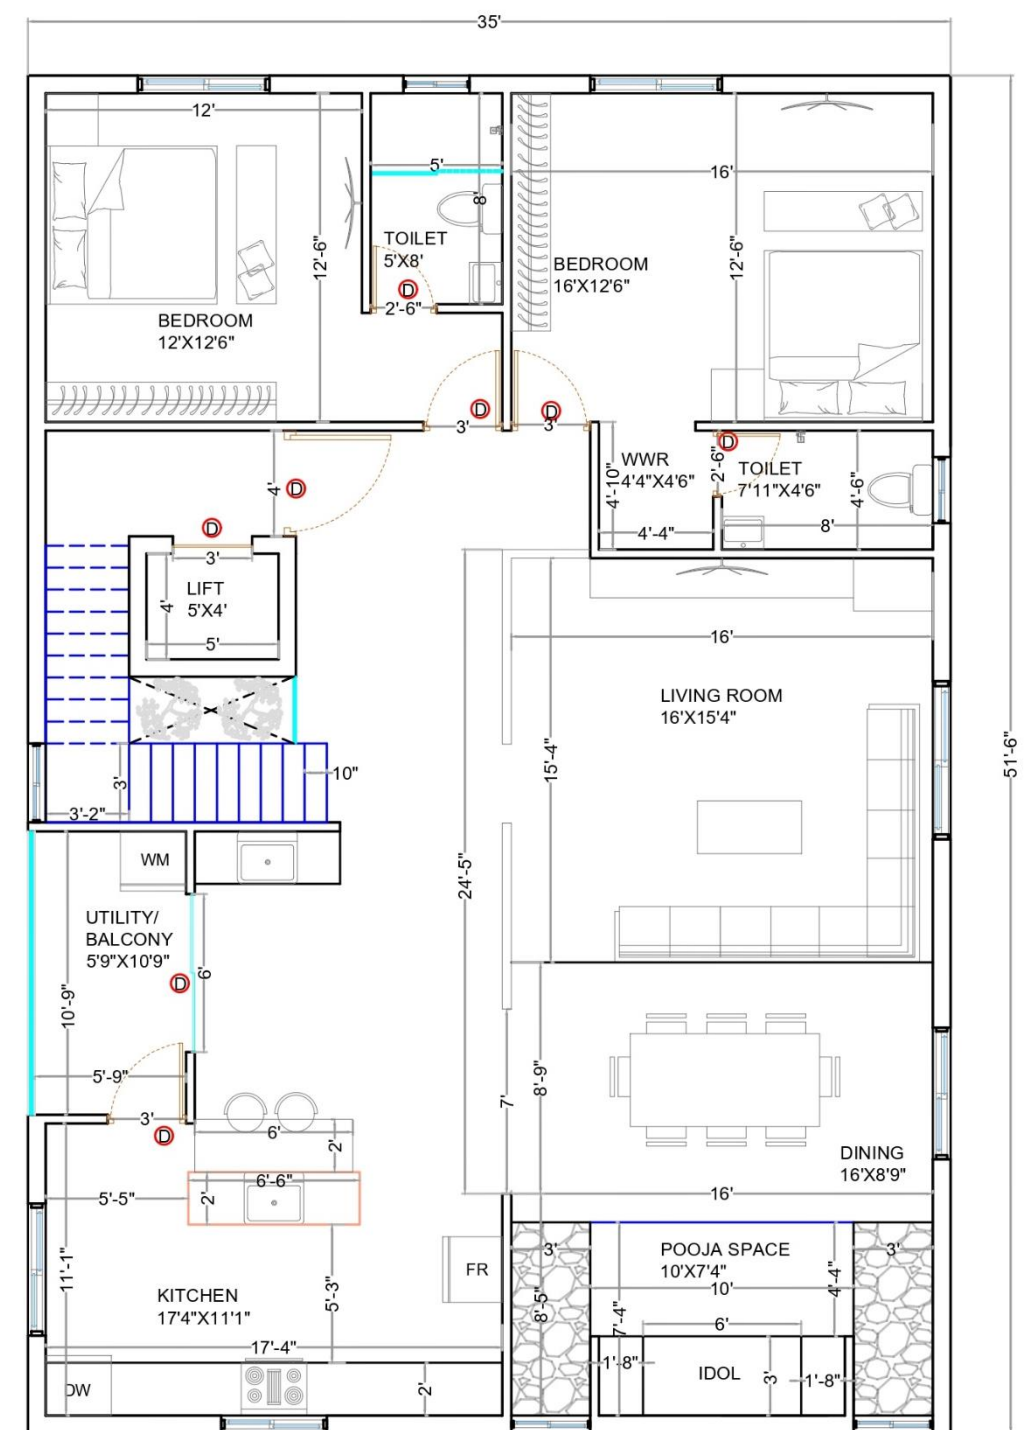

FIRST FLOOR

DRAWING TITLE:

Mrs. Lavanya Residence
Schematic Drawing (Option 1)

CLIENT:

Mrs. Lavanya


ARCHITECTURAL DESIGNERS:


**DEEJOS ENGINEERS AND
CONTRACTORS PVT Ltd**

2nd floor, C.L.C. Road, Chrompet,
Chennai-600 044,
Mobile: +91-8110000384
Email: projects@deejos.com

SIGNATURE & SEAL:

ORIENTATION:

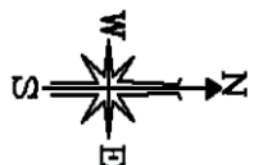

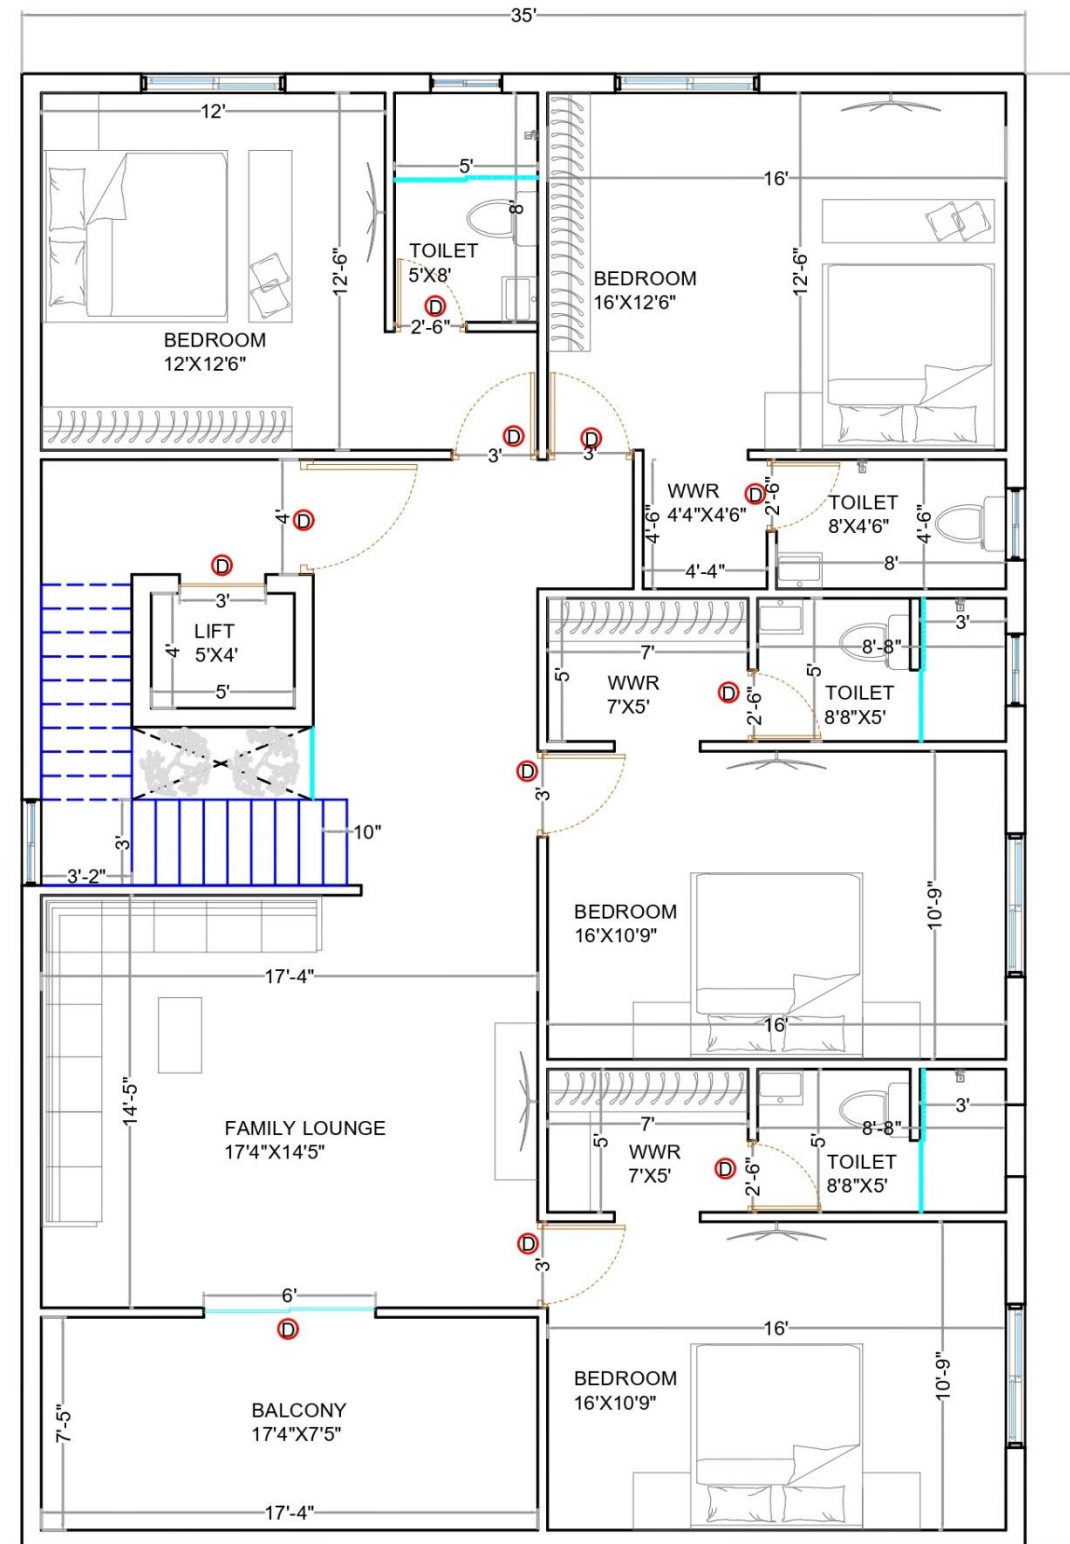

SECOND FLOOR

DRAWING TITLE:

Mrs. Lavanya Residence
Schematic Drawing (Option 1)

CLIENT:

Mrs. Lavanya


ARCHITECTURAL DESIGNERS:



**DEEJOS ENGINEERS AND
CONTRACTORS PVT Ltd**

2nd floor, C.L.C. Road, Chrompet,
Chennai-600 044,
Mobile: +91-8110000384
Email: projects@deejos.com

SIGNATURE & SEAL:

ORIENTATION:

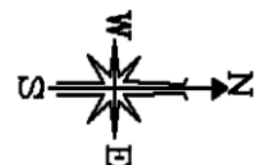

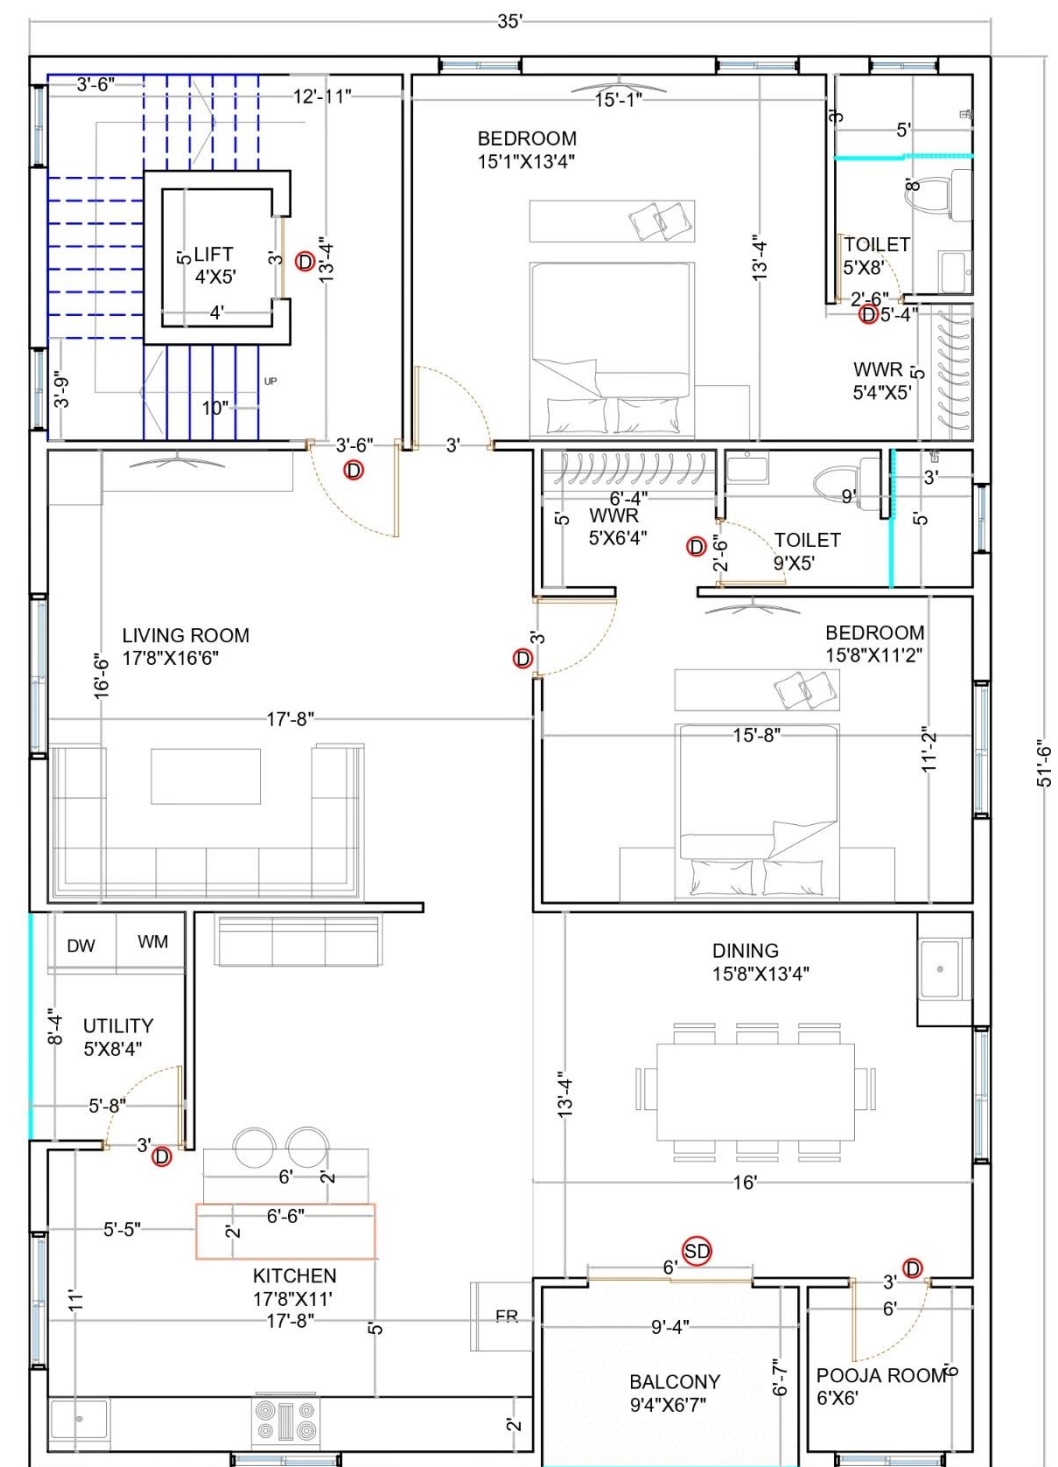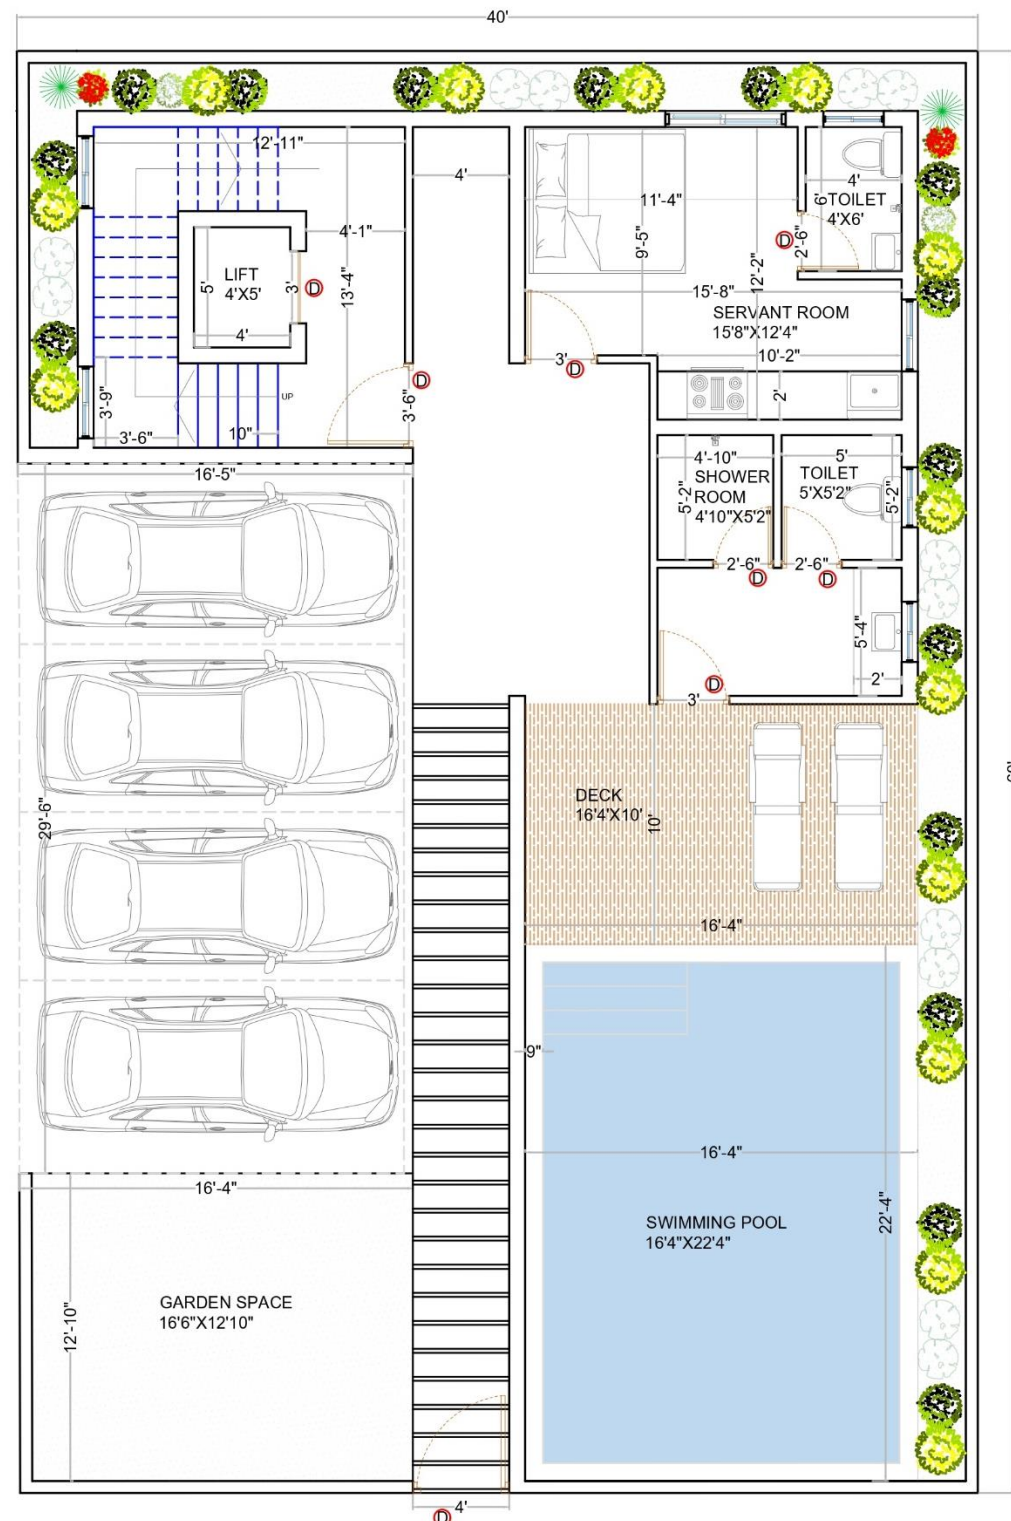

DRAWING TITLE:

Mrs. Lavanya Residence
Schematic Drawing (Option 2)

CLIENT:

Mrs. Lavanya


ARCHITECTURAL DESIGNERS:


**DEEJOS ENGINEERS AND
CONTRACTORS PVT Ltd**

2nd floor, C.L.C. Road, Chrompet,
Chennai-600 044,
Mobile: +91-8110000384
Email: projects@deejos.com

SIGNATURE & SEAL:

ORIENTATION:

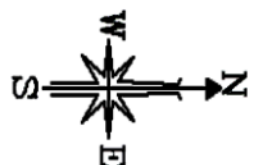

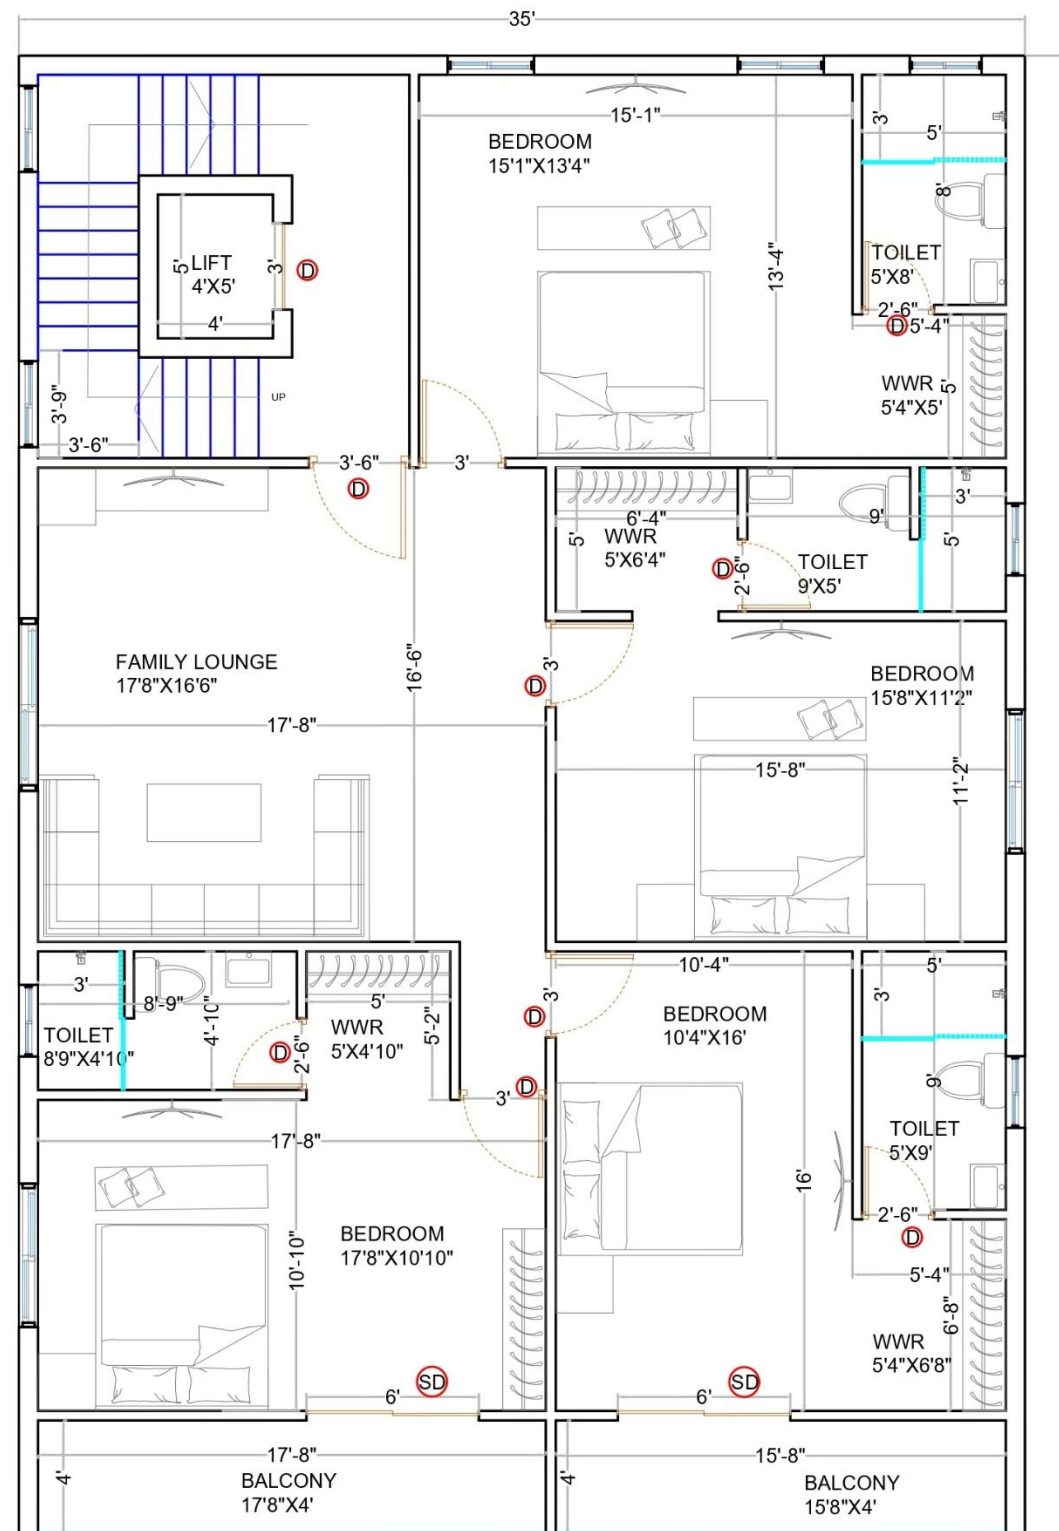

SECOND FLOOR

DRAWING TITLE:

Mrs. Lavanya Residence
Schematic Drawing (Option 2)

CLIENT:

Mrs. Lavanya


ARCHITECTURAL DESIGNERS:


**DEEJOS ENGINEERS AND
CONTRACTORS PVT Ltd**

2nd floor, C.L.C. Road, Chrompet,
Chennai-600 044,
Mobile: +91-8110000384
Email: projects@deejos.com

SIGNATURE & SEAL:

ORIENTATION:

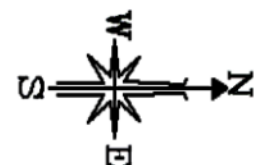

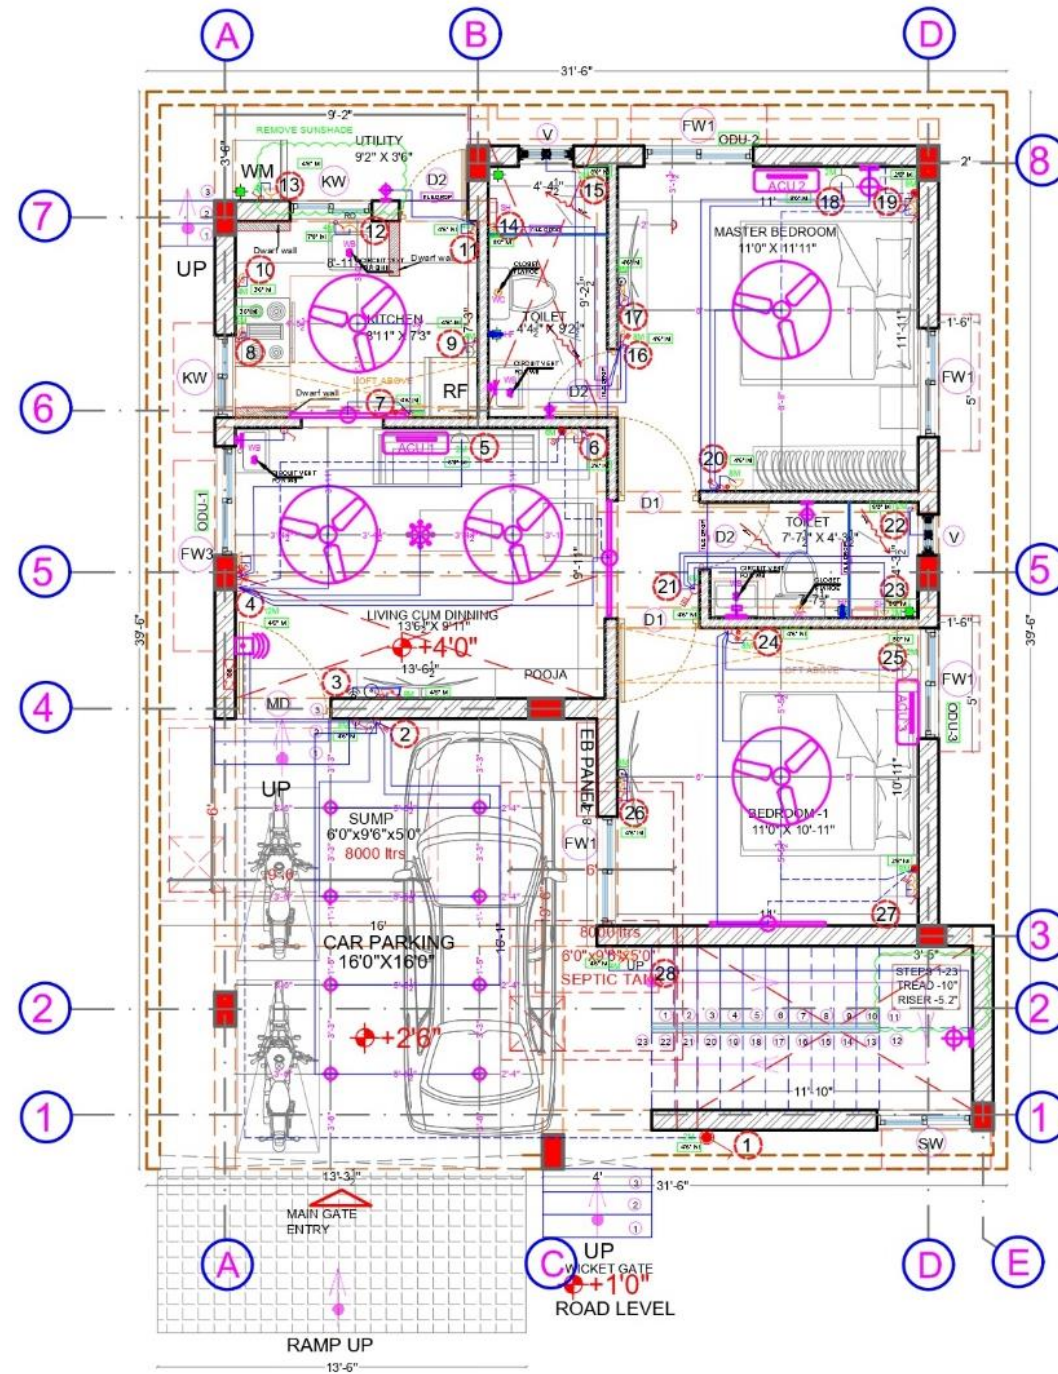

CAR PARKING AREA - 231 SQ FT
GROUND FLOOR AREA - 985 SQ FT

LEGEND	
	CEILING FAN
	AIR CONDITIONER / AC TRIP SWITCH
	FLOURESCENT LIGHT
	SPOT LIGHT
	WALL LIGHT
	CHANDLIER
	MIRROR LAMP
	CALLING BELL
	EXHAUST FAN
	GEYSER
	DISTRIBUTION BOARD
	U HOOK
	JHULA HOOK
	15A SOCKET
	10A SOCKET
	SOCKET FOR RO
	SOCKET FOR CHIMNEY
	REGULATOR
	SINGLE GANG SWITCH
	DOUBLE GANG SWITCH
	TRIPLE GANG SWITCH
	SINGLE TWO WAY SWITCH
	DOUBLE TWO WAY SWITCH
	TV AND INTERNET POINT
	WALL FAN

GROUND FLOOR

DRAWING TITLE:

Mr. Masthan Residence
Electrical Drawing

CLIENT:

Mr. Masthan


ARCHITECTURAL DESIGNERS:


**DEEJOS ENGINEERS AND
CONTRACTORS PVT Ltd**

2nd floor, C.L.C. Road, Chrompet,
Chennai-600 044,
Mobile: +91-8110000384
Email: projects@deejos.com

SIGNATURE & SEAL:

ORIENTATION:

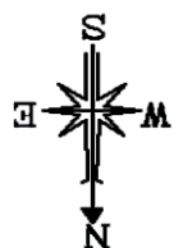

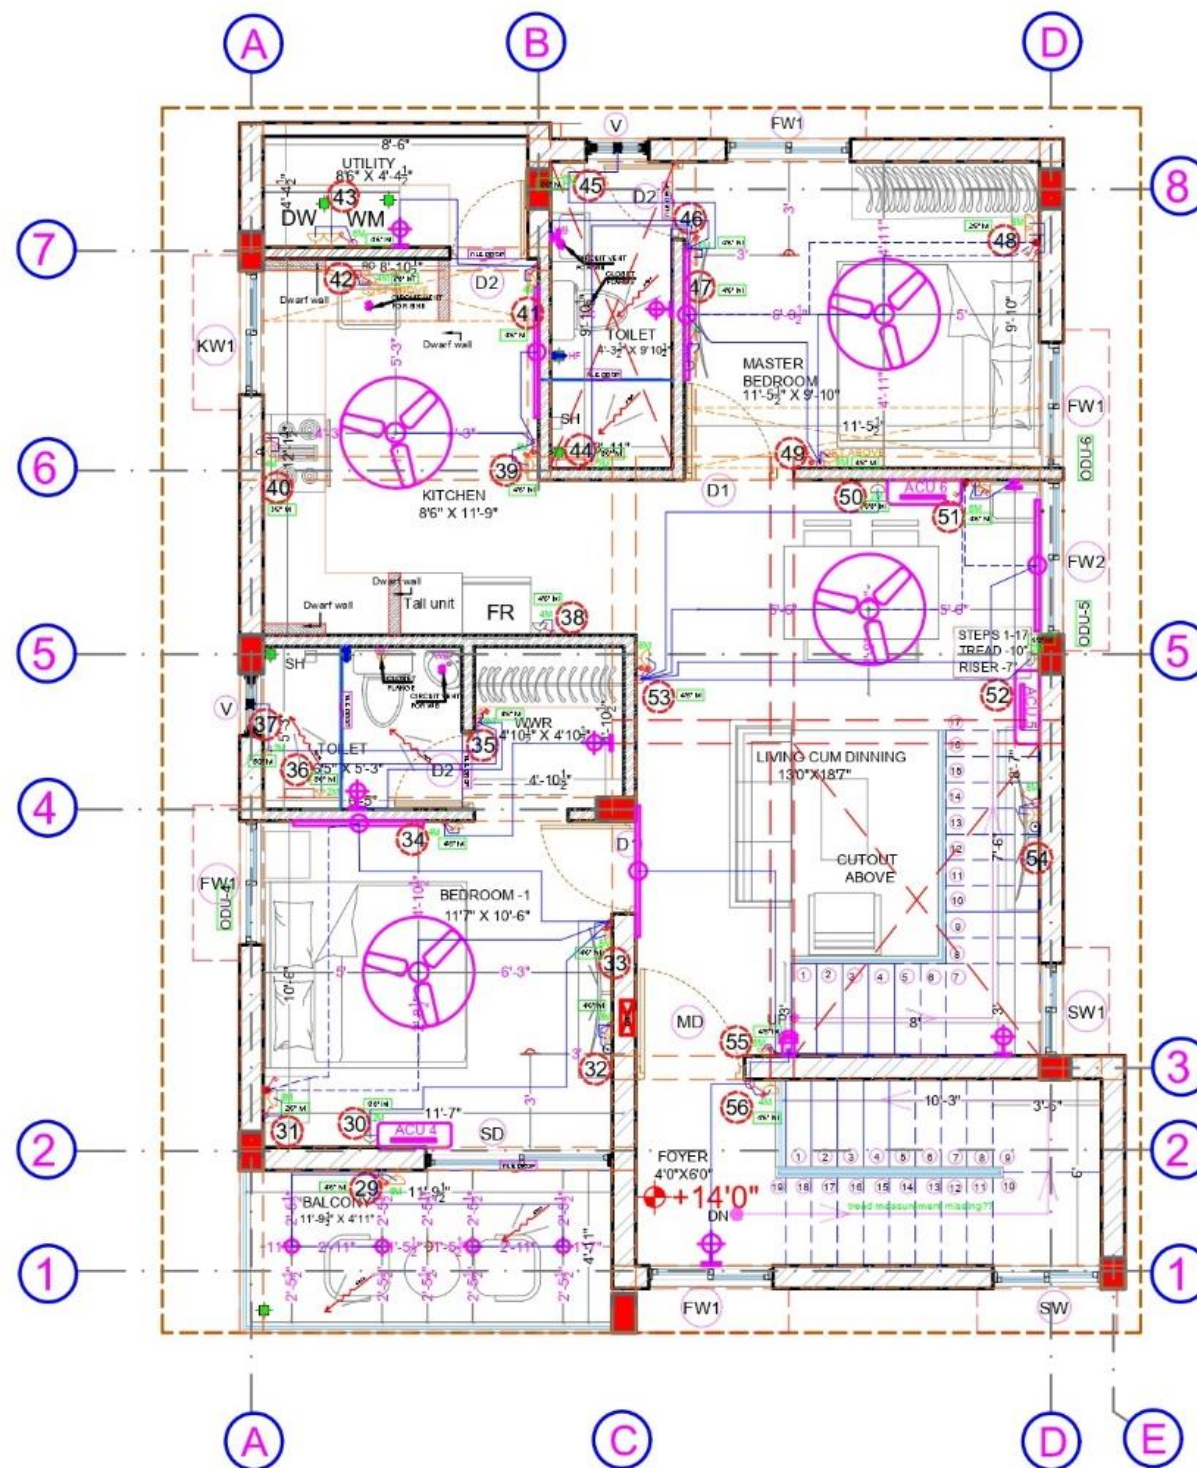

LEGEND	
	CEILING FAN
	AIR CONDITIONER / AC TRIP SWITCH
	FLOURESCENT LIGHT
	SPOT LIGHT
	WALL LIGHT
	CHANDLIER
	MIRROR LAMP
	CALLING BELL
	EXHAUST FAN
	GEYSER
	DISTRIBUTION BOARD
	U HOOK
	JHULA HOOK
	15A SOCKET
	10A SOCKET
	SOCKET FOR RO
	SOCKET FOR CHIMNEY
	REGULATOR
	SINGLE GANG SWITCH
	DOUBLE GANG SWITCH
	TRIPLE GANG SWITCH
	SINGLE TWO WAY SWITCH
	DOUBLE TWO WAY SWITCH
	TV AND INTERNET POINT
	WALL FAN

FIRST FLOOR

DRAWING TITLE:

Mr. Masthan Residence
Electrical Drawing

CLIENT:

Mr. Masthan

ARCHITECTURAL DESIGNERS:


**DEEJOS ENGINEERS AND
CONTRACTORS PVT Ltd**

2nd floor, C.L.C. Road, Chrompet,
Chennai-600 044,
Mobile: +91-8110000384
Email: projects@deejos.com

SIGNATURE & SEAL:

ORIENTATION:



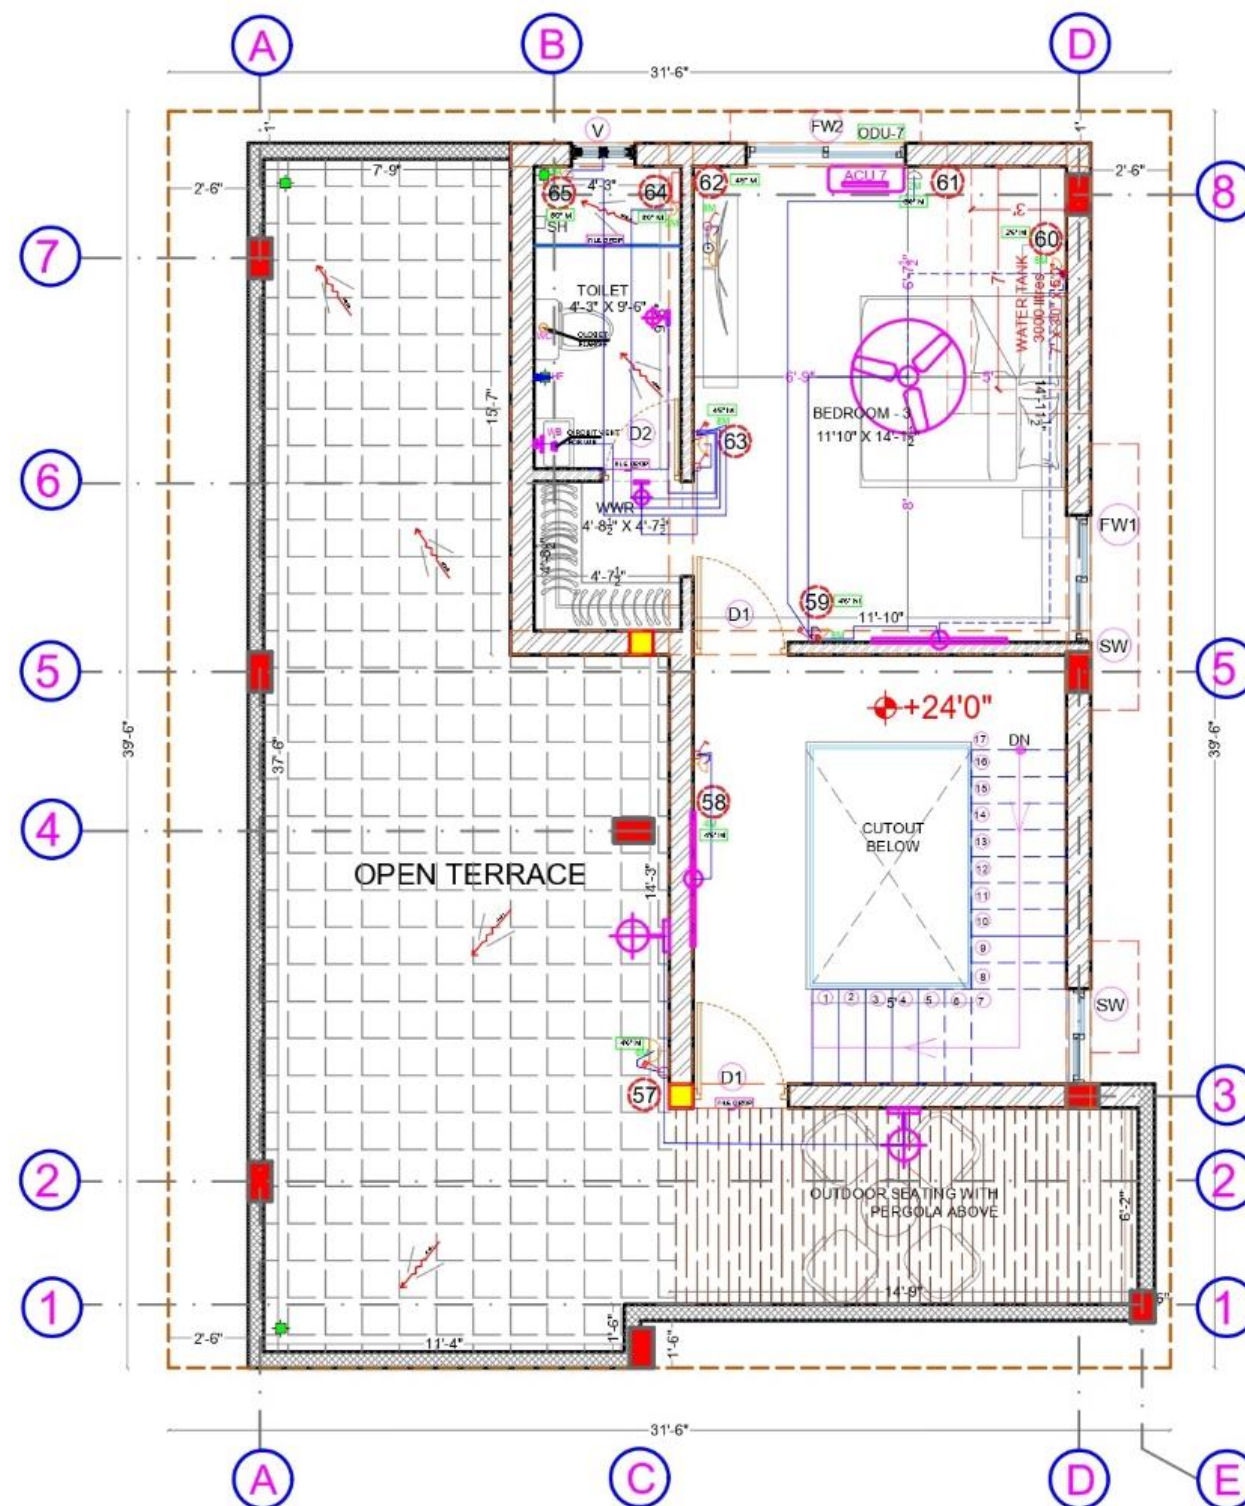

LEGEND	
	CEILING FAN
	AIR CONDITIONER / AC TRIP SWITCH
	FLOURESCENT LIGHT
	SPOT LIGHT
	WALL LIGHT
	CHANDLIER
	MIRROR LAMP
	CALLING BELL
	EXHAUST FAN
	GEYSER
	DISTRIBUTION BOARD
	U HOOK
	JHULA HOOK
	15A SOCKET
	10A SOCKET
	SOCKET FOR RO
	SOCKET FOR CHIMNEY
	REGULATOR
	SINGLE GANG SWITCH
	DOUBLE GANG SWITCH
	TRIPLE GANG SWITCH
	SINGLE TWO WAY SWITCH
	DOUBLE TWO WAY SWITCH
	TV AND INTERNET POINT
	WALL FAN

SECOND FLOOR

DRAWING TITLE:

Mr. Masthan Residence
Electrical Drawing

CLIENT:

Mr. Masthan


ARCHITECTURAL DESIGNERS:


**DEEJOS ENGINEERS AND
CONTRACTORS PVT Ltd**

2nd floor, C.L.C. Road, Chrompet,
Chennai-600 044,
Mobile: +91-8110000384
Email: projects@deejos.com

SIGNATURE & SEAL:

ORIENTATION:

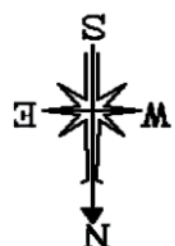

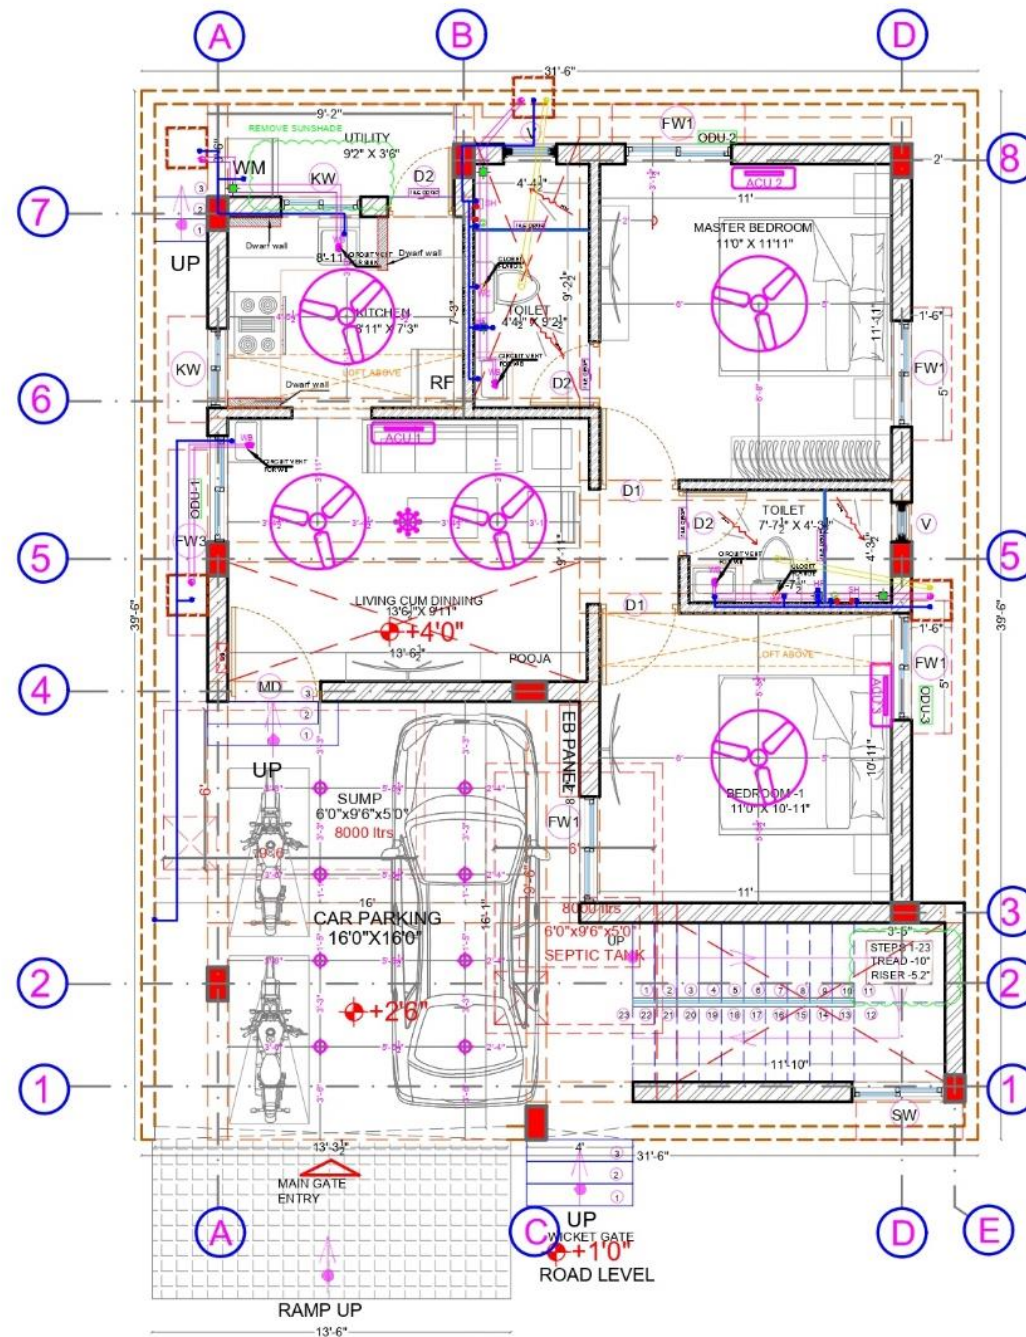

LEGEND		
	EWC	EUROPEAN WATER CLOSET (Wall mounted with flush valve)
	WB	WASH BASIN
	FT	FLOOR TRAP
	RWP	RAIN WATER PIPE 160Ø PVC (4 kg)
	SP	SOIL PIPE 110Ø PVC (6 kg)
	WP	WASTE PIPE 75Ø PVC (6 kg)
	WP	WASTE PIPE 40Ø PVC (10 kg)
	G	GEYSER
	BV	BALL VALVE
	CWS	COLD WATER SUPPLY CpvC PIPE
	HWS	HOT WATER SUPPLY CpvC PIPE
	M	MOTOR
	HF	HEALTH FAUCET
	HS	HAND SHOWER

GROUND FLOOR

CAR PARKING AREA - 231 SQ FT
GROUND FLOOR AREA - 985 SQ FT

DRAWING TITLE:

Mr. Masthan Residence
Plumbing Drawing

CLIENT:

Mr. Masthan


ARCHITECTURAL DESIGNERS:


**DEEJOS ENGINEERS AND
CONTRACTORS PVT Ltd**

2nd floor, C.L.C. Road, Chrompet,
Chennai-600 044,
Mobile: +91-8110000384
Email: projects@deejos.com

SIGNATURE & SEAL:

ORIENTATION:

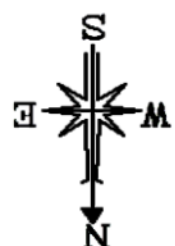

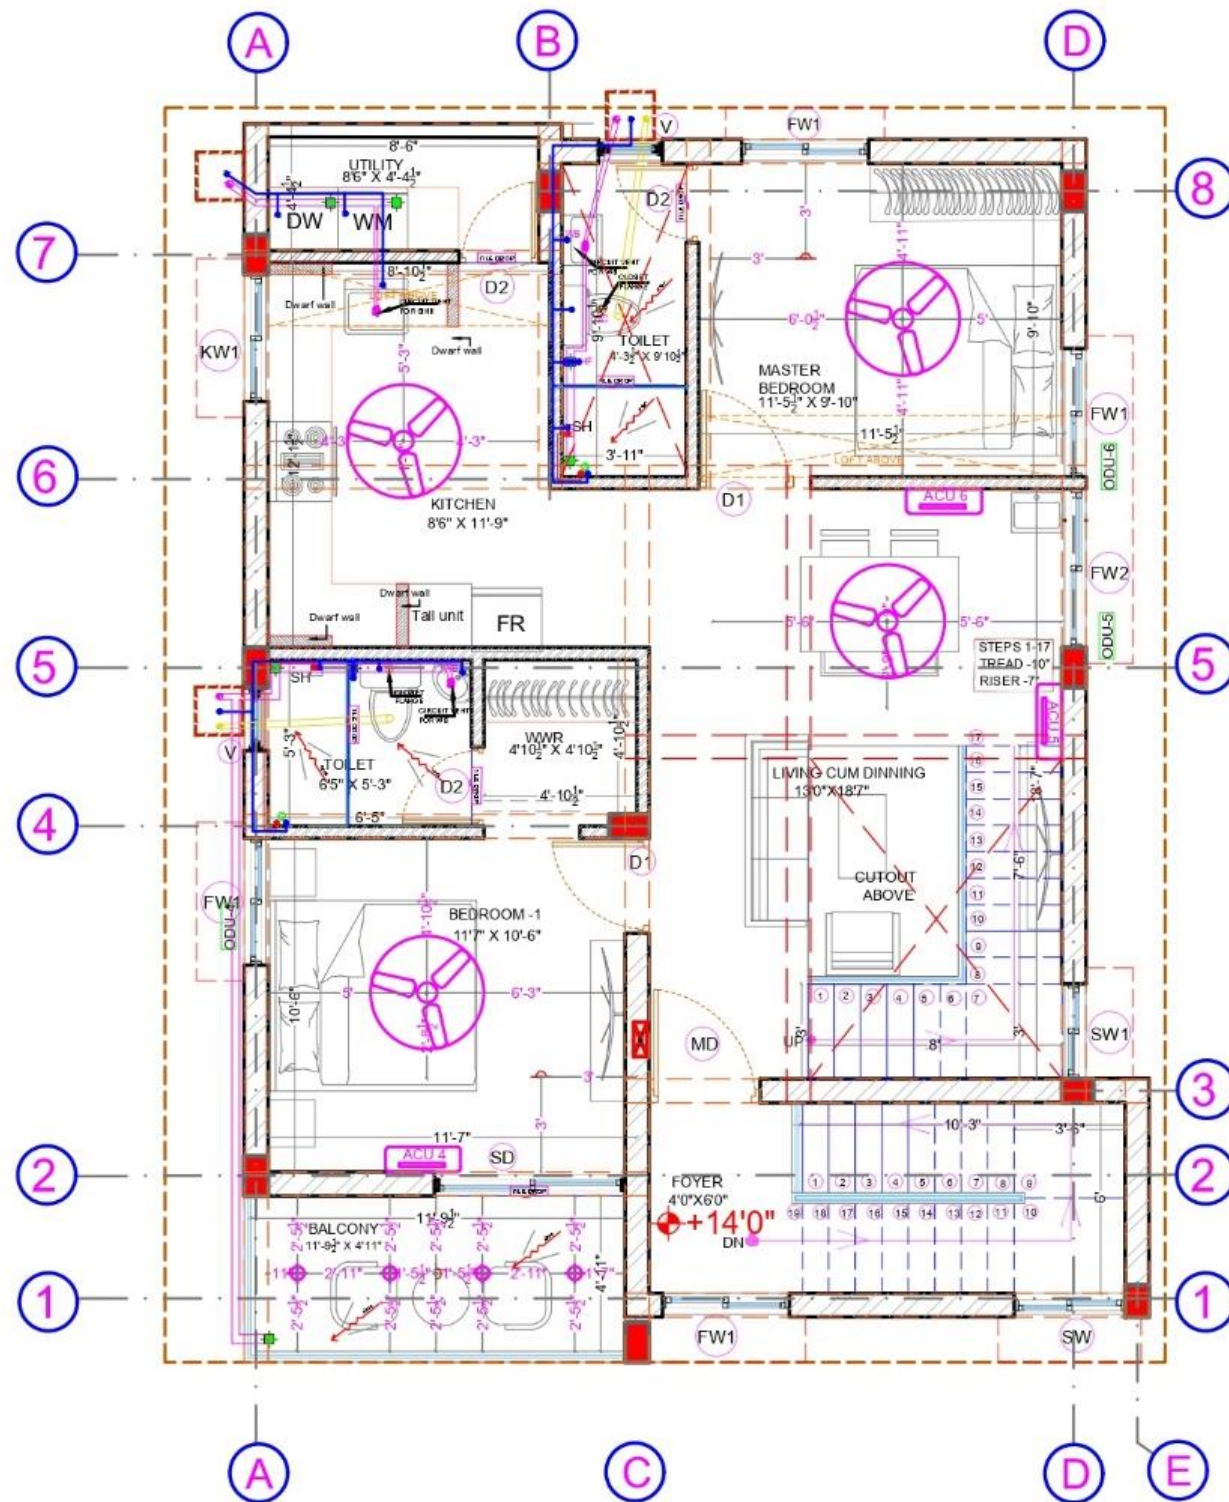

LEGEND		
	EWC	EUROPEAN WATER CLOSET (Wall mounted with flush valve)
	WB	WASH BASIN
	FT	FLOOR TRAP
	RWP	RAIN WATER PIPE 160Ø PVC (4 kg)
	SP	SOIL PIPE 110Ø PVC (6 kg)
	WP	WASTE PIPE 75Ø PVC (6 kg)
	WP	WASTE PIPE 40Ø PVC (10 kg)
	G	GEYSER
	BV	BALL VALVE
	CWS	COLD WATER SUPPLY Cpvc PIPE
	HWS	HOT WATER SUPPLY Cpvc PIPE
	M	MOTOR
	HF	HEALTH FAUCET
	HS	HAND SHOWER

FIRST FLOOR

DRAWING TITLE:

Mr. Masthan Residence
Plumbing Drawing

CLIENT:

Mr. Masthan

ARCHITECTURAL DESIGNERS:


**DEEJOS ENGINEERS AND
CONTRACTORS PVT Ltd**

2nd floor, C.L.C. Road, Chrompet,
Chennai-600 044,
Mobile: +91-8110000384
Email: projects@deejos.com

SIGNATURE & SEAL:

ORIENTATION:



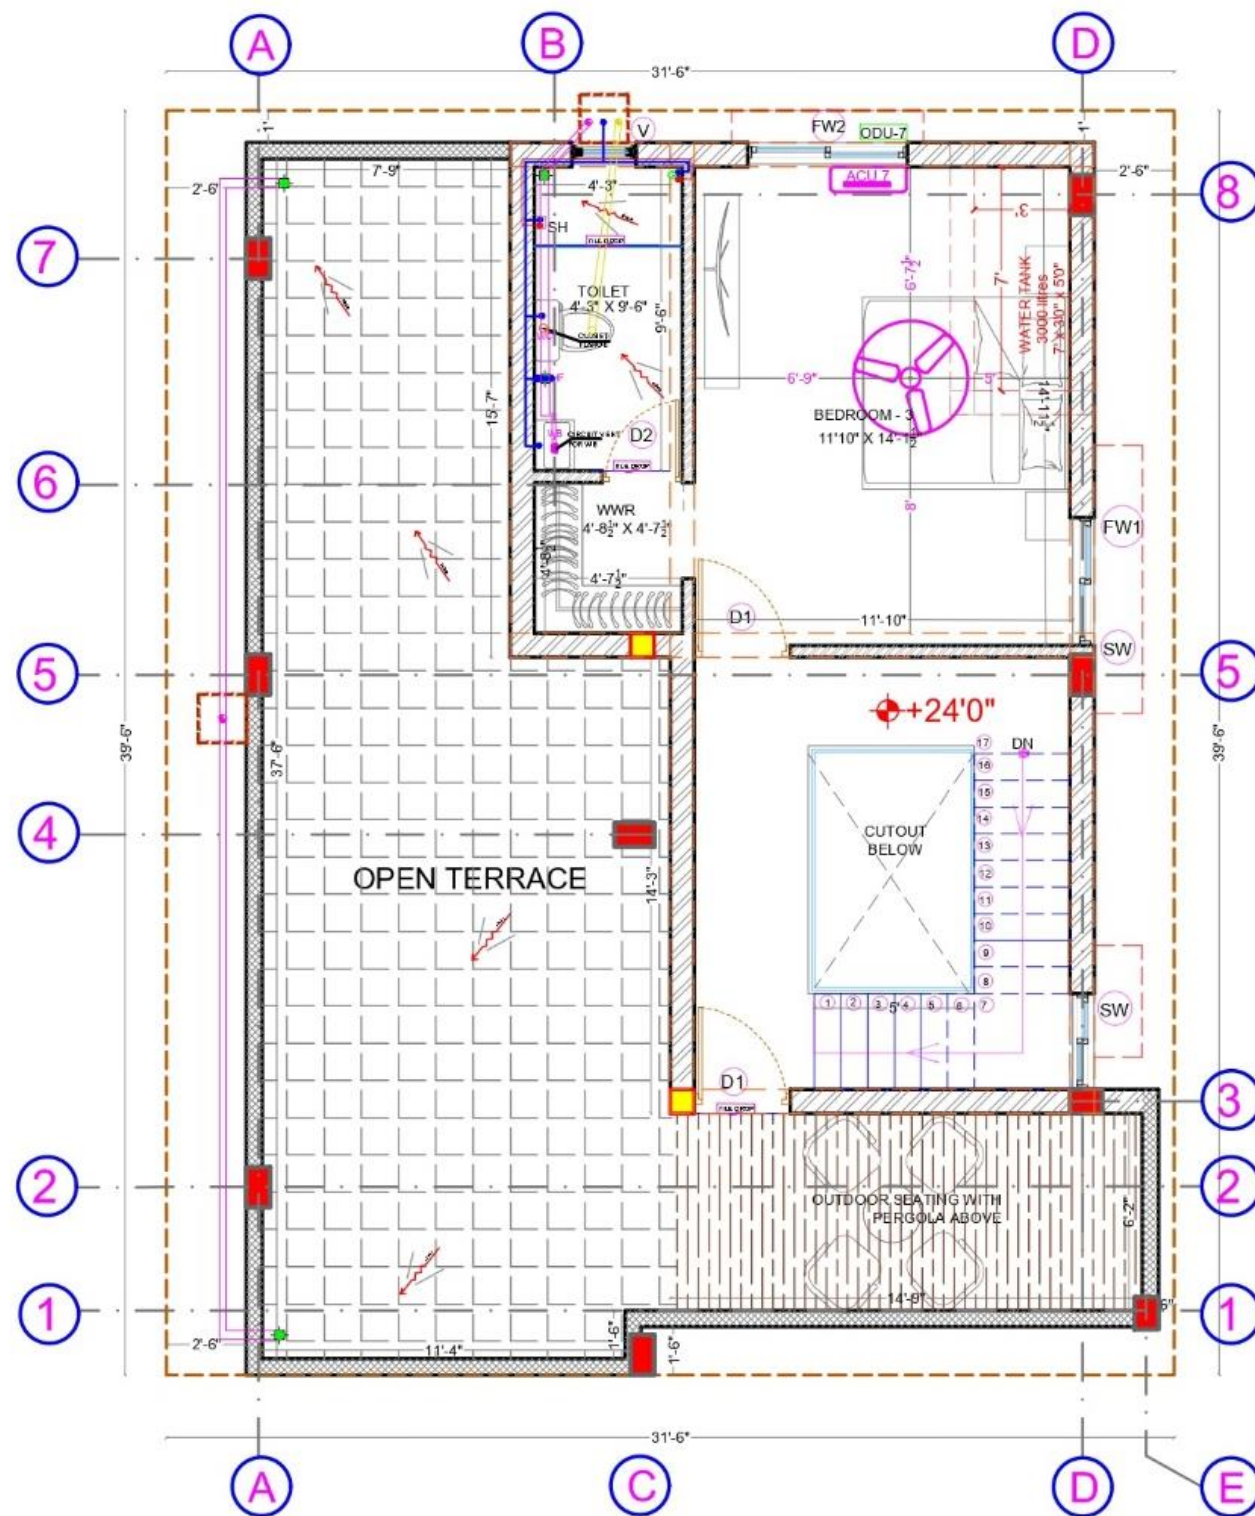

LEGEND		
	EWC	EUROPEAN WATER CLOSET (Wall mounted with flush valve)
	WB	WASH BASIN
	FT	FLOOR TRAP
	RWP	RAIN WATER PIPE 160Ø PVC (4 kg)
	SP	SOIL PIPE 110Ø PVC (6 kg)
	WP	WASTE PIPE 75Ø PVC (6 kg)
	WP	WASTE PIPE 40Ø PVC (10 kg)
	G	GEYSER
	BV	BALL VALVE
	CWS	COLD WATER SUPPLY CpvC PIPE
	HWS	HOT WATER SUPPLY CpvC PIPE
	M	MOTOR
	HF	HEALTH FAUCET
	HS	HAND SHOWER

SECOND FLOOR

DRAWING TITLE:

Mr. Masthan Residence
Plumbing Drawing

CLIENT:

Mr. Masthan


ARCHITECTURAL DESIGNERS:

**DEEJOS ENGINEERS AND
CONTRACTORS PVT Ltd**

2nd floor, C.L.C. Road, Chrompet,
Chennai-600 044,
Mobile: +91-8110000384
Email: projects@deejos.com

SIGNATURE & SEAL:

ORIENTATION:

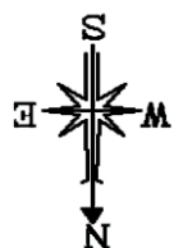



OPTION 1



OPTION 2

DRAWING TITLE:

Mr. MH. Raja Residence 3D
Elevation

CLIENT:

Mr. MH. Raja

ARCHITECTURAL DESIGNERS:

**DEEJOS ENGINEERS AND
CONTRACTORS PVT Ltd**

2nd floor, C.L.C. Road, Chrompet,
Chennai-600 044,
Mobile: +91-8110000384
Email: projects@deejos.com

SIGNATURE & SEAL:

ORIENTATION:





OPTION 3

DRAWING TITLE:

Mr. MH. Raja Residence 3D
Elevation

CLIENT:

Mr. MH. Raja

ARCHITECTURAL DESIGNERS:


**DEEJOS ENGINEERS AND
CONTRACTORS PVT Ltd**

2nd floor, C.L.C. Road, Chrompet,
Chennai-600 044,
Mobile: +91-8110000384
Email: projects@deejos.com

SIGNATURE & SEAL:

ORIENTATION:



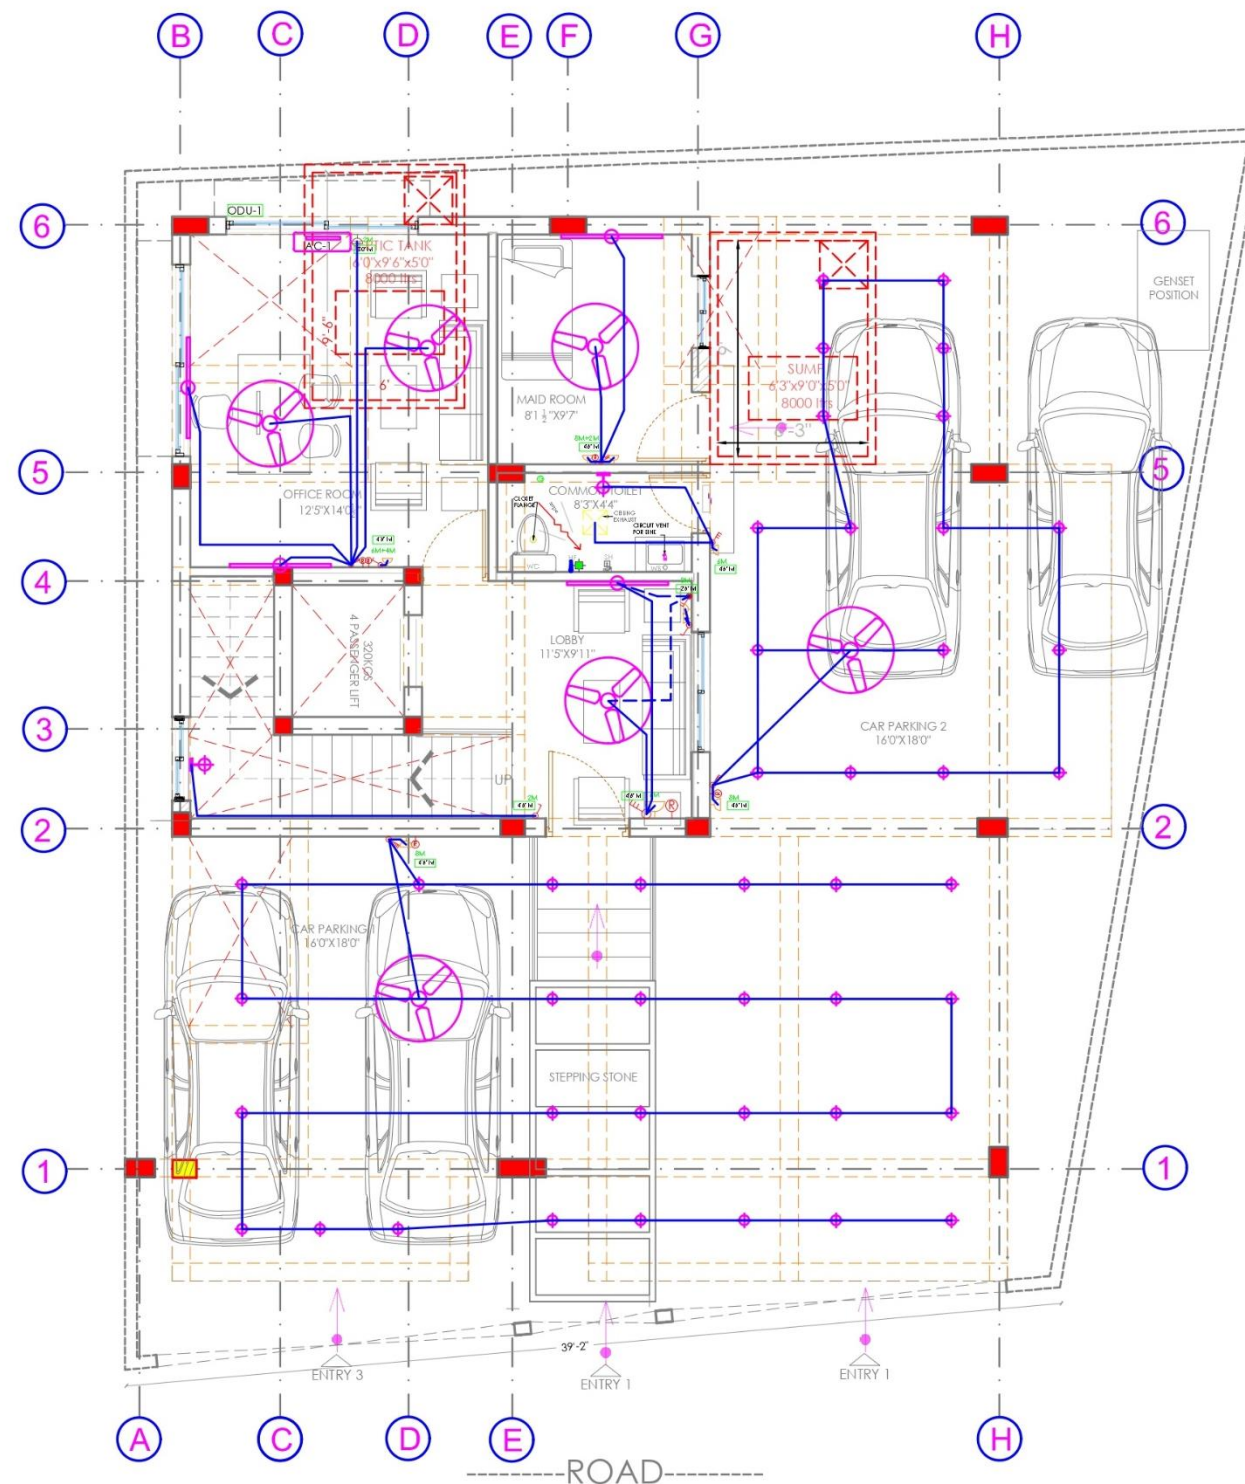

LEGEND	
	CEILING FAN
	AIR CONDITIONER / AC TRIP SWITCH
	FLOURESCENT LIGHT
	SPOT LIGHT
	WALL LIGHT
	CHANDLIER
	MIRROR LAMP
	CALLING BELL
	EXHAUST FAN
	GEYSER
	DISTRIBUTION BOARD
	U HOOK
	JHULA HOOK
	15A SOCKET
	10A SOCKET
	SOCKET FOR RO
	SOCKET FOR CHIMNEY
	REGULATOR
	SINGLE GANG SWITCH
	DOUBLE GANG SWITCH
	TRIPLE GANG SWITCH
	SINGLE TWO WAY SWITCH
	DOUBLE TWO WAY SWITCH
	TV AND INTERNET POINT
	WALL FAN

GROUND FLOOR

DRAWING TITLE:

Mr. MH. Raja Residence
Electrical Drawing

CLIENT:

Mr. MH. Raja

ARCHITECTURAL DESIGNERS:


**DEEJOS ENGINEERS AND
CONTRACTORS PVT Ltd**

2nd floor, C.L.C. Road, Chrompet,
Chennai-600 044,
Mobile: +91-8110000384
Email: projects@deejos.com

SIGNATURE & SEAL:

ORIENTATION:



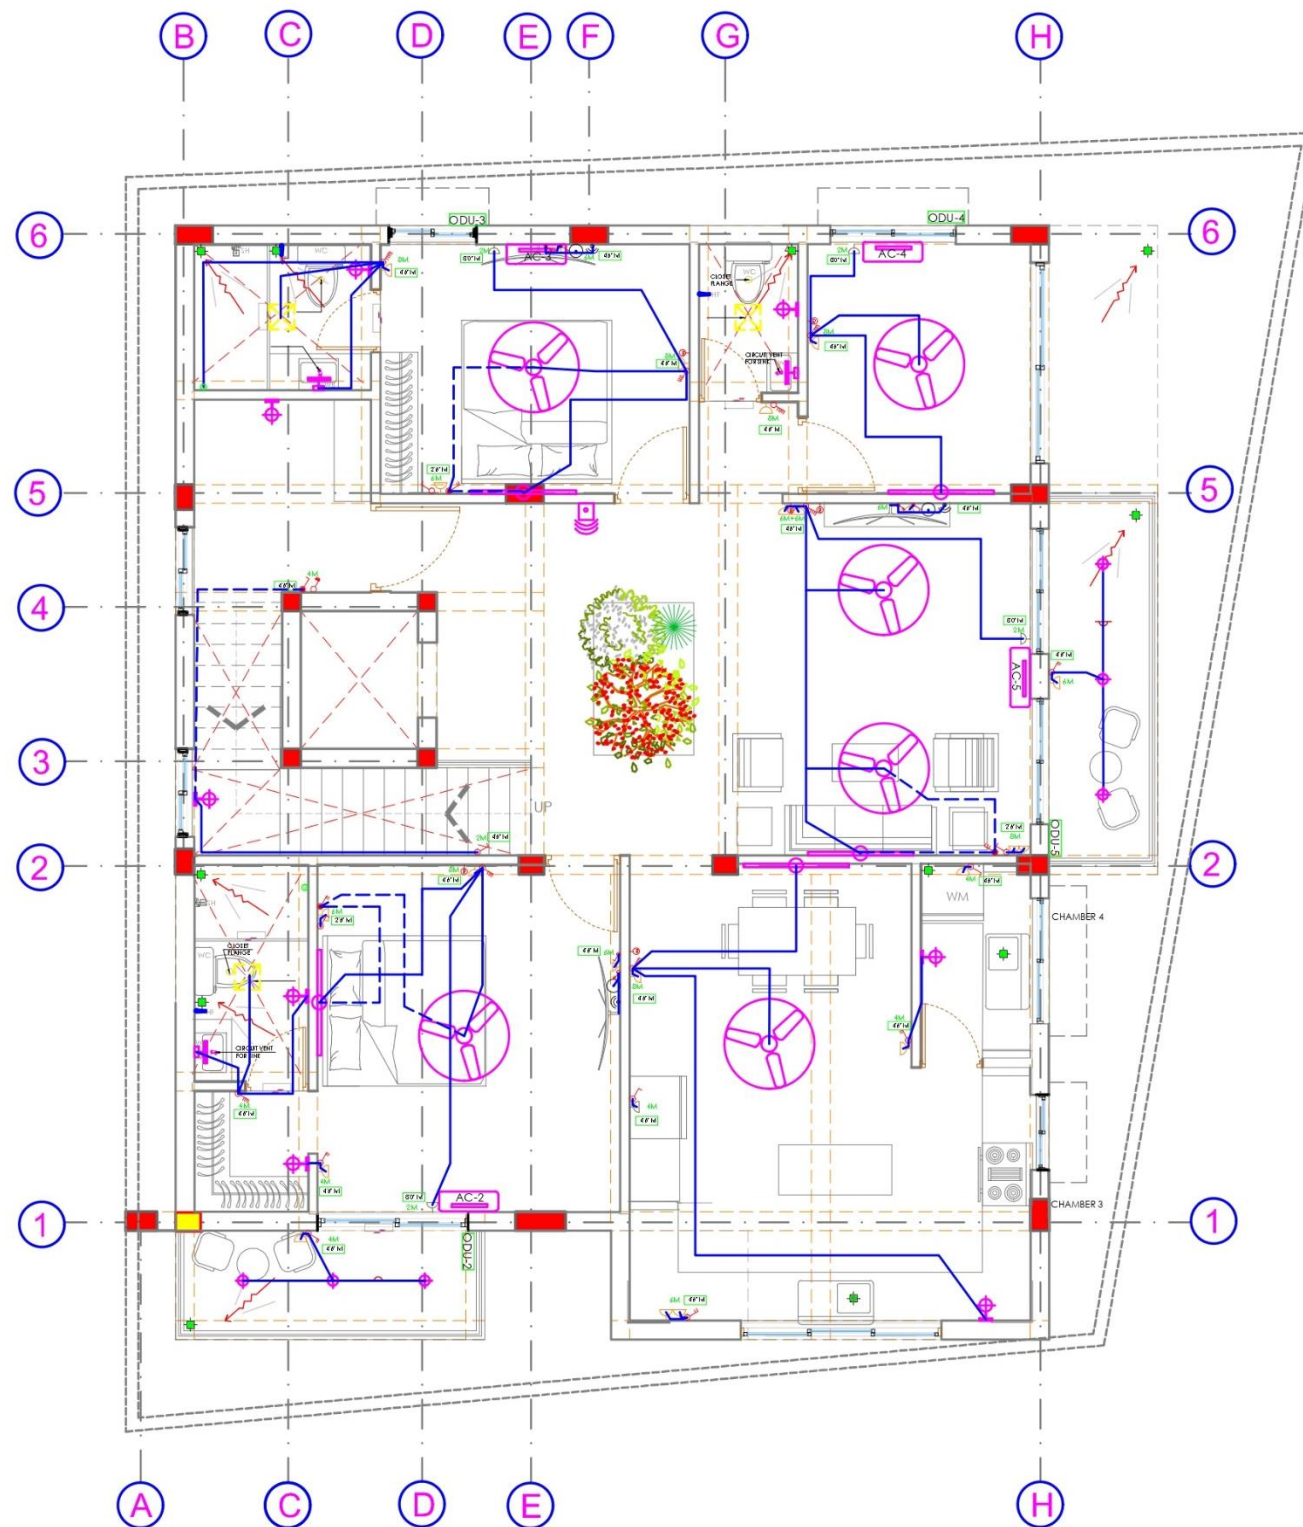

LEGEND	
	CEILING FAN
	AIR CONDITIONER / AC TRIP SWITCH
	FLOURESCENT LIGHT
	SPOT LIGHT
	WALL LIGHT
	CHANDLIER
	MIRROR LAMP
	CALLING BELL
	EXHAUST FAN
	GEYSER
	DISTRIBUTION BOARD
	U HOOK
	JHULA HOOK
	15A SOCKET
	10A SOCKET
	SOCKET FOR RO
	SOCKET FOR CHIMNEY
	REGULATOR
	SINGLE GANG SWITCH
	DOUBLE GANG SWITCH
	TRIPLE GANG SWITCH
	SINGLE TWO WAY SWITCH
	DOUBLE TWO WAY SWITCH
	TV AND INTERNET POINT
	WALL FAN

FIRST FLOOR

DRAWING TITLE:

Mr. MH. Raja Residence
Electrical Drawing

CLIENT:

Mr. MH. Raja

ARCHITECTURAL DESIGNERS:


**DEEJOS ENGINEERS AND
CONTRACTORS PVT Ltd**

2nd floor, C.L.C. Road, Chrompet,
Chennai-600 044,
Mobile: +91-8110000384
Email: projects@deejos.com

SIGNATURE & SEAL:

ORIENTATION:



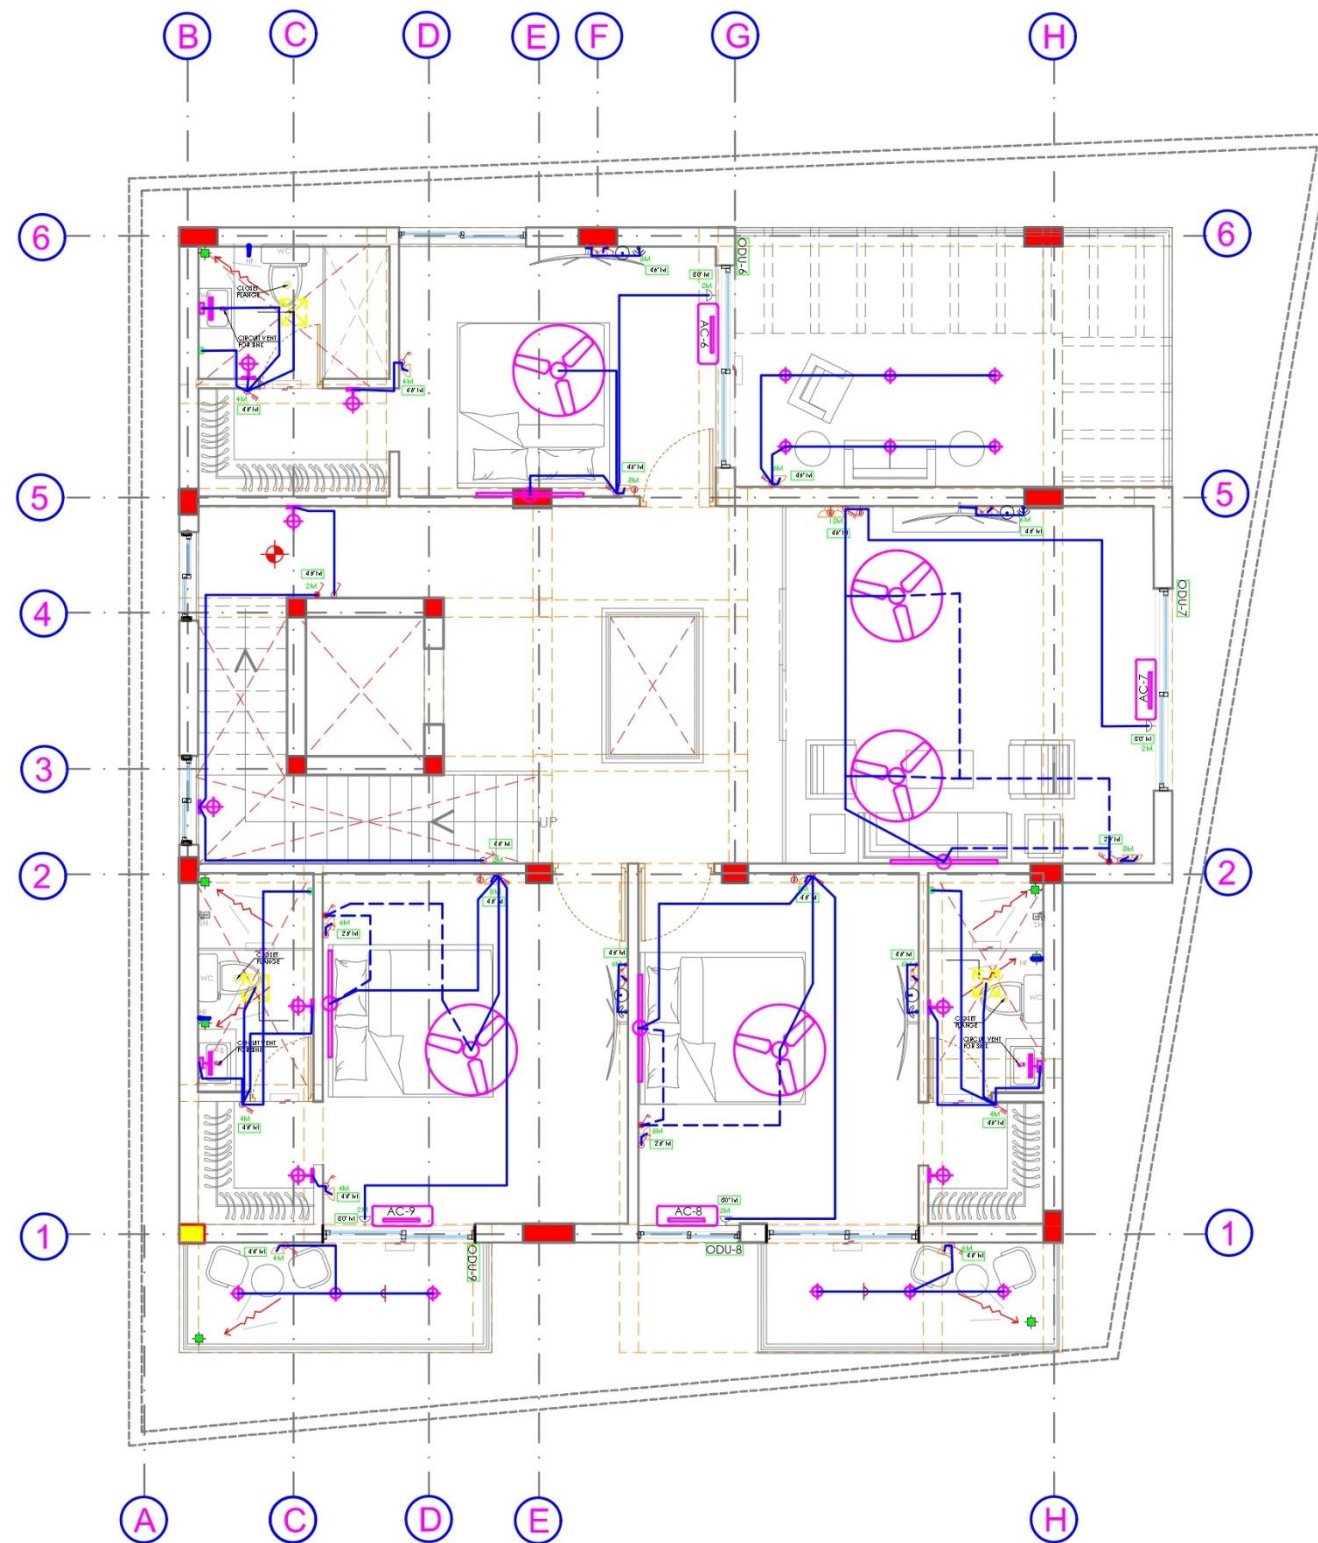

LEGEND	
	CEILING FAN
	AIR CONDITIONER / AC TRIP SWITCH
	FLOURESCENT LIGHT
	SPOT LIGHT
	WALL LIGHT
	CHANDLIER
	MIRROR LAMP
	CALLING BELL
	EXHAUST FAN
	GEYSER
	DISTRIBUTION BOARD
	U HOOK
	JHULA HOOK
	15A SOCKET
	10A SOCKET
	SOCKET FOR RO
	SOCKET FOR CHIMNEY
	REGULATOR
	SINGLE GANG SWITCH
	DOUBLE GANG SWITCH
	TRIPLE GANG SWITCH
	SINGLE TWO WAY SWITCH
	DOUBLE TWO WAY SWITCH
	TV AND INTERNET POINT
	WALL FAN

SECOND FLOOR

DRAWING TITLE:

Mr. MH. Raja Residence
Electrical Drawing

CLIENT:

Mr. MH. Raja

ARCHITECTURAL DESIGNERS:


**DEEJOS ENGINEERS AND
CONTRACTORS PVT Ltd**

2nd floor, C.L.C. Road, Chrompet,
Chennai-600 044,
Mobile: +91-8110000384
Email: projects@deejos.com

SIGNATURE & SEAL:

ORIENTATION:



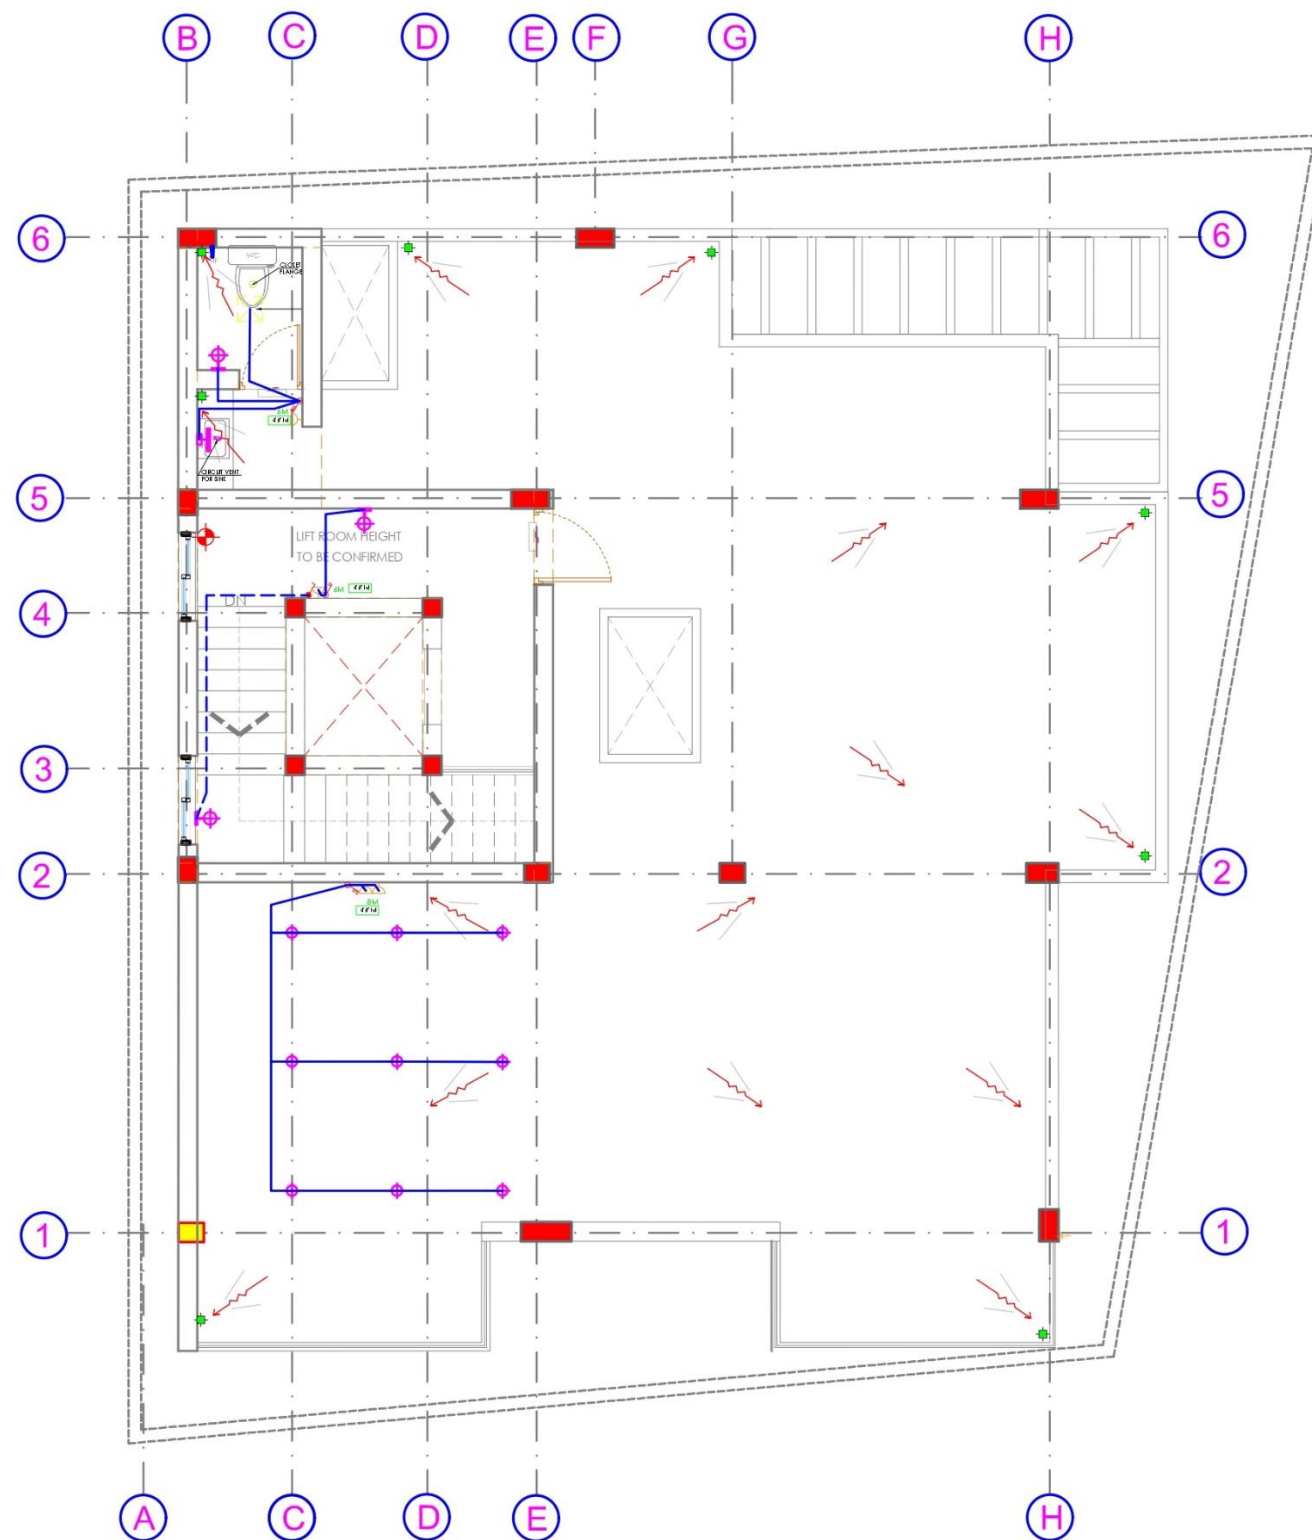

LEGEND	
	CEILING FAN
	AIR CONDITIONER / AC TRIP SWITCH
	FLOURESCENT LIGHT
	SPOT LIGHT
	WALL LIGHT
	CHANDLIER
	MIRROR LAMP
	CALLING BELL
	EXHAUST FAN
	GEYSER
	DISTRIBUTION BOARD
	U HOOK
	JHULA HOOK
	15A SOCKET
	10A SOCKET
	SOCKET FOR RO
	SOCKET FOR CHIMNEY
	REGULATOR
	SINGLE GANG SWITCH
	DOUBLE GANG SWITCH
	TRIPLE GANG SWITCH
	SINGLE TWO WAY SWITCH
	DOUBLE TWO WAY SWITCH
	TV AND INTERNET POINT
	WALL FAN

TERRACE FLOOR

DRAWING TITLE:

Mr. MH. Raja Residence
Electrical Drawing

CLIENT:

Mr. MH. Raja

ARCHITECTURAL DESIGNERS:

**DEEJOS ENGINEERS AND
CONTRACTORS PVT Ltd**

2nd floor, C.L.C. Road, Chrompet,
Chennai-600 044,
Mobile: +91-8110000384
Email: projects@deejos.com

SIGNATURE & SEAL:

ORIENTATION:





DRAWING TITLE:

Mr. Murugan Residence 3D
Elevation

CLIENT:

Mr. Murugan

ARCHITECTURAL DESIGNERS:

**DEEJOS ENGINEERS AND
CONTRACTORS PVT Ltd**

2nd floor, C.L.C. Road, Chrompet,
Chennai-600 044,
Mobile: +91-8110000384
Email: projects@deejos.com

SIGNATURE & SEAL:

ORIENTATION:





OPTION 1

DRAWING TITLE:

Mr. Poovarasana Raja Residence
3D Elevation

CLIENT:

Mr. Poovarasana Raja

ARCHITECTURAL DESIGNERS:

**DEEJOS ENGINEERS AND
CONTRACTORS PVT Ltd**

2nd floor, C.L.C. Road, Chrompet,
Chennai-600 044,
Mobile: +91-8110000384
Email: projects@deejos.com

SIGNATURE & SEAL:

ORIENTATION:





OPTION 2



OPTION 3

DRAWING TITLE:

Mr. Poovarasana Raja Residence
3D Elevation

CLIENT:

Mr. Poovarasana Raja

ARCHITECTURAL DESIGNERS:


**DEEJOS ENGINEERS AND
CONTRACTORS PVT Ltd**

2nd floor, C.L.C. Road, Chrompet,
Chennai-600 044,
Mobile: +91-8110000384
Email: projects@deejos.com

SIGNATURE & SEAL:


ORIENTATION:



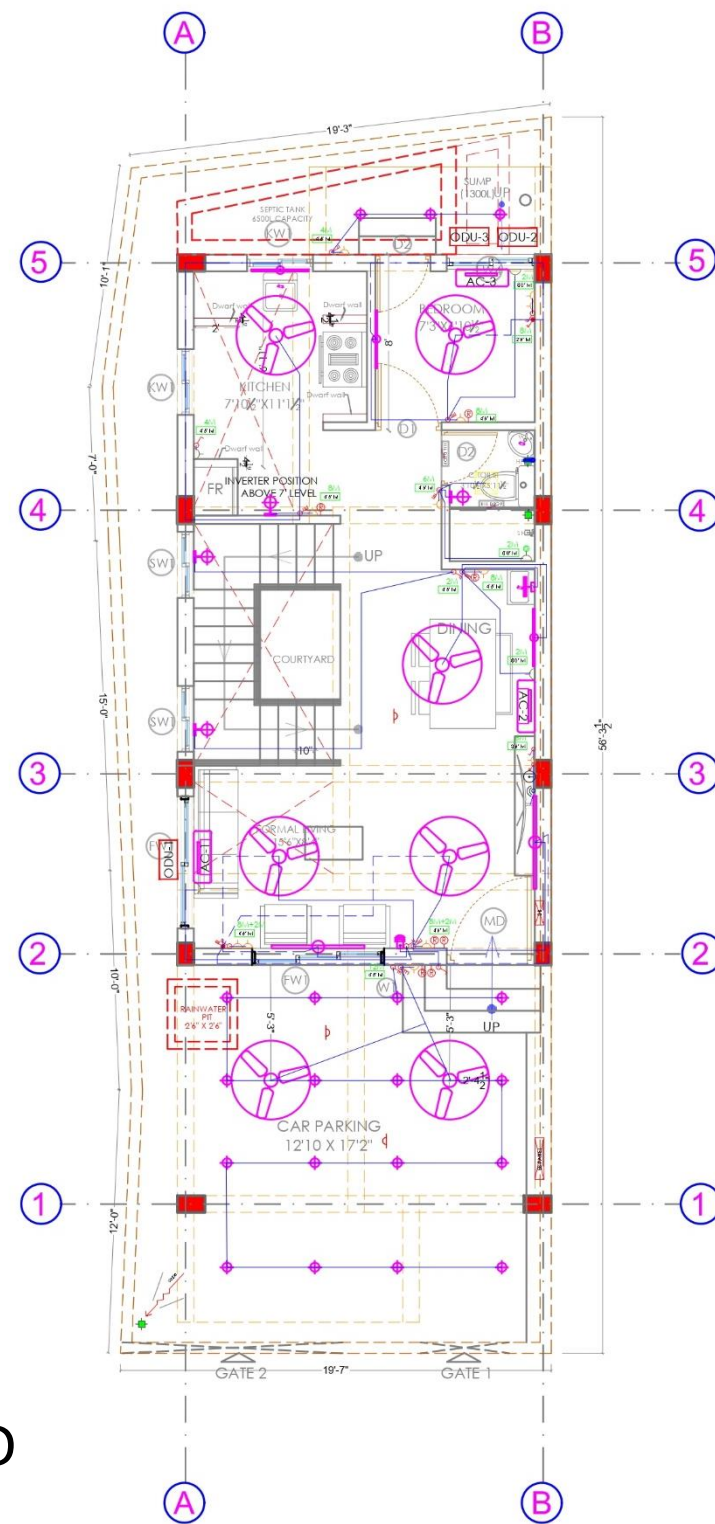

GROUND
FLOOR

LEGEND	
	CEILING FAN
	AIR CONDITIONER / AC TRIP SWITCH
	FLOURESCENT LIGHT
	SPOT LIGHT
	WALL LIGHT
	CHANDLIER
	MIRROR LAMP
	CALLING BELL
	EXHAUST FAN
	GEYSER
	DISTRIBUTION BOARD
	U HOOK
	JHULA HOOK
	15A SOCKET
	10A SOCKET
	SOCKET FOR RO
	SOCKET FOR CHIMNEY
	REGULATOR
	SINGLE GANG SWITCH
	DOUBLE GANG SWITCH
	TRIPLE GANG SWITCH
	SINGLE TWO WAY SWITCH
	DOUBLE TWO WAY SWITCH
	TV AND INTERNET POINT
	WALL FAN

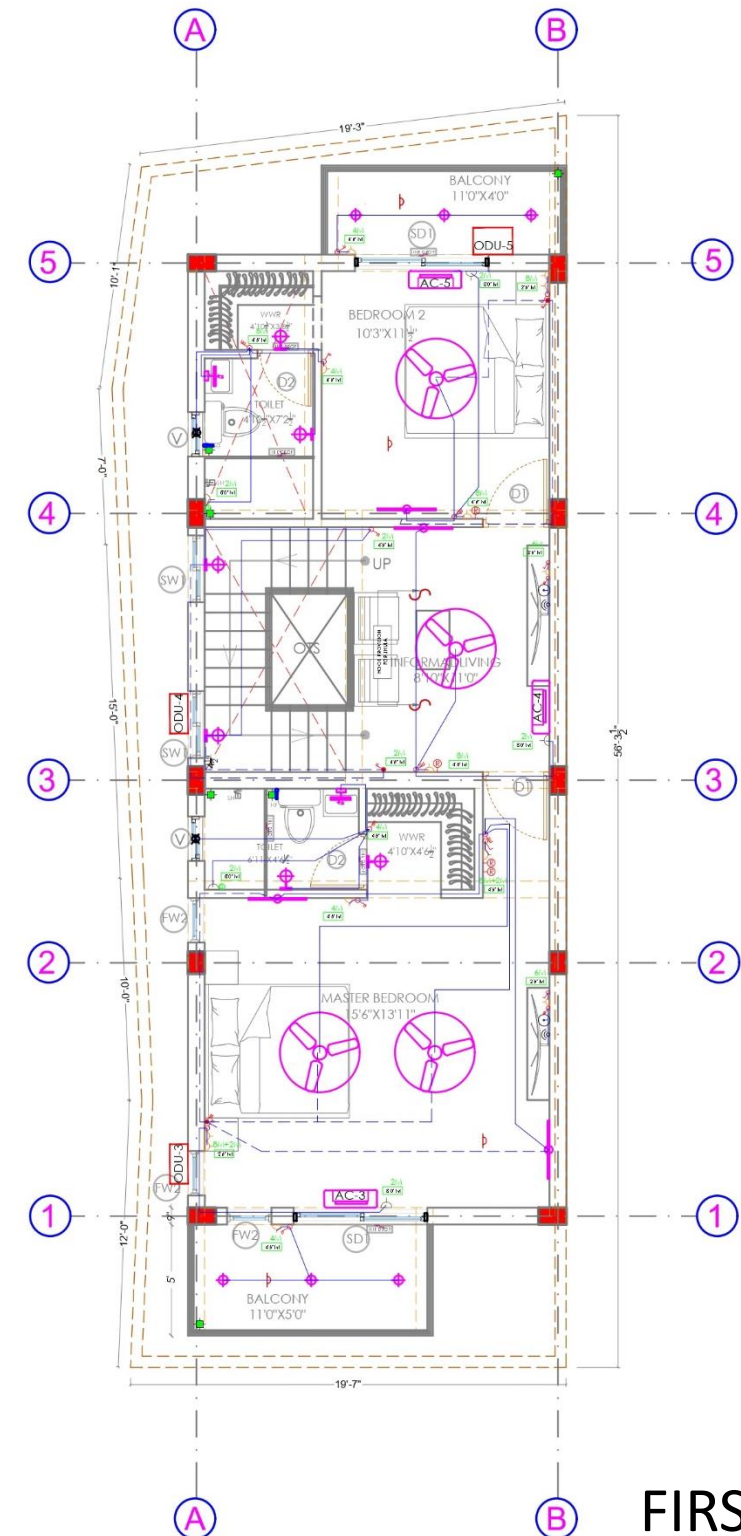

FIRST FLOOR

DRAWING TITLE:

Mr. Poovarasana Raja Electrical
Drawing

CLIENT:

Mr. Poovarasana Raja

ARCHITECTURAL DESIGNERS:

**DEEJOS ENGINEERS AND
CONTRACTORS PVT Ltd**


2nd floor, C.L.C. Road, Chrompet,
Chennai-600 044,
Mobile: +91-8110000384
Email: projects@deejos.com

SIGNATURE & SEAL:

ORIENTATION:



SECOND FLOOR

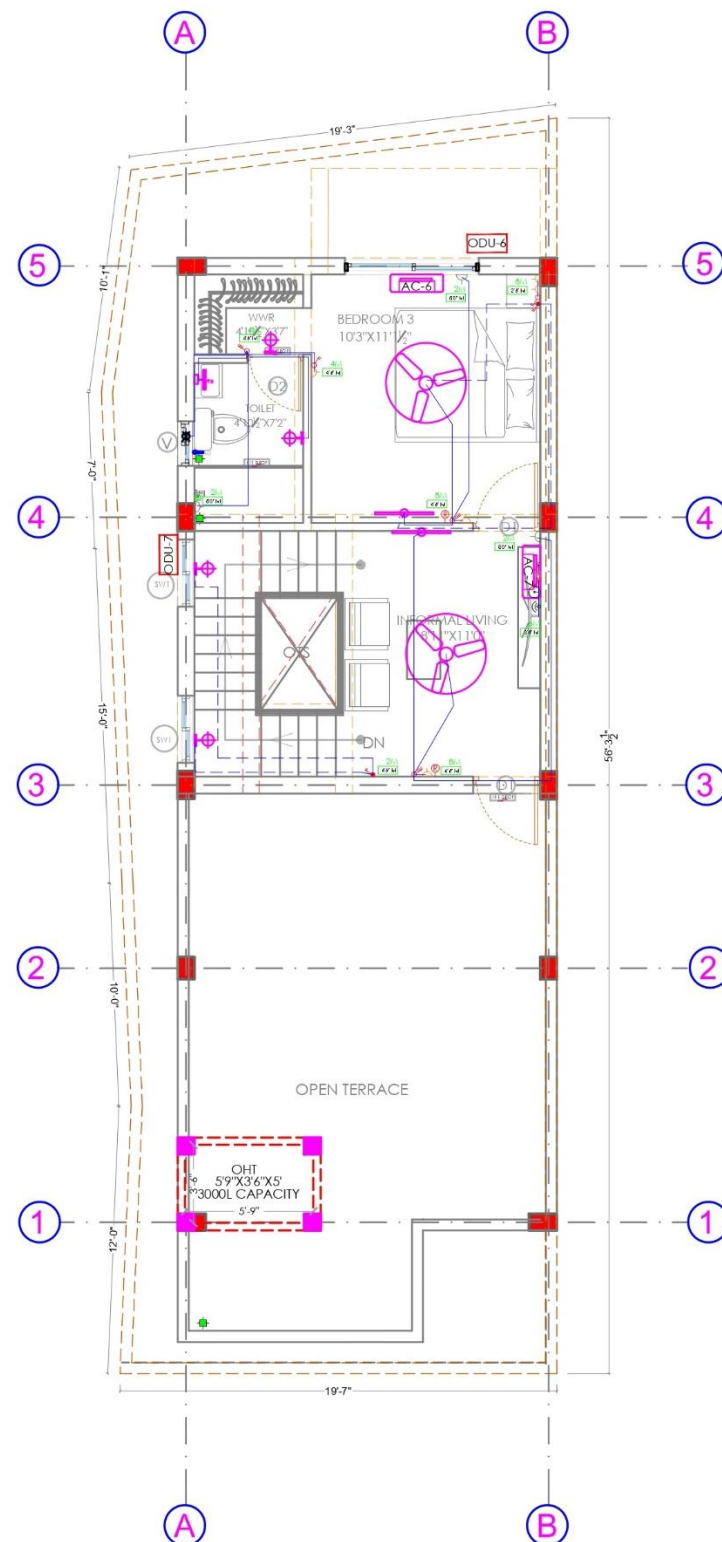

LEGEND	
	CEILING FAN
	AIR CONDITIONER / AC TRIP SWITCH
	FLOURESCENT LIGHT
	SPOT LIGHT
	WALL LIGHT
	CHANDLIER
	MIRROR LAMP
	CALLING BELL
	EXHAUST FAN
	GEYSER
	DISTRIBUTION BOARD
	U HOOK
	JHULA HOOK
	15A SOCKET
	10A SOCKET
	SOCKET FOR RO
	SOCKET FOR CHIMNEY
	REGULATOR
	SINGLE GANG SWITCH
	DOUBLE GANG SWITCH
	TRIPLE GANG SWITCH
	SINGLE TWO WAY SWITCH
	DOUBLE TWO WAY SWITCH
	TV AND INTERNET POINT
	WALL FAN

DRAWING TITLE:

Mr. Poovarasana Raja Electrical
Drawing

CLIENT:

Mr. Poovarasana Raja

ARCHITECTURAL DESIGNERS:

**DEEJOS ENGINEERS AND
CONTRACTORS PVT Ltd**


2nd floor, C.L.C. Road, Chrompet,
Chennai-600 044,
Mobile: +91-8110000384
Email: projects@deejos.com

SIGNATURE & SEAL:


ORIENTATION:



GROUND FLOOR

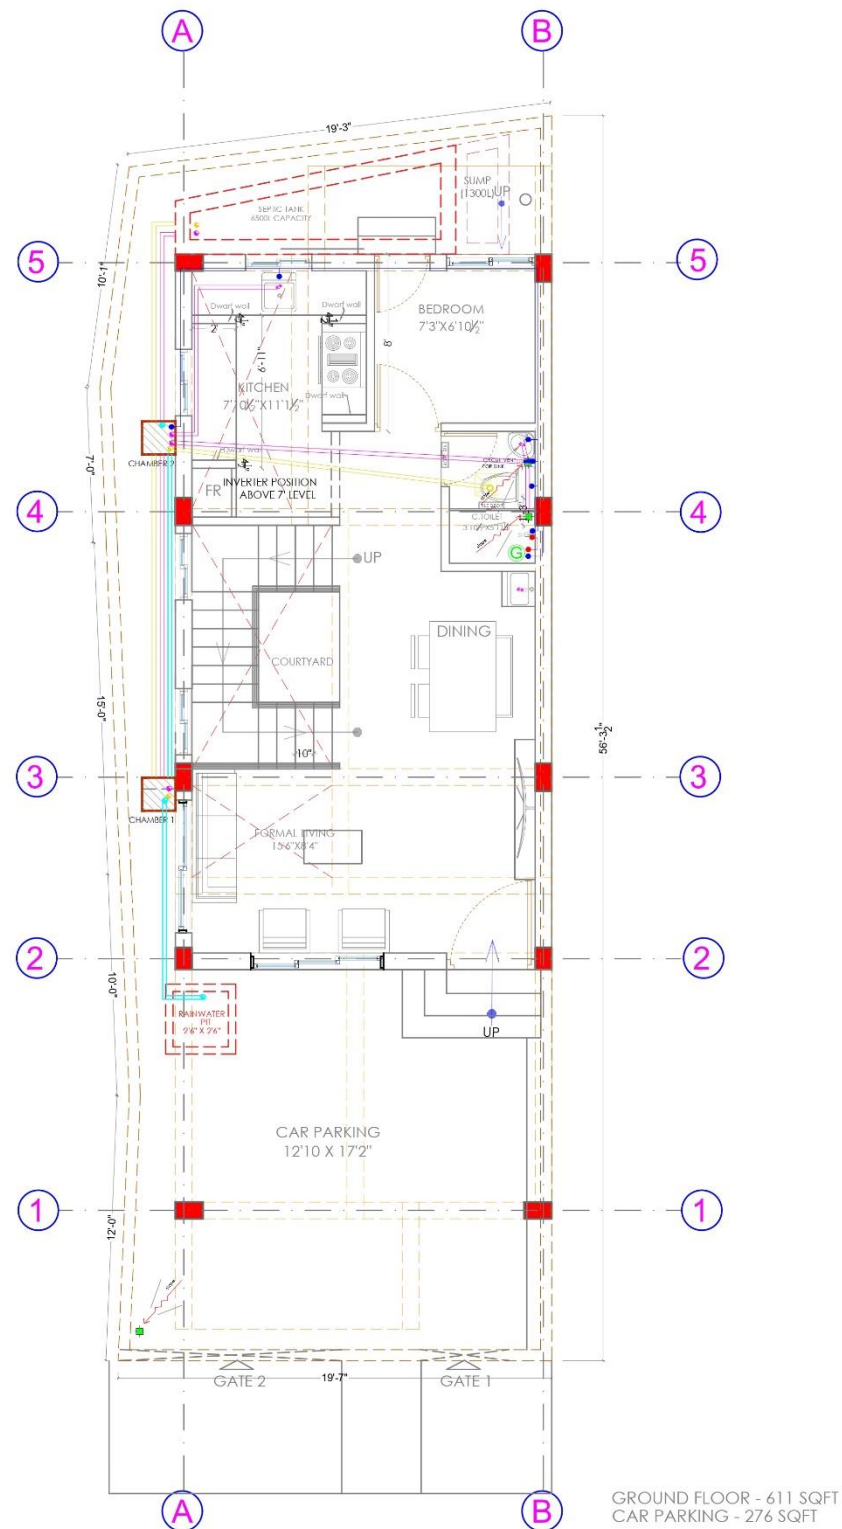

LEGEND		
	EWC	EUROPEAN WATER CLOSET (Wall mounted with flush valve)
	WB	WASH BASIN
	FT	FLOOR TRAP
	RWP	RAIN WATER PIPE 160Ø PVC (4 kg)
	SP	SOIL PIPE 110Ø PVC (6 kg)
	WP	WASTE PIPE 75Ø PVC (6 kg)
	WP	WASTE PIPE 40Ø PVC (10 kg)
	G	GEYSER
	BV	BALL VALVE
	CWS	COLD WATER SUPPLY Cpvc PIPE
	HWS	HOT WATER SUPPLY Cpvc PIPE
	M	MOTOR
	HF	HEALTH FAUCET
	HS	HAND SHOWER

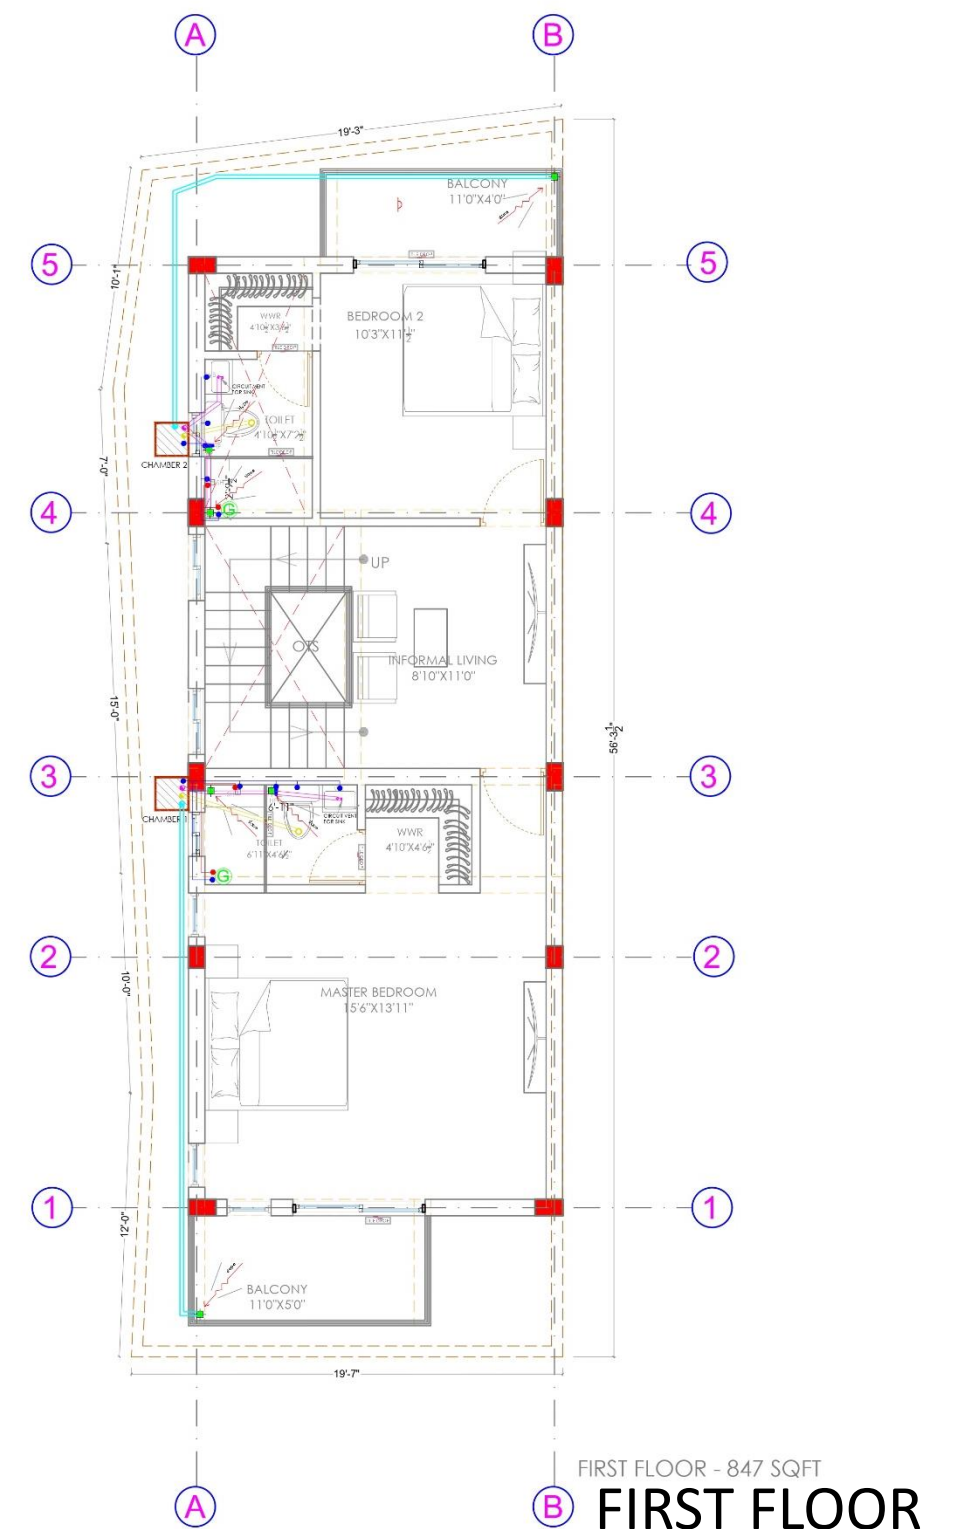

DRAWING TITLE:

Mr. Poovarasana Raja Plumbing
Drawing

CLIENT:

Mr. Poovarasana Raja

ARCHITECTURAL DESIGNERS:

**DEEJOS ENGINEERS AND
CONTRACTORS PVT Ltd**


2nd floor, C.L.C. Road, Chrompet,
Chennai-600 044,
Mobile: +91-8110000384
Email: projects@deejos.com

SIGNATURE & SEAL:

ORIENTATION:



SECOND FLOOR

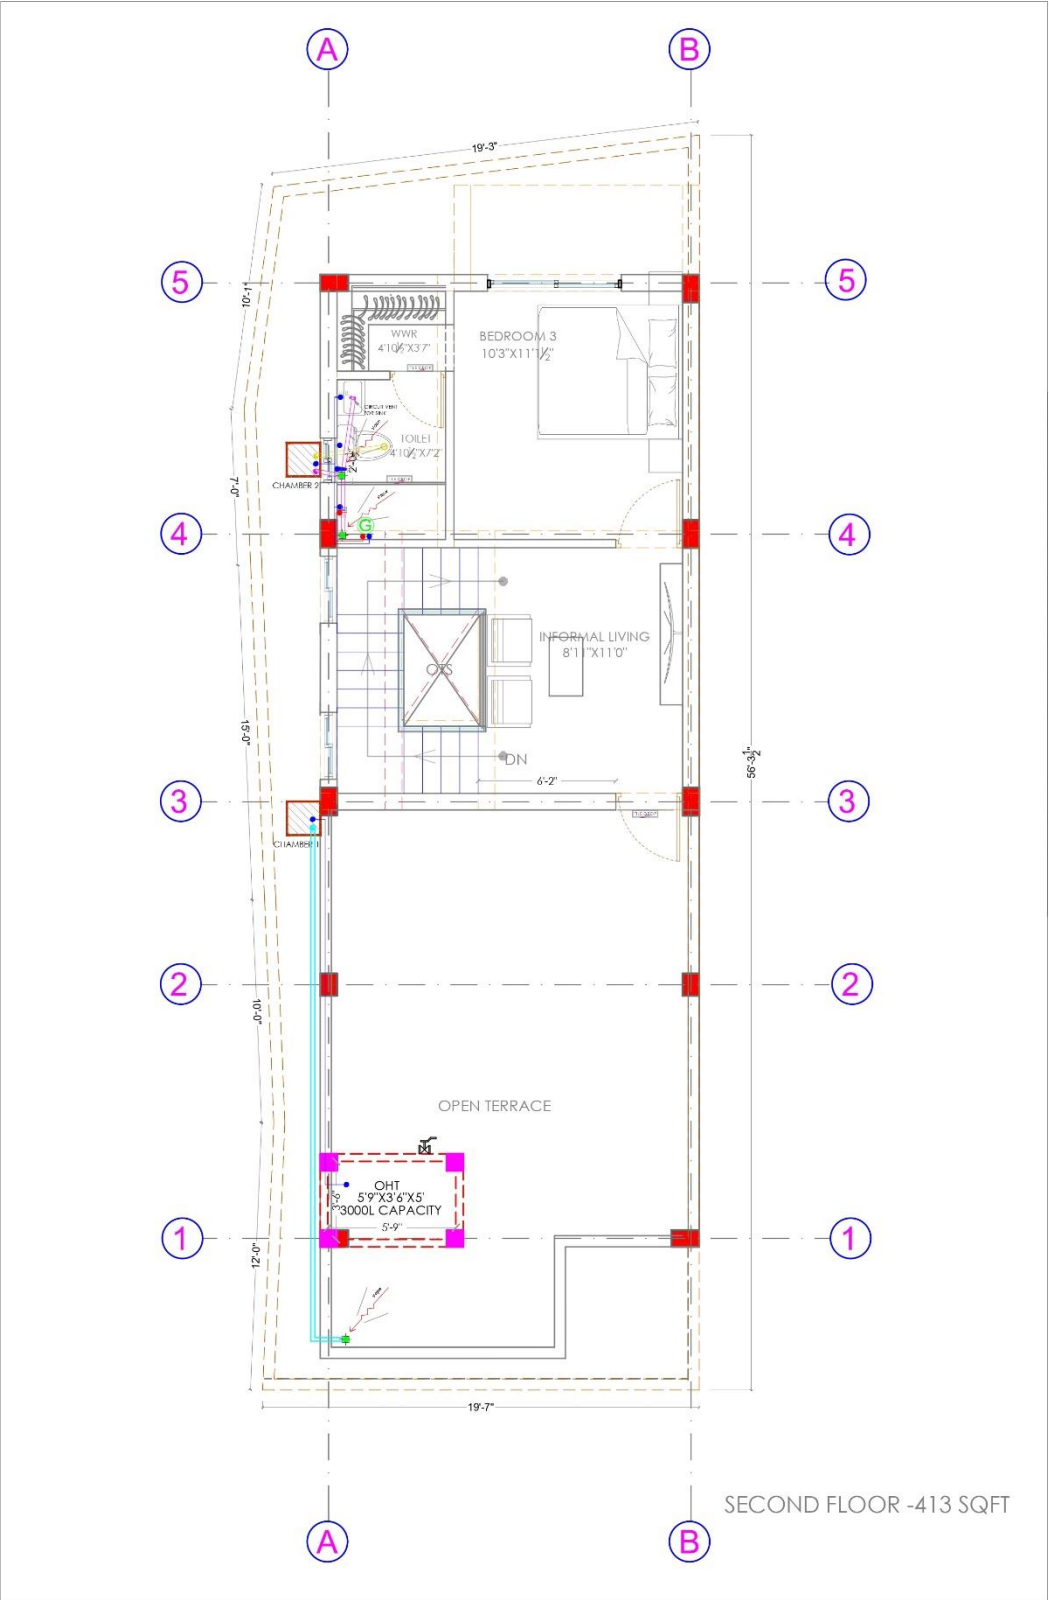

LEGEND		
	EWC	EUROPEAN WATER CLOSET (Wall mounted with flush valve)
	WB	WASH BASIN
	FT	FLOOR TRAP
	RWP	RAIN WATER PIPE 160Ø PVC (4 kg)
	SP	SOIL PIPE 110Ø PVC (6 kg)
	WP	WASTE PIPE 75Ø PVC (6 kg)
	WP	WASTE PIPE 40Ø PVC (10 kg)
	G	GEYSER
	BV	BALL VALVE
	CWS	COLD WATER SUPPLY Cpvc PIPE
	HWS	HOT WATER SUPPLY Cpvc PIPE
	M	MOTOR
	HF	HEALTH FAUCET
	HS	HAND SHOWER

DRAWING TITLE:
Mr. Poovarasana Raja Plumbing
Drawing


CLIENT:
Mr. Poovarasana Raja

ARCHITECTURAL DESIGNERS:
**DEEJOS ENGINEERS AND
CONTRACTORS PVT Ltd**
2nd floor, C.L.C. Road, Chrompet,
Chennai-600 044,
Mobile: +91-8110000384
Email: projects@deejos.com

SIGNATURE & SEAL:

ORIENTATION:



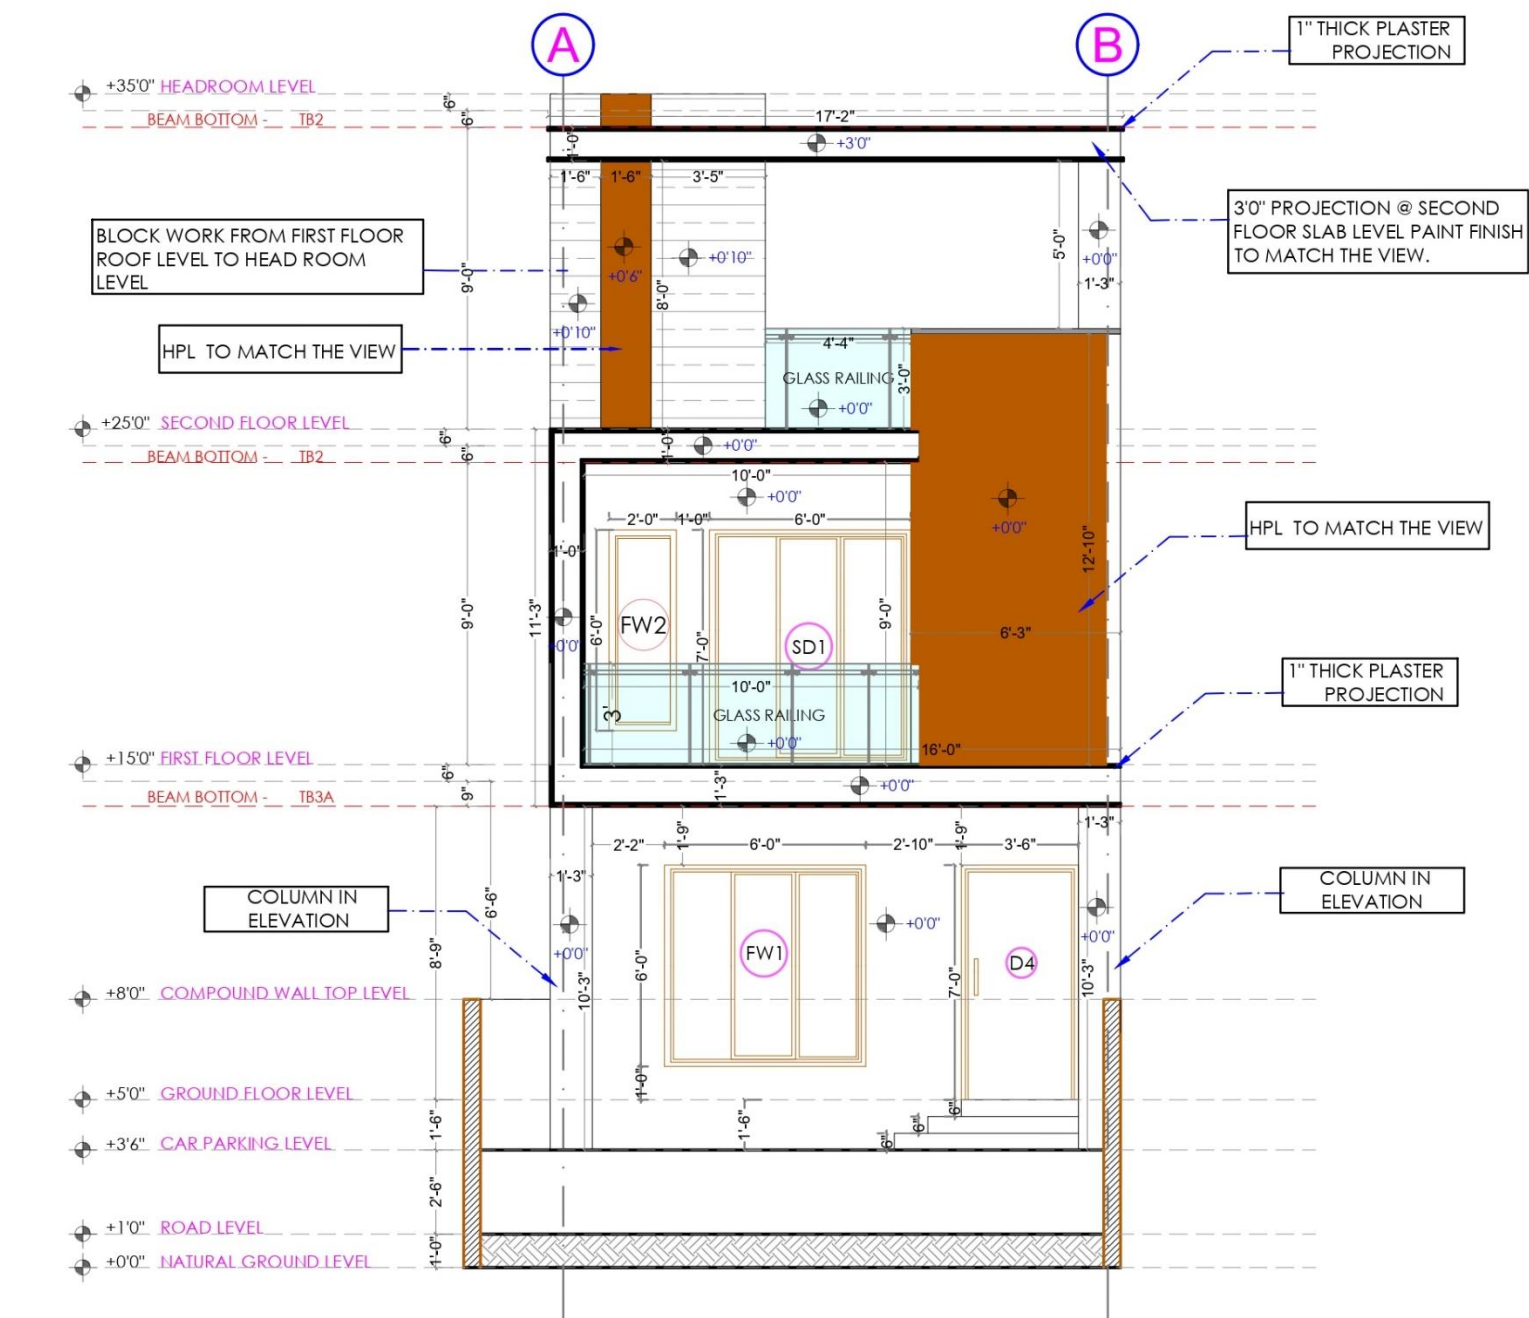

1 SOUTH ELEVATION

DRAWING TITLE:

Mr. Poovarasana Raja 2D
Elevation

CLIENT:

Mr. Poovarasana Raja

ARCHITECTURAL DESIGNERS:


**DEEJOS ENGINEERS AND
CONTRACTORS PVT Ltd**

2nd floor, C.L.C. Road, Chrompet,
Chennai-600 044,
Mobile: +91-8110000384
Email: projects@deejos.com

SIGNATURE & SEAL:

ORIENTATION:



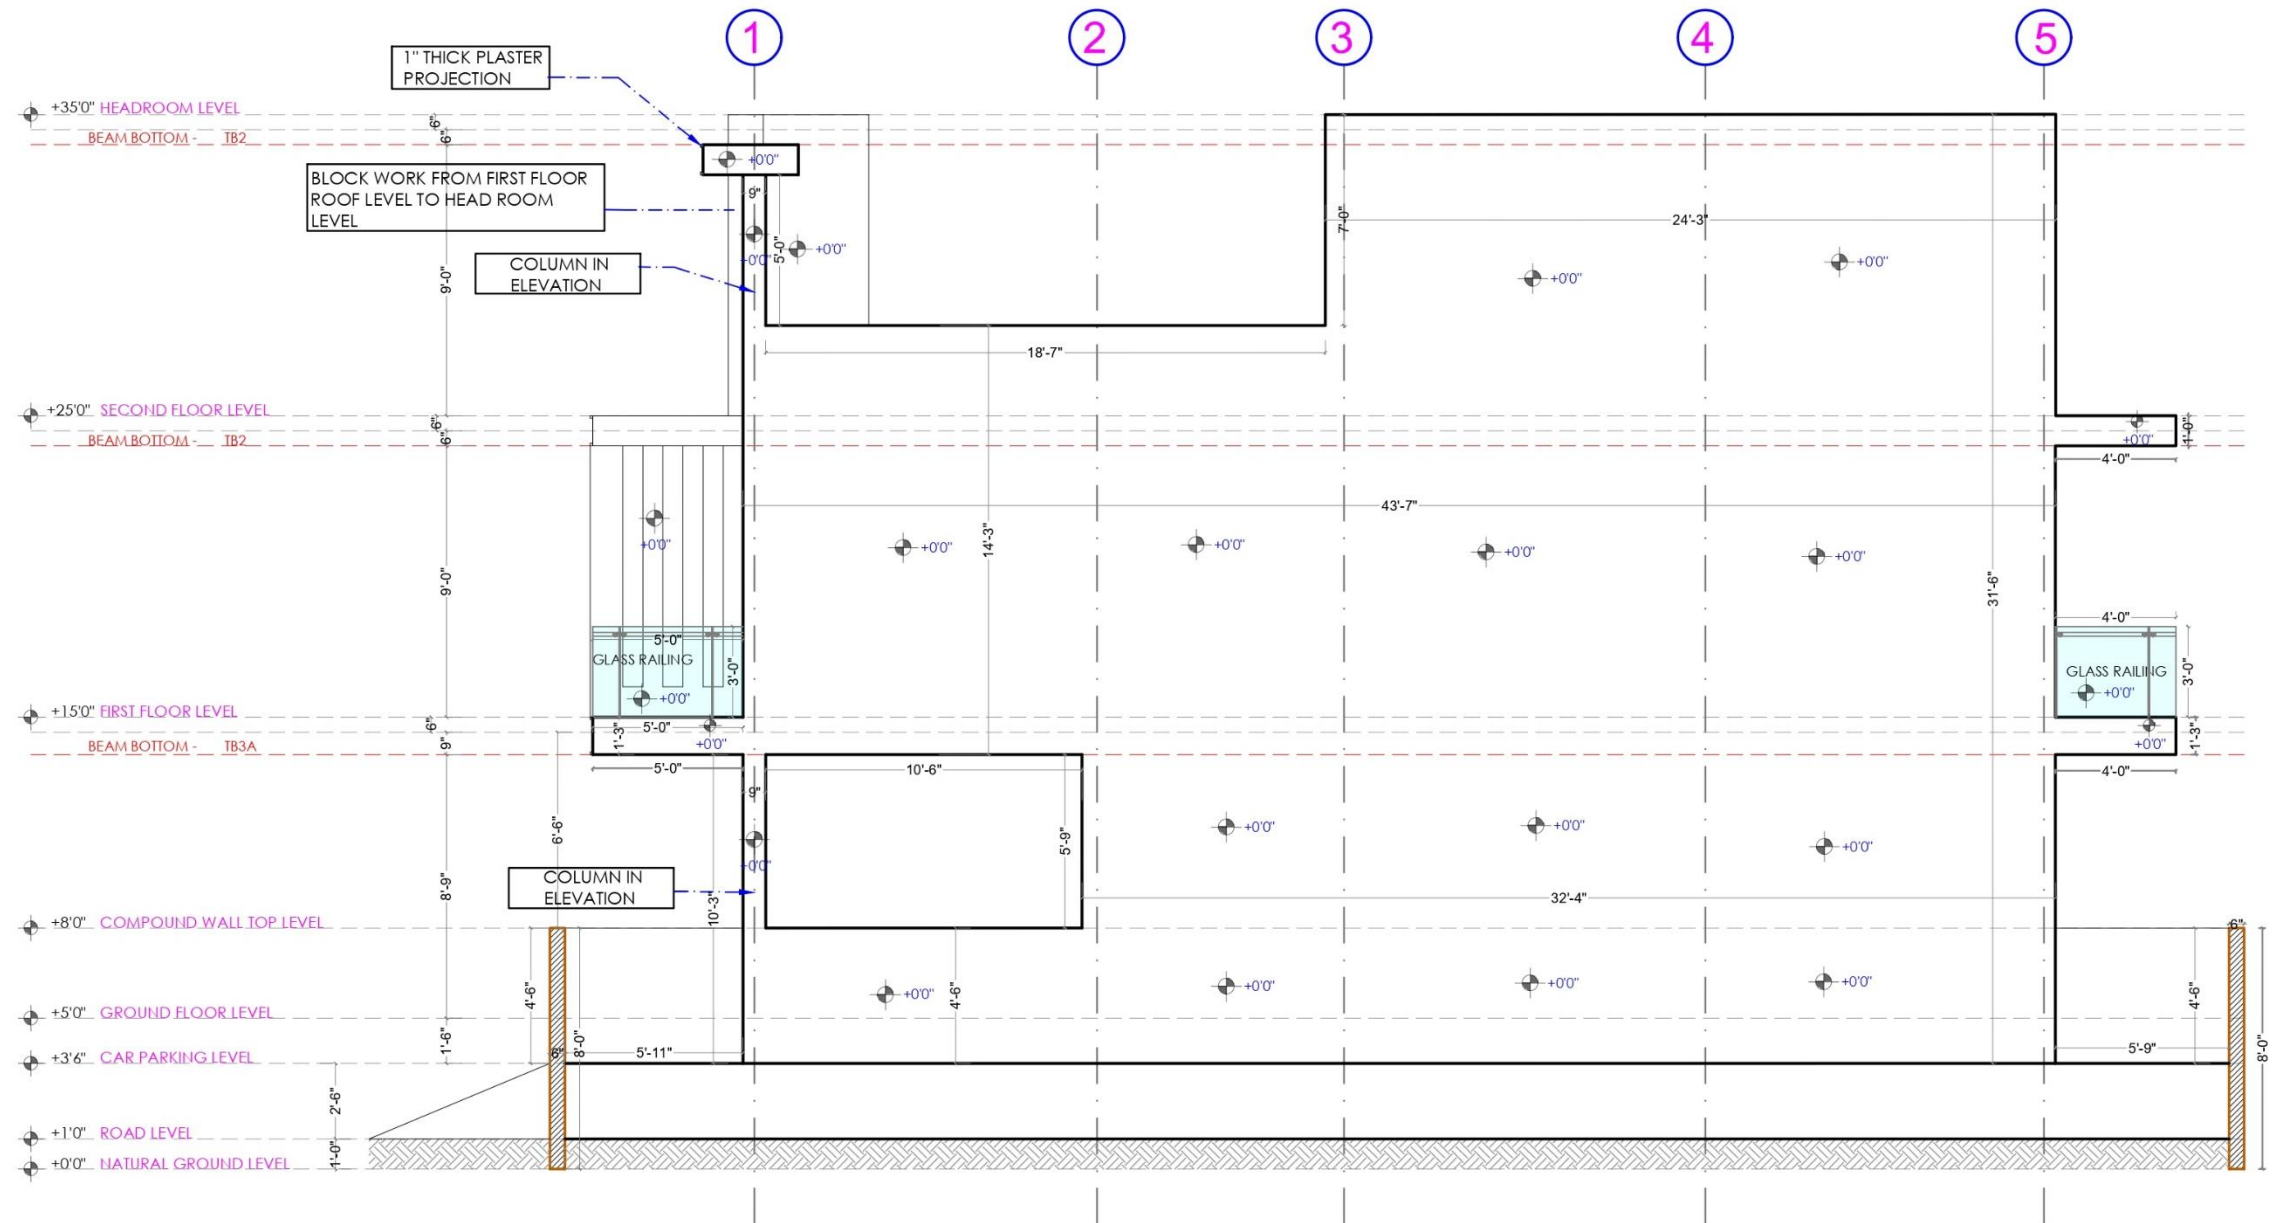

2

EAST ELEVATION

DRAWING TITLE:

Mr. Poovarasana Raja 2D
Elevation

CLIENT:

Mr. Poovarasana Raja

ARCHITECTURAL DESIGNERS:


**DEEJOS ENGINEERS AND
CONTRACTORS PVT Ltd**

2nd floor, C.L.C. Road, Chrompet,
Chennai-600 044,
Mobile: +91-8110000384
Email: projects@deejos.com

SIGNATURE & SEAL:

ORIENTATION:



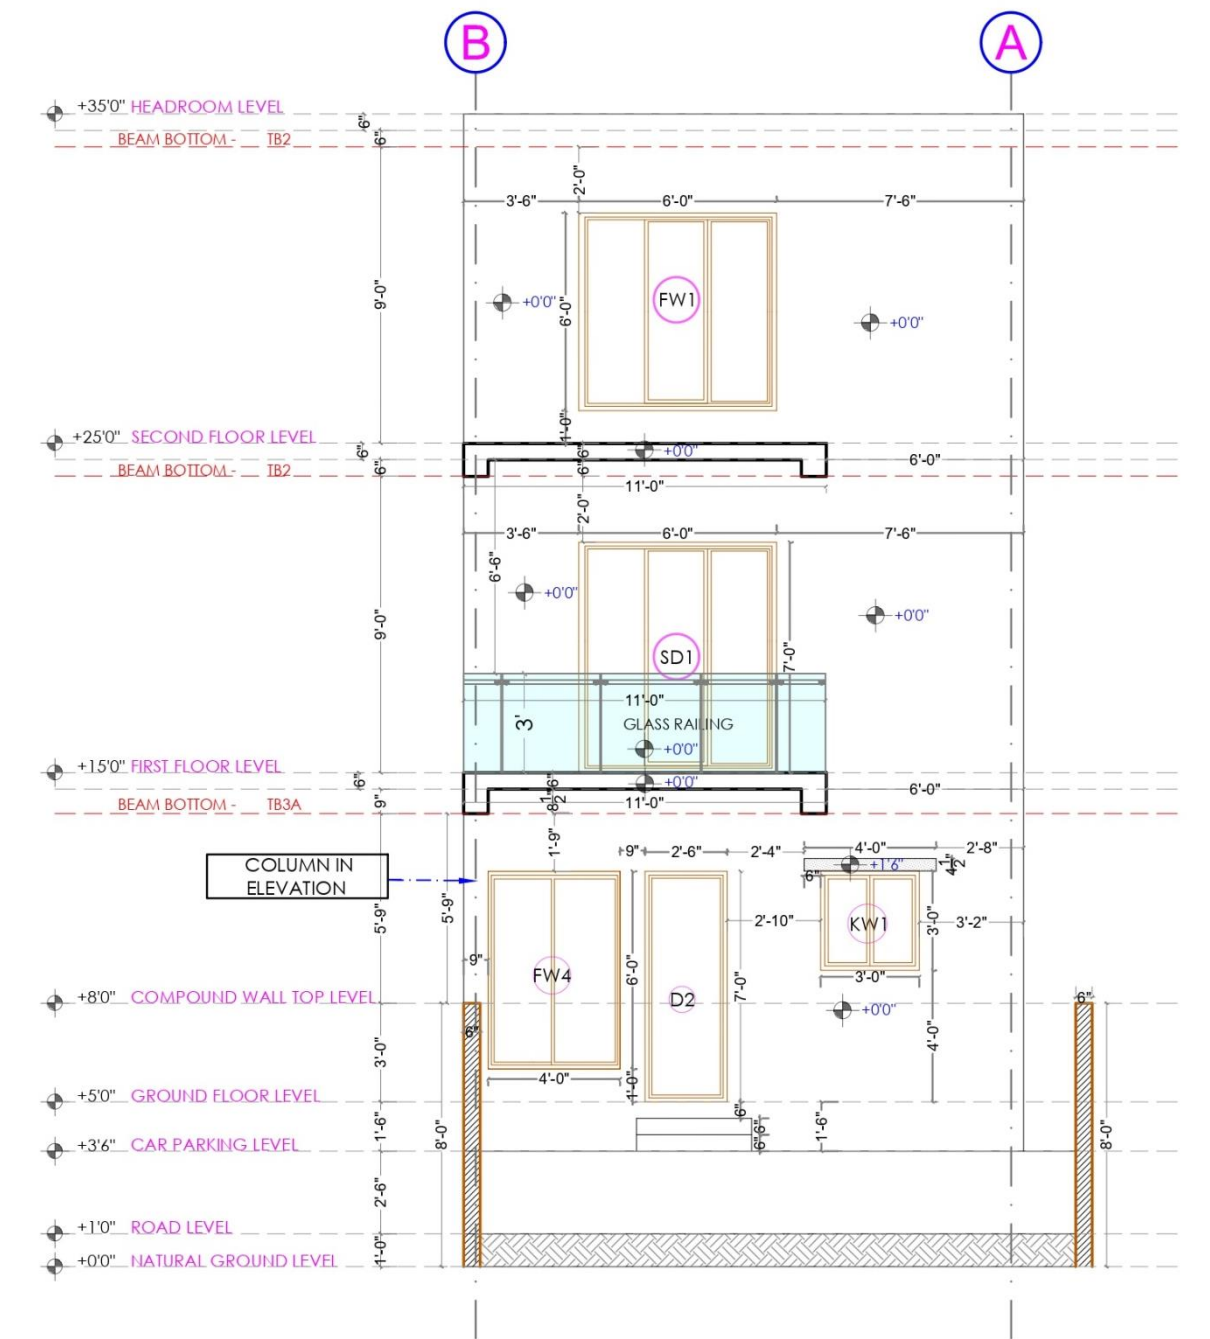

3 NORTH ELEVATION

DRAWING TITLE:

Mr. Poovarasana Raja 2D
Elevation

CLIENT:

Mr. Poovarasana Raja

ARCHITECTURAL DESIGNERS:


**DEEJOS ENGINEERS AND
CONTRACTORS PVT Ltd**

2nd floor, C.L.C. Road, Chrompet,
Chennai-600 044,
Mobile: +91-8110000384
Email: projects@deejos.com

SIGNATURE & SEAL:

ORIENTATION:



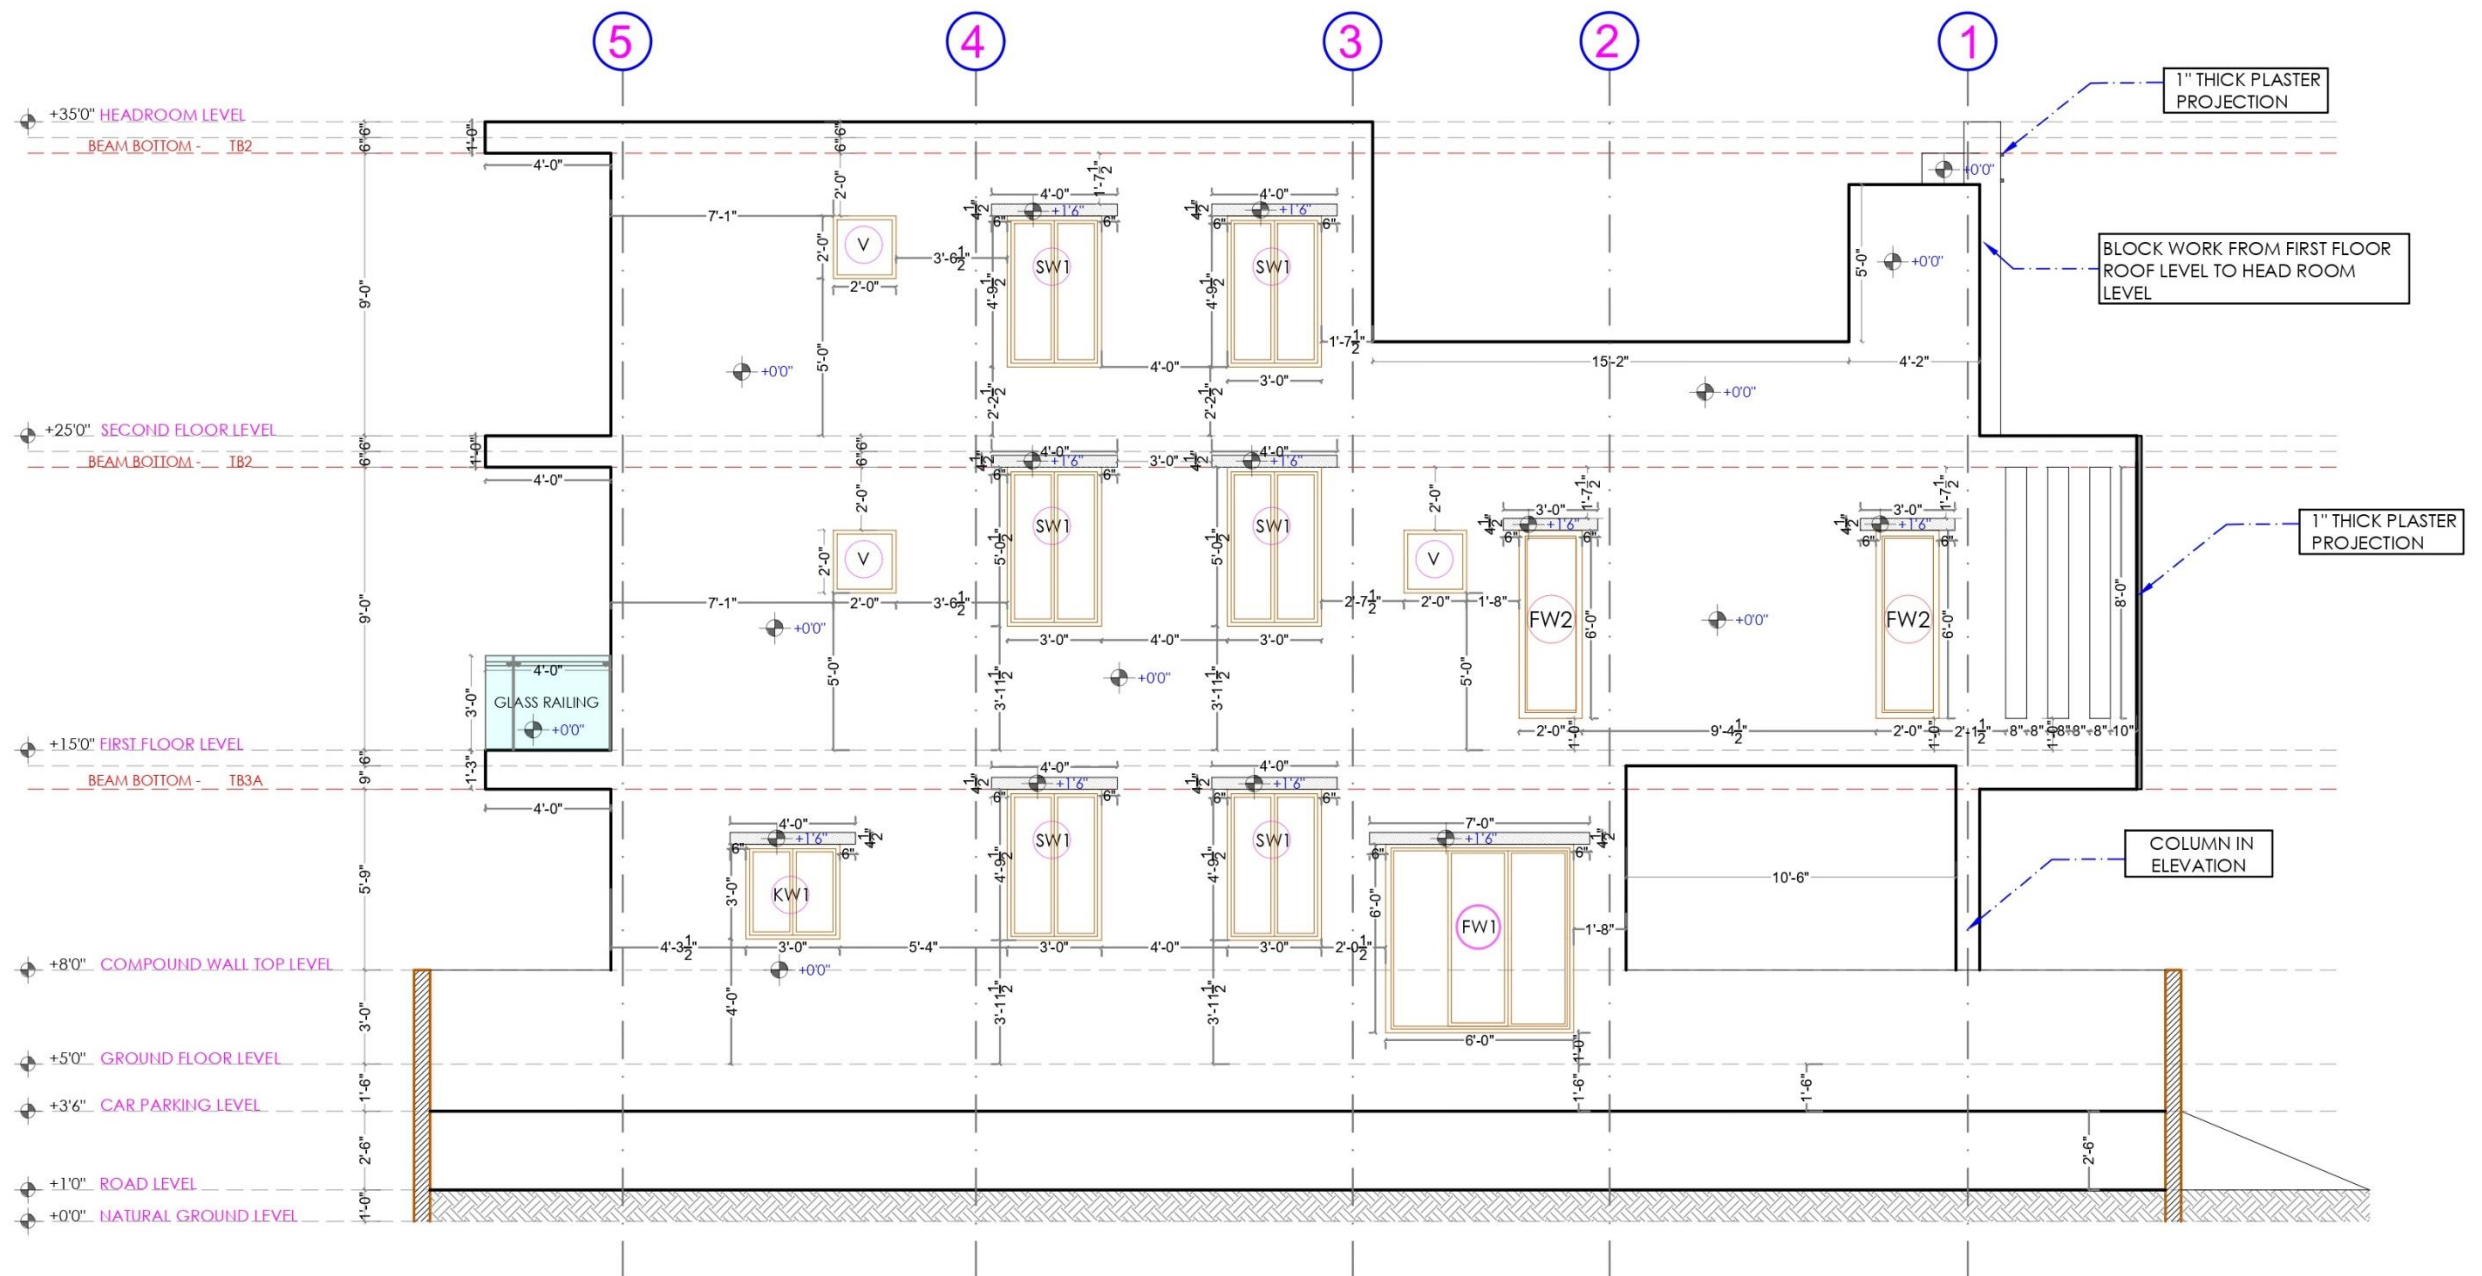

4 WEST ELEVATION

DRAWING TITLE:

Mr. Poovarasana Raja 2D
Elevation

CLIENT:

Mr. Poovarasana Raja

ARCHITECTURAL DESIGNERS:


**DEEJOS ENGINEERS AND
CONTRACTORS PVT Ltd**

2nd floor, C.L.C. Road, Chrompet,
Chennai-600 044,
Mobile: +91-8110000384
Email: projects@deejos.com


SIGNATURE & SEAL:

ORIENTATION:



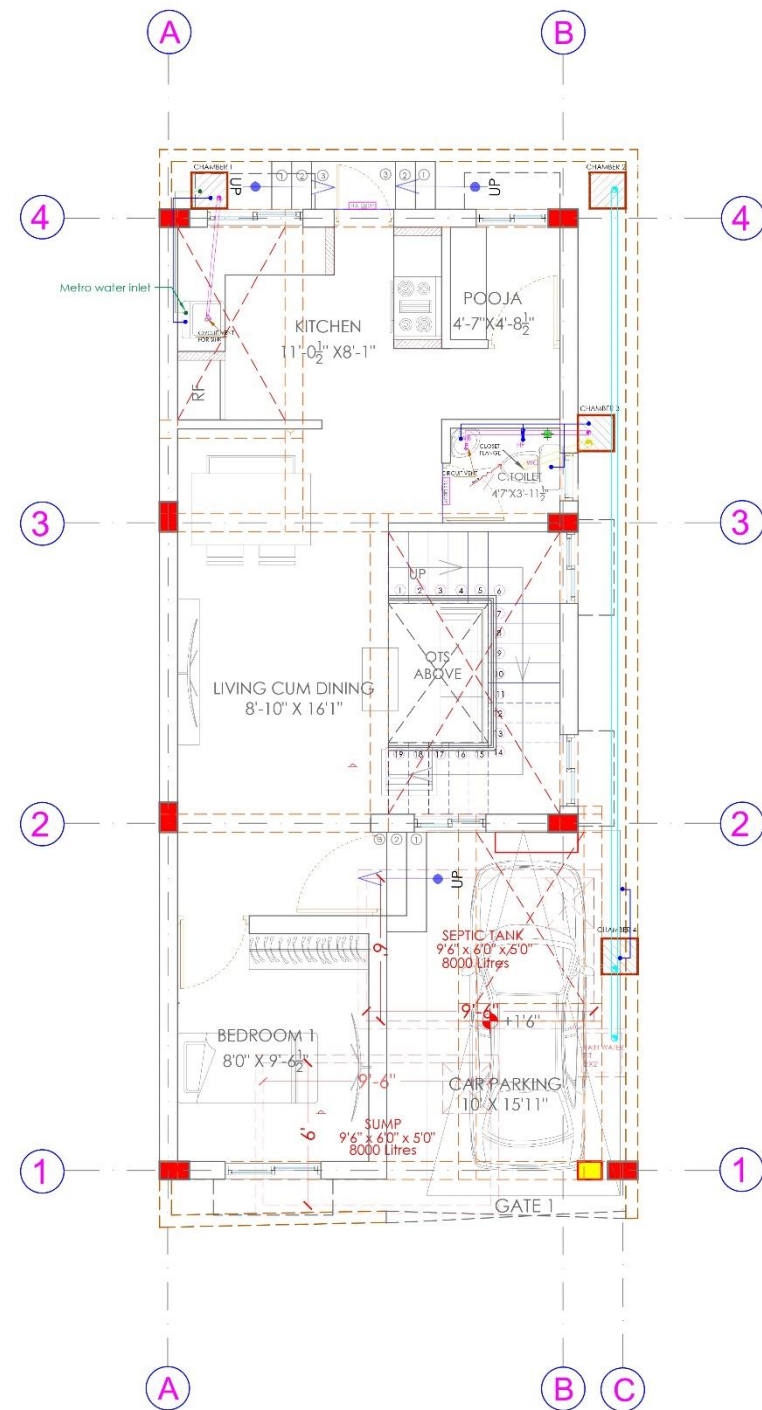

LEGEND		
	EWC	EUROPEAN WATER CLOSET (Wall mounted with flush valve)
	WB	WASH BASIN
	FT	FLOOR TRAP
	RWP	RAIN WATER PIPE 160Ø PVC (4 kg)
	SP	SOIL PIPE 110Ø PVC (6 kg)
	WP	WASTE PIPE 75Ø PVC (6 kg)
	WP	WASTE PIPE 40Ø PVC (10 kg)
	G	GEYSER
	BV	BALL VALVE
	CWS	COLD WATER SUPPLY Cpvc PIPE
	HWS	HOT WATER SUPPLY Cpvc PIPE
	M	MOTOR
	HF	HEALTH FAUCET
	HS	HAND SHOWER

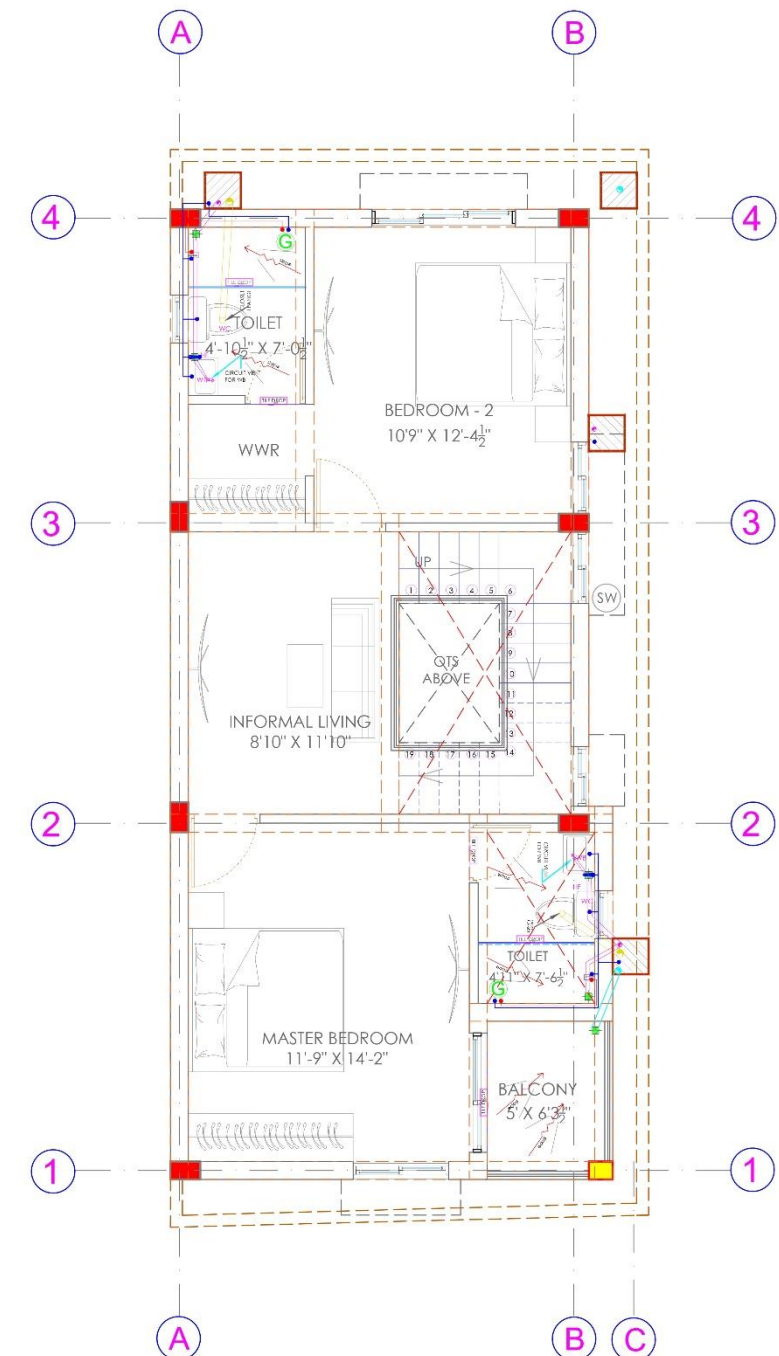

DRAWING TITLE:

Mr. Prabhu Residence
Plumbing Drawing

CLIENT:

Mr. Prabhu

ARCHITECTURAL DESIGNERS:

**DEEJOS ENGINEERS AND
CONTRACTORS PVT Ltd**


2nd floor, C.L.C. Road, Chrompet,
Chennai-600 044,
Mobile: +91-8110000384
Email: projects@deejos.com

SIGNATURE & SEAL:

ORIENTATION:



SECOND FLOOR

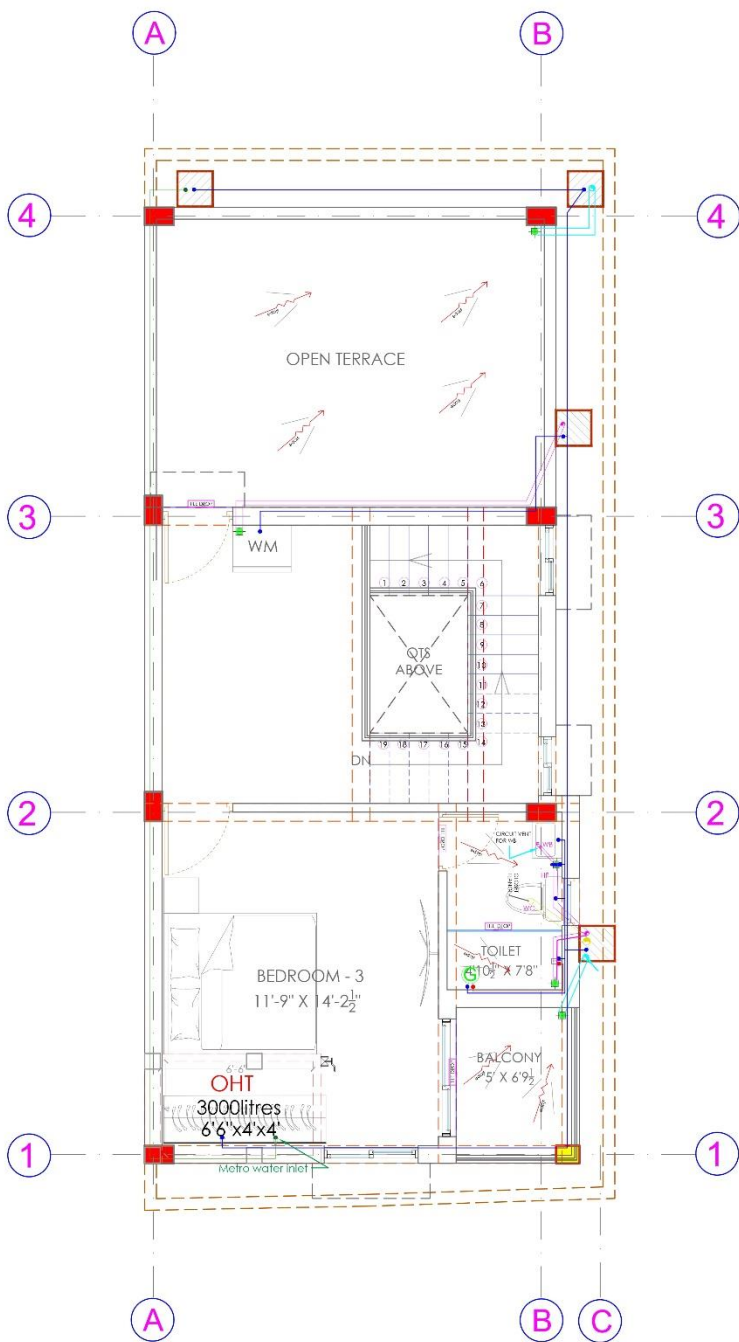

LEGEND		
	EWC	EUROPEAN WATER CLOSET (Wall mounted with flush valve)
	WB	WASH BASIN
	FT	FLOOR TRAP
	RWP	RAIN WATER PIPE 160Ø PVC (4 kg)
	SP	SOIL PIPE 110Ø PVC (6 kg)
	WP	WASTE PIPE 75Ø PVC (6 kg)
	WP	WASTE PIPE 40Ø PVC (10 kg)
	G	GEYSER
	BV	BALL VALVE
	CWS	COLD WATER SUPPLY Cpvc PIPE
	HWS	HOT WATER SUPPLY Cpvc PIPE
	M	MOTOR
	HF	HEALTH FAUCET
	HS	HAND SHOWER

DRAWING TITLE:

Mr. Prabhu Residence
Plumbing Drawing

CLIENT:

Mr. Prabhu

ARCHITECTURAL DESIGNERS:


**DEEJOS ENGINEERS AND
CONTRACTORS PVT Ltd**

2nd floor, C.L.C. Road, Chrompet,
Chennai-600 044,
Mobile: +91-8110000384
Email: projects@deejos.com

SIGNATURE & SEAL:

ORIENTATION:



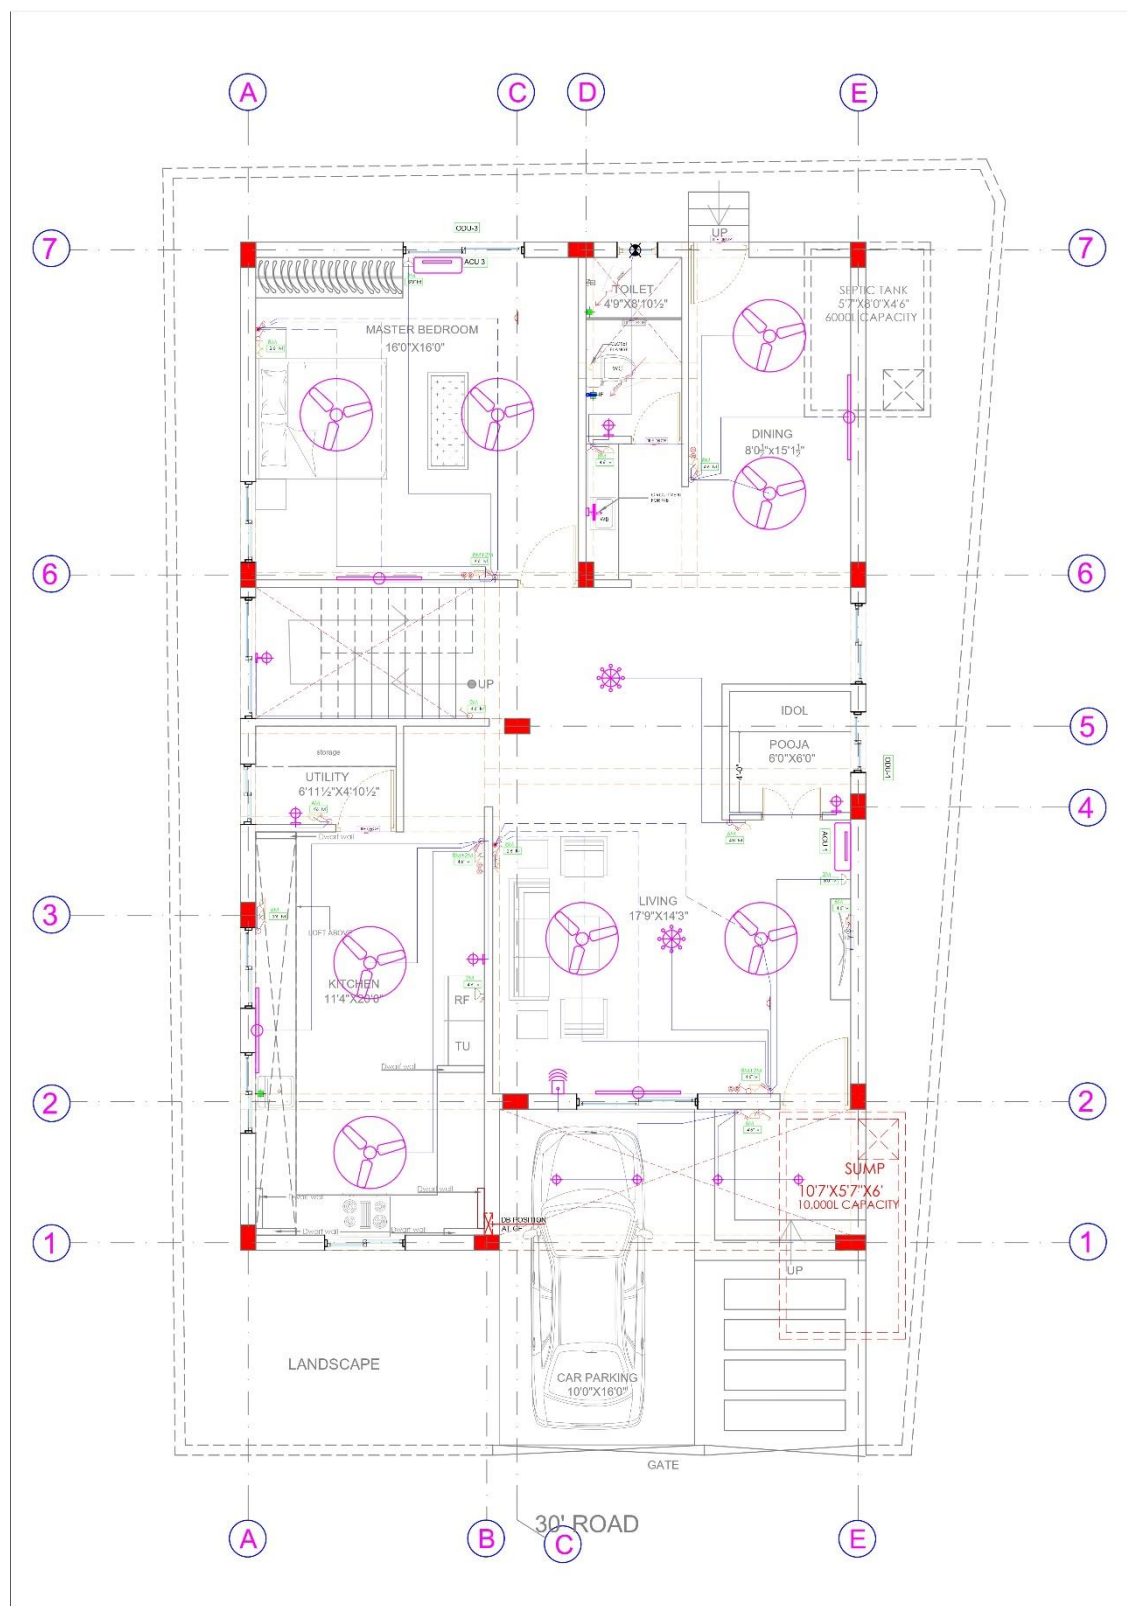

LEGEND	
	CEILING FAN
	AIR CONDITIONER / AC TRIP SWITCH
	FLOURESCENT LIGHT
	SPOT LIGHT
	WALL LIGHT
	CHANDLIER
	MIRROR LAMP
	CALLING BELL
	EXHAUST FAN
	GEYSER
	DISTRIBUTION BOARD
	U HOOK
	JHULA HOOK
	15A SOCKET
	10A SOCKET
	SOCKET FOR RO
	SOCKET FOR CHIMNEY
	REGULATOR
	SINGLE GANG SWITCH
	DOUBLE GANG SWITCH
	TRIPLE GANG SWITCH
	SINGLE TWO WAY SWITCH
	DOUBLE TWO WAY SWITCH
	TV AND INTERNET POINT
	WALL FAN

GROUND FLOOR

DRAWING TITLE:

Mr. Pradheep Residence
Electrical Drawing

CLIENT:

Mr. Pradheep


ARCHITECTURAL DESIGNERS:


**DEEJOS ENGINEERS AND
CONTRACTORS PVT Ltd**

2nd floor, C.L.C. Road, Chrompet,
Chennai-600 044,
Mobile: +91-8110000384
Email: projects@deejos.com

SIGNATURE & SEAL:

ORIENTATION:

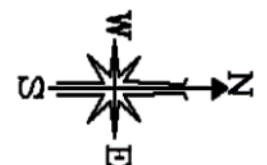


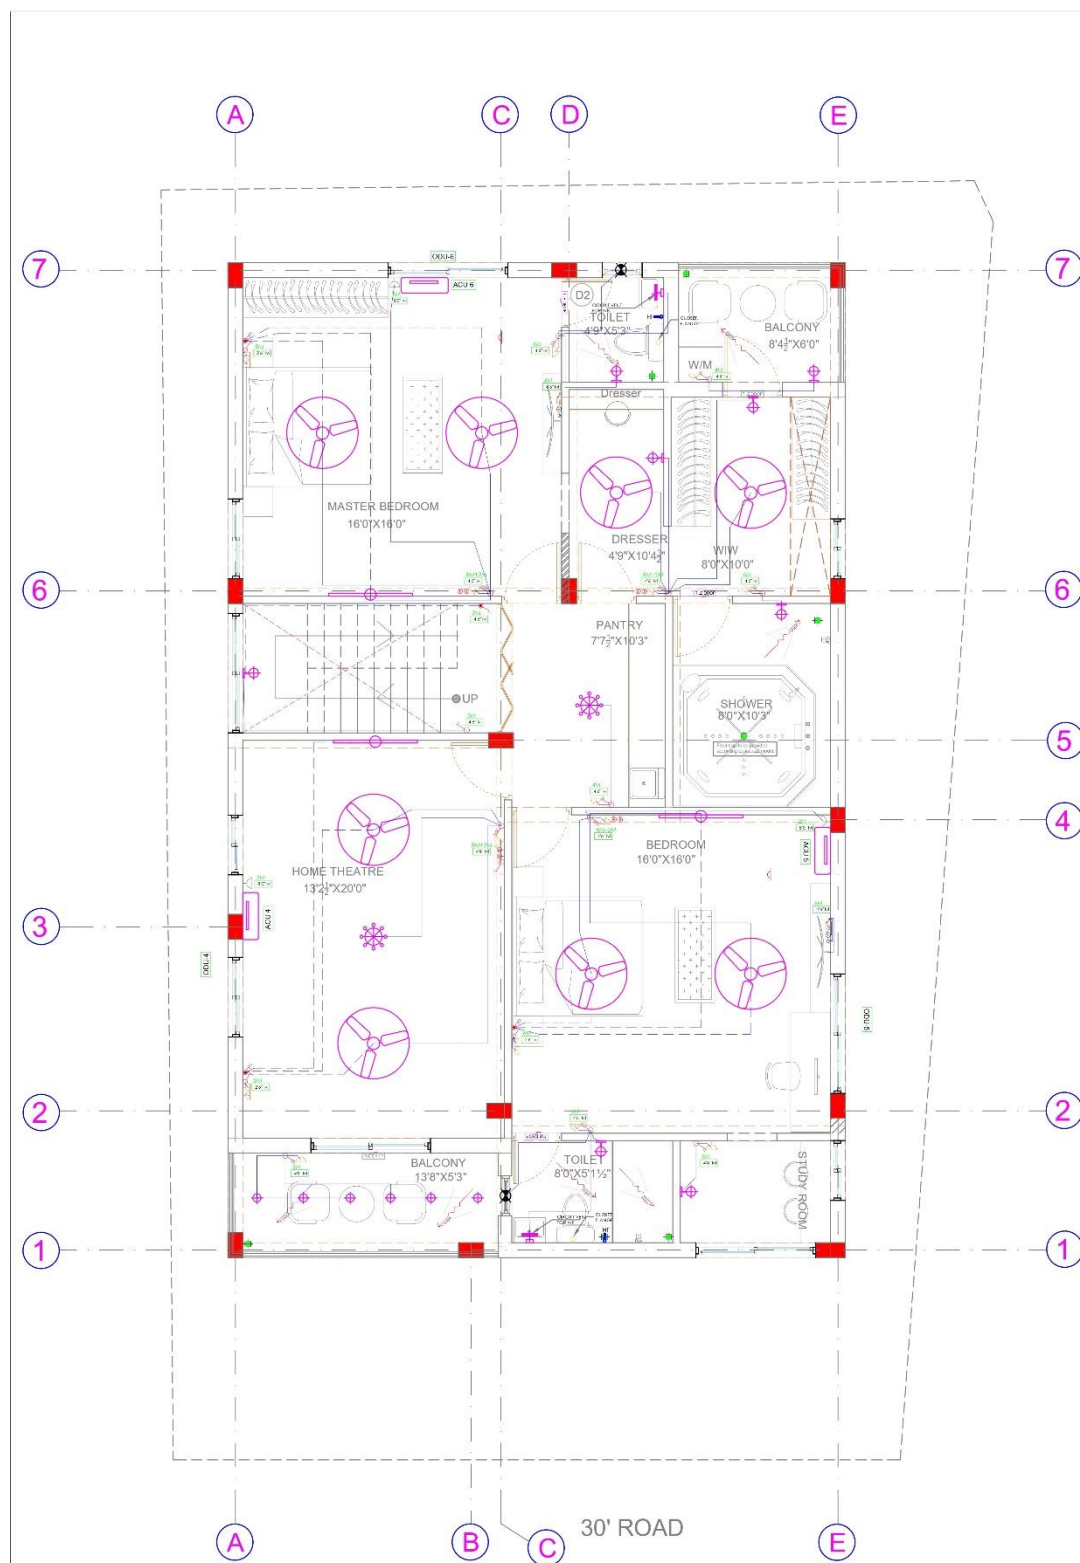

LEGEND	
	CEILING FAN
	AIR CONDITIONER / AC TRIP SWITCH
	FLOURESCENT LIGHT
	SPOT LIGHT
	WALL LIGHT
	CHANDLIER
	MIRROR LAMP
	CALLING BELL
	EXHAUST FAN
	GEYSER
	DISTRIBUTION BOARD
	U HOOK
	JHULA HOOK
	15A SOCKET
	10A SOCKET
	SOCKET FOR RO
	SOCKET FOR CHIMNEY
	REGULATOR
	SINGLE GANG SWITCH
	DOUBLE GANG SWITCH
	TRIPLE GANG SWITCH
	SINGLE TWO WAY SWITCH
	DOUBLE TWO WAY SWITCH
	TV AND INTERNET POINT
	WALL FAN

FIRST FLOOR

<u>DRAWING TITLE:</u> Mr. Pradheep Residence Electrical Drawing	<u>ARCHITECTURAL DESIGNERS:</u> DEEJOS ENGINEERS AND CONTRACTORS PVT Ltd 2nd floor, C.L.C. Road, Chrompet, Chennai-600 044, Mobile: +91-8110000384 Email: projects@deejos.com	<u>SIGNATURE & SEAL:</u>	<u>ORIENTATION:</u>
<u>CLIENT:</u> Mr. Pradheep			

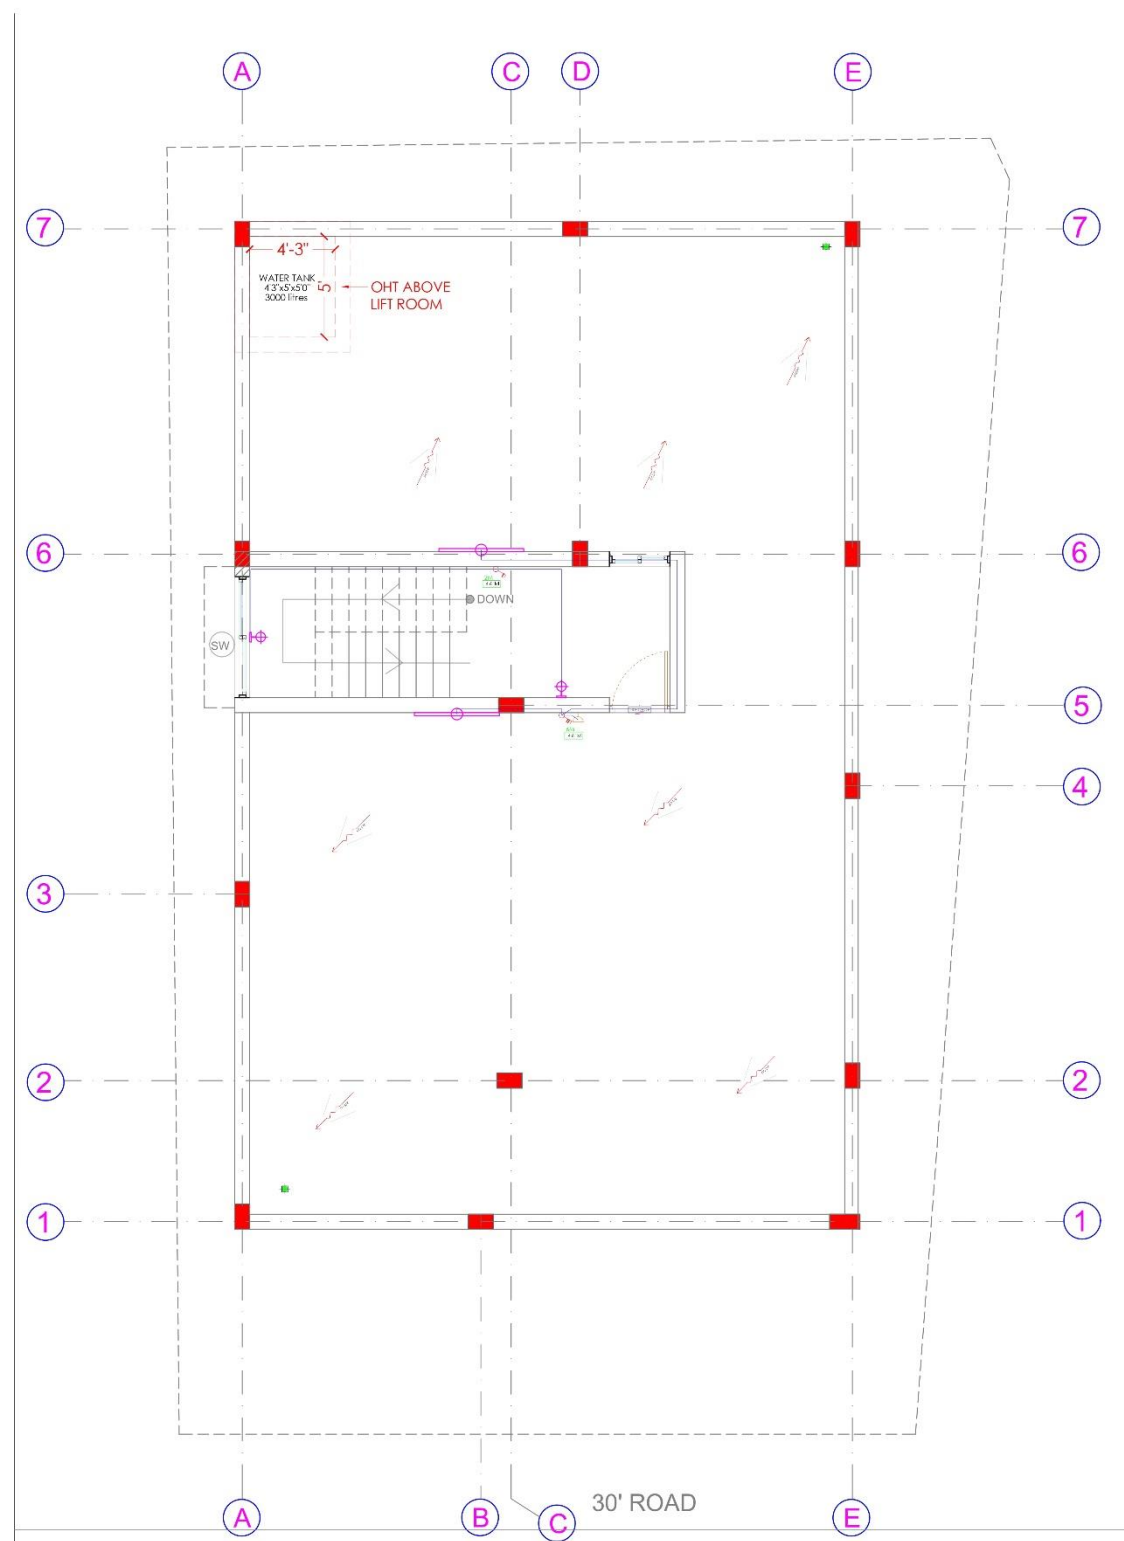

LEGEND	
	CEILING FAN
	AIR CONDITIONER / AC TRIP SWITCH
	FLOURESCENT LIGHT
	SPOT LIGHT
	WALL LIGHT
	CHANDLIER
	MIRROR LAMP
	CALLING BELL
	EXHAUST FAN
	GEYSER
	DISTRIBUTION BOARD
	U HOOK
	JHULA HOOK
	15A SOCKET
	10A SOCKET
	SOCKET FOR RO
	SOCKET FOR CHIMNEY
	REGULATOR
	SINGLE GANG SWITCH
	DOUBLE GANG SWITCH
	TRIPLE GANG SWITCH
	SINGLE TWO WAY SWITCH
	DOUBLE TWO WAY SWITCH
	TV AND INTERNET POINT
	WALL FAN

SECOND FLOOR

DRAWING TITLE:

Mr. Pradheep Residence
Electrical Drawing

CLIENT:

Mr. Pradheep


ARCHITECTURAL DESIGNERS:

**DEEJOS ENGINEERS AND
CONTRACTORS PVT Ltd**


2nd floor, C.L.C. Road, Chrompet,
Chennai-600 044,
Mobile: +91-8110000384
Email: projects@deejos.com

SIGNATURE & SEAL:

ORIENTATION:

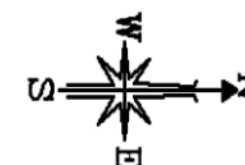

GROUND FLOOR

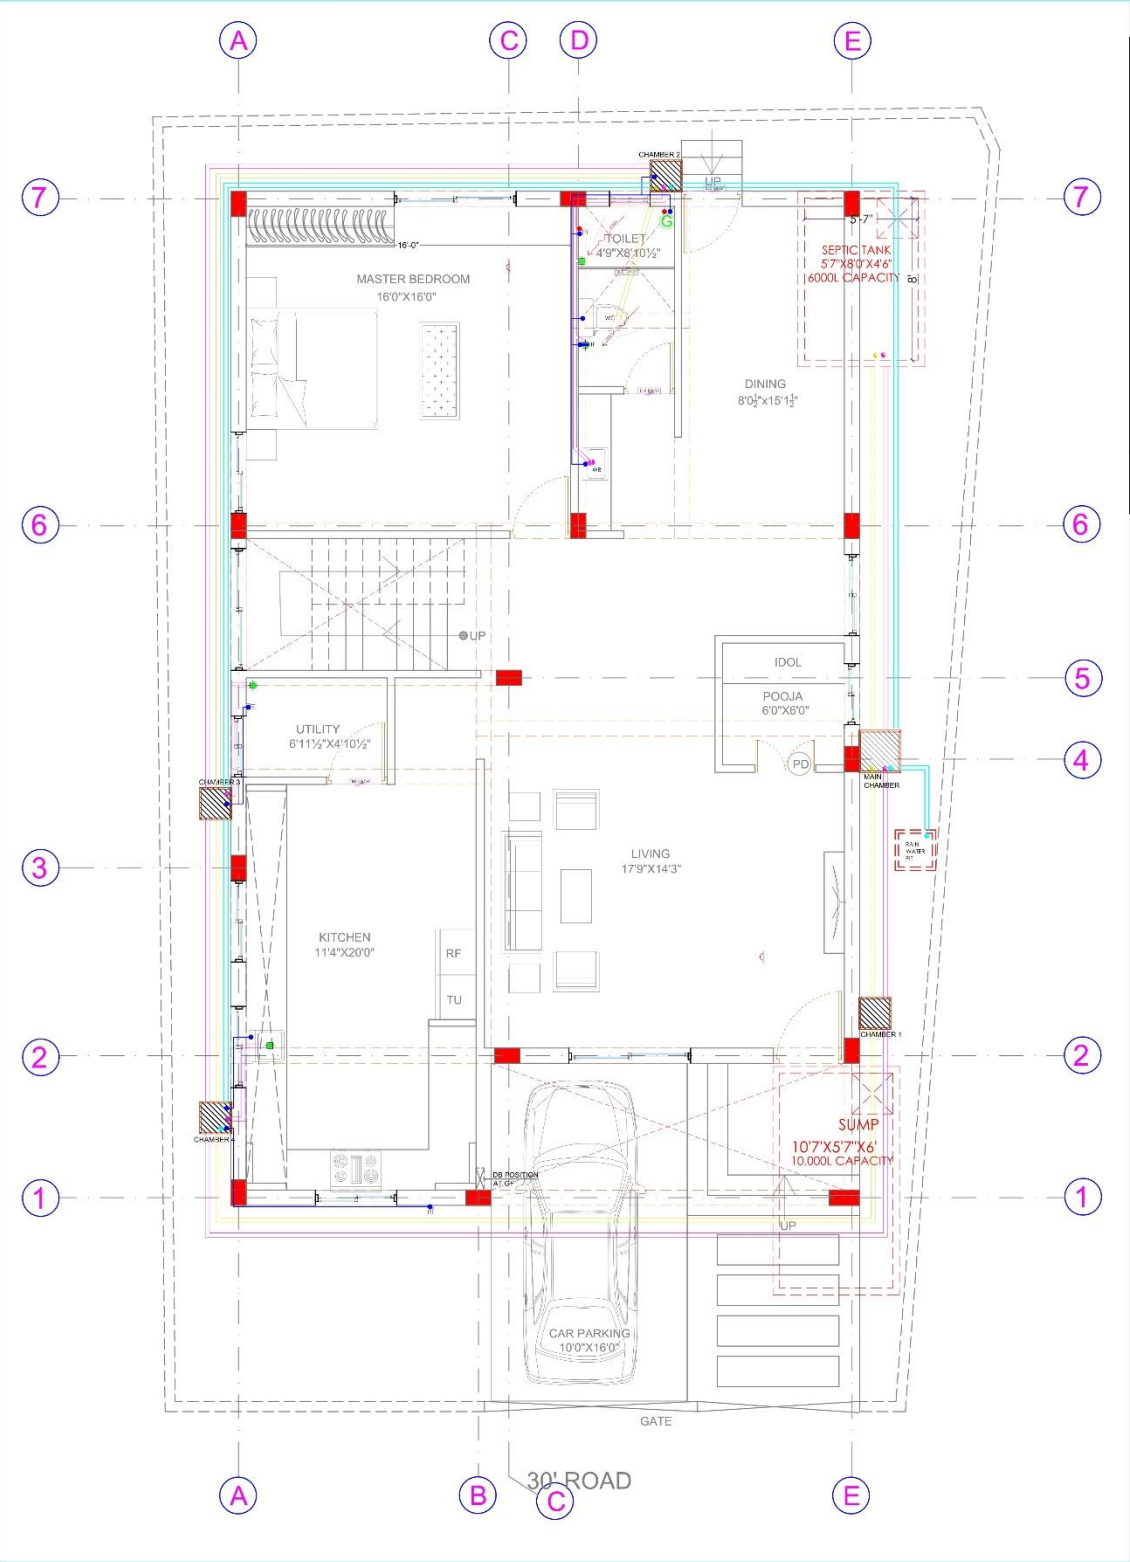

LEGEND		
	EWC	EUROPEAN WATER CLOSET (Wall mounted with flush valve)
	WB	WASH BASIN
	FT	FLOOR TRAP
	RWP	RAIN WATER PIPE 160Ø PVC (4 kg)
	SP	SOIL PIPE 110Ø PVC (6 kg)
	WP	WASTE PIPE 75Ø PVC (6 kg)
	WP	WASTE PIPE 40Ø PVC (10 kg)
	G	GEYSER
	BV	BALL VALVE
	CWS	COLD WATER SUPPLY Cpvc PIPE
	HWS	HOT WATER SUPPLY Cpvc PIPE
	M	MOTOR
	HF	HEALTH FAUCET
	HS	HAND SHOWER

DRAWING TITLE:

Mr. Pradheep Residence
Plumbing Drawing

CLIENT:

Mr. Pradheep


ARCHITECTURAL DESIGNERS:

**DEEJOS ENGINEERS AND
CONTRACTORS PVT Ltd**


2nd floor, C.L.C. Road, Chrompet,
Chennai-600 044,
Mobile: +91-8110000384
Email: projects@deejos.com

SIGNATURE & SEAL:

ORIENTATION:

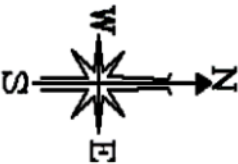

FIRST FLOOR

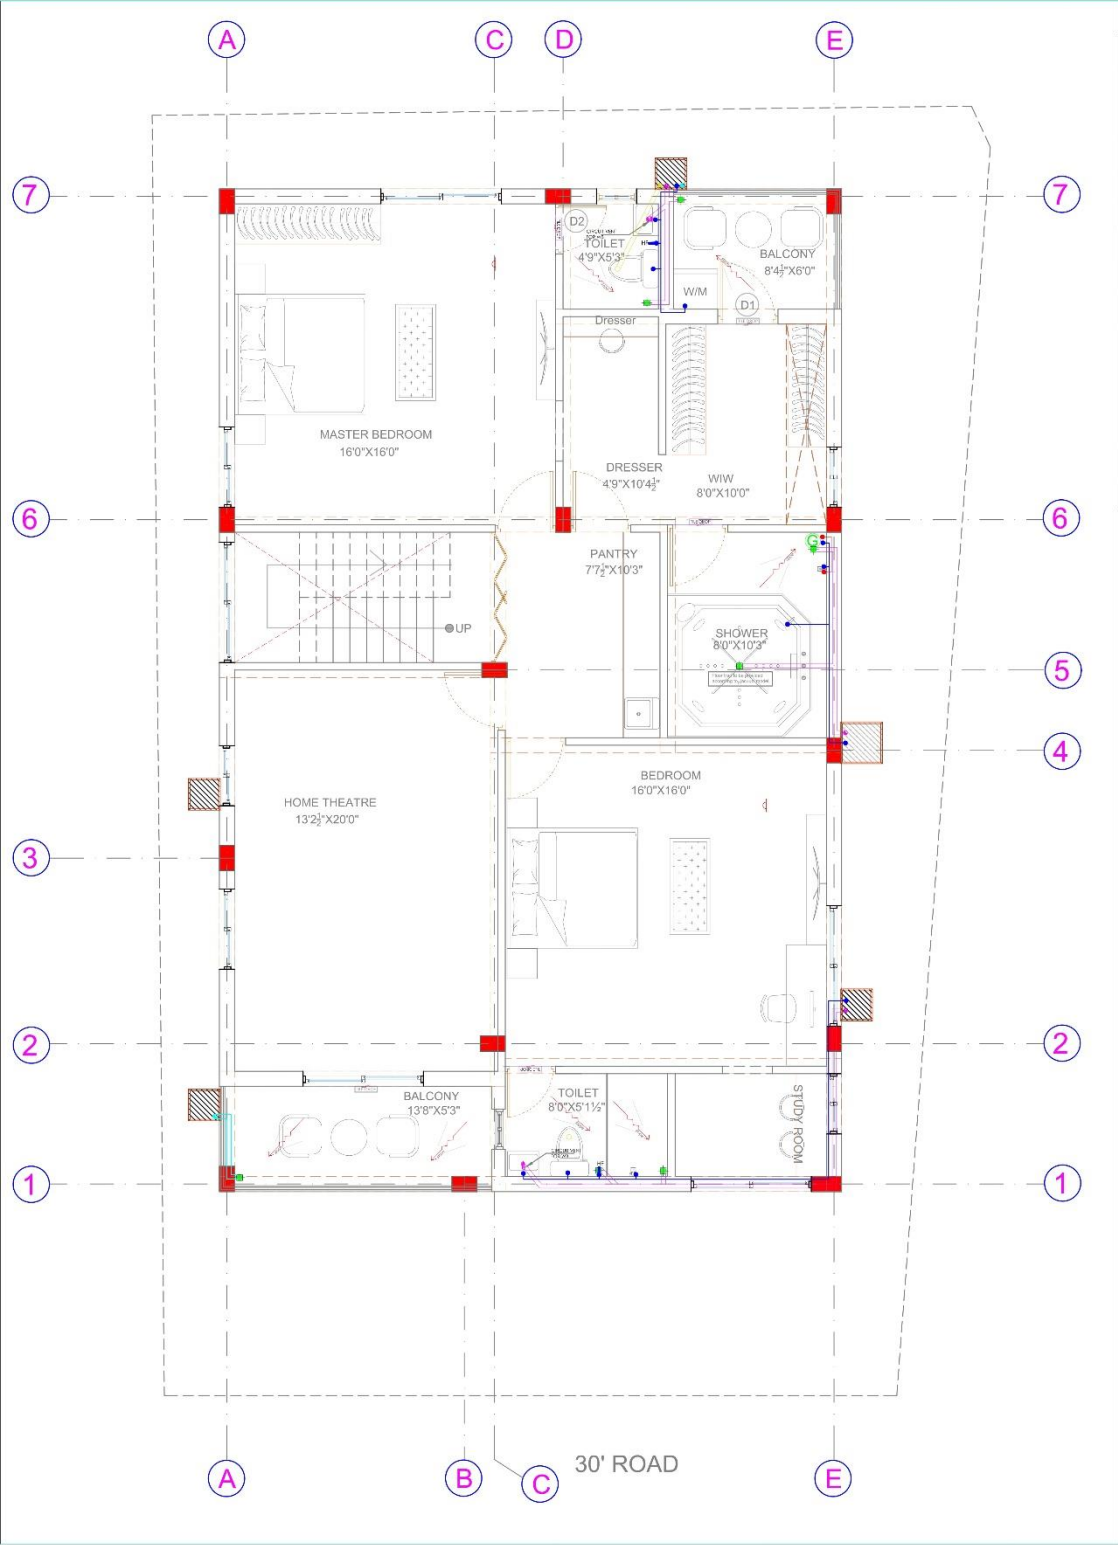

LEGEND		
	EWC	EUROPEAN WATER CLOSET (Wall mounted with flush valve)
	WB	WASH BASIN
	FT	FLOOR TRAP
	RWP	RAIN WATER PIPE 160Ø PVC (4 kg)
	SP	SOIL PIPE 110Ø PVC (6 kg)
	WP	WASTE PIPE 75Ø PVC (6 kg)
	WP	WASTE PIPE 40Ø PVC (10 kg)
	G	GEYSER
	BV	BALL VALVE
	CWS	COLD WATER SUPPLY Cpvc PIPE
	HWS	HOT WATER SUPPLY Cpvc PIPE
	M	MOTOR
	HF	HEALTH FAUCET
	HS	HAND SHOWER

DRAWING TITLE:

Mr. Pradheep Residence
Plumbing Drawing

CLIENT:

Mr. Pradheep


ARCHITECTURAL DESIGNERS:

**DEEJOS ENGINEERS AND
CONTRACTORS PVT Ltd**


2nd floor, C.L.C. Road, Chrompet,
Chennai-600 044,
Mobile: +91-8110000384
Email: projects@deejos.com

SIGNATURE & SEAL:

ORIENTATION:

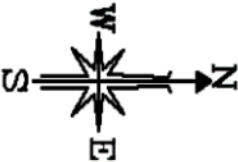

SECOND FLOOR

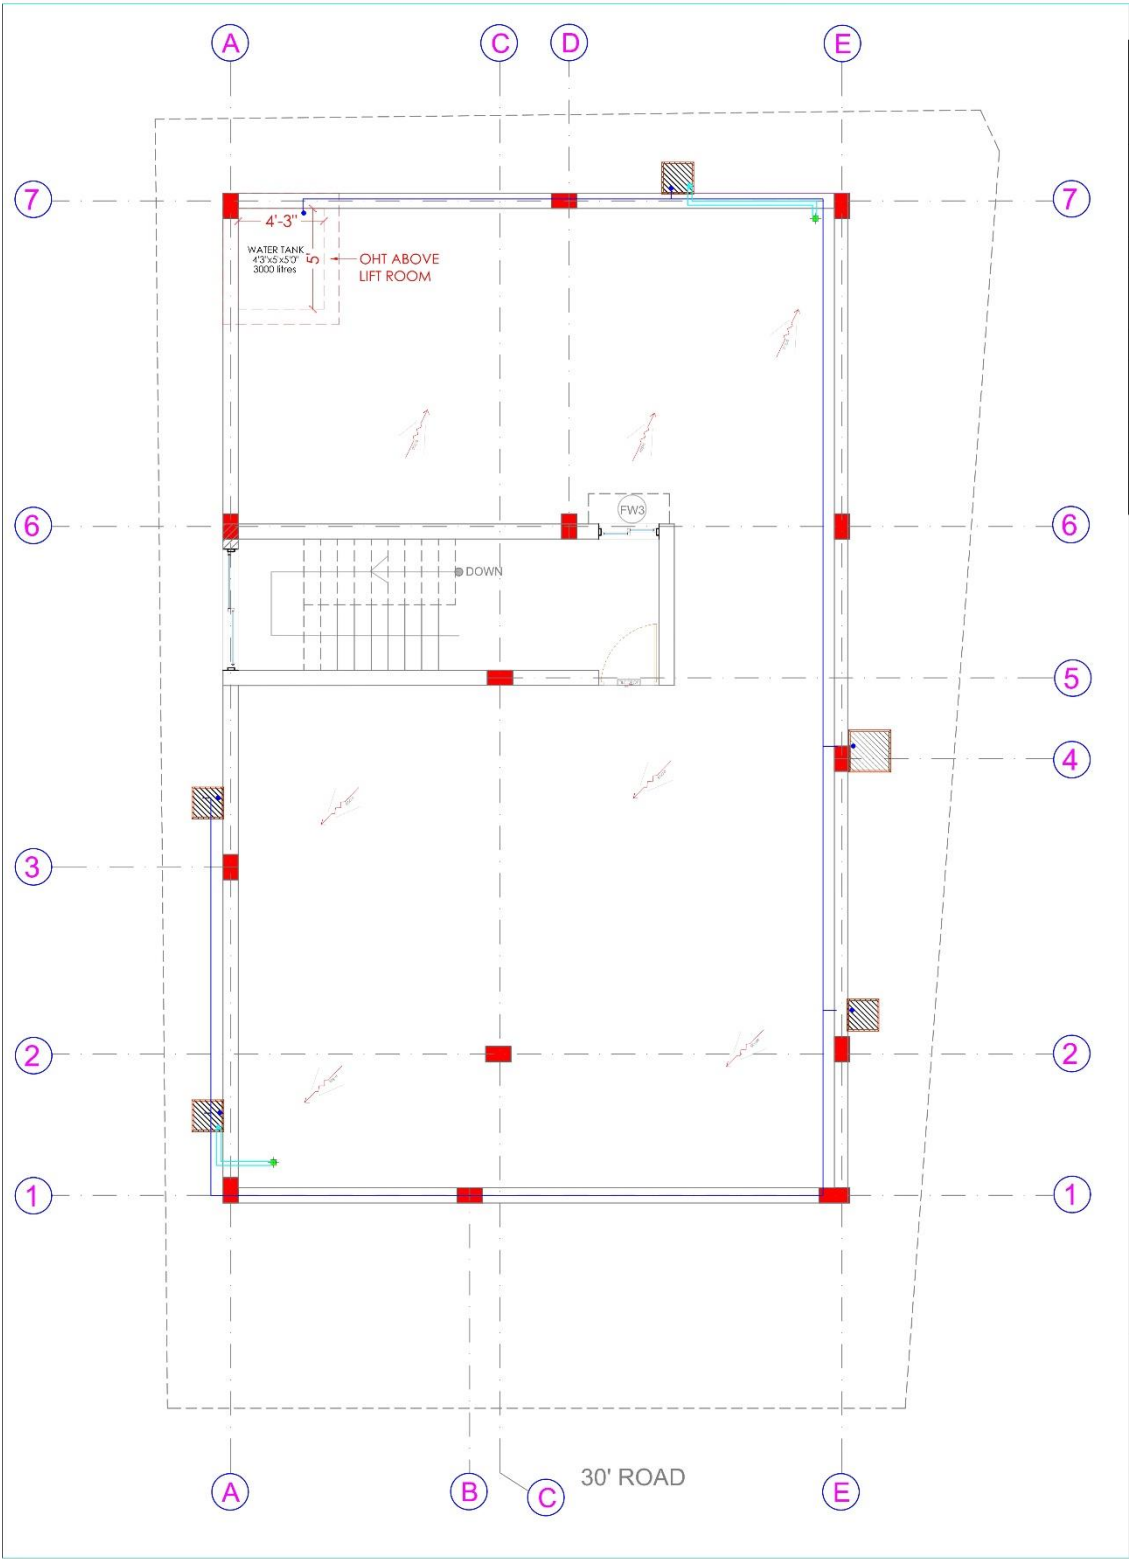

LEGEND		
	EWC	EUROPEAN WATER CLOSET (Wall mounted with flush valve)
	WB	WASH BASIN
	FT	FLOOR TRAP
	RWP	RAIN WATER PIPE 160Ø PVC (4 kg)
	SP	SOIL PIPE 110Ø PVC (6 kg)
	WP	WASTE PIPE 75Ø PVC (6 kg)
	WP	WASTE PIPE 40Ø PVC (10 kg)
	G	GEYSER
	BV	BALL VALVE
	CWS	COLD WATER SUPPLY Cpvc PIPE
	HWS	HOT WATER SUPPLY Cpvc PIPE
	M	MOTOR
	HF	HEALTH FAUCET
	HS	HAND SHOWER

DRAWING TITLE:

Mr. Pradheep Residence
Plumbing Drawing

CLIENT:

Mr. Pradheep


ARCHITECTURAL DESIGNERS:

**DEEJOS ENGINEERS AND
CONTRACTORS PVT Ltd**

2nd floor, C.L.C. Road, Chrompet,
Chennai-600 044,
Mobile: +91-8110000384
Email: projects@deejos.com

SIGNATURE & SEAL:

ORIENTATION:

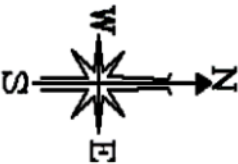



OPTION 1

DRAWING TITLE:

Mr. Prem Kumar Residence 3D
Elevation

CLIENT:

Mr. Prem Kumar


ARCHITECTURAL DESIGNERS:

**DEEJOS ENGINEERS AND
CONTRACTORS PVT Ltd**

2nd floor, C.L.C. Road, Chrompet,
Chennai-600 044,
Mobile: +91-8110000384
Email: projects@deejos.com

SIGNATURE & SEAL:

ORIENTATION:

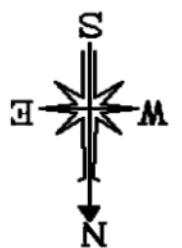



OPTION 2

DRAWING TITLE:

Mr. Prem Kumar Residence 3D
Elevation

CLIENT:

Mr. Prem Kumar


ARCHITECTURAL DESIGNERS:

**DEEJOS ENGINEERS AND
CONTRACTORS PVT Ltd**

2nd floor, C.L.C. Road, Chrompet,
Chennai-600 044,
Mobile: +91-8110000384
Email: projects@deejos.com

SIGNATURE & SEAL:

ORIENTATION:

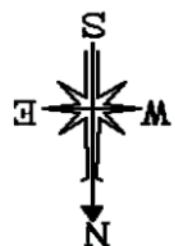



DRAWING TITLE:

Mr. Prem Kumar Residence 3D
Elevation

CLIENT:

Mr. Prem Kumar


ARCHITECTURAL DESIGNERS:


**DEEJOS ENGINEERS AND
CONTRACTORS PVT Ltd**

2nd floor, C.L.C. Road, Chrompet,
Chennai-600 044,
Mobile: +91-8110000384
Email: projects@deejos.com

SIGNATURE & SEAL:

ORIENTATION:

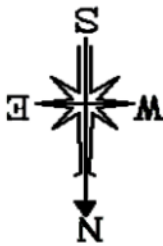

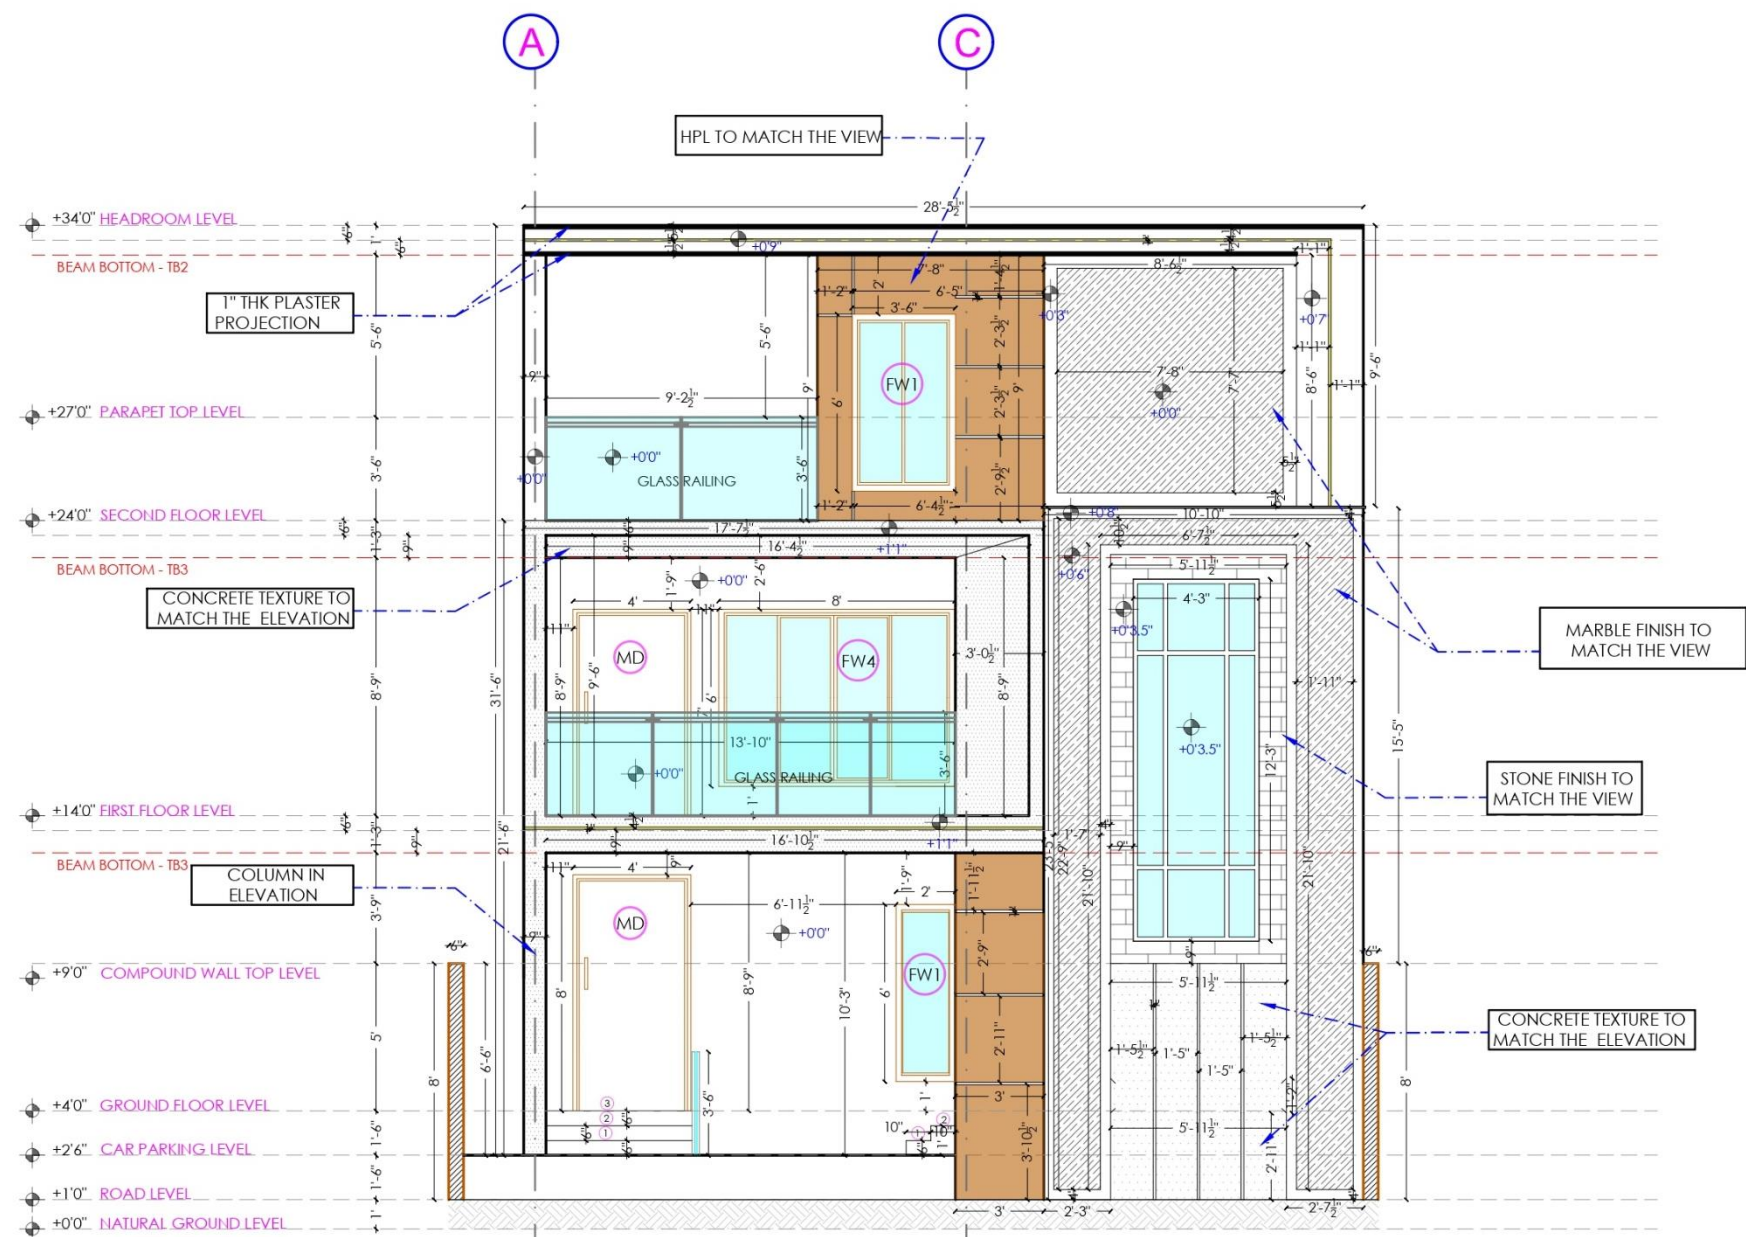

1 NORTH ELEVATION

DRAWING TITLE:

Mr. Prem Kumar Residence 2D
Elevation

CLIENT:

Mr. Prem Kumar


ARCHITECTURAL DESIGNERS:


**DEEJOS ENGINEERS AND
CONTRACTORS PVT Ltd**

2nd floor, C.L.C. Road, Chrompet,
Chennai-600 044,
Mobile: +91-8110000384
Email: projects@deejos.com

SIGNATURE & SEAL:

ORIENTATION:

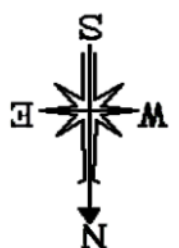

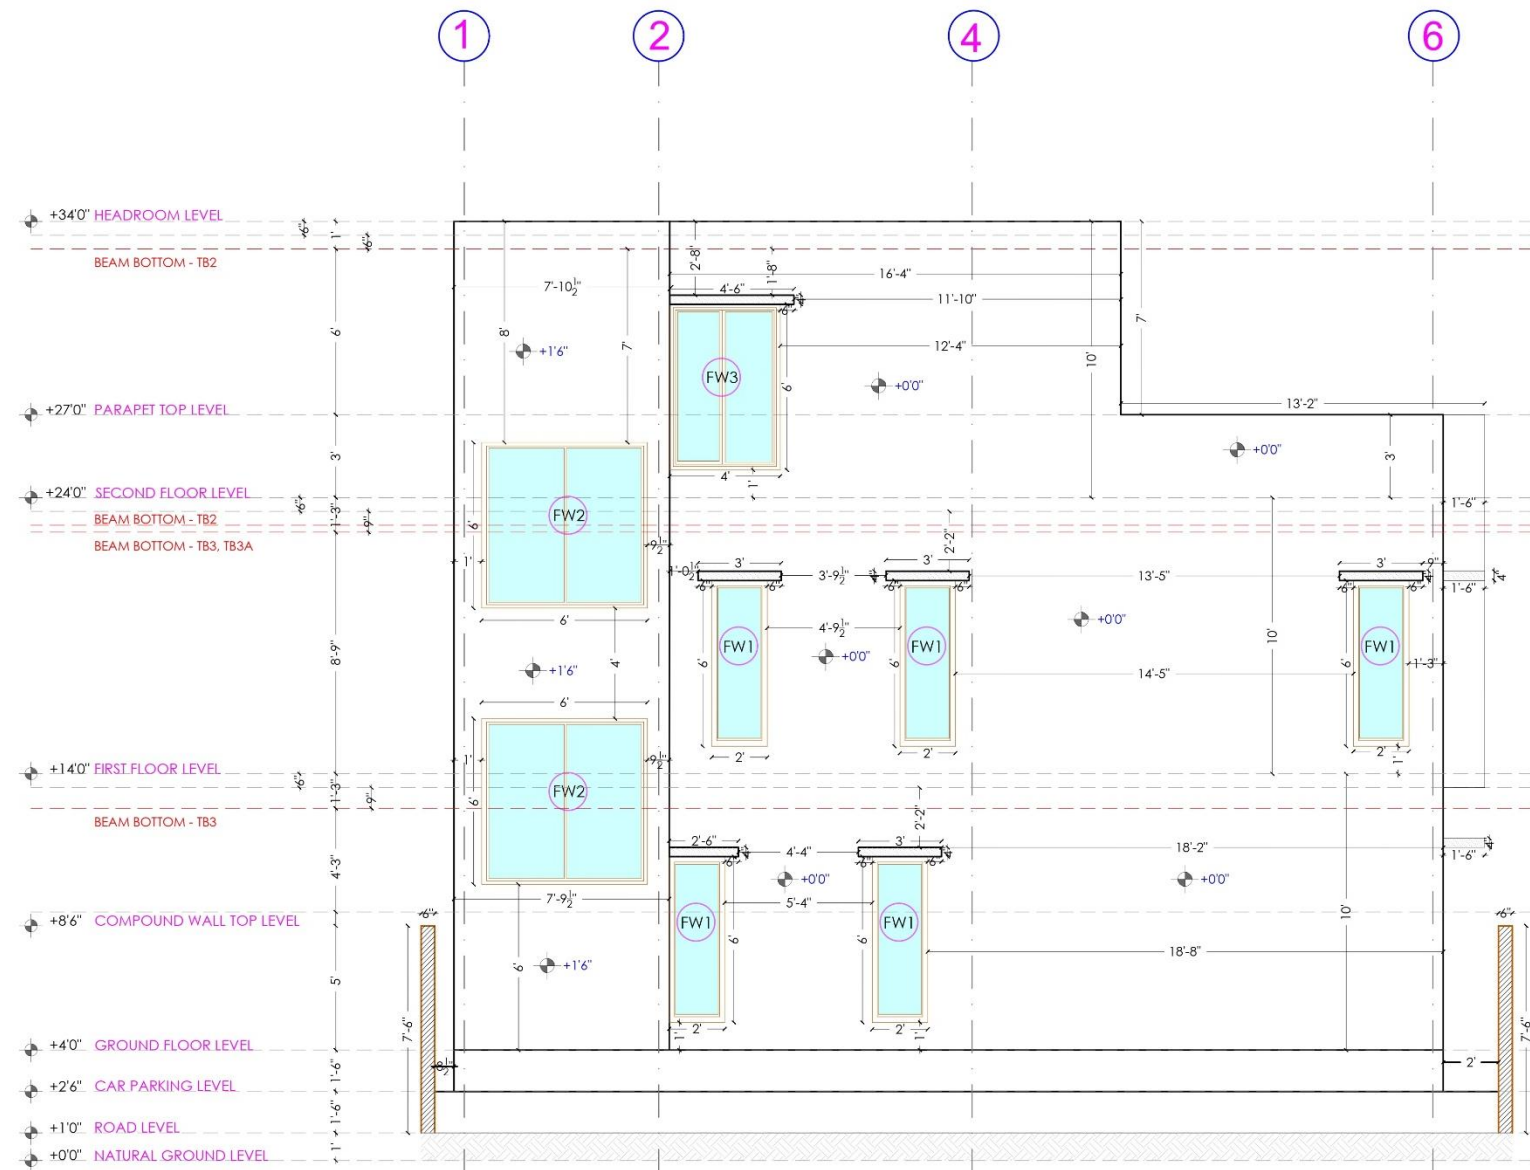

2 WEST ELEVATION

DRAWING TITLE:

Mr. Prem Kumar Residence 2D
Elevation

CLIENT:

Mr. Prem Kumar

ARCHITECTURAL DESIGNERS:


**DEEJOS ENGINEERS AND
CONTRACTORS PVT Ltd**

2nd floor, C.L.C. Road, Chrompet,
Chennai-600 044,
Mobile: +91-8110000384
Email: projects@deejos.com

SIGNATURE & SEAL:

ORIENTATION:



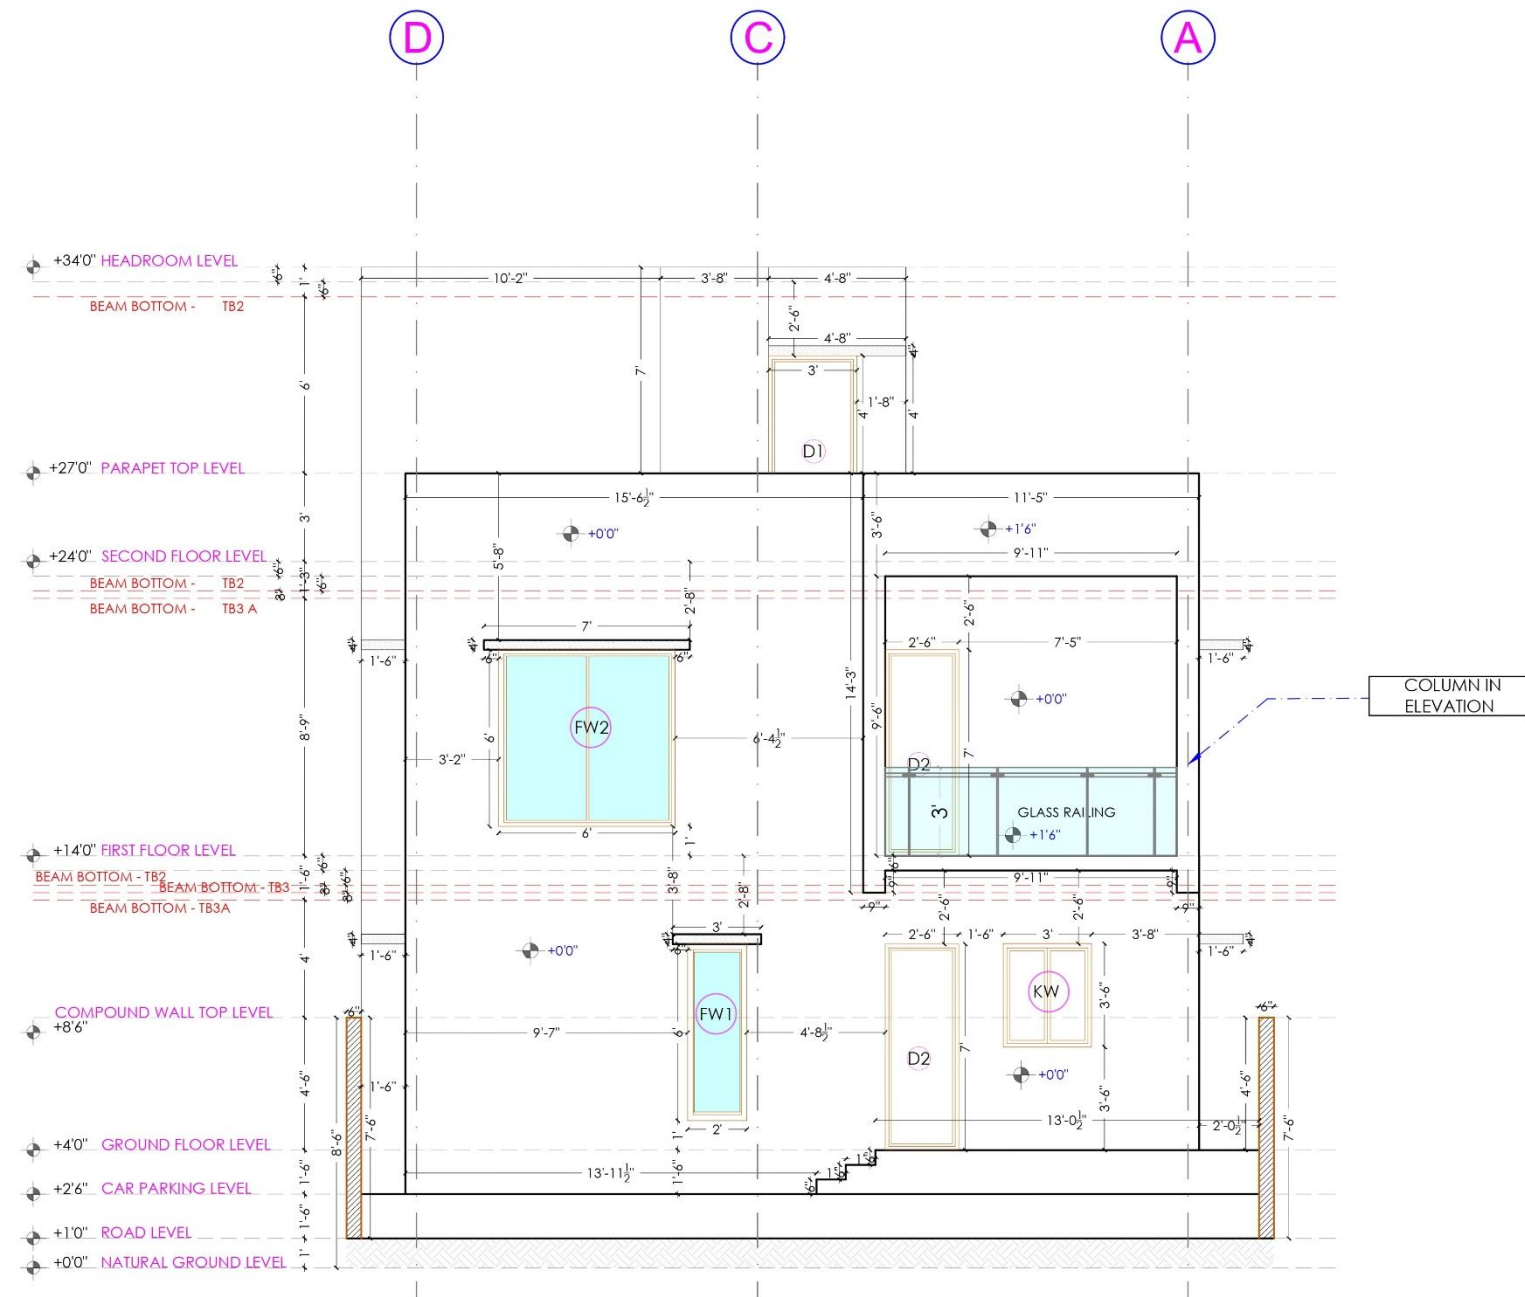

3 SOUTH ELEVATION

DRAWING TITLE:

Mr. Prem Kumar Residence 2D
Elevation

CLIENT:

Mr. Prem Kumar


ARCHITECTURAL DESIGNERS:


**DEEJOS ENGINEERS AND
CONTRACTORS PVT Ltd**

2nd floor, C.L.C. Road, Chrompet,
Chennai-600 044,
Mobile: +91-8110000384
Email: projects@deejos.com

SIGNATURE & SEAL:

ORIENTATION:

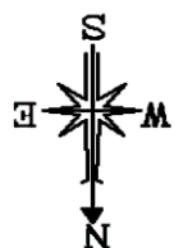

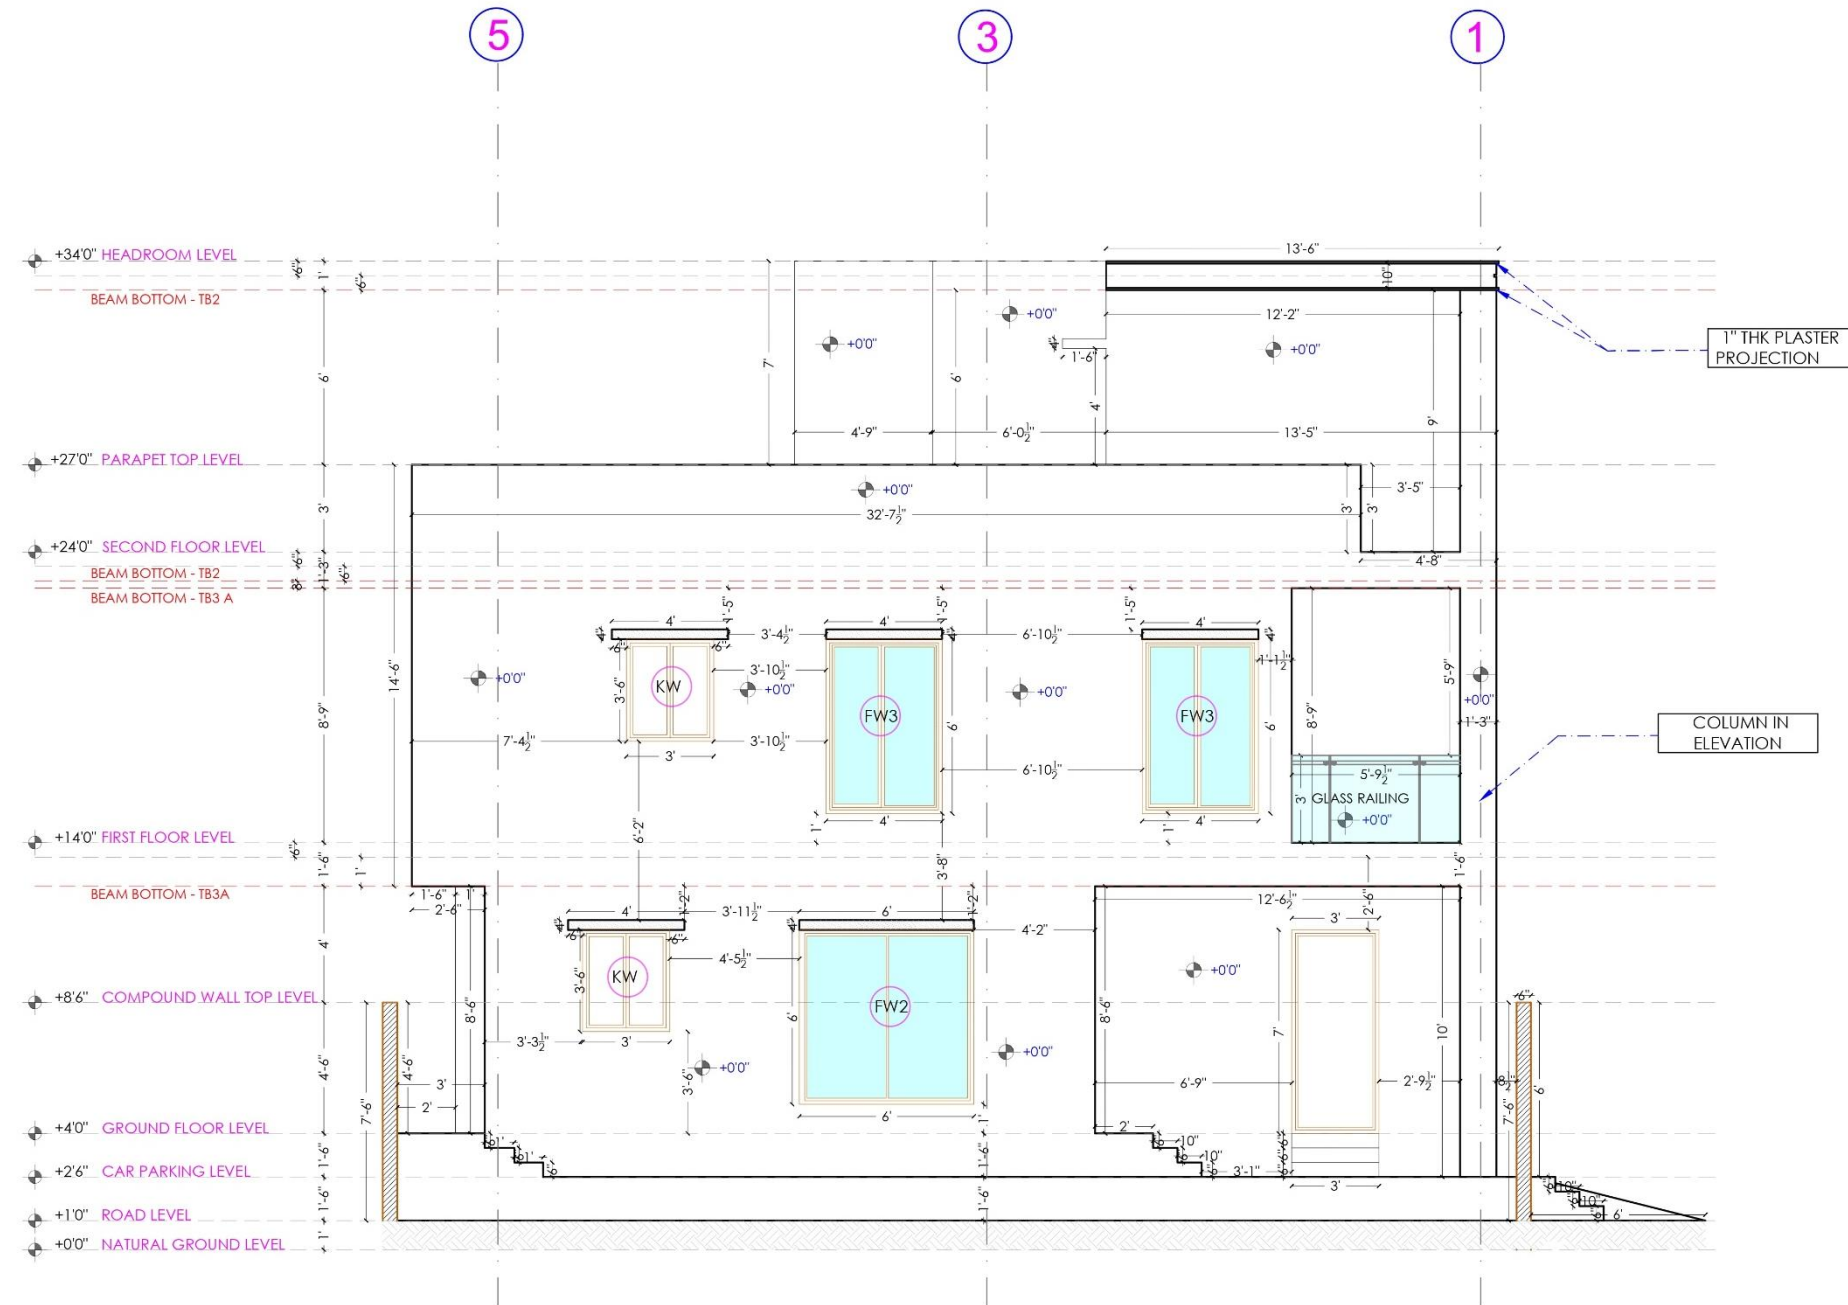

4 EAST ELEVATION

DRAWING TITLE:

Mr. Prem Kumar Residence 2D
Elevation

CLIENT:

Mr. Prem Kumar


ARCHITECTURAL DESIGNERS:


**DEEJOS ENGINEERS AND
CONTRACTORS PVT Ltd**

2nd floor, C.L.C. Road, Chrompet,
Chennai-600 044,
Mobile: +91-8110000384
Email: projects@deejos.com

SIGNATURE & SEAL:

ORIENTATION:

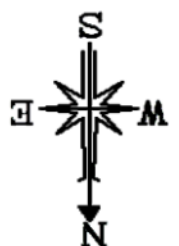

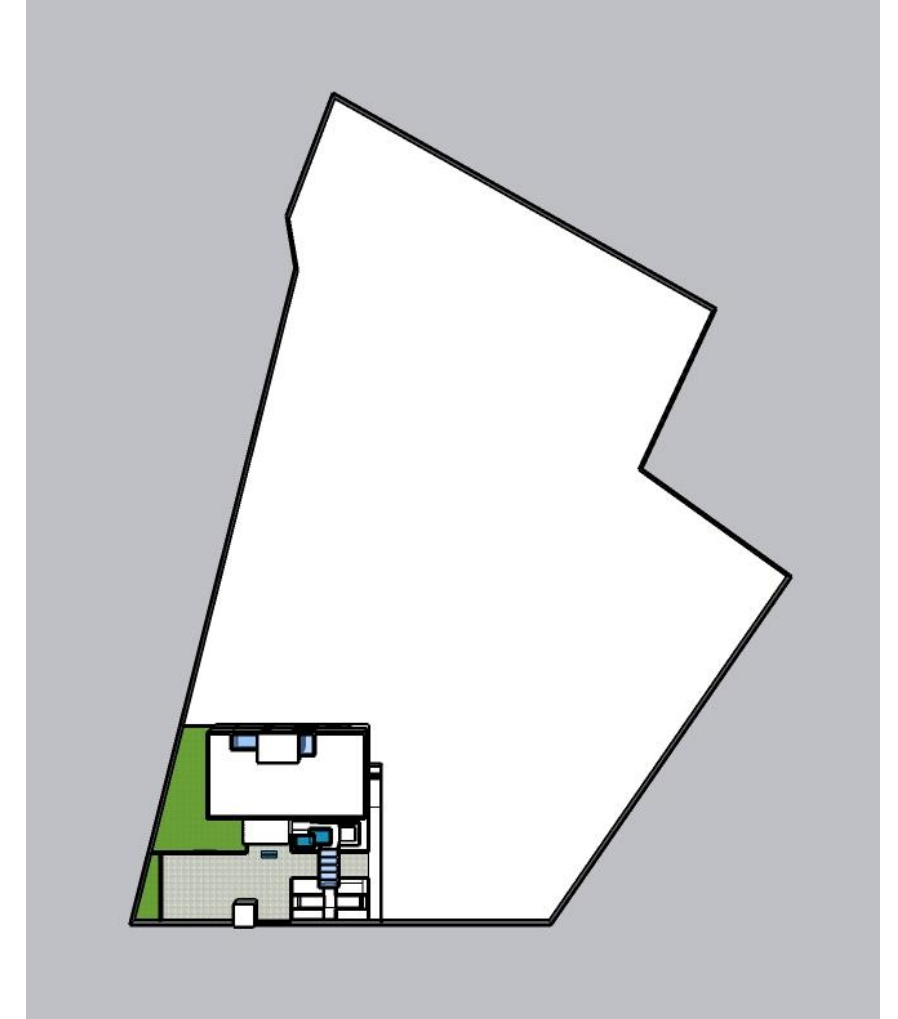

DRAWING TITLE:

Mr. Raina Farmhouse Model

CLIENT:

Mr. Raina

ARCHITECTURAL DESIGNERS:

**DEEJOS ENGINEERS AND
CONTRACTORS PVT Ltd**


2nd floor, C.L.C. Road, Chrompet,
Chennai-600 044,
Mobile: +91-8110000384
Email: projects@deejos.com

SIGNATURE & SEAL:

ORIENTATION:



GROUND FLOOR

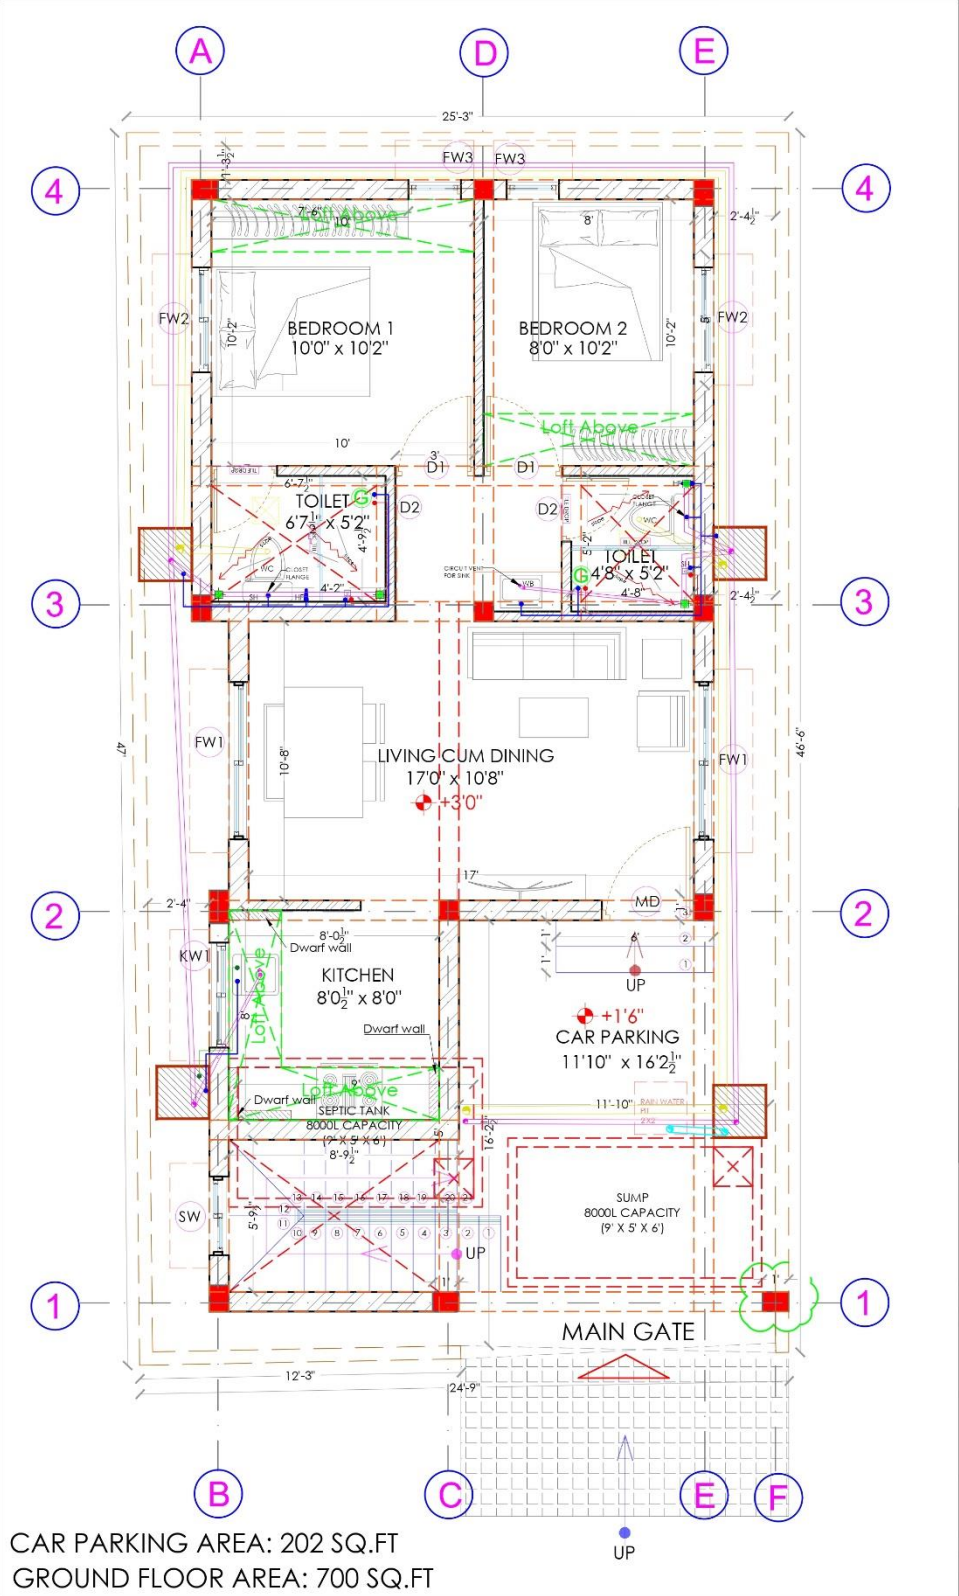

LEGEND		
	EWC	EUROPEAN WATER CLOSET (Wall mounted with flush valve)
	WB	WASH BASIN
	FT	FLOOR TRAP
	RWP	RAIN WATER PIPE 160Ø PVC (4 kg)
	SP	SOIL PIPE 110Ø PVC (6 kg)
	WP	WASTE PIPE 75Ø PVC (6 kg)
	WP	WASTE PIPE 40Ø PVC (10 kg)
	G	GEYSER
	BV	BALL VALVE
	CWS	COLD WATER SUPPLY Cpvc PIPE
	HWS	HOT WATER SUPPLY Cpvc PIPE
	M	MOTOR
	HF	HEALTH FAUCET
	HS	HAND SHOWER

DRAWING TITLE:

Mr. Rajaguru Residence
Plumbing Drawing

CLIENT:

Mr. Rajaguru


ARCHITECTURAL DESIGNERS:

**DEEJOS ENGINEERS AND
CONTRACTORS PVT Ltd**


2nd floor, C.L.C. Road, Chrompet,
Chennai-600 044,
Mobile: +91-8110000384
Email: projects@deejos.com

SIGNATURE & SEAL:

ORIENTATION:

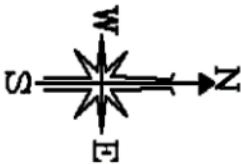

FIRST FLOOR

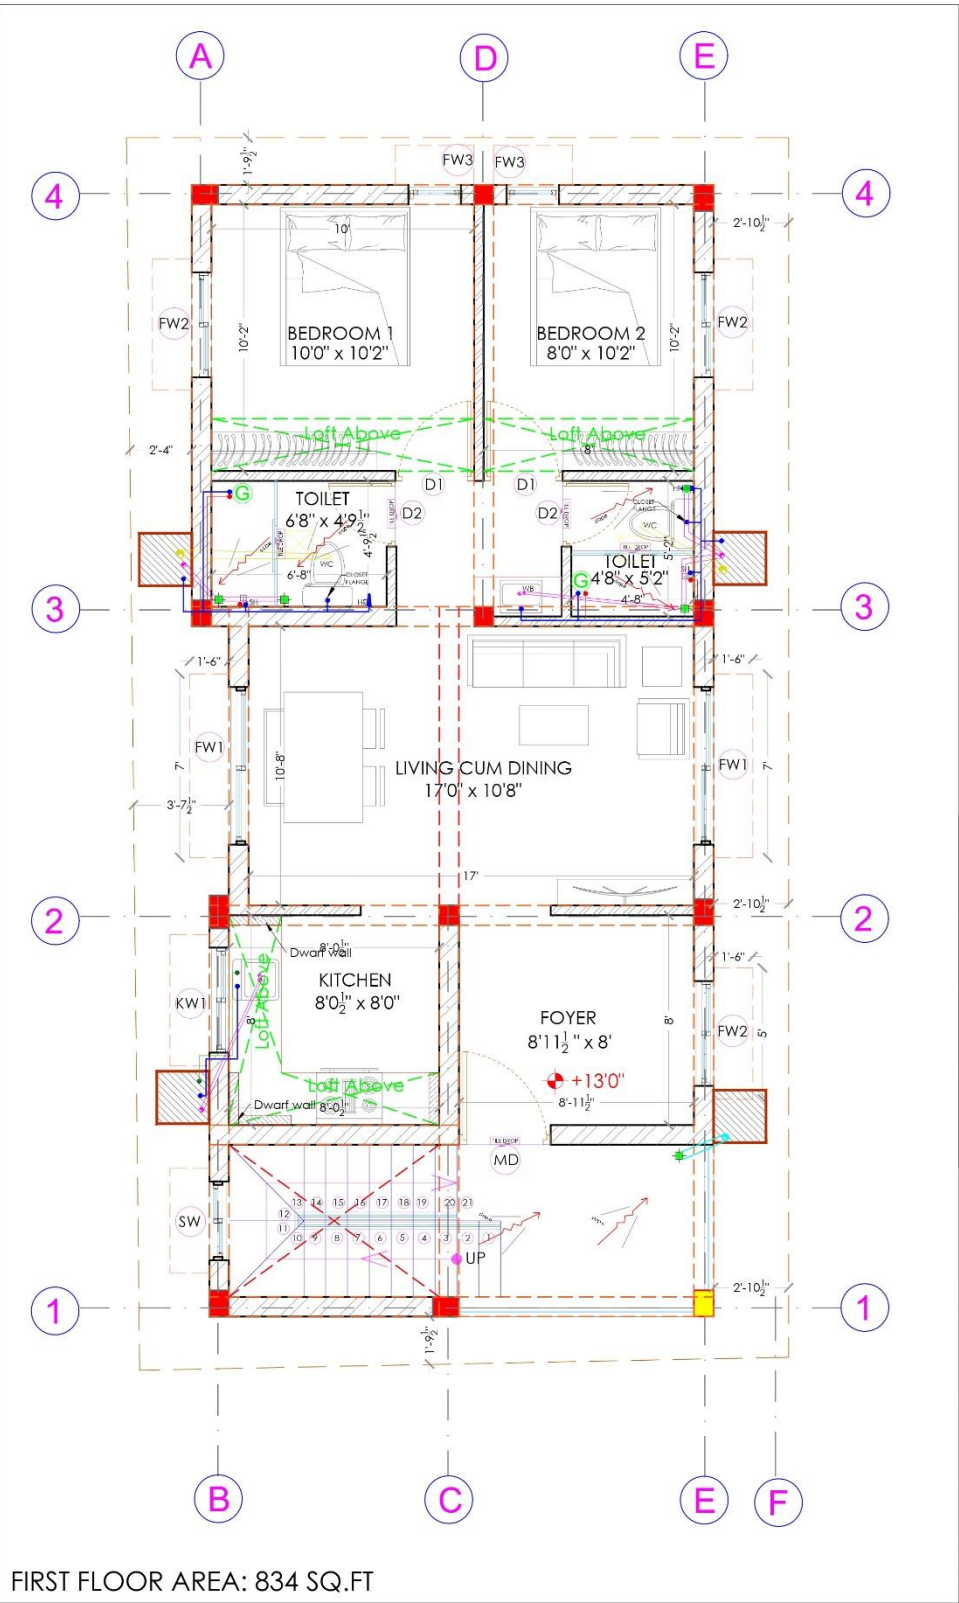

FIRST FLOOR AREA: 834 SQ.FT

LEGEND		
	EWC	EUROPEAN WATER CLOSET (Wall mounted with flush valve)
	WB	WASH BASIN
	FT	FLOOR TRAP
	RWP	RAIN WATER PIPE 160Ø PVC (4 kg)
	SP	SOIL PIPE 110Ø PVC (6 kg)
	WP	WASTE PIPE 75Ø PVC (6 kg)
	WP	WASTE PIPE 40Ø PVC (10 kg)
	G	GEYSER
	BV	BALL VALVE
	CWS	COLD WATER SUPPLY Cpvc PIPE
	HWS	HOT WATER SUPPLY Cpvc PIPE
	M	MOTOR
	HF	HEALTH FAUCET
	HS	HAND SHOWER

DRAWING TITLE:

Mr. Rajaguru Residence
Plumbing Drawing

CLIENT:

Mr. Rajaguru


ARCHITECTURAL DESIGNERS:

**DEEJOS ENGINEERS AND
CONTRACTORS PVT Ltd**


2nd floor, C.L.C. Road, Chrompet,
Chennai-600 044,
Mobile: +91-8110000384
Email: projects@deejos.com

SIGNATURE & SEAL:

ORIENTATION:

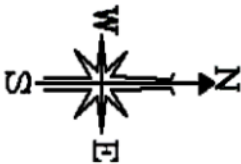

TERRACE FLOOR

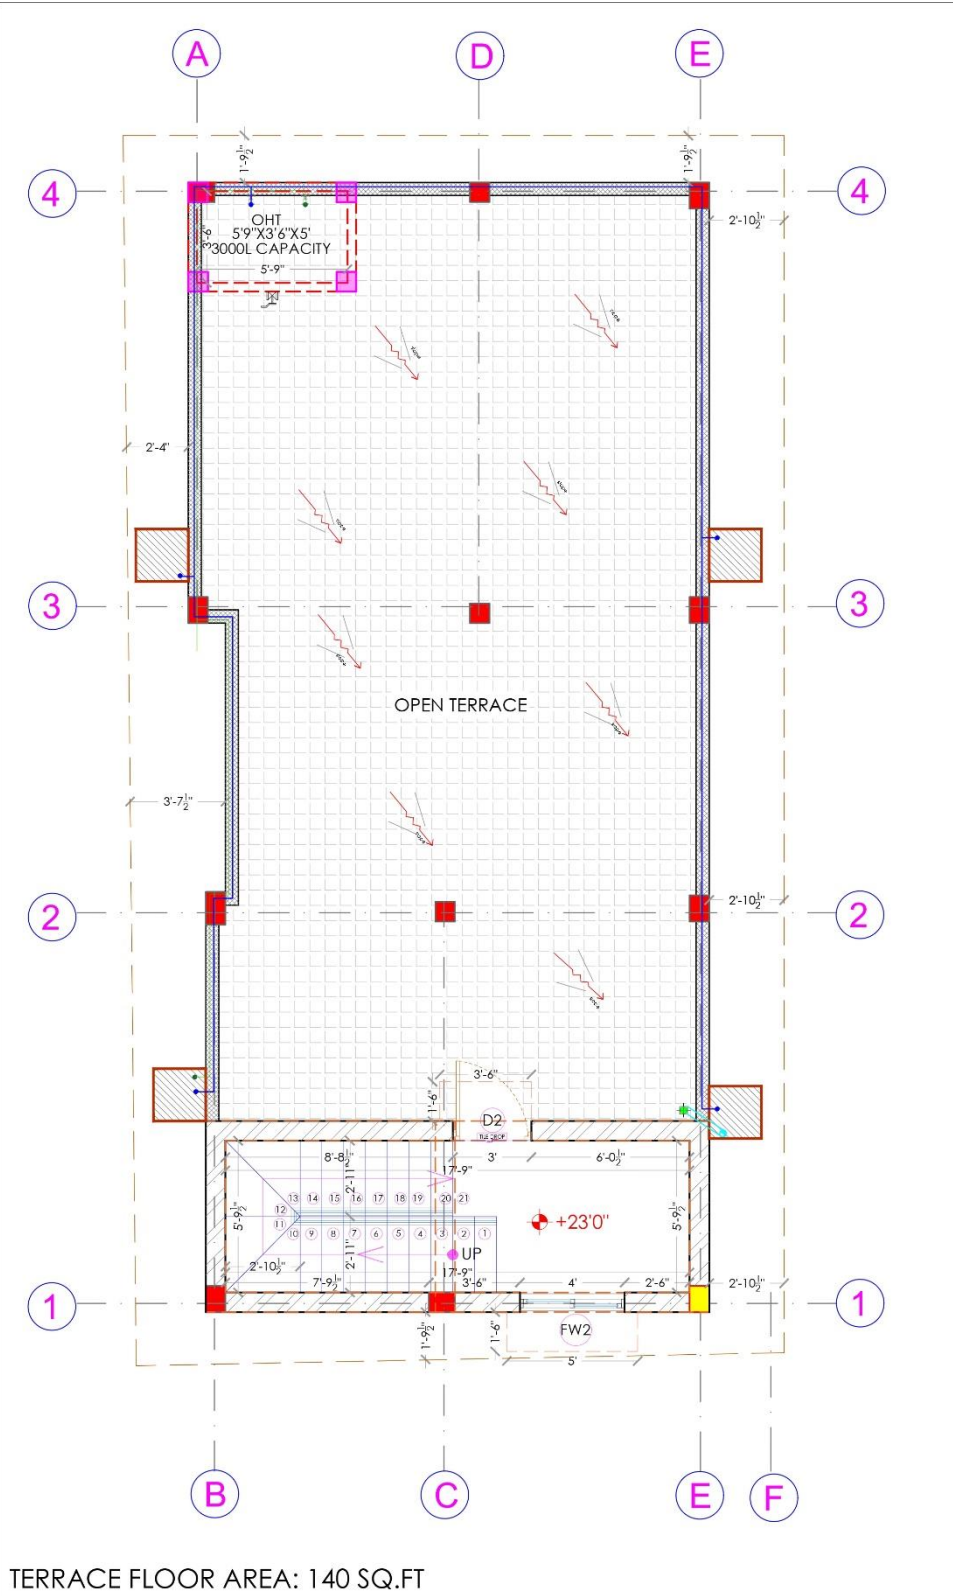

LEGEND		
	EWC	EUROPEAN WATER CLOSET (Wall mounted with flush valve)
	WB	WASH BASIN
	FT	FLOOR TRAP
	RWP	RAIN WATER PIPE 160Ø PVC (4 kg)
	SP	SOIL PIPE 110Ø PVC (6 kg)
	WP	WASTE PIPE 75Ø PVC (6 kg)
	WP	WASTE PIPE 40Ø PVC (10 kg)
	G	GEYSER
	BV	BALL VALVE
	CWS	COLD WATER SUPPLY Cpvc PIPE
	HWS	HOT WATER SUPPLY Cpvc PIPE
	M	MOTOR
	HF	HEALTH FAUCET
	HS	HAND SHOWER

DRAWING TITLE:

Mr. Rajaguru Residence
Plumbing Drawing

CLIENT:

Mr. Rajaguru


ARCHITECTURAL DESIGNERS:

**DEEJOS ENGINEERS AND
CONTRACTORS PVT Ltd**

2nd floor, C.L.C. Road, Chrompet,
Chennai-600 044,
Mobile: +91-8110000384
Email: projects@deejos.com

SIGNATURE & SEAL:

ORIENTATION:

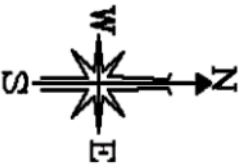



OPTION 1

<u>DRAWING TITLE:</u> Mr. Ramprasad Commercial Building 3D Elevation	<u>ARCHITECTURAL DESIGNERS:</u> DEEJOS ENGINEERS AND CONTRACTORS PVT Ltd 2nd floor, C.L.C. Road, Chrompet, Chennai-600 044, Mobile: +91-8110000384 Email: projects@deejos.com	<u>SIGNATURE & SEAL:</u>	<u>ORIENTATION:</u> 
<u>CLIENT:</u> Mr. Ramprasad			



OPTION 2

DRAWING TITLE:

Mr. Ramprasad Commercial
Building 3D Elevation

CLIENT:

Mr. Ramprasad

ARCHITECTURAL DESIGNERS:


**DEEJOS ENGINEERS AND
CONTRACTORS PVT Ltd**

2nd floor, C.L.C. Road, Chrompet,
Chennai-600 044,
Mobile: +91-8110000384
Email: projects@deejos.com

SIGNATURE & SEAL:


ORIENTATION:



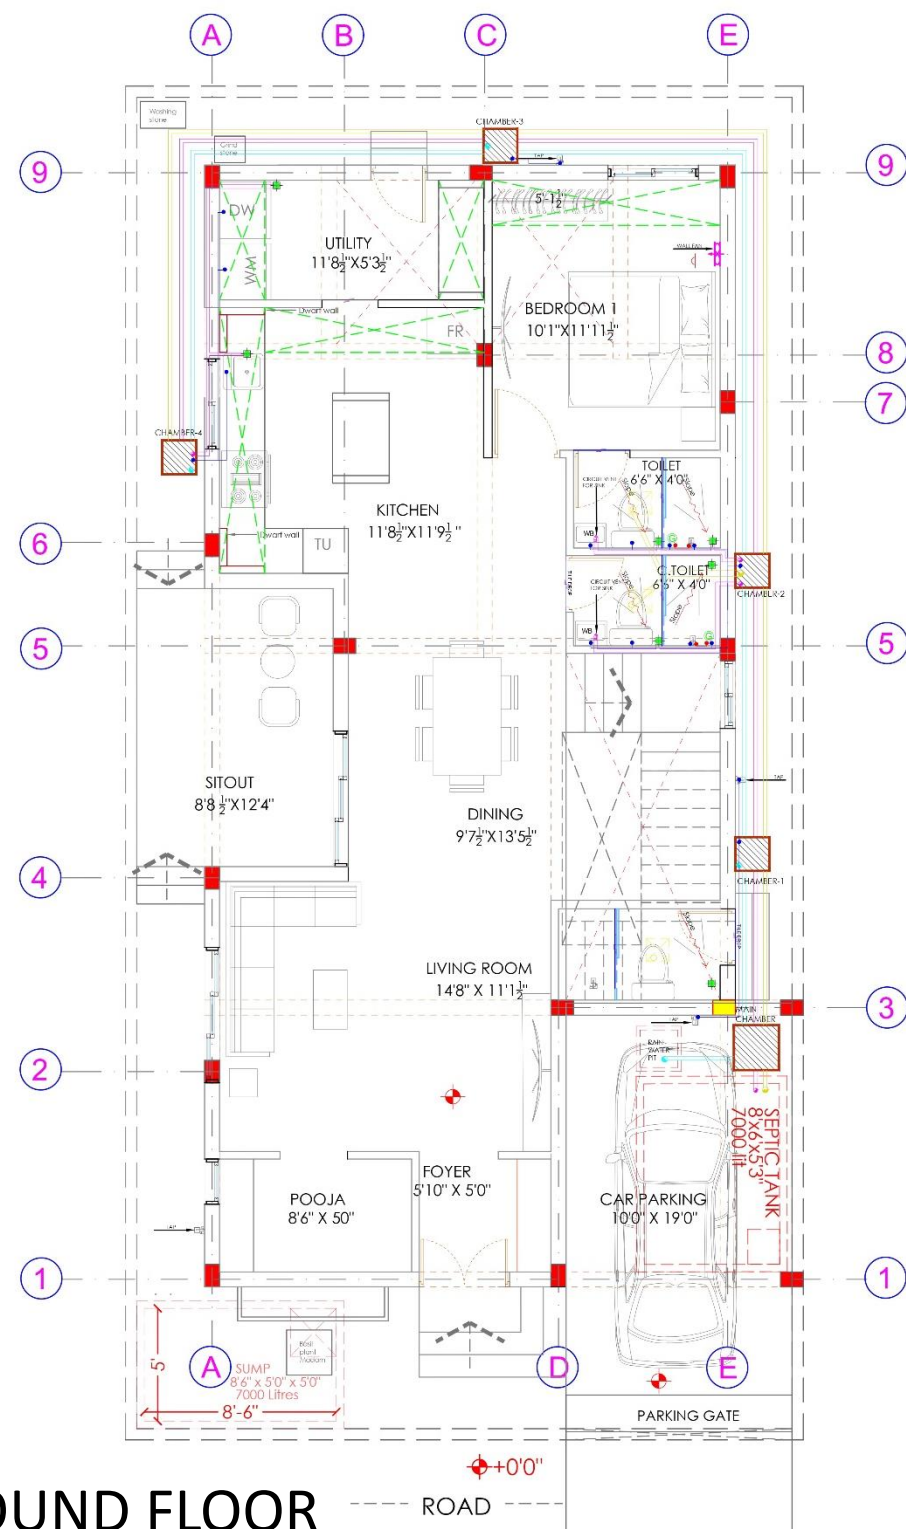

GROUND FLOOR

LEGEND		
	EWC	EUROPEAN WATER CLOSET (Wall mounted with flush valve)
	WB	WASH BASIN
	FT	FLOOR TRAP
	RWP	RAIN WATER PIPE 160Ø PVC (4 kg)
	SP	SOIL PIPE 110Ø PVC (6 kg)
	WP	WASTE PIPE 75Ø PVC (6 kg)
	WP	WASTE PIPE 40Ø PVC (10 kg)
	G	GEYSER
	BV	BALL VALVE
	CWS	COLD WATER SUPPLY Cpvc PIPE
	HWS	HOT WATER SUPPLY Cpvc PIPE
	M	MOTOR
	HF	HEALTH FAUCET
	HS	HAND SHOWER

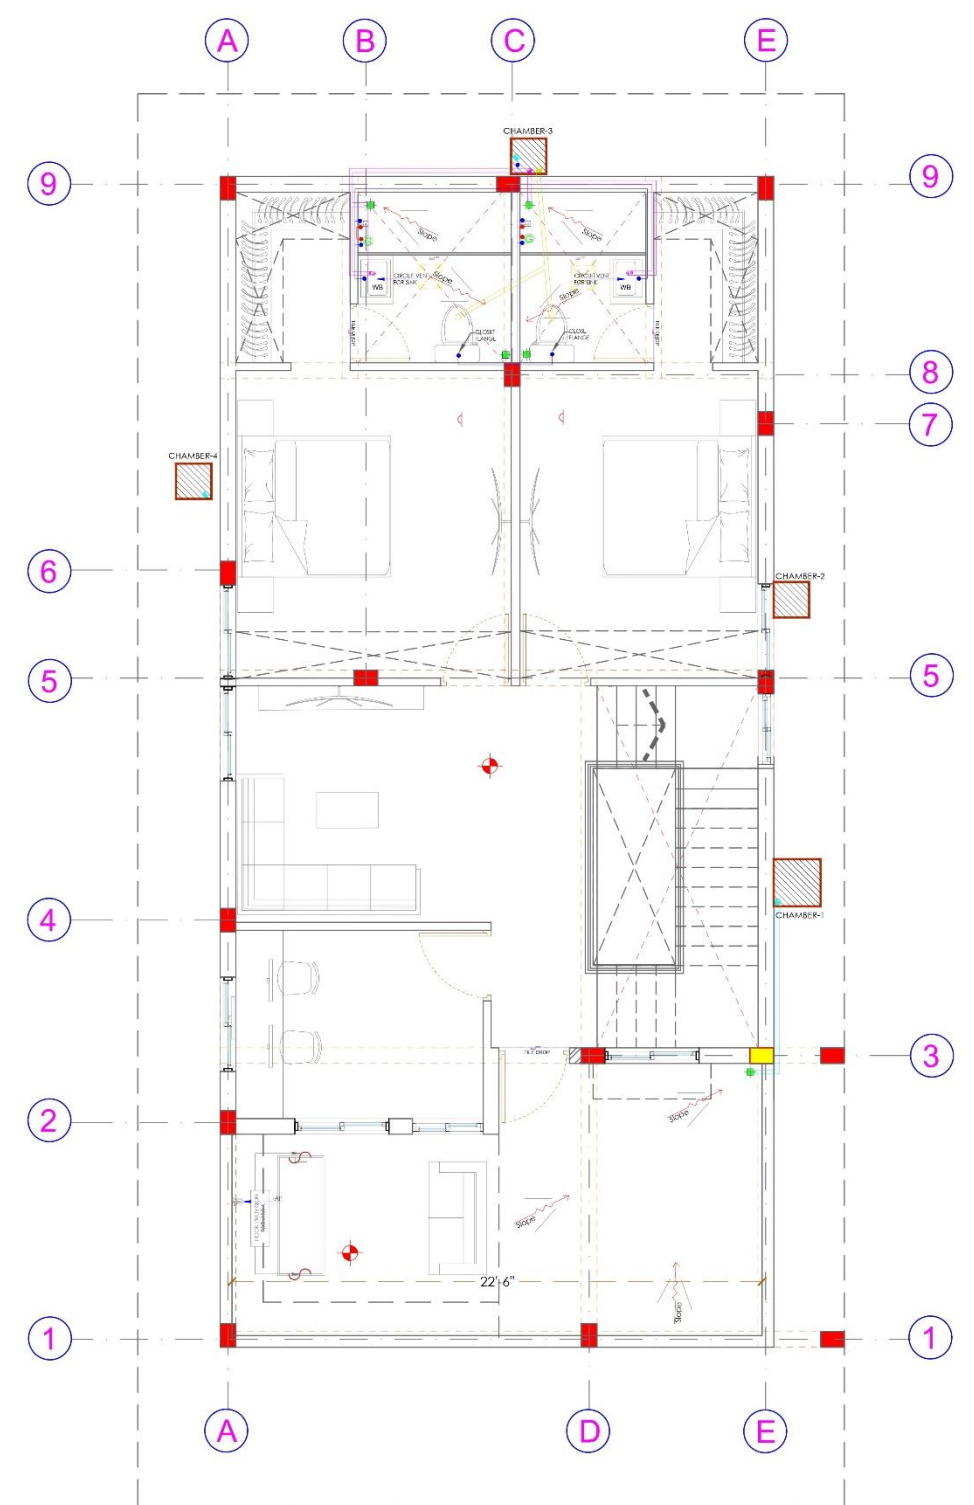

FIRST FLOOR

DRAWING TITLE:

Mr. Sasikumar Residence
Plumbing Drawing

CLIENT:

Mr. Sasikumar


ARCHITECTURAL DESIGNERS:

**DEEJOS ENGINEERS AND
CONTRACTORS PVT Ltd**


2nd floor, C.L.C. Road, Chrompet,
Chennai-600 044,
Mobile: +91-8110000384
Email: projects@deejos.com

SIGNATURE & SEAL:

ORIENTATION:

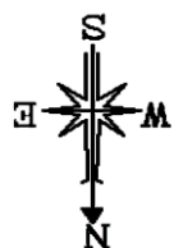

TERRACE FLOOR

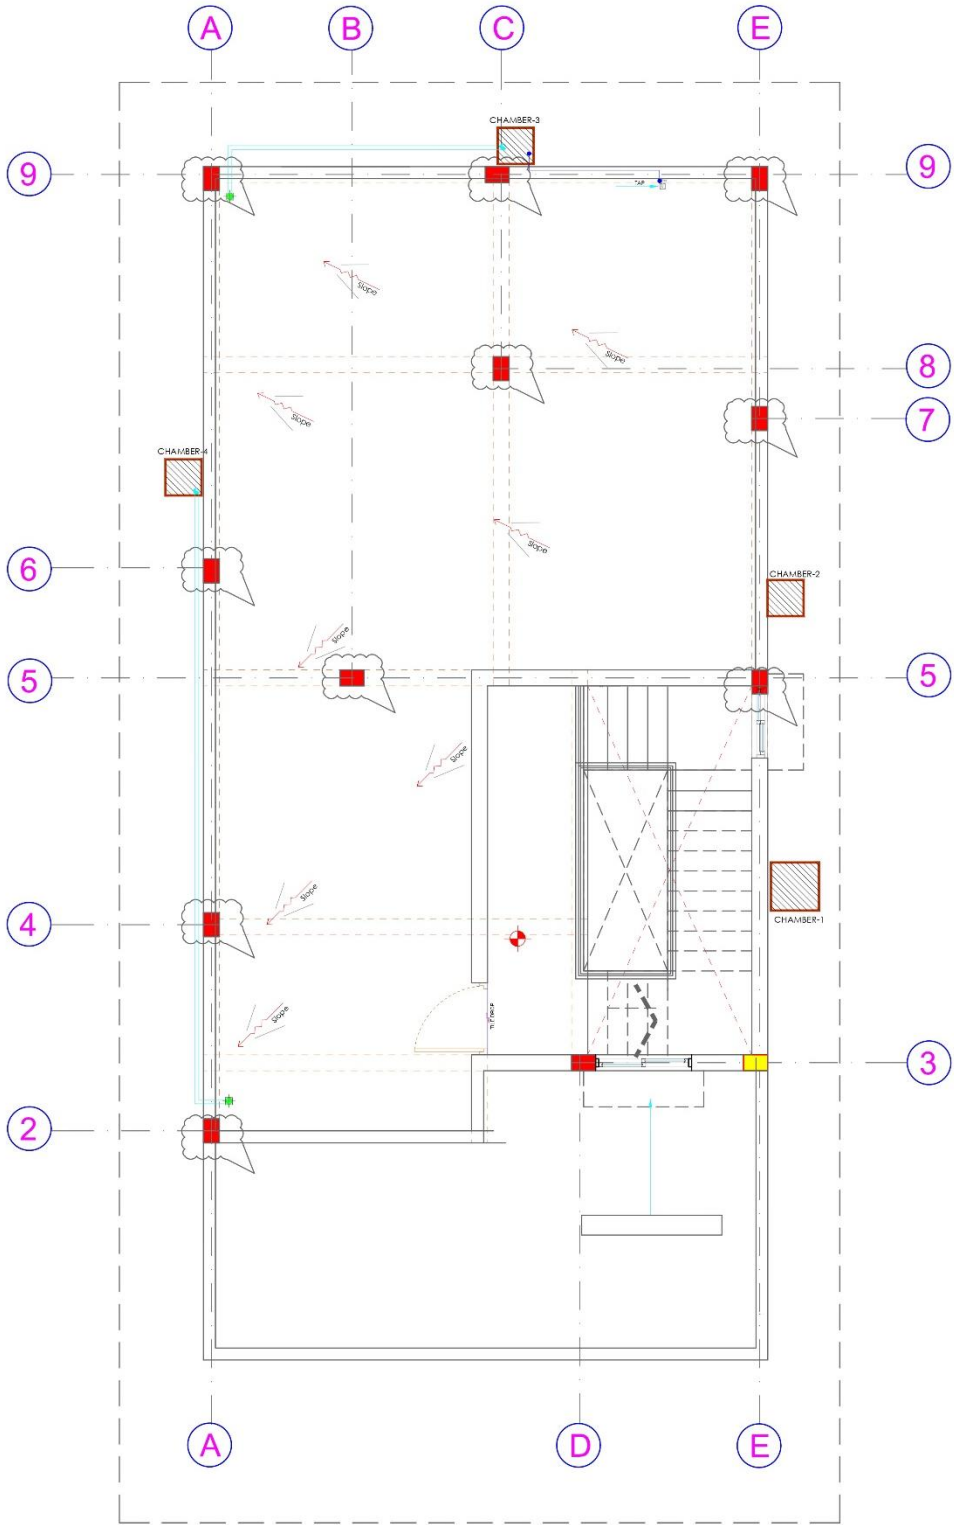

LEGEND		
	EWC	EUROPEAN WATER CLOSET (Wall mounted with flush valve)
	WB	WASH BASIN
	FT	FLOOR TRAP
	RWP	RAIN WATER PIPE 160Ø PVC (4 kg)
	SP	SOIL PIPE 110Ø PVC (6 kg)
	WP	WASTE PIPE 75Ø PVC (6 kg)
	WP	WASTE PIPE 40Ø PVC (10 kg)
	G	GEYSER
	BV	BALL VALVE
	CWS	COLD WATER SUPPLY Cpvc PIPE
	HWS	HOT WATER SUPPLY Cpvc PIPE
	M	MOTOR
	HF	HEALTH FAUCET
	HS	HAND SHOWER

DRAWING TITLE:

Mr. Sasikumar Residence
Plumbing Drawing

CLIENT:

Mr. Sasikumar

ARCHITECTURAL DESIGNERS:

**DEEJOS ENGINEERS AND
CONTRACTORS PVT Ltd**

2nd floor, C.L.C. Road, Chrompet,
Chennai-600 044,
Mobile: +91-8110000384
Email: projects@deejos.com

SIGNATURE & SEAL:

ORIENTATION:





DRAWING TITLE:

Mr. Sathish Kumar Residence
3D Elevation

CLIENT:

Mr. Sathish kumar

ARCHITECTURAL DESIGNERS:

**DEEJOS ENGINEERS AND
CONTRACTORS PVT Ltd**

2nd floor, C.L.C. Road, Chrompet,
Chennai-600 044,
Mobile: +91-8110000384
Email: projects@deejos.com

SIGNATURE & SEAL:

ORIENTATION:





DEEJOS ENGINEERS AND CONTRACTORS :: MR. SATHISH KUMAR - HALF LAYOUT - GF

DRAWING TITLE:

Mr. Sathish Kumar Residence
Half Layout

CLIENT:

Mr. Sathish kumar

ARCHITECTURAL DESIGNERS:

**DEEJOS ENGINEERS AND
CONTRACTORS PVT Ltd**

2nd floor, C.L.C. Road, Chrompet,
Chennai-600 044,
Mobile: +91-8110000384
Email: projects@deejos.com

SIGNATURE & SEAL:

ORIENTATION:





DEEJOS ENGINEERS AND CONTRACTORS :: MR. SATHISH KUMAR - HALF LAYOUT - FF

DRAWING TITLE:

Mr. Sathish Kumar Residence
Half Layout

CLIENT:

Mr. Sathish kumar

ARCHITECTURAL DESIGNERS:

**DEEJOS ENGINEERS AND
CONTRACTORS PVT Ltd**

2nd floor, C.L.C. Road, Chrompet,
Chennai-600 044,
Mobile: +91-8110000384
Email: projects@deejos.com

SIGNATURE & SEAL:

ORIENTATION:





DEEJOS ENGINEERS AND CONTRACTORS :: MR. SATHISH KUMAR - HALF LAYOUT - SF

DRAWING TITLE:

Mr. Sathish Kumar Residence
Half Layout

CLIENT:

Mr. Sathish kumar

ARCHITECTURAL DESIGNERS:

**DEEJOS ENGINEERS AND
CONTRACTORS PVT Ltd**

2nd floor, C.L.C. Road, Chrompet,
Chennai-600 044,
Mobile: +91-8110000384
Email: projects@deejos.com

SIGNATURE & SEAL:

ORIENTATION:





DEEJOS ENGINEERS AND CONTRACTORS :: MR. SATHISH KUMAR - HALF LAYOUT - TF

DRAWING TITLE:

Mr. Sathish Kumar Residence
Half Layout

CLIENT:

Mr. Sathish kumar

ARCHITECTURAL DESIGNERS:

**DEEJOS ENGINEERS AND
CONTRACTORS PVT Ltd**

2nd floor, C.L.C. Road, Chrompet,
Chennai-600 044,
Mobile: +91-8110000384
Email: projects@deejos.com

SIGNATURE & SEAL:

ORIENTATION:





GROUND FLOOR

DRAWING TITLE:

Mrs. Sivagami Sundari
Residence Half Layout

CLIENT:

Mrs. Sivagami Sundari

ARCHITECTURAL DESIGNERS:

**DEEJOS ENGINEERS AND
CONTRACTORS PVT Ltd**

2nd floor, C.L.C. Road, Chrompet,
Chennai-600 044,
Mobile: +91-8110000384
Email: projects@deejos.com


SIGNATURE & SEAL:

ORIENTATION:





RIGHT SIDE

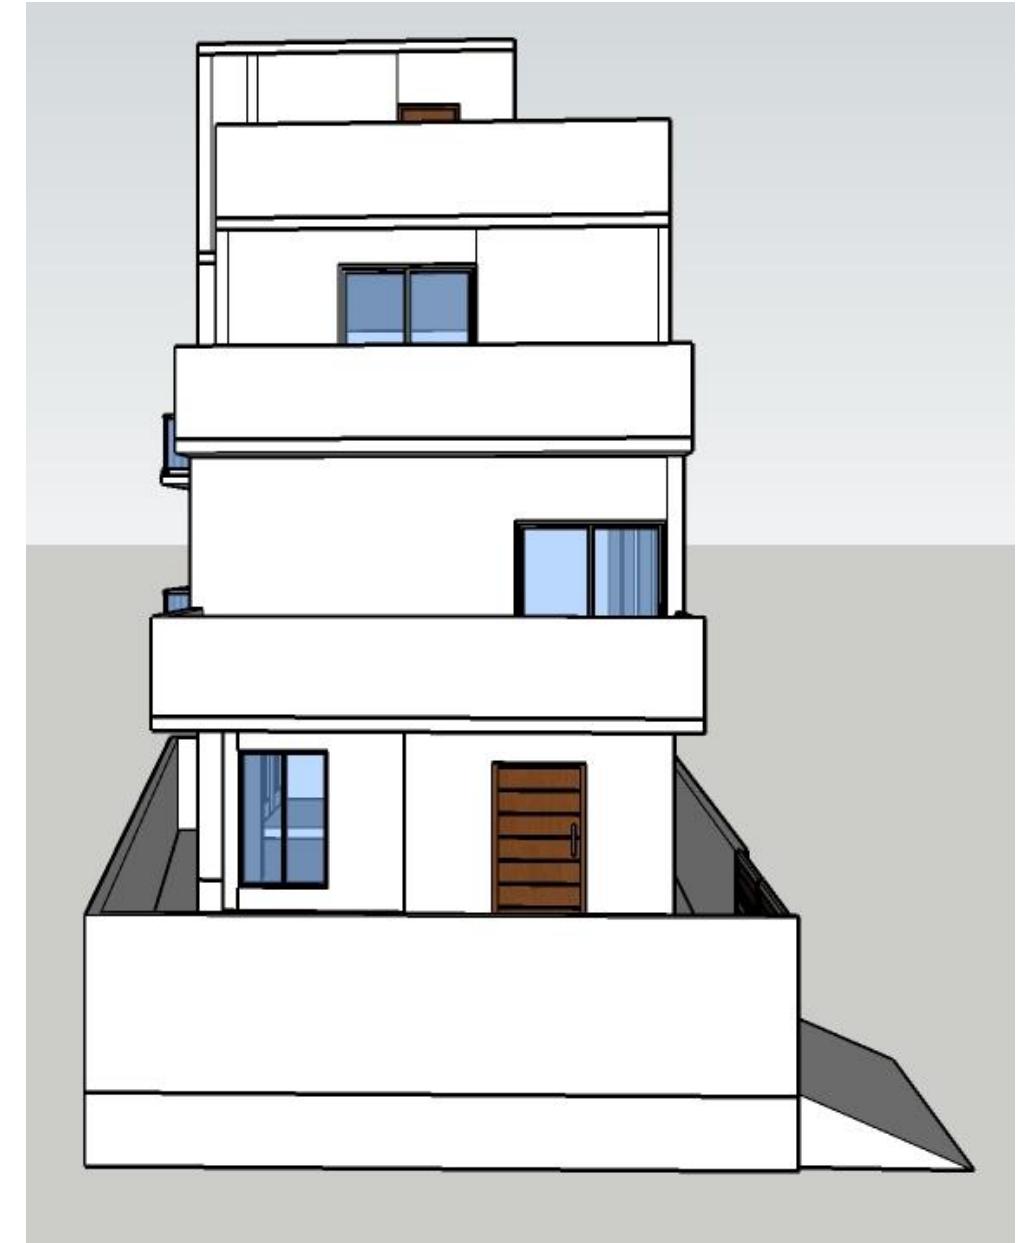

FRONT SIDE

DRAWING TITLE:

Mrs. Sivagami Sundari
Residence Base Model

CLIENT:

Mrs. Sivagami Sundari

ARCHITECTURAL DESIGNERS:

**DEEJOS ENGINEERS AND
CONTRACTORS PVT Ltd**

2nd floor, C.L.C. Road, Chrompet,
Chennai-600 044,
Mobile: +91-8110000384
Email: projects@deejos.com

SIGNATURE & SEAL:

ORIENTATION:





DRAWING TITLE:

Mrs. Sivagami Sundari
Residence 3D Elevation

CLIENT:

Mrs. Sivagami Sundari

ARCHITECTURAL DESIGNERS:

**DEEJOS ENGINEERS AND
CONTRACTORS PVT Ltd**

2nd floor, C.L.C. Road, Chrompet,
Chennai-600 044,
Mobile: +91-8110000384
Email: projects@deejos.com


SIGNATURE & SEAL:

ORIENTATION:





OPTION 1

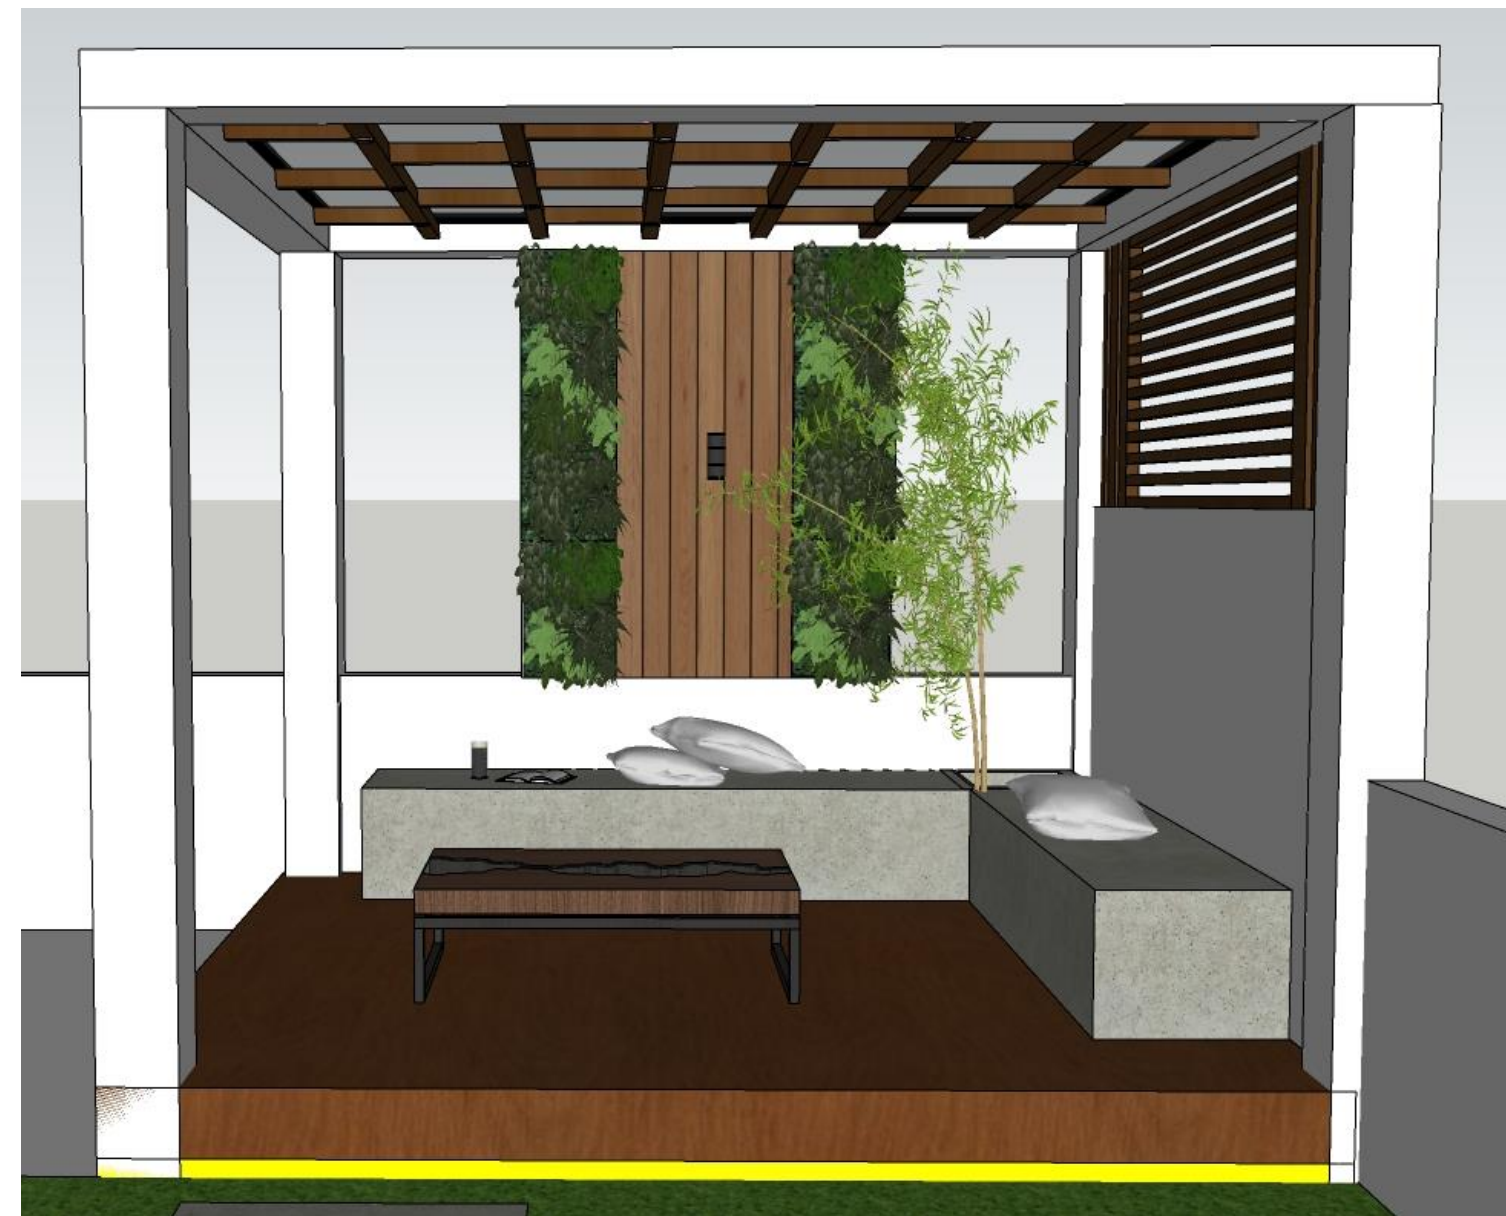

OPTION 2

DRAWING TITLE:

Mr. Vasanth Residence Pergola
Design

CLIENT:

Mr. Vasanth

ARCHITECTURAL DESIGNERS:


**DEEJOS ENGINEERS AND
CONTRACTORS PVT Ltd**

2nd floor, C.L.C. Road, Chrompet,
Chennai-600 044,
Mobile: +91-8110000384
Email: projects@deejos.com

SIGNATURE & SEAL:

ORIENTATION:



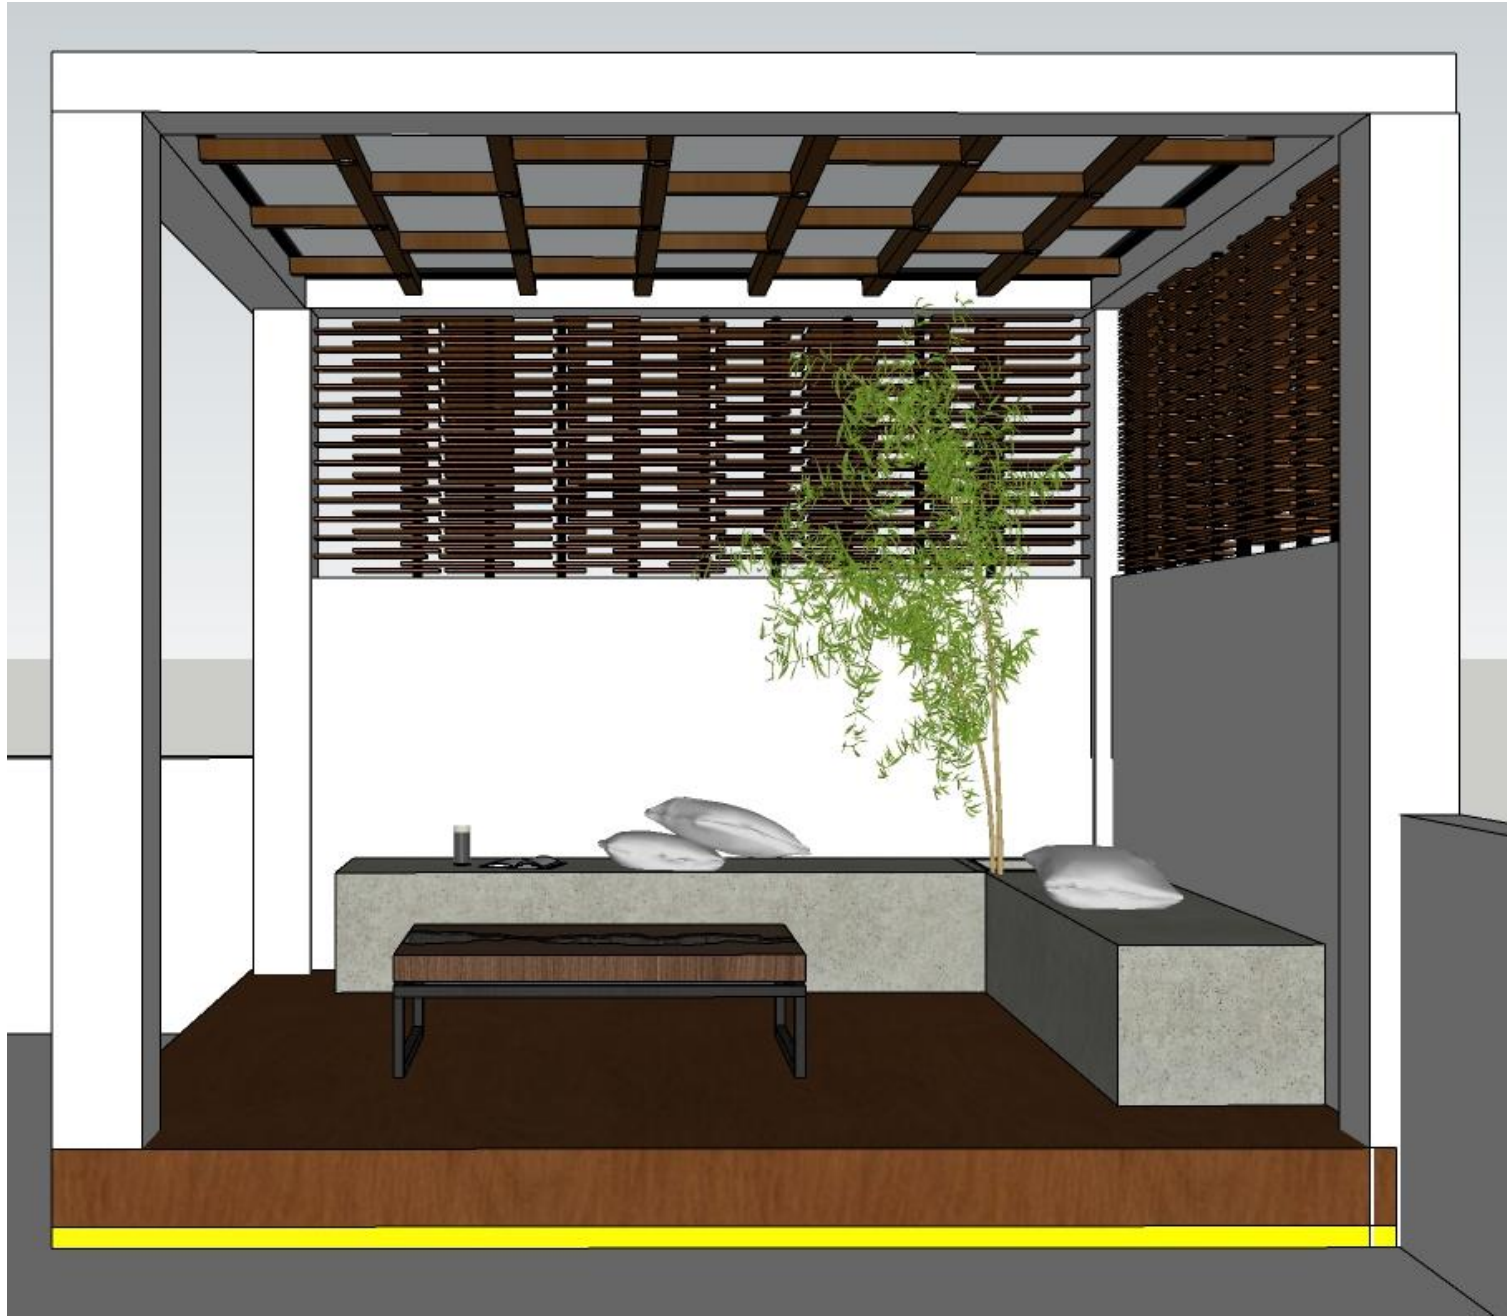

OPTION 3



OPTION 4

DRAWING TITLE:

Mr. Vasanth Residence Pergola
Design

CLIENT:

Mr. Vasanth

ARCHITECTURAL DESIGNERS:

**DEEJOS ENGINEERS AND
CONTRACTORS PVT Ltd**

2nd floor, C.L.C. Road, Chrompet,
Chennai-600 044,
Mobile: +91-8110000384
Email: projects@deejos.com

SIGNATURE & SEAL:

ORIENTATION:





WEST ELEVATION

DRAWING TITLE:

Mr. Vinod Residence 2D
Elevation

CLIENT:

Mr. Vinod

ARCHITECTURAL DESIGNERS:


**DEEJOS ENGINEERS AND
CONTRACTORS PVT Ltd**

2nd floor, C.L.C. Road, Chrompet,
Chennai-600 044,
Mobile: +91-8110000384
Email: projects@deejos.com

SIGNATURE & SEAL:

ORIENTATION:



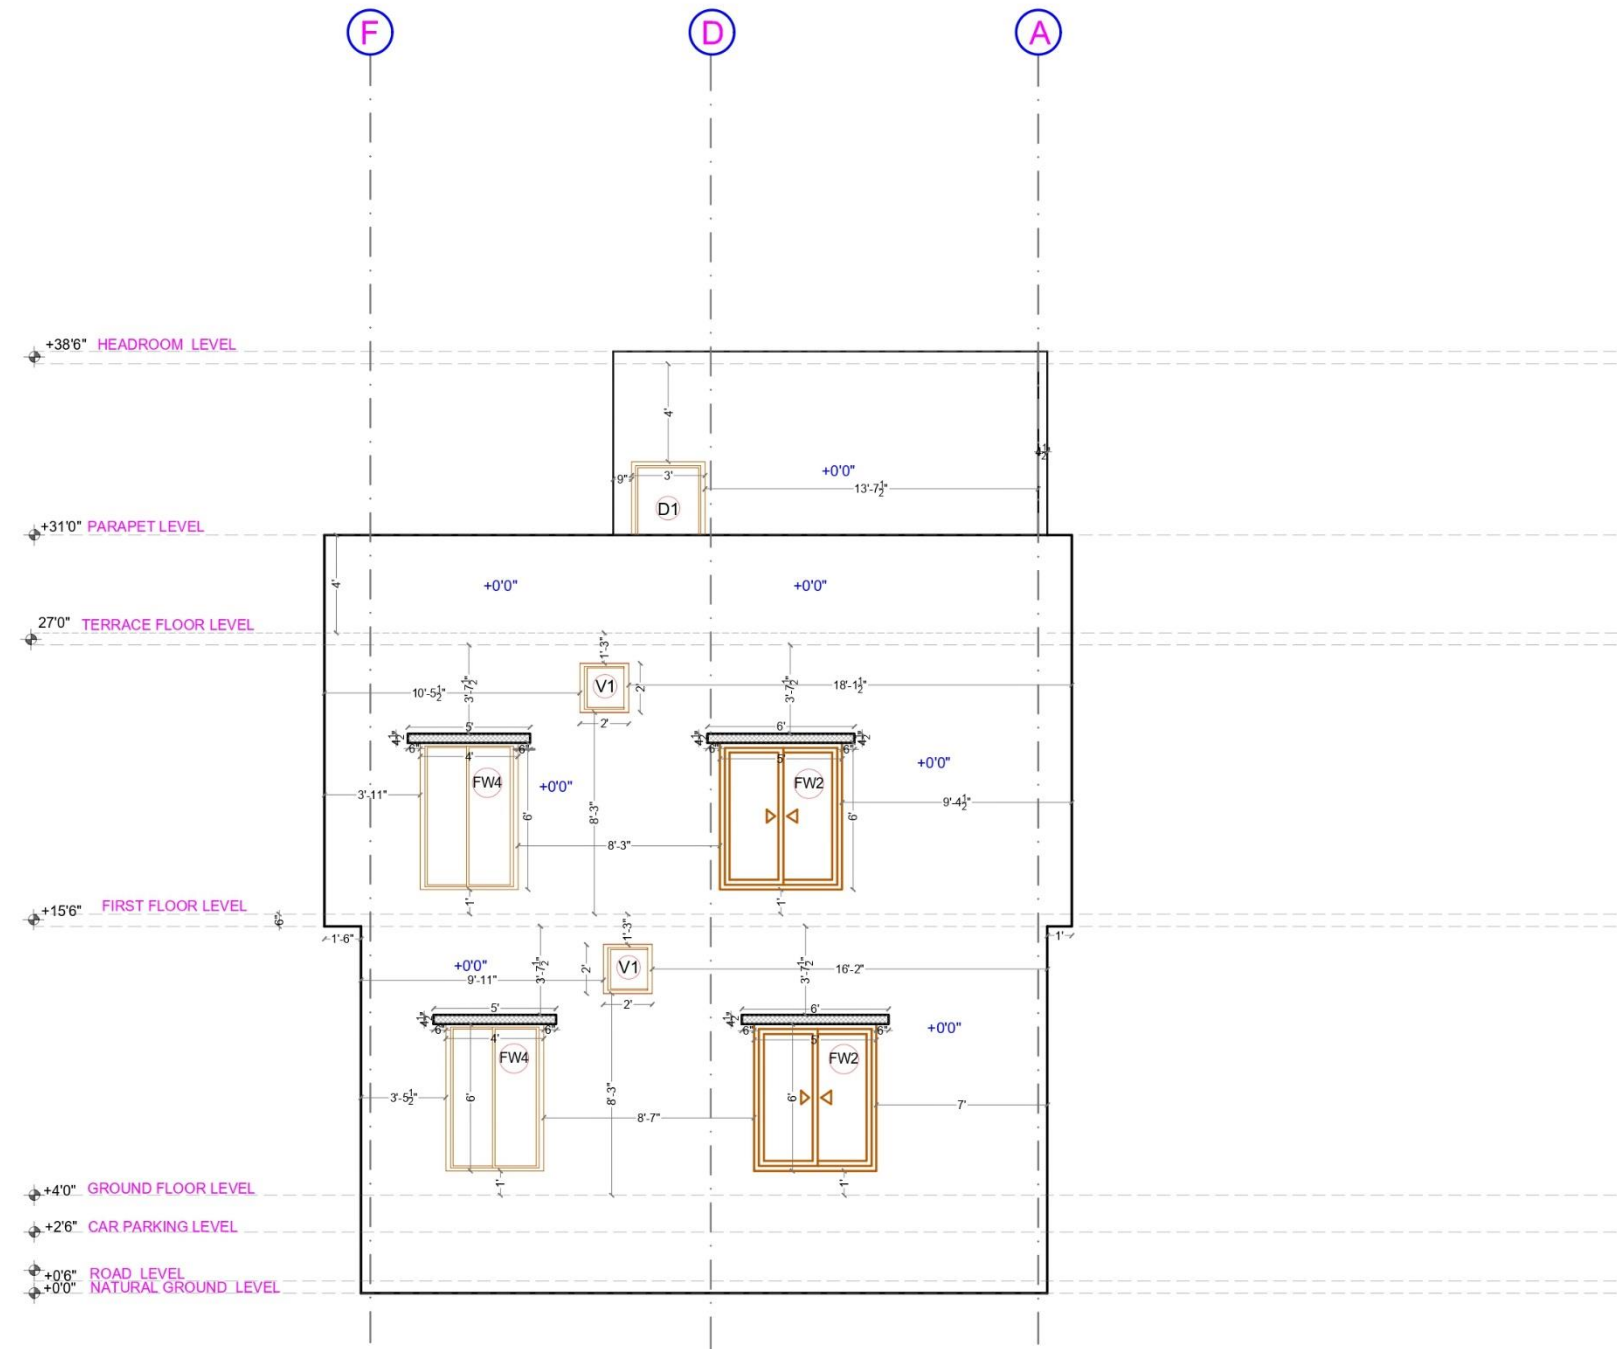

EAST ELEVATION

DRAWING TITLE:

Mr. Vinod Residence 2D
Elevation

CLIENT:

Mr. Vinod

ARCHITECTURAL DESIGNERS:


**DEEJOS ENGINEERS AND
CONTRACTORS PVT Ltd**

2nd floor, C.L.C. Road, Chrompet,
Chennai-600 044,
Mobile: +91-8110000384
Email: projects@deejos.com

SIGNATURE & SEAL:


ORIENTATION:



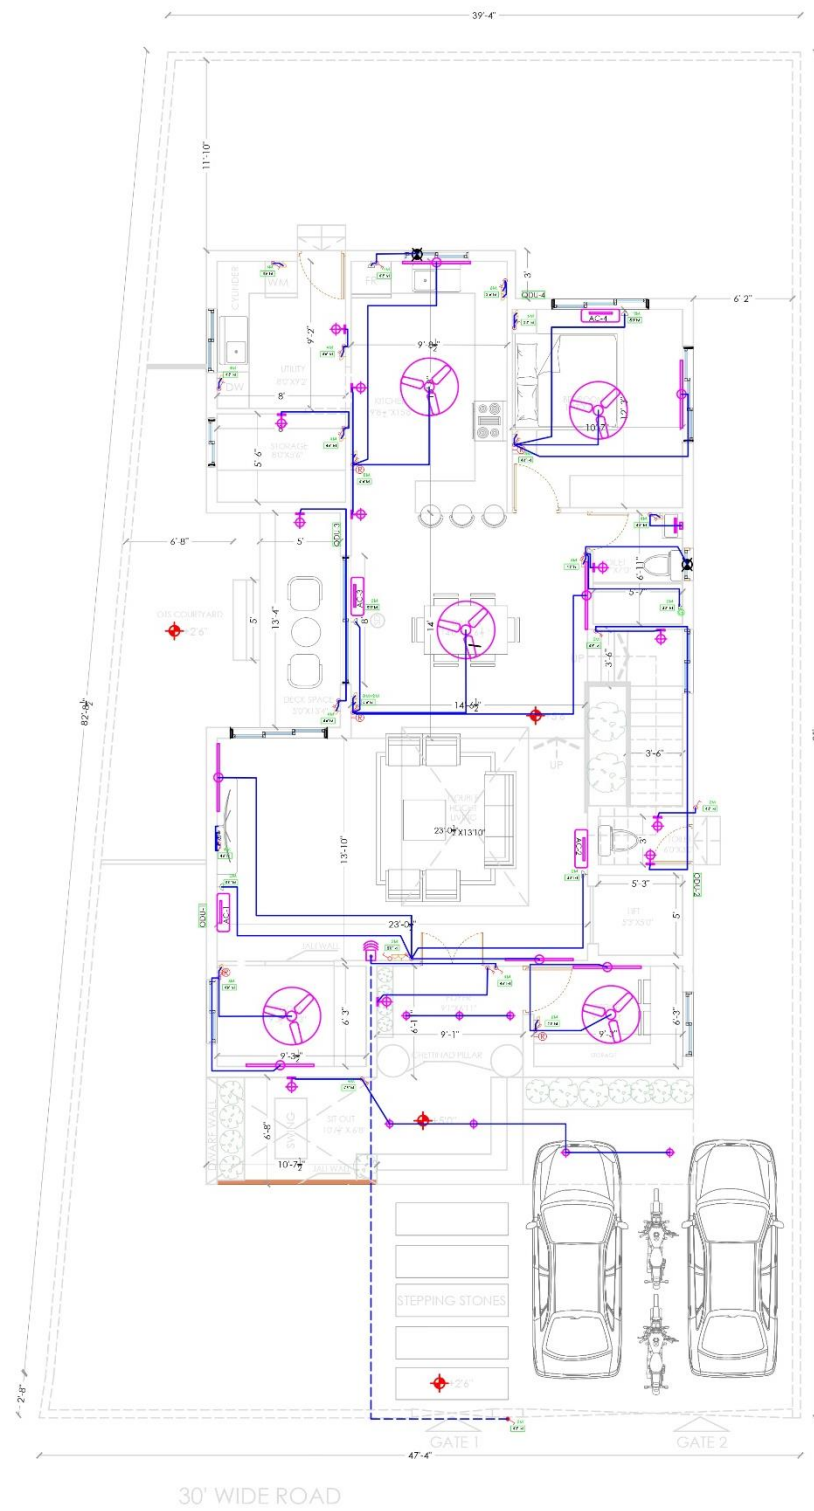

GROUND FLOOR

LEGEND	
	CEILING FAN
	AIR CONDITIONER / AC TRIP SWITCH
	FLOURESCENT LIGHT
	SPOT LIGHT
	WALL LIGHT
	CHANDLIER
	MIRROR LAMP
	CALLING BELL
	EXHAUST FAN
	GEYSER
	DISTRIBUTION BOARD
	U HOOK
	JHULA HOOK
	15A SOCKET
	10A SOCKET
	RO SOCKET
	SOCKET FOR CHIMNEY
	REGULATOR
	SINGLE GANG SWITCH
	DOUBLE GANG SWITCH
	TRIPLE GANG SWITCH
	SINGLE TWO WAY SWITCH
	DOUBLE TWO WAY SWITCH
	TV AND INTERNET POINT
	WALL FAN

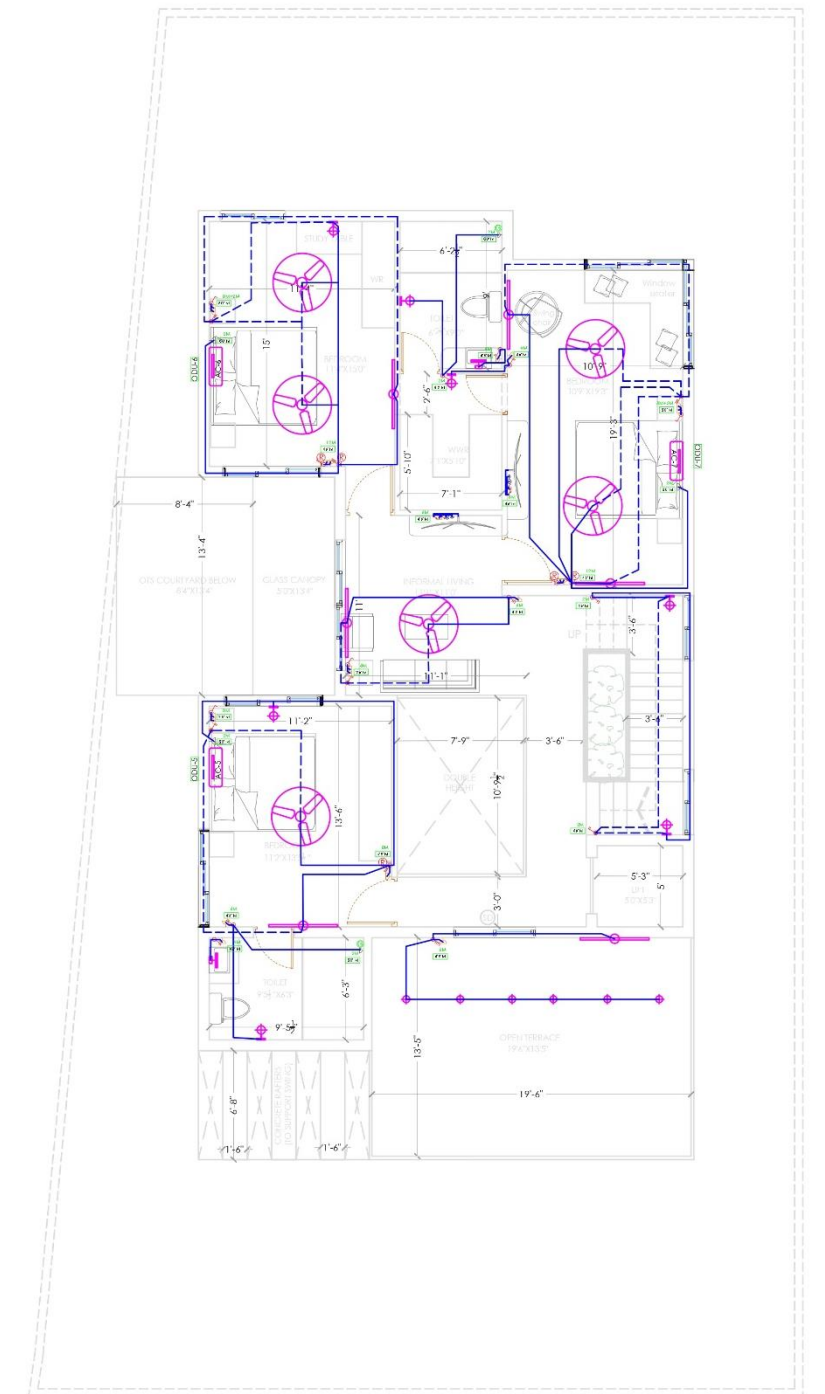

FIRST FLOOR

DRAWING TITLE:

Mr. Vivek Anand Residence
Electrical Drawing

CLIENT:

Mr. Vivek Anand


ARCHITECTURAL DESIGNERS:


**DEEJOS ENGINEERS AND
CONTRACTORS PVT Ltd**

2nd floor, C.L.C. Road, Chrompet,
Chennai-600 044,
Mobile: +91-8110000384
Email: projects@deejos.com

SIGNATURE & SEAL:

ORIENTATION:

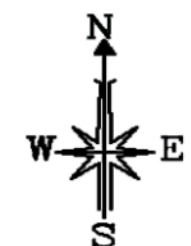

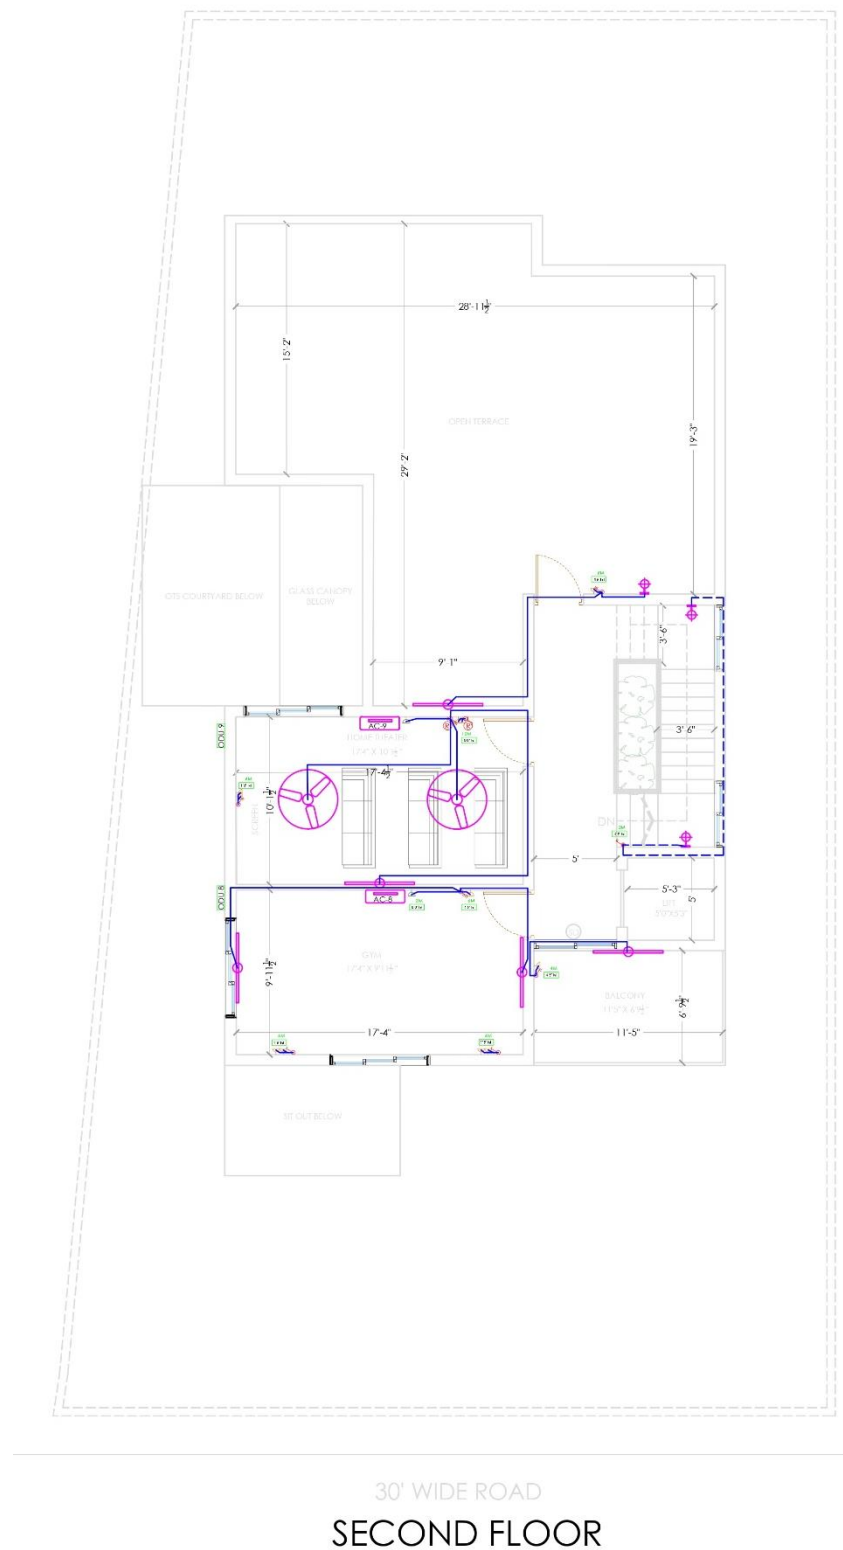

LEGEND	
	CEILING FAN
	AIR CONDITIONER / AC TRIP SWITCH
	FLOURESCENT LIGHT
	SPOT LIGHT
	WALL LIGHT
	CHANDLIER
	MIRROR LAMP
	CALLING BELL
	EXHAUST FAN
	GEYSER
	DISTRIBUTION BOARD
	U HOOK
	JHULA HOOK
	15A SOCKET
	10A SOCKET
	SOCKET FOR RO
	SOCKET FOR CHIMNEY
	REGULATOR
	SINGLE GANG SWITCH
	DOUBLE GANG SWITCH
	TRIPLE GANG SWITCH
	SINGLE TWO WAY SWITCH
	DOUBLE TWO WAY SWITCH
	TV AND INTERNET POINT
	WALL FAN

DRAWING TITLE:

Mr. Vivek Anand Residence
Electrical Drawing

CLIENT:

Mr. Vivek Anand

ARCHITECTURAL DESIGNERS:

**DEEJOS ENGINEERS AND
CONTRACTORS PVT Ltd**

2nd floor, C.L.C. Road, Chrompet,
Chennai-600 044,
Mobile: +91-8110000384
Email: projects@deejos.com

SIGNATURE & SEAL:**ORIENTATION:**



DRAWING TITLE:

3D Elevation

CLIENT:

ARCHITECTURAL DESIGNERS:

**DEEJOS ENGINEERS AND
CONTRACTORS PVT Ltd**

2nd floor, C.L.C. Road, Chrompet,
Chennai-600 044,

Mobile: +91-8110000384

Email: projects@deejos.com

SIGNATURE & SEAL:

ORIENTATION:

