



SATHYABAMA

INSTITUTE OF SCIENCE AND TECHNOLOGY
(DEEMED TO BE UNIVERSITY)

Accredited with “A” grade by NAAC | 12B Status by UGC | Approved by AICTE

Jeppiaar Nagar, Rajiv Gandhi Salai, Chennai – 600 119

www.sathyabama.ac.in

SCHOOL OF BUILDING AND ENVIRONMENT
DEPARTMENT OF ARCHITECTURE
PRACTICAL TRAINING PORTFOLIO (SAR 4063)
JUNE 2023

Name of the Student : RAGHUL.S

Batch : **2018 - 2023**

Reg No. : 38210057

Semester : X



SATHYABAMA

INSTITUTE OF SCIENCE AND TECHNOLOGY
(DEEMED TO BE UNIVERSITY)

Accredited with "A" grade by NAAC | 12B Status by UGC | Approved by AICTE
Jeppiaar Nagar, Rajiv Gandhi Salai, Chennai – 600 119
www.sathyabama.ac.in

SCHOOL OF BUILDING AND ENVIRONMENT
DEPARTMENT OF ARCHITECTURE

VIVA-VOCE EXAMINATION

This is to certify that the practical training SAR 4063 is the work of RAGHUL.S who had undergone training in Design Sync Consulting and Advisory Pvt Ltd. has been monitored by the continuous assessment during JANUARY 2023 to MAY 2023

Dr. Devyani Gangopadhyay
DEAN

Submitted for Viva voce Examination held on 08 June 2023

Internal Examiner

External Examiner



SATHYABAMA

INSTITUTE OF SCIENCE AND TECHNOLOGY
(DEEMED TO BE UNIVERSITY)

Accredited with "A" grade by NAAC | 12B Status by UGC | Approved by AICTE

Jeppiaar Nagar, Rajiv Gandhi Salai, Chennai – 600 119

www.sathyabama.ac.in

DECLARATION

I, RAGHUL.S hereby declare that the Training Report **JANUARY 2023 to MAY 2023** done by me under the guidance of **Ar. PRIYA SHYAM PARAMESWARAN** is submitted in partial fulfillment of the requirements for the completion of practical training session.

DATE : 04.05.2023

PLACE : BANGLORE

A handwritten signature in black ink, appearing to be 'R.S.', is written over a horizontal line.

SIGNATURE OF CANDIDATE

ACKNOWLEDGEMENT

I am pleased to acknowledge my sincere thanks to **Board of Management of SATHYABAMA** for their kind encouragement in doing this practical training and for completing it successfully. I am grateful to them.

I convey my thanks to **Dr. Devyani Gangopadhyay**, Dean, School of Building and Environment and **Ar.Sarath Chandra Kanth**, Design Chair, Department of Architecture for having been a constant source of support and encouragement.

I wish to express my thanks to all Teaching and Non-teaching staff members of the Department of who were helpful in many ways for the completion of the project.

I also wish to thank **Ar.PRIYA SHYAM PARAMESWARAN**, for the experience of interning at their firm.

PROFESSIONAL PRACTICAL TRAINING REPORT 2023

(Monthly Progress to be documented and submitted to the HOD by the Architect in charge of Trainee of the Organization)

- Name of the Office / Organization : DESIGN SYNC COLLABORATIVE - DESIGN SYNC
- Address & Contact Number : C1504, BRIGADE METROPOLIS, MAHADEVAPURA, 9900094737
- Name of the Student : S. RAGHUL
- Duration : From JAN 16th 2023 To FEB 16th 2023
- Total No. of days : 20 working days.
- Evaluation of Performance Criteria shall be on

Description of works	Excellent	Good	Fair	Poor	NA
Office Culture Comprehension			✓		
Participation in the Office			✓		
Reading of Drawings			✓		
Presentation Techniques			✓		
Model Making					✓
Understanding of Construction Details			✓		
Drafting Skills (Manual/Computer)			✓		
Site Supervision / Client Interaction Skills			✓		
Time Schedule Adherence				✓	
Other Computer Skills			✓		
Files and Office Maintenance			✓		
Coordination with other Consultants					✓
Overall Grading*	56.				

* Note: Kindly grade the student as per his/her overall performance in the office during the assessment month*

- Any other Remarks: We plan to introduce client interaction and coordination next month. Wish Raghul all the best to improve on time management.

Signature of the Head of the Office / Organization (With Seal)



PROFESSIONAL PRACTICAL TRAINING REPORT 2023

(Monthly Progress to be documented and submitted to the HOD by the Architect in charge of Trainee of the Organization)

- Name of the Office / Organization : DESIGN SYNC
- Address & Contact Number : C1504, BRIGADE METROPOLIS, MAHADEVAPURA, 9900094737
- Name of the Student : S. RAGHUL
- Duration : From FEB 16th 2023 To MARCH 16th 2023
- Total No. of days : 23 working days.
- Evaluation of Performance Criteria shall be on

Description of works	Excellent	Good	Fair	Poor	NA
Office Culture Comprehension		✓			
Participation in the Office		✓			
Reading of Drawings		✓			
Presentation Techniques		✓			
Model Making 3D Map.		✓			✓
Understanding of Construction Details			✓		
Drafting Skills (Manual/Computer)			✓		
Site Supervision / Client Interaction Skills			✓		
Time Schedule Adherence			✓		
Other Computer Skills			✓		
Files and Office Maintenance		✓			
Coordination with other Consultants			✓		
Overall Grading*	64.				

* Note: Kindly grade the student as per his/her overall performance in the office during the assessment month*

- Any other Remarks:

Signature of the Head of the Office / Organization (With Seal)



PROFESSIONAL PRACTICAL TRAINING REPORT 2023

(Monthly Progress to be documented and submitted to the HOD by the Architect in charge of Trainee of the Organization)

1. Name of the Office / Organization : DESIGN SYNC COLLAB
2. Address & Contact Number : CEO4, BRIGADE METROPOLIS, MAHADEVAPUR
3. Name of the Student : S. RAGHUL
4. Duration : From MARCH 16th To MAY 6th
5. Total No. of days :
6. Evaluation of Performance Criteria shall be on

Description of works	Excellent	Good	Fair	Poor	NA
Office Culture Comprehension			✓		
Participation in the Office			✓		
Reading of Drawings			✓		
Presentation Techniques		✓			
Model Making			✓		✓
Understanding of Construction Details			✓		
Drafting Skills (Manual/Computer)				✓	
Site Supervision / Client Interaction Skills				✓	
Time Schedule Adherence		✓			
Other Computer Skills		✓			
Files and Office Maintenance			✓		
Coordination with other Consultants			✓		
Overall Grading*					

* Note: Kindly grade the student as per his/her overall performance in the office during the assessment month *

7. Any other Remarks:

Working Raghul well the best -!

Signature of the Head of the Office / Organization (With Seal)



S.NO:	DATE	PROJECTS
1	30-01-2023	BELGAUM MCD SKETCHUP SIGNAGES MODELLING AND RENDER
2	31-01-2023	BELGAUM MCD SKETCHUP MODELLING MISTAKES WAS CORRECTED AND FEW MORE ELEMENTS WERE ADDED
3	01-02-2023	BELGAUM MCD RENDERING WAS COMPLETED
4	02-02-2023	NAYADAHALLI RAILWAY STATION - ENTRANCE SKETCHUP MODEL
5	06-02-2023	NAYADAHALLI RAILWAY STATION - ENTRANCE SKETCHUP MODEL
6	08-02-2023	NAYADAHALLI RAILWAY STATION - ENTRANCE SKETCHUP MODEL
7	09-02-2023	SBC LADIES WAITING AREA SKETCHUP MODEL
8	10-02-2023	PAVOR BLOCK PATTERN
9	11-02-2023	SBC TOILET BLOCK SECTION,TICKET COUNTER COLUMN MAPPING (NAYADAHALLI) PAVOR BLOCK PATTERN
10	13-02-2023	SBC TOILET BLOCK (SECTION & ELEVATION),LADIES TOILET WAITING ROOM MATERIAL SELECTION (MOODBOARD)
11	14-02-2023	SBC TOILET BLOCK ELEVATIONS
12	15-02-2023	SBC LADIES WAITING AREA SKETCHUP MODEL
13	16-02-2023	SBC LADIES WAITING AREA SKETCHUP MODEL
14	21-02-2023	SBC GENTS WAITING AREA SKETCHUP MODEL
15	22-02-2023	SBC LADIES & GENTS WAITING AREA SKETCHUP MODEL
16	23-02-2023	SBC GENTS WAITING AREA SKETCHUP MODEL
17	24-02-2023	SBC GENTS WAITING AREA SKETCHUP MODEL,FALSE CEILING CAD DRAWING - SKETCHUP MODEL
18	25-02-2023	SBC GENTS WAITING AREA SKETCHUP MODEL,FALSE CEILING LAYOUT (FANS & LIGHT FIXTURES LAYOUT)SKETCHUP MODEL

S.NO:	DATE	PROJECTS
19	27-02-2023	SBC GENTS WAITING HALL, ELEVATIONS - SKETCHUP MODEL
20	28-02-2023	SBC GENTS WAITING HALL, SHOP,SEATING LAYOUT - (SKETCHUP MODEL OPTIONS)
21	01-03-2023	SBC GENTS WAITING HALL- (SKETCHUP MODEL),NAYADAHALLI TICKET COUNTER (SKETCHUP MODEL)
22	02-03-2023	SBC GENTS WAITING HALL- ELEVATIONS (SKETCHUP MODEL),PRACHITEE LAMINATE CAD WORK
23	03-03-2023	PRACHITEE FURNITURE BLOCK FORMATION (SKETCHUP),NAYADAHALLI STATION - ELEVATION ,SKETCHES AND SBC - GENTS WAITING HALL ELEVATION CORRECTIONS
24	08-03-2023	SBC AC WAITING HALL GENERAL LAYOUT & SKETCHUP MODELLING
25	09-03-2023	SBC AC WAITING HALL SEATING LAYOUT & SKETCHUP MODELLING
26	10-03-2023	NAYADAHALLI & SBC WAITING HALL SKETCHUP MODEL
27	11-03-2023	SBC AC WAITING HALL SKETCHUP MODELLING, SEATING LAYOUT & NAYANDAHALLI SKETCHUP MODELLING
28	13-03-2023	BELGAM MCD PRESENTATION WORK
29	14-03-2023	SBC AC WAITING HALL LAYOUT & SKETCHUP MODELLING
30	15-03-2023	SBC AC WAITING HALL SEATING LAYOUT
31	16-03-2023	SBC GENTS WAITING AREA SKETCHUP MODEL,FALSE CEILING LAYOUT (FANS & LIGHT FIXTURES LAYOUT)SKETCHUP MODEL
32	21-03-2023	SBC AC WAITING HALL SEATING LAYOUT-SKETCHUP
33	23-03-2023	NAYANDAHALLI ELEVATION DESIGN & SBC SECOND ENTRY - SKETCHUP MODELLING

Date: 04 JUN 2023


Ref: DS/Admin/2023/86

TO WHOMSOEVER IT MAY CONCERN

Sub: Completion of Internship Program for Mr. S. Raghul

This is to certify that Mr. S. Raghul with Reg. no 38210057 has completed Internship for a period of 12 weeks at our firm Design Sync Consulting and Advisory Pvt Ltd from 16th Jan 2023 2022 to 4th May 2023. During this period he contributed to the projects he was involved in-creating presentation works and working drawings. We wish him good luck in his future endeavours.


Thanking you, Yours faithfully,

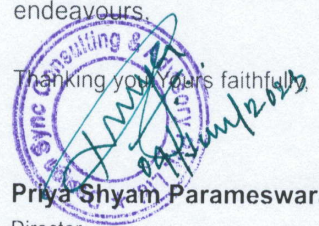
Priya Shyam Parameswaran
Director
Design Sync
Consulting & Advisory Pvt Ltd . Bangalore

Bachelor of Architecture B.Arch
Masters in Building Engineering and Management M.BEM

PROJECTS

1. SBC STATION - GENTS WAITING HALL
2. AC WAITING HALL - PLATFORM NO 1
3. BELGAUM MCDONALDS STORE
4. SBC SECOND ENTRY - TOILET BLOCK
5. PRESTIGE JINDAL RESIDENCE
6. NAYANDAHALLI RAILWAY STATION

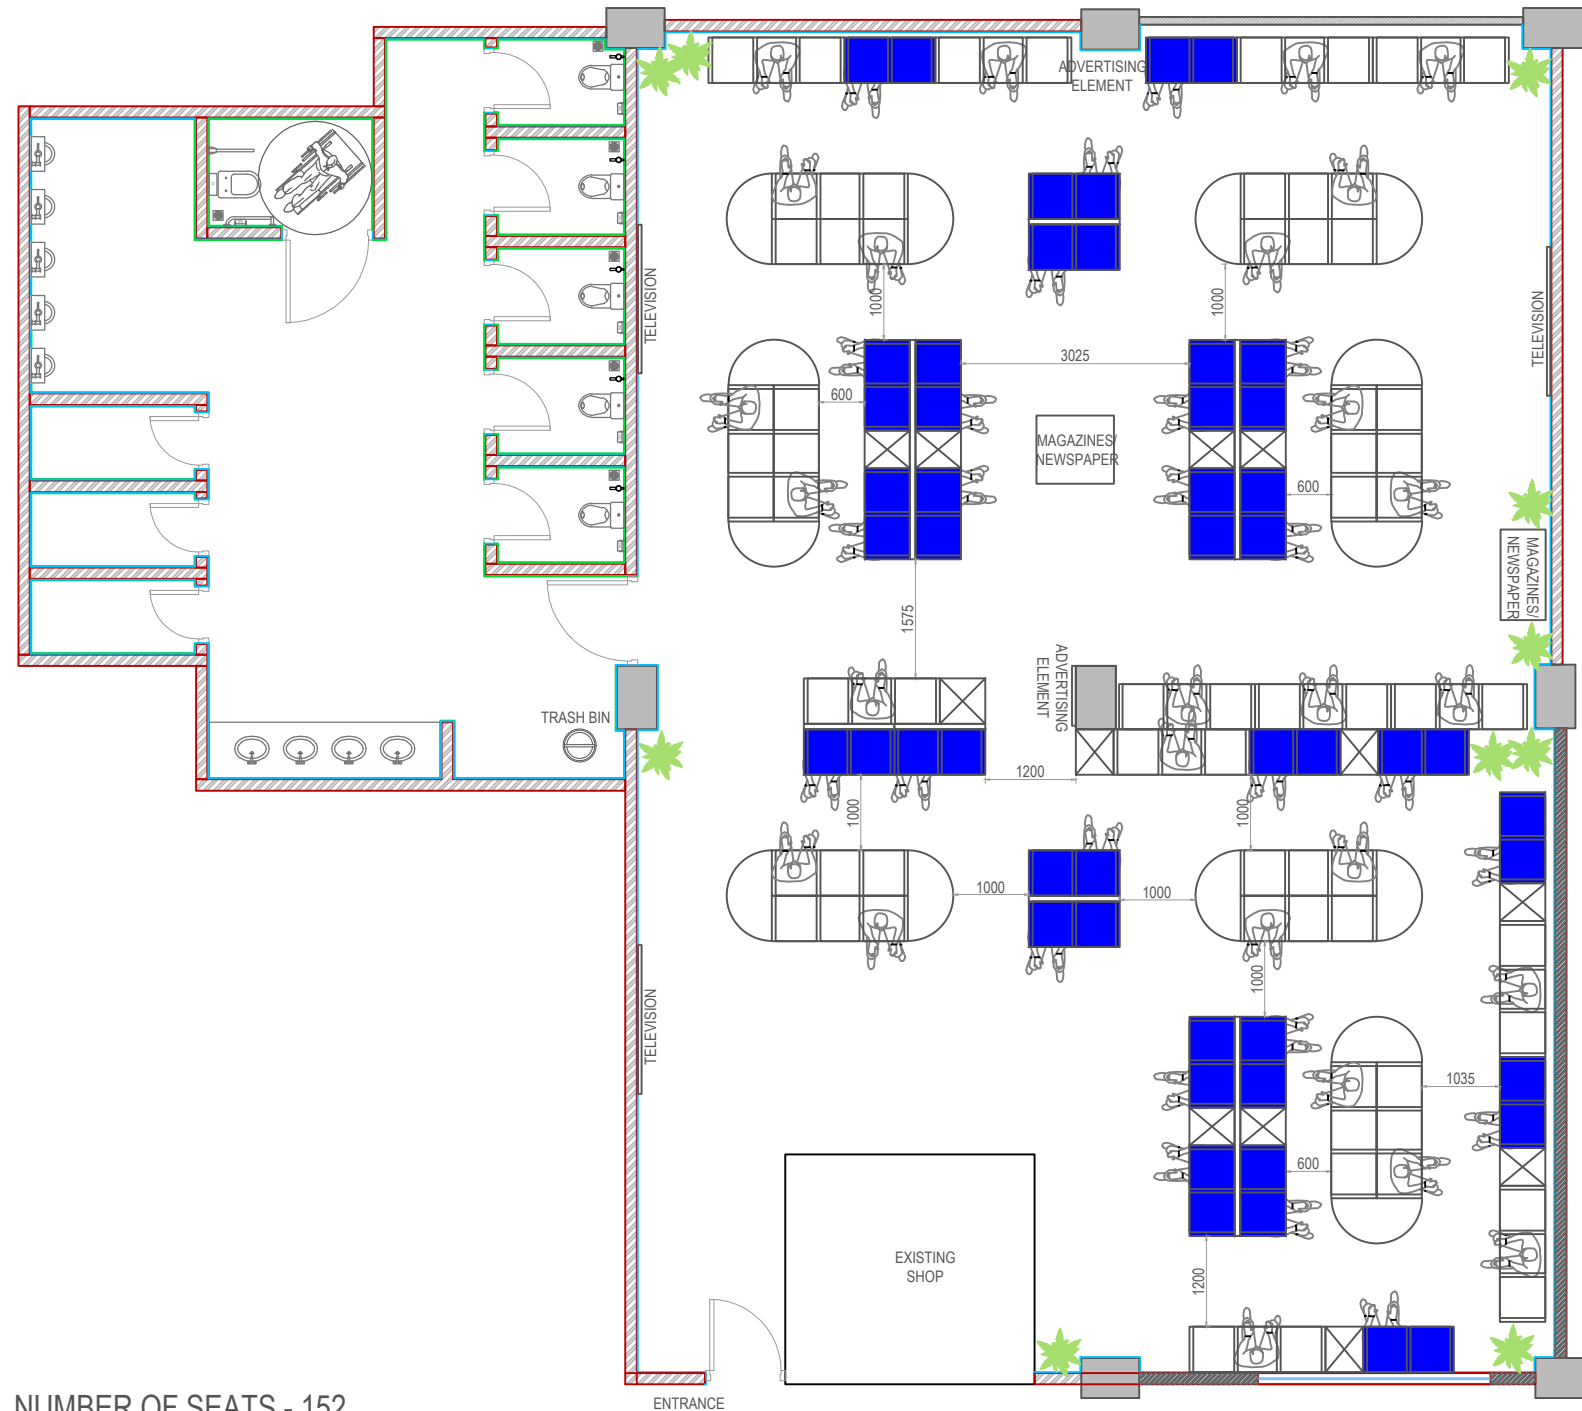

NUMBER OF SEATS - 152

LEGEND	
	2 SEATER
	3 SEATER
	CHARGING UNIT JUNCTION BOX

DESIGN SYNC COLLABORATIVE
DESIGN SYNC CONSULTING & ADVISORY PVT LTD
BRIGADE METROPOLIS WHITEFIELD ROAD

080:25350922
studio@designsync.in
www.designsync.in



WAITING HALL SBC STATION KARNATAKA

STAGE	PURPOSE
☐ F EASIBILITY	☐ T ENDER REVIEW
☐ D ESIGN	☐ C O-ORDINATION
☐ C ONSTRUCTION	☐ E XECUTION

TITLE
GENTS WAITING HALL
SEATING ARRANGEMENT

DRAWING NUMBER	SCALE	ISSUED	VERSION
A-101	1:100	02 MAR 2023	R0

01

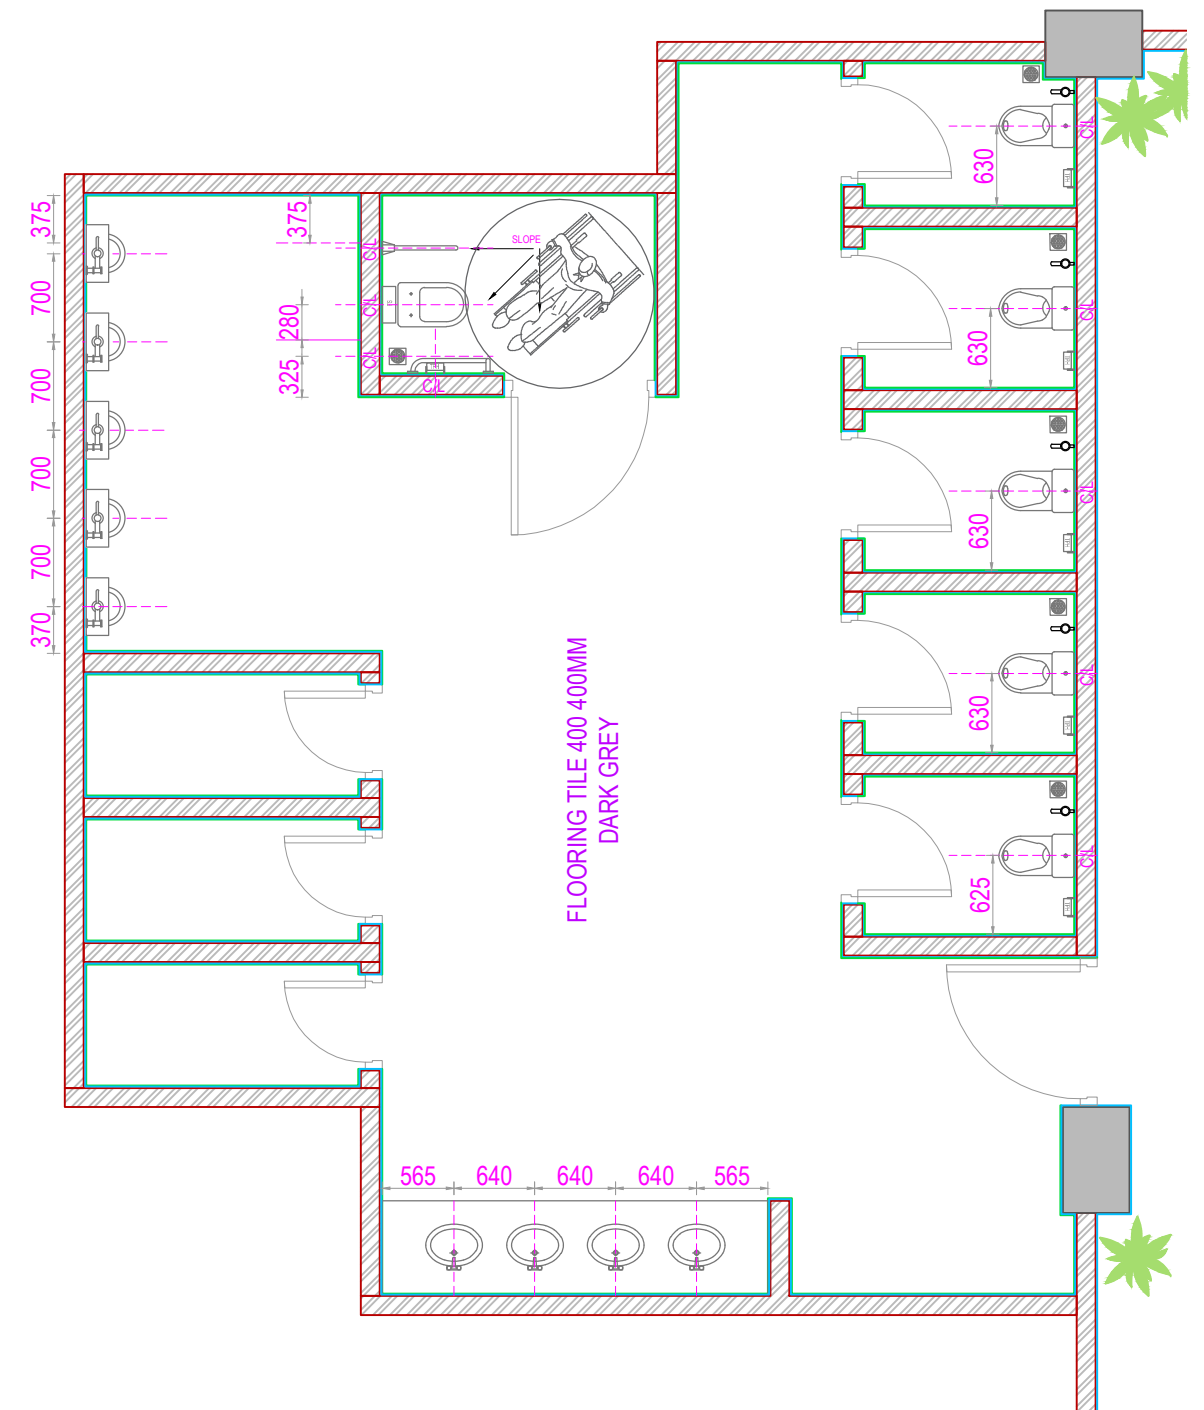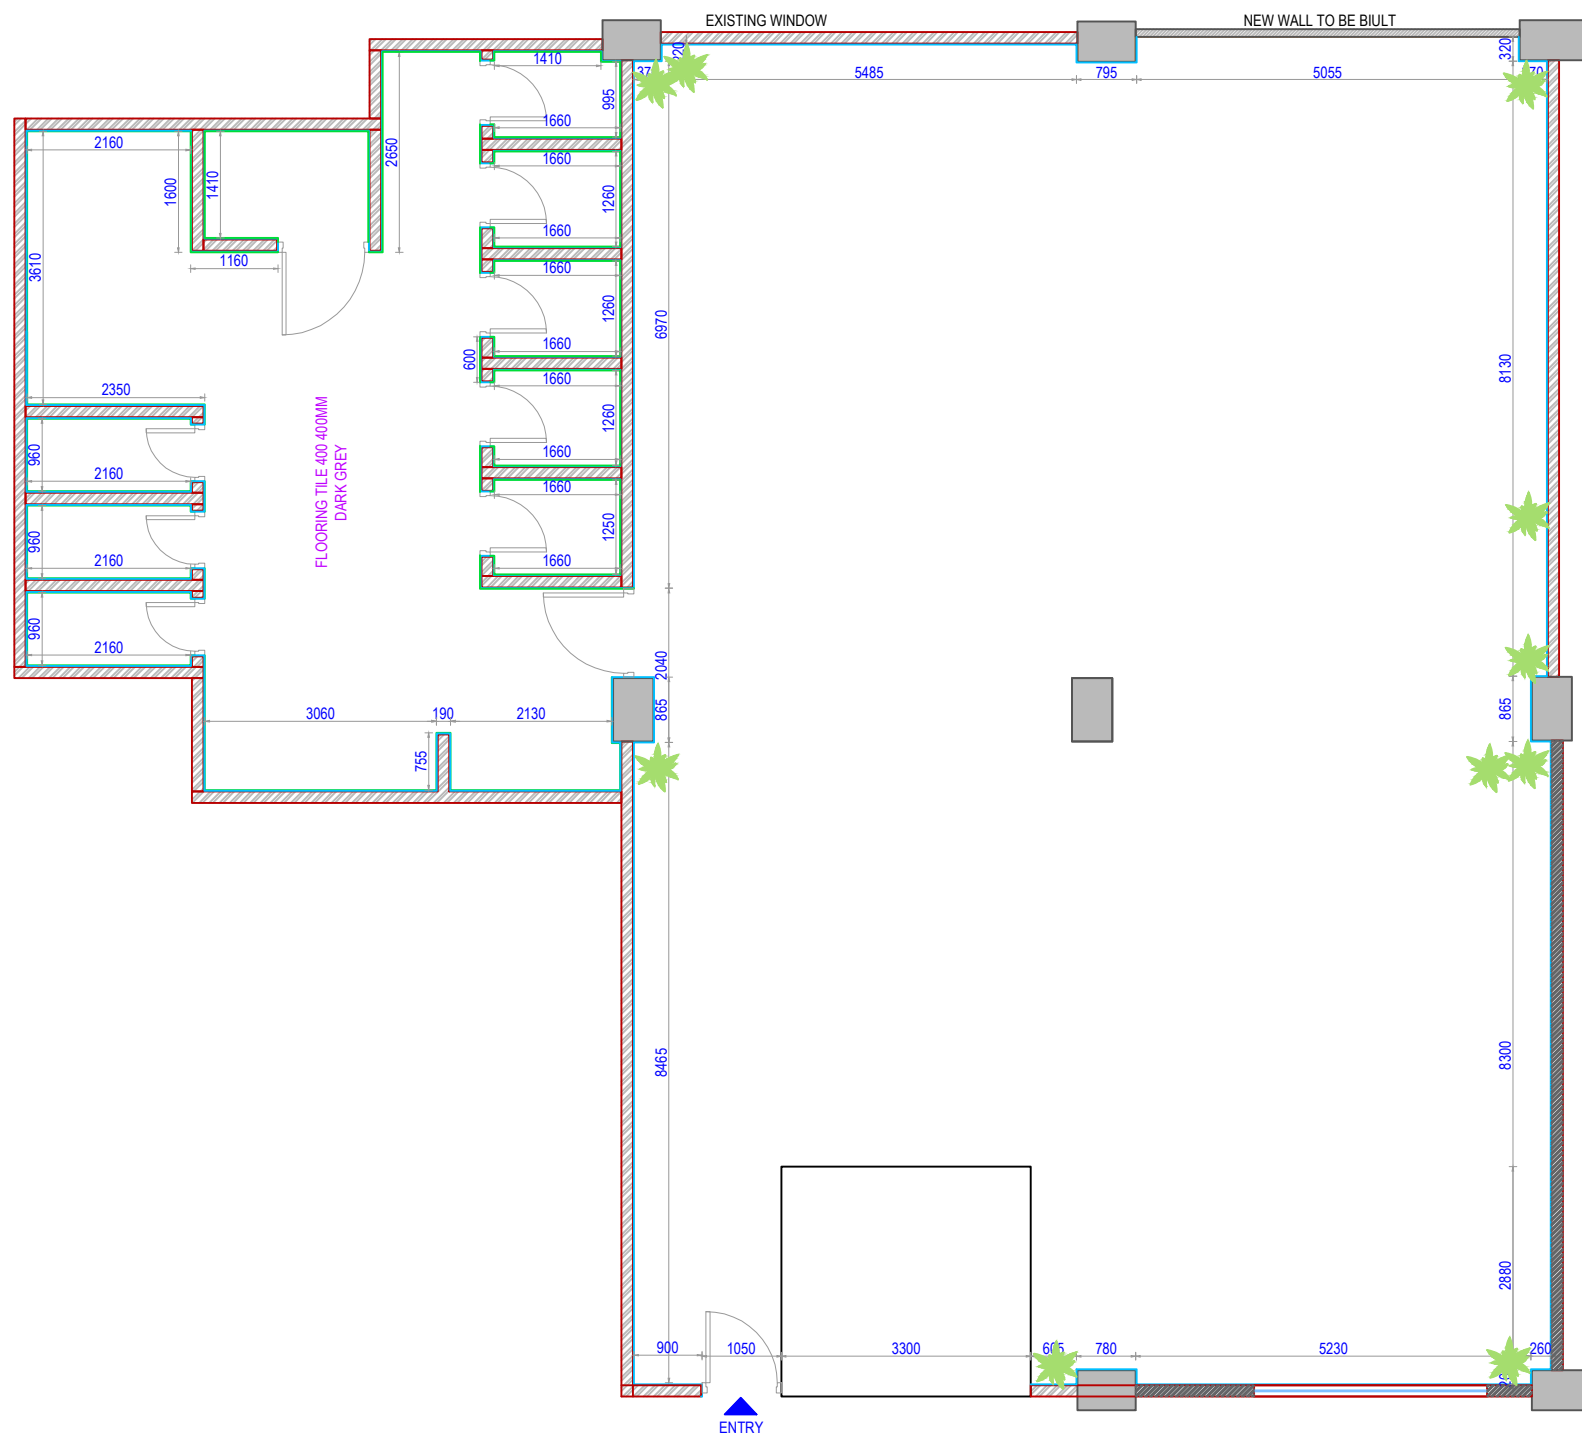

FIXTURE ALIGNMENT LAYOUT

DESIGN SYNC COLLABORATIVE
DESIGN SYNC CONSULTING & ADVISORY PVT LTD
BRIGADE METROPOLIS WHITEFIELD ROAD

080:25350922
studio@designsync.in
www.designsync.in

WAITING HALL SBC STATION
KARNATAKA

KARNATAKA

STAGE

□ F EASIBILITY

DESIGN

CONSTRUCTION

PURPOSE

☐ **T**ENDER REVIEW

C O-ORDINATION

EXECUTION

TITLE

GENTS WAITING HALL TOILET
CIVIL LAYOUT

CIVIL LAYOUT

DRAWING NUMBER

SCALE


ISSUED

02 MAR 2023


VERSION

R0


02

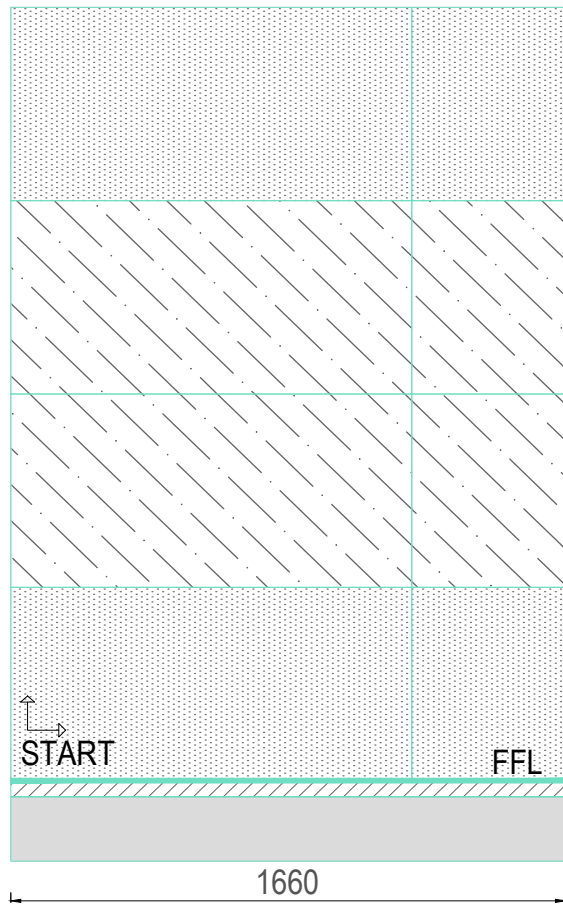


ELEVATION A

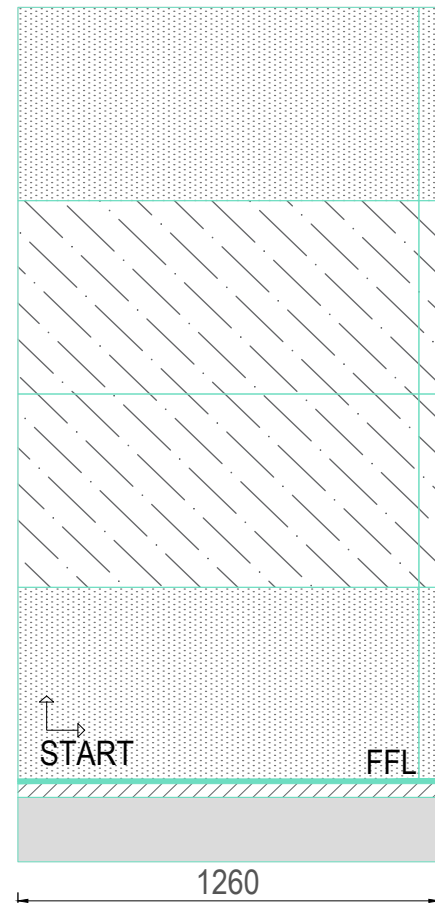


ELEVATION B

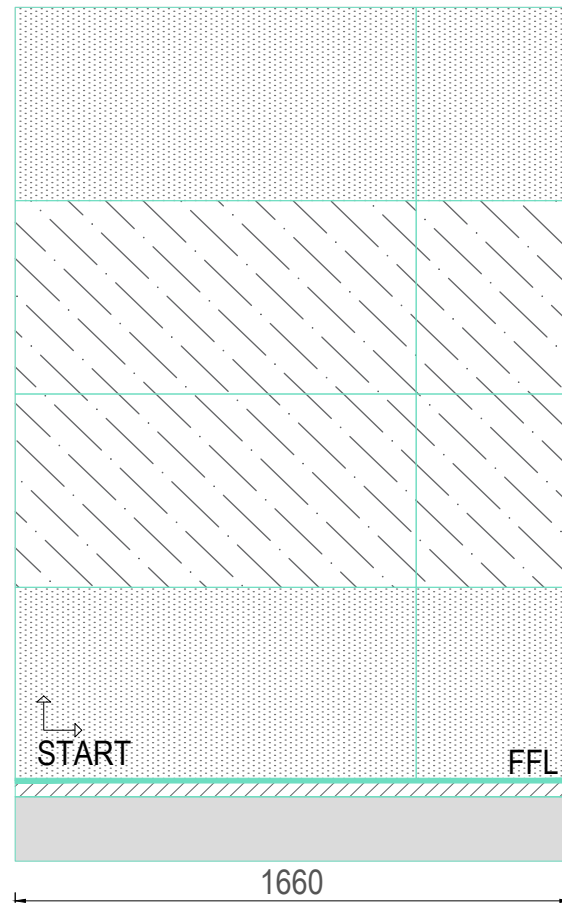

ELEVATION C

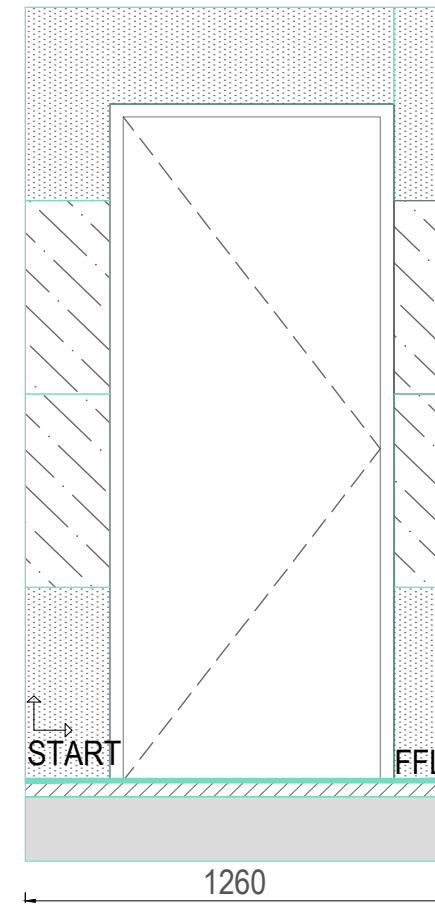


ELEVATION D

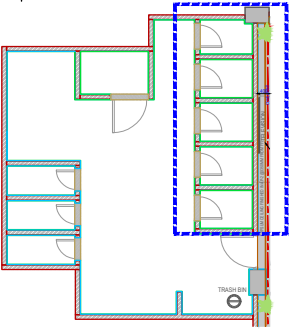

KEY PLAN

2 TOILET BLOCK WALL ELEVATION

Scale: 1:15

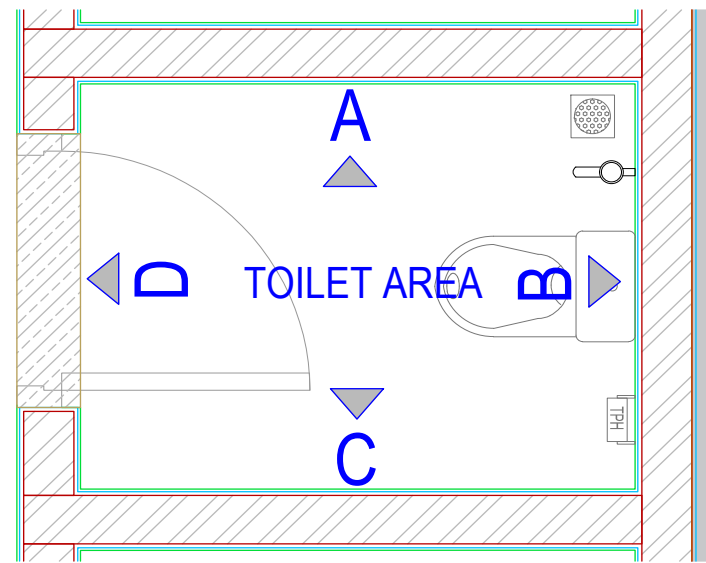

1 TOILET BLOCK PLAN

Scale: 1:15

LEGEND	
TL-01 - 600 X 1200	BLACK TILE
TL-02 - 600 X 1200	WHITE TILE
TL-03 - 600 X 1200	GREY TILE

DESIGN SYNC COLLABORATIVE
DESIGN SYNC CONSULTING & ADVISORY PVT LTD
BRIGADE METROPOLIS WHITEFIELD ROAD

080:25350922
studio@designsync.in
www.designsync.in


WAITING HALL SBC STATION
KARNATAKA

STAGE	
☐ F	EASIBILITY
☐ D	ESIGN
☐ C	ONSTRUCTION
PURPOSE	
☐ T	ENDER REVIEW
☐ C	O-ORDINATION
☐ E	XECUTION

TITLE
GENTS WAITING HALL
TOILET BLOCK WALL ELEVATION

DRAWING NUMBER	SCALE	ISSUED	VERSION
A-204	1:15	02 MAR 2023	R0

03

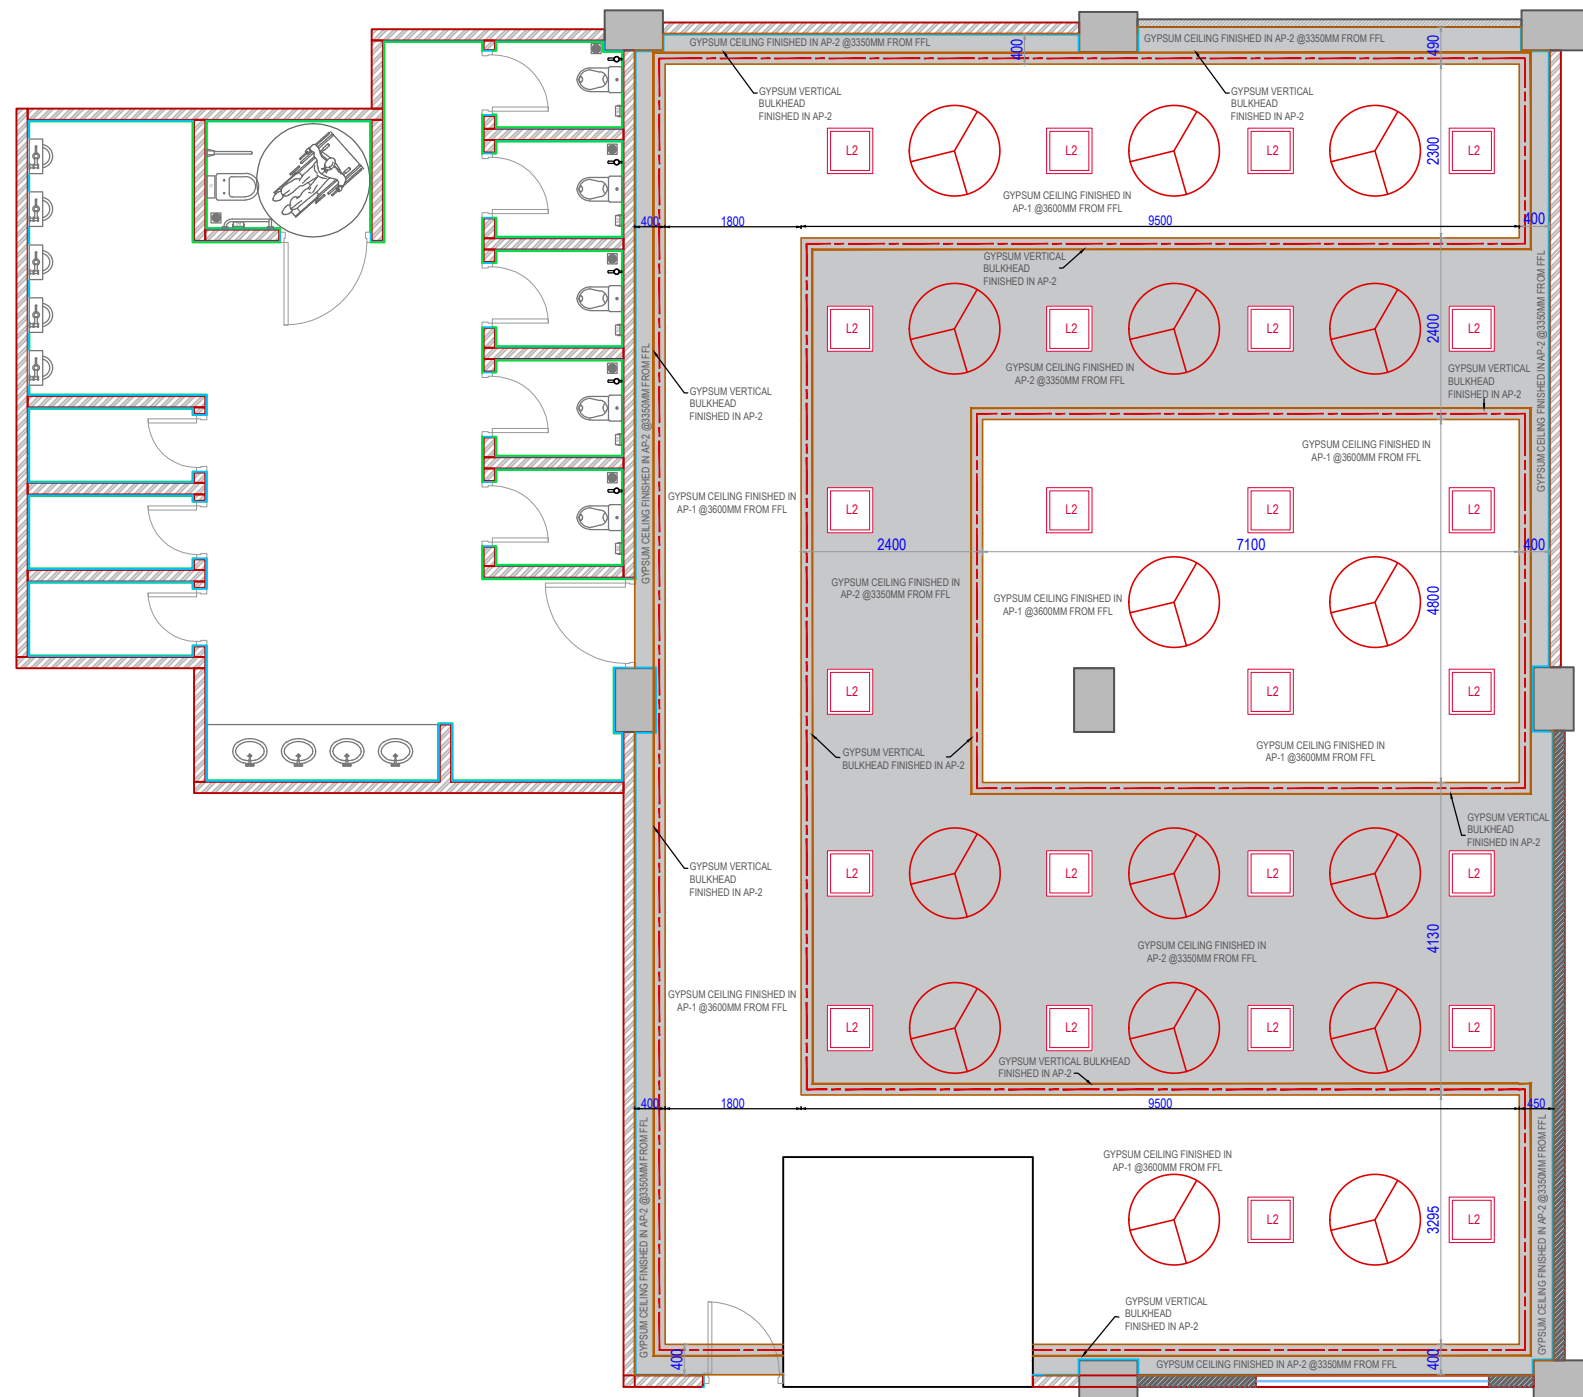

DESIGN SYNC COLLABORATIVE
DESIGN SYNC CONSULTING & ADVISORY PVT LTD
BRIGADE METROPOLIS WHITEFIELD ROAD

080:25350922
studio@designsync.in
www.designsync.in

WAITING HALL SBC STATION KARNATAKA

STAGE
☐ F EASIBILITY
☒ D ESIGN
☐ C ONSTRUCTION

PURPOSE
☐ T ENDER REVIEW
☒ C O-ORDINATION
☐ E XECUTION

TITLE
GENTS WAITING HALL
FALSE CEILING LAYOUT


DRAWING NUMBER
A-208

SCALE
1:100

ISSUED
02 MAR 2023

VERSION
R0

04

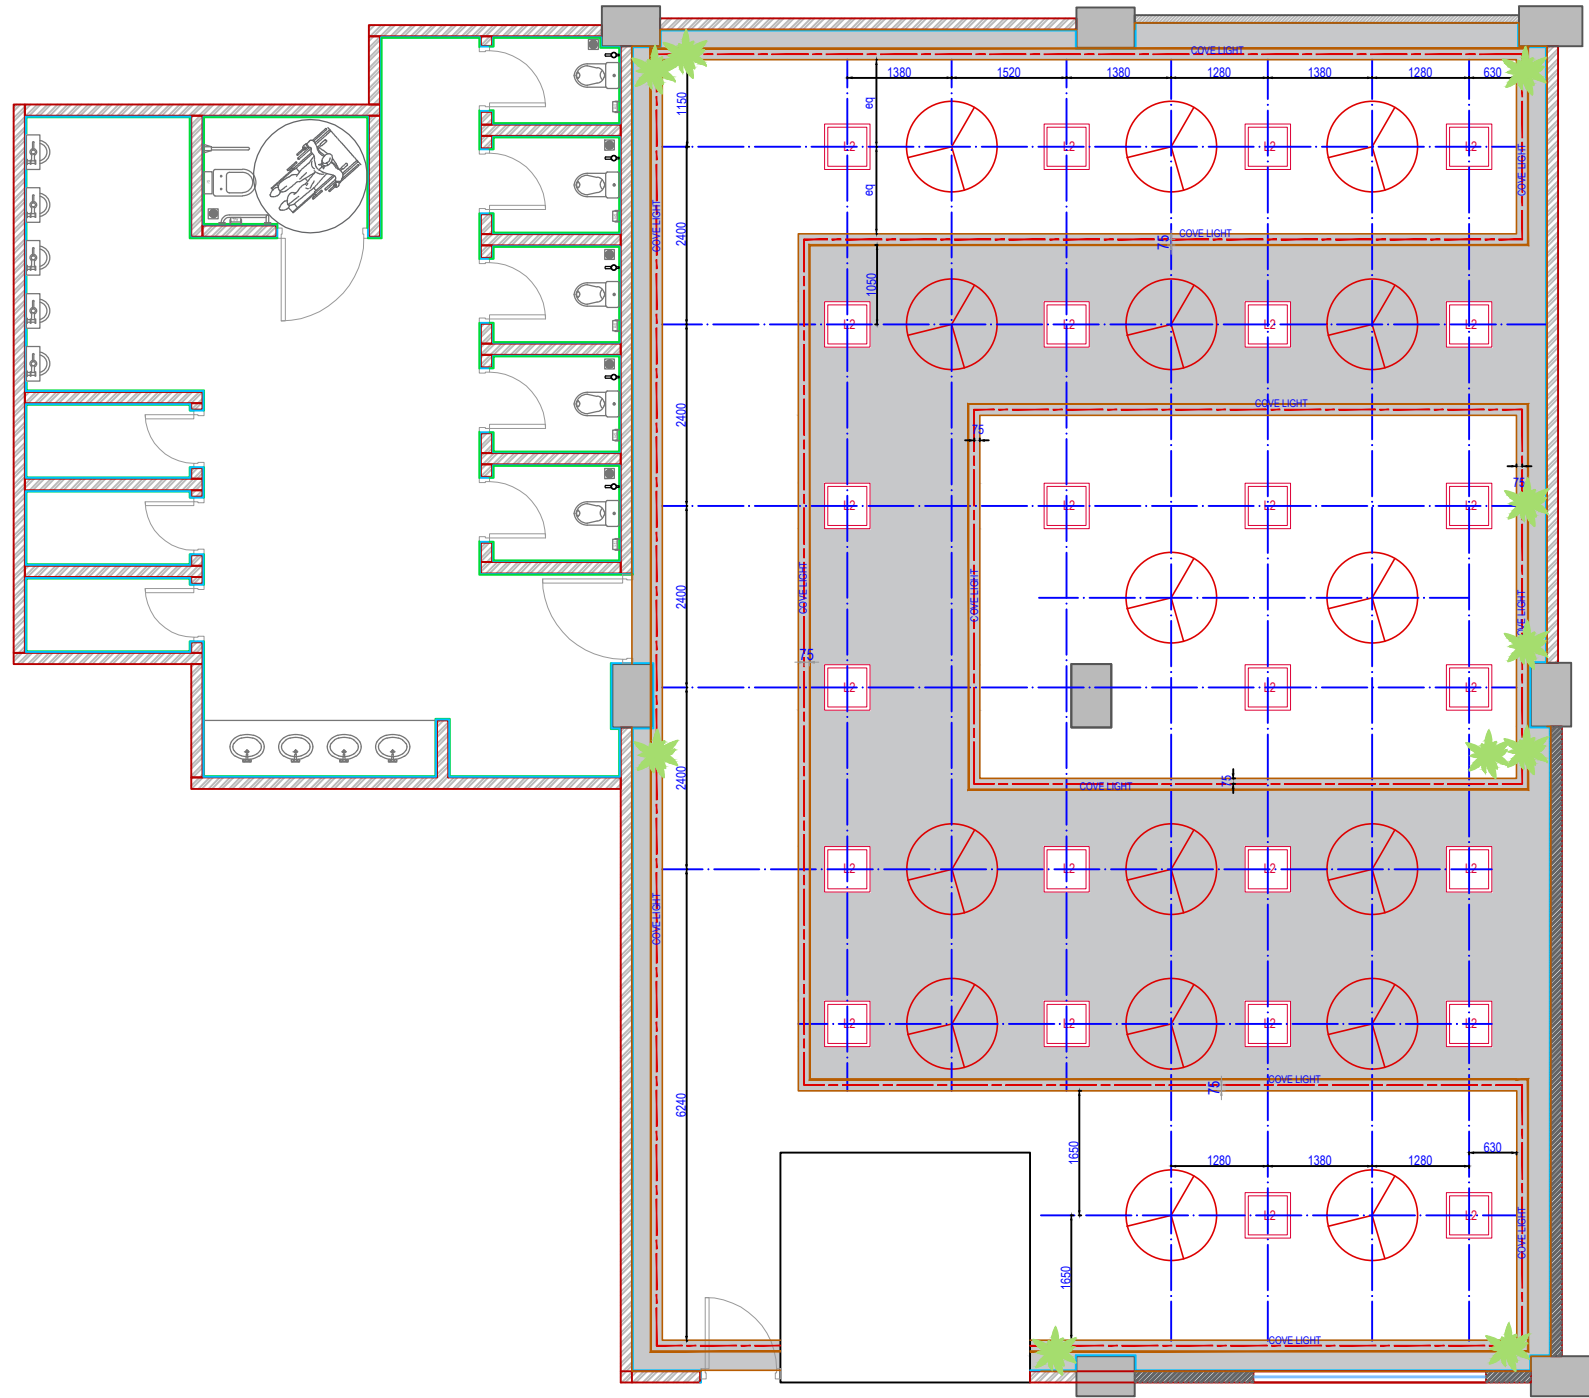

DESIGN SYNC COLLABORATIVE
DESIGN SYNC CONSULTING & ADVISORY PVT LTD
BRIGADE METROPOLIS WHITEFIELD ROAD

080:25350922
studio@designsync.in
www.designsync.in


WAITING HALL SBC STATION
KARNATAKA

STAGE
☐ F EASIBILITY
☒ D ESIGN
☐ C ONSTRUCTION
PURPOSE
☐ T ENDER REVIEW
☒ C O-ORDINATION
☐ E XECUTION


TITLE
GENTS WAITING HALL
LIGHTING LAYOUT

DRAWING NUMBER SCALE ISSUED VERSION
A-209 1:100 02 MAR 2023 R0


05

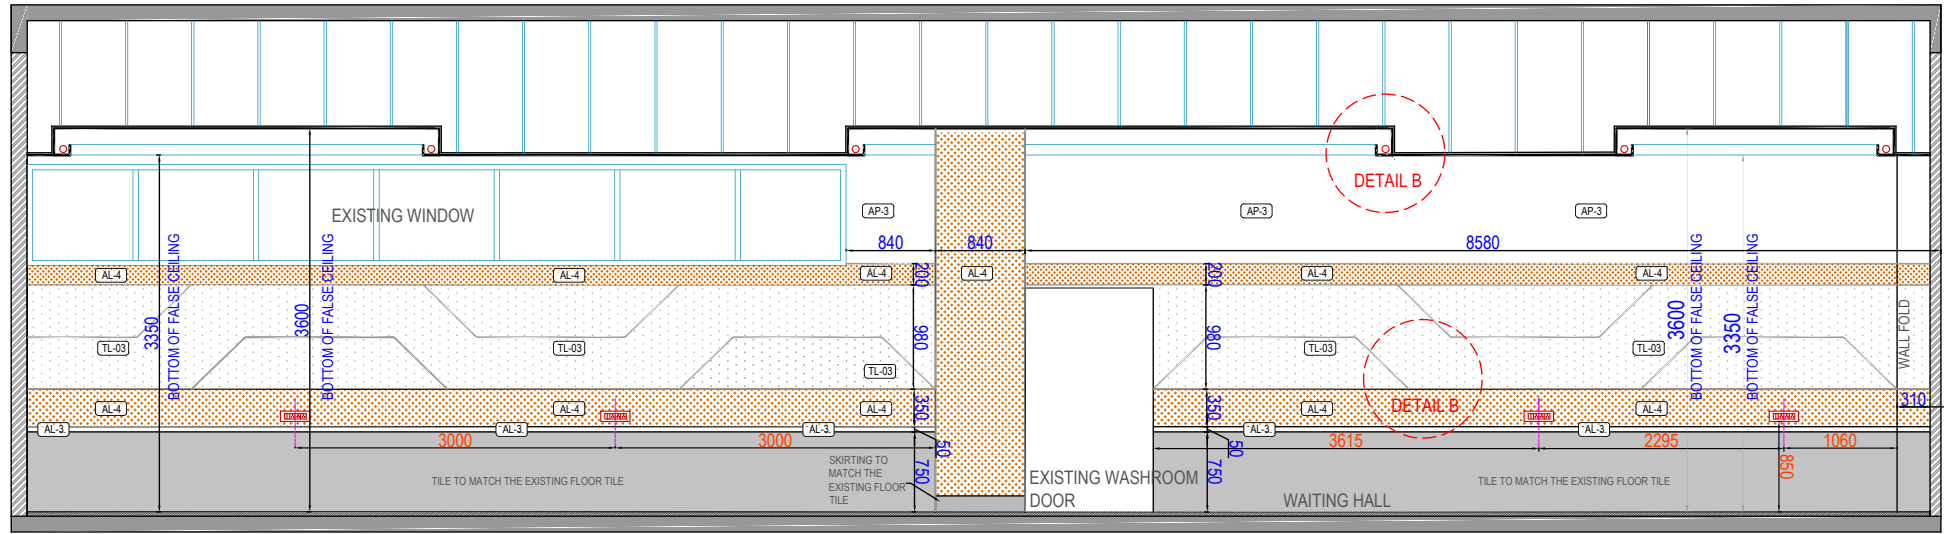


01 WALL ELEVATION A
1:50

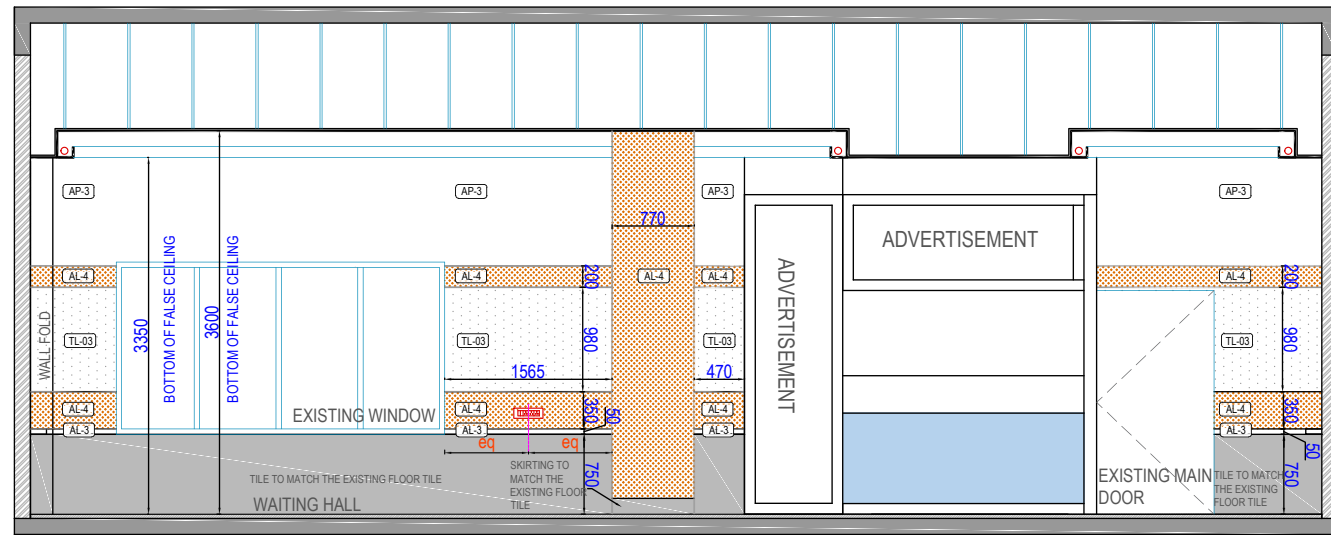


03 WALL ELEVATION C
1:50

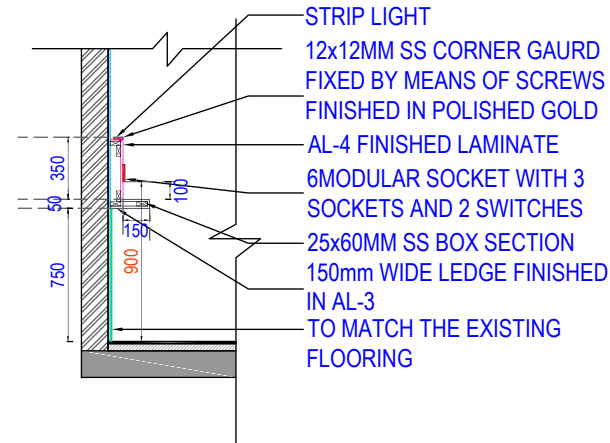

04 DETAIL B
05

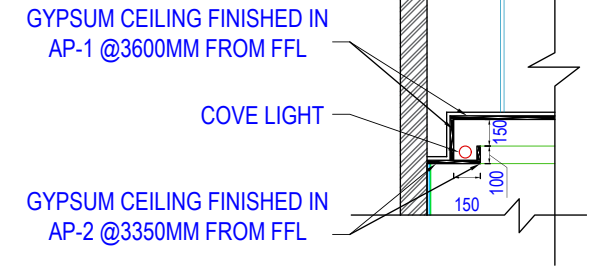

04 TYPICAL COVE DETAIL
1:30

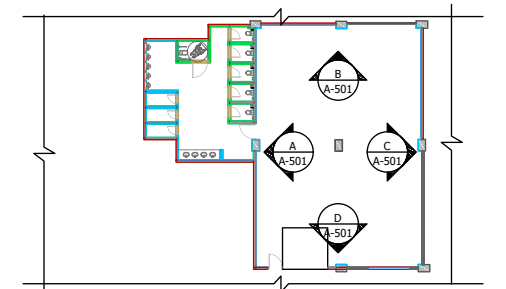

08 KEY PLAN

LEGEND	
TL-01 - 600 X 1200	BLACK TILE
TL-02 - 600 X 1200	WHITE TILE
TL-03 - 600 X 1200	GREY TILE

LAMINATE		
CODE	COLOUR	MAKE
A-L1	WHITE	CF-132 ROYAL TOUCHE
A-L2	SLATE GREY	CF-184 ROYAL TOUCHE
A-L3	MATT BLACK	CF-106 ROYAL TOUCHE
A-L4	RURAL OAK	CF-489 ROYAL TOUCHE

12x12MM SS CORNER GUARD/ TILE STRIPS
FIXED FINISHED IN POLISHED GOLD

PAINT FINISHES	
A-P1	AGATE GREY (RAL 7038)- DULUXE
A-P2	SIGNAL WHITE DULUX- RAL 9003-
A-P3	BLUEWEED -9232

DESIGN SYNC COLLABORATIVE
DESIGN SYNC CONSULTING & ADVISORY PVT LTD
BRIGADE METROPOLIS WHITEFIELD ROAD

080:25350922
studio@designsync.in
www.designsync.in


WAITING HALL SBC STATION KARNATAKA

STAGE	PURPOSE
☐ F EASIBILITY	☐ T ENDER REVIEW
☐ D ESIGN	☐ C O-ORDINATION
☐ C ONSTRUCTION	☐ E XECUTION


TITLE
GENTS WAITING HALL
WALL ELEVATIONS

DRAWING NUMBER	SCALE	ISSUED	VERSION
A-501	1:15	02 MAR 2023	R0


06

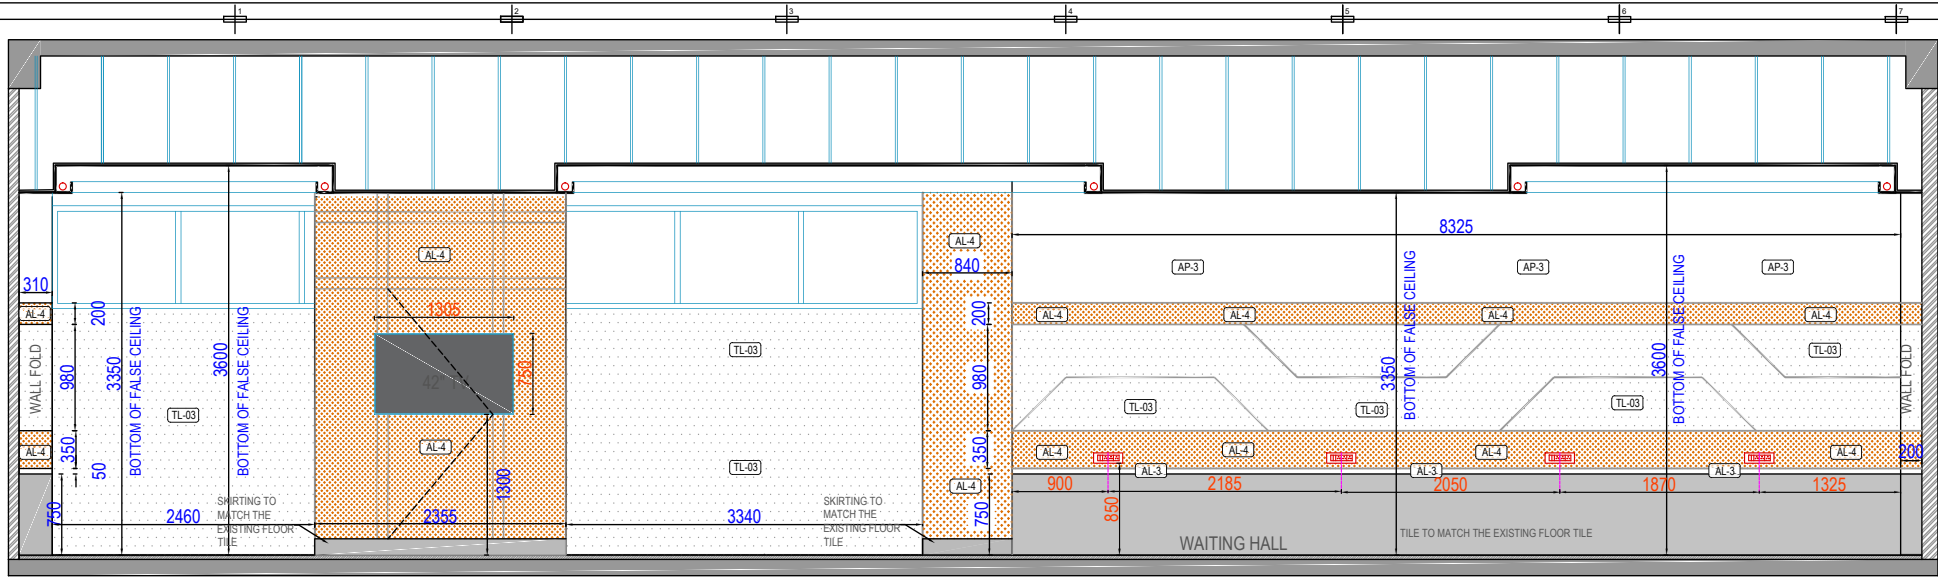


01 WALL ELEVATION A
1:50

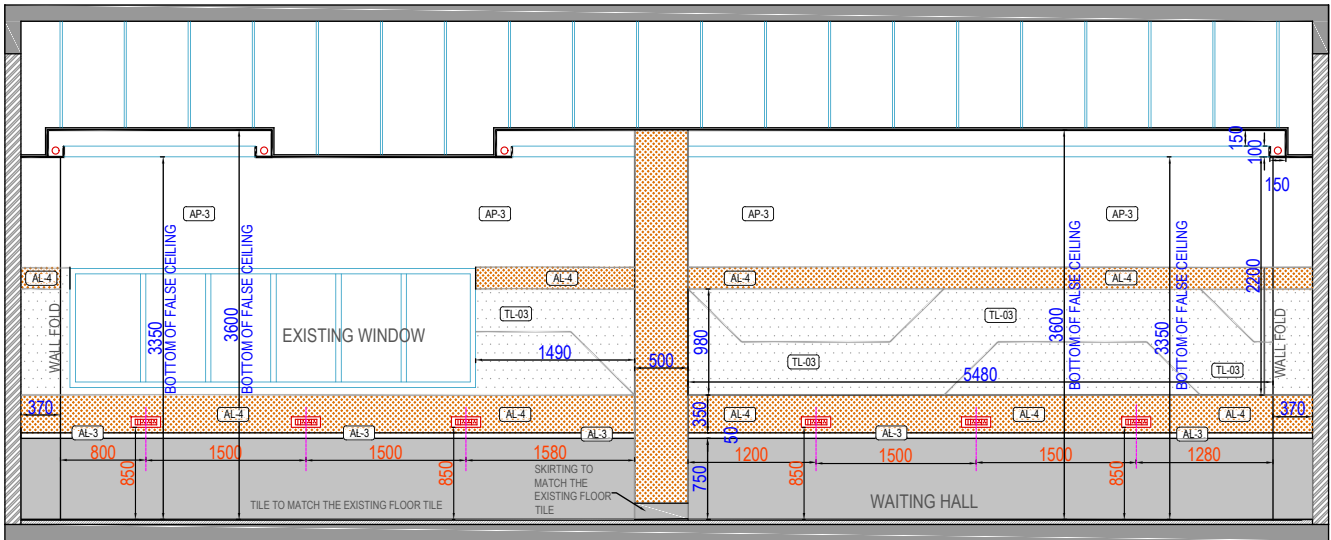

03 WALL ELEVATION C
1:50

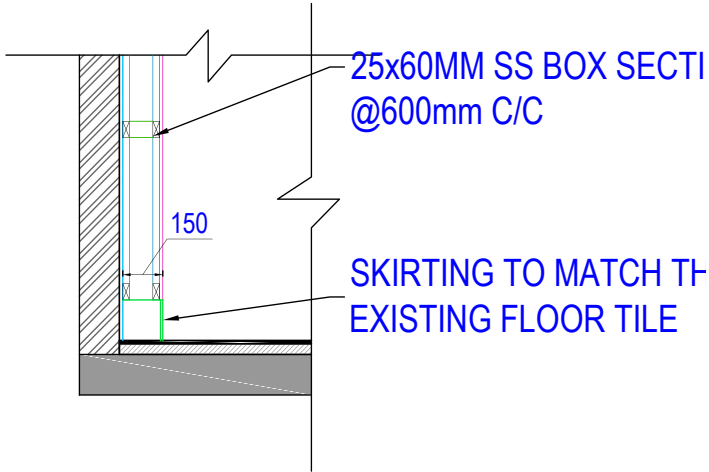

07 DETAIL C
1:30

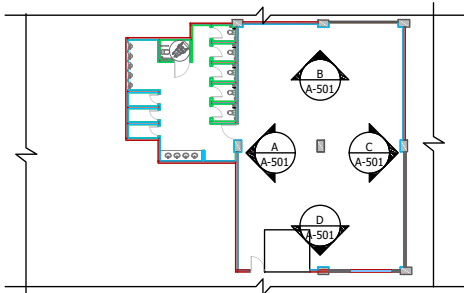

08 KEY PLAN

LEGEND		
TL-01 - 600 X 1200	BLACK TILE	
TL-02 - 600 X 1200	WHITE TILE	
TL-03 - 600 X 1200	GREY TILE	

PAINT FINISHES	
A-P1	AGATE GREY (RAL 7038)- DULUXE
A-P2	SIGNAL WHITE DULUX- RAL 9003-
A-P3	BLUEWEED -9232

LAMINATE		
CODE	COLOUR	MAKE
A-L1	WHITE	CF-132 ROYAL TOUCHE
A-L2	SLATE GREY	CF-184 ROYAL TOUCHE
A-L3	MATT BLACK	CF-106 ROYAL TOUCHE
A-L4	RURAL OAK	CF-489 ROYAL TOUCHE

12x12MM SS CORNER GUARD/ TILE STRIPS
FIXED FINISHED IN POLISHED GOLD

DESIGN SYNC COLLABORATIVE
DESIGN SYNC CONSULTING & ADVISORY PVT LTD
BRIGADE METROPOLIS WHITEFIELD ROAD

080:25350922
studio@designsync.in
www.designsync.in


WAITING HALL SBC STATION KARNATAKA

STAGE	PURPOSE
☐ F EASIBILITY	☐ T ENDER REVIEW
☒ D ESIGN	☒ C O-ORDINATION
☐ C ONSTRUCTION	☐ E XECUTION



TITLE
GENTS WAITING HALL
WALL ELEVATIONS


DRAWING NUMBER	SCALE	ISSUED	VERSION
A-501	1:15	02 MAR 2023	R0

07

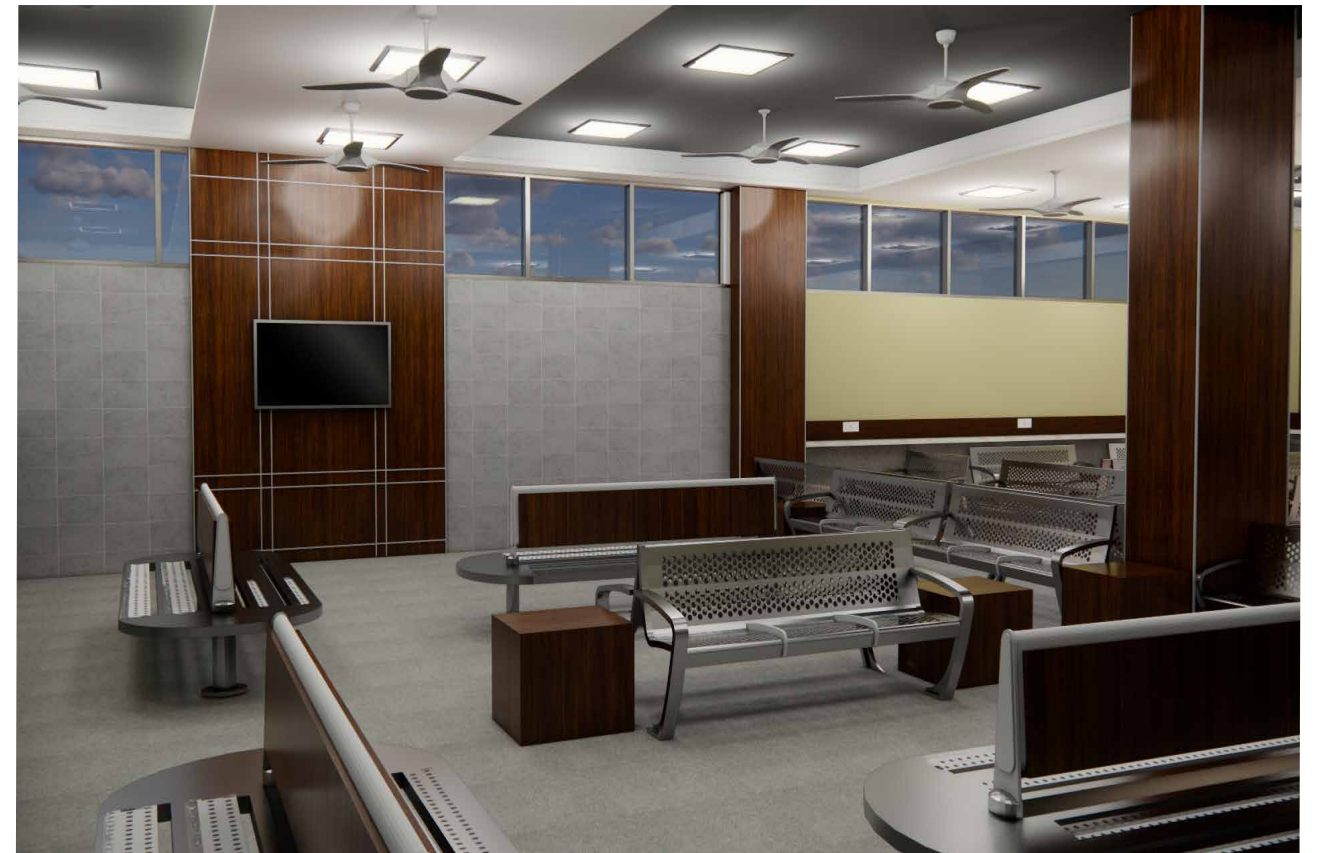

SBC STATION
GENTS WAITING HALL

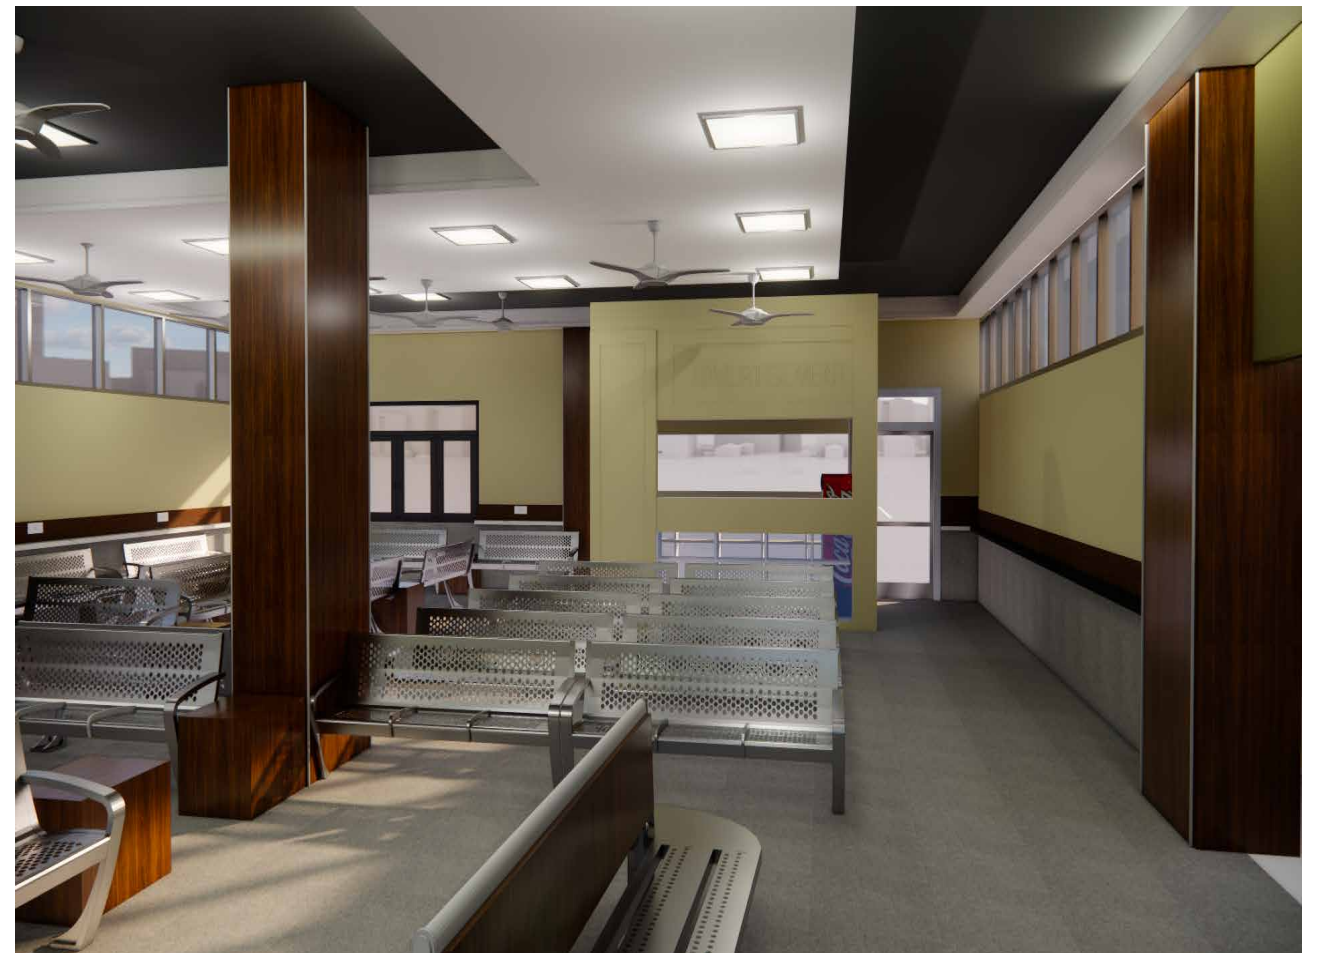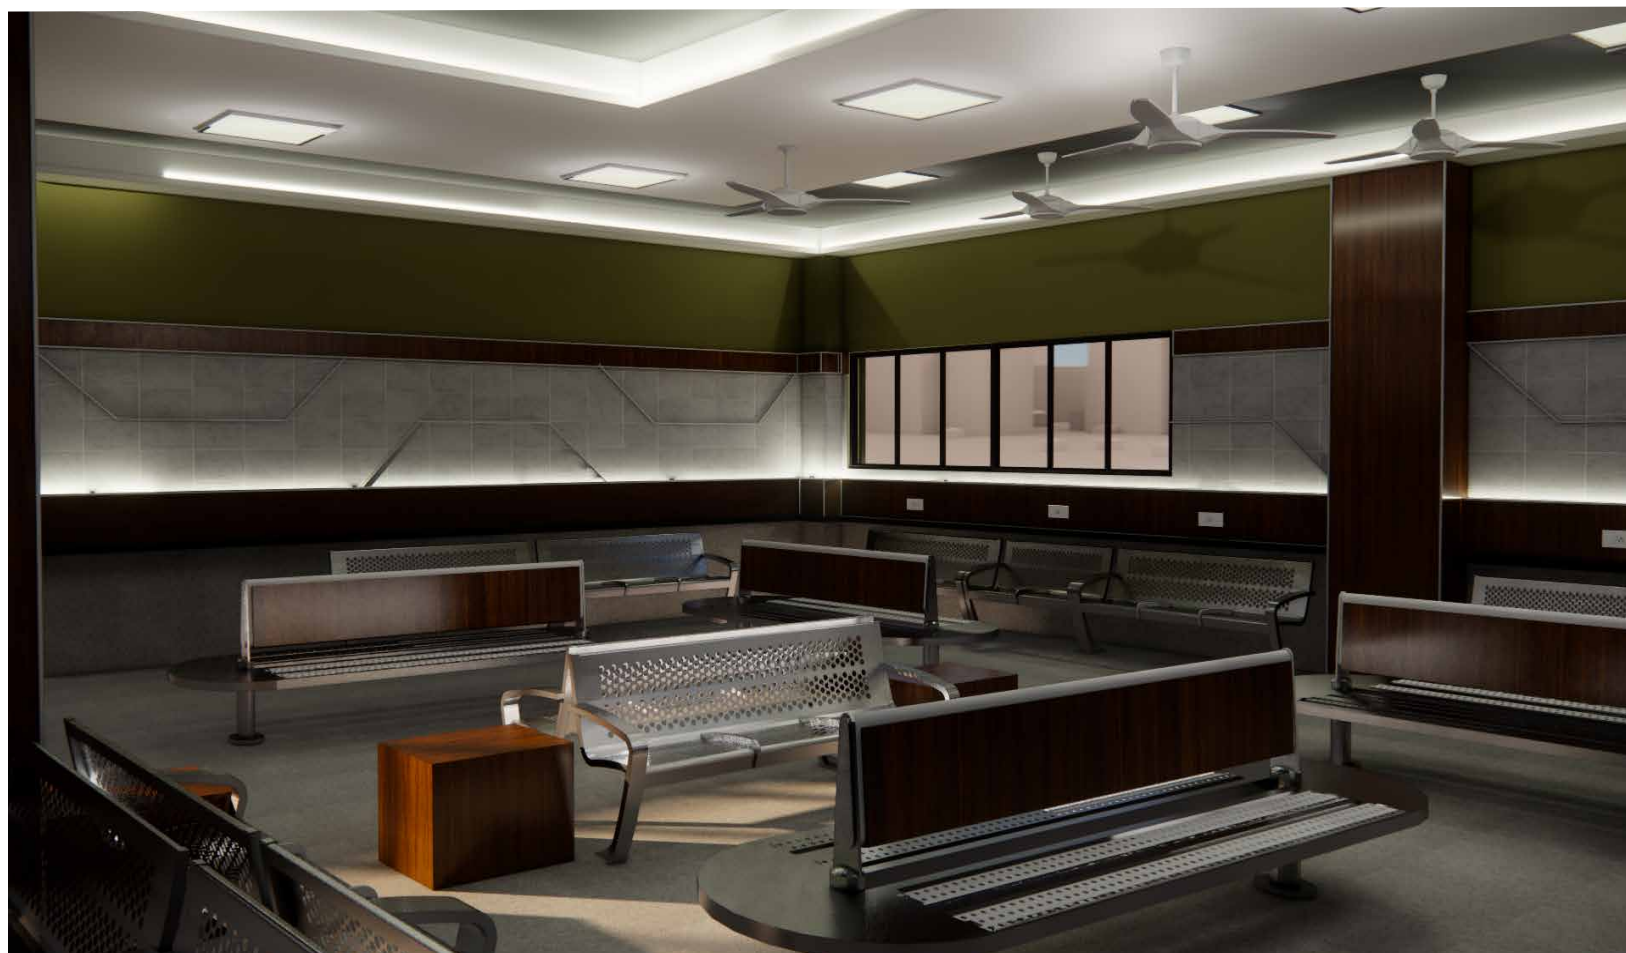

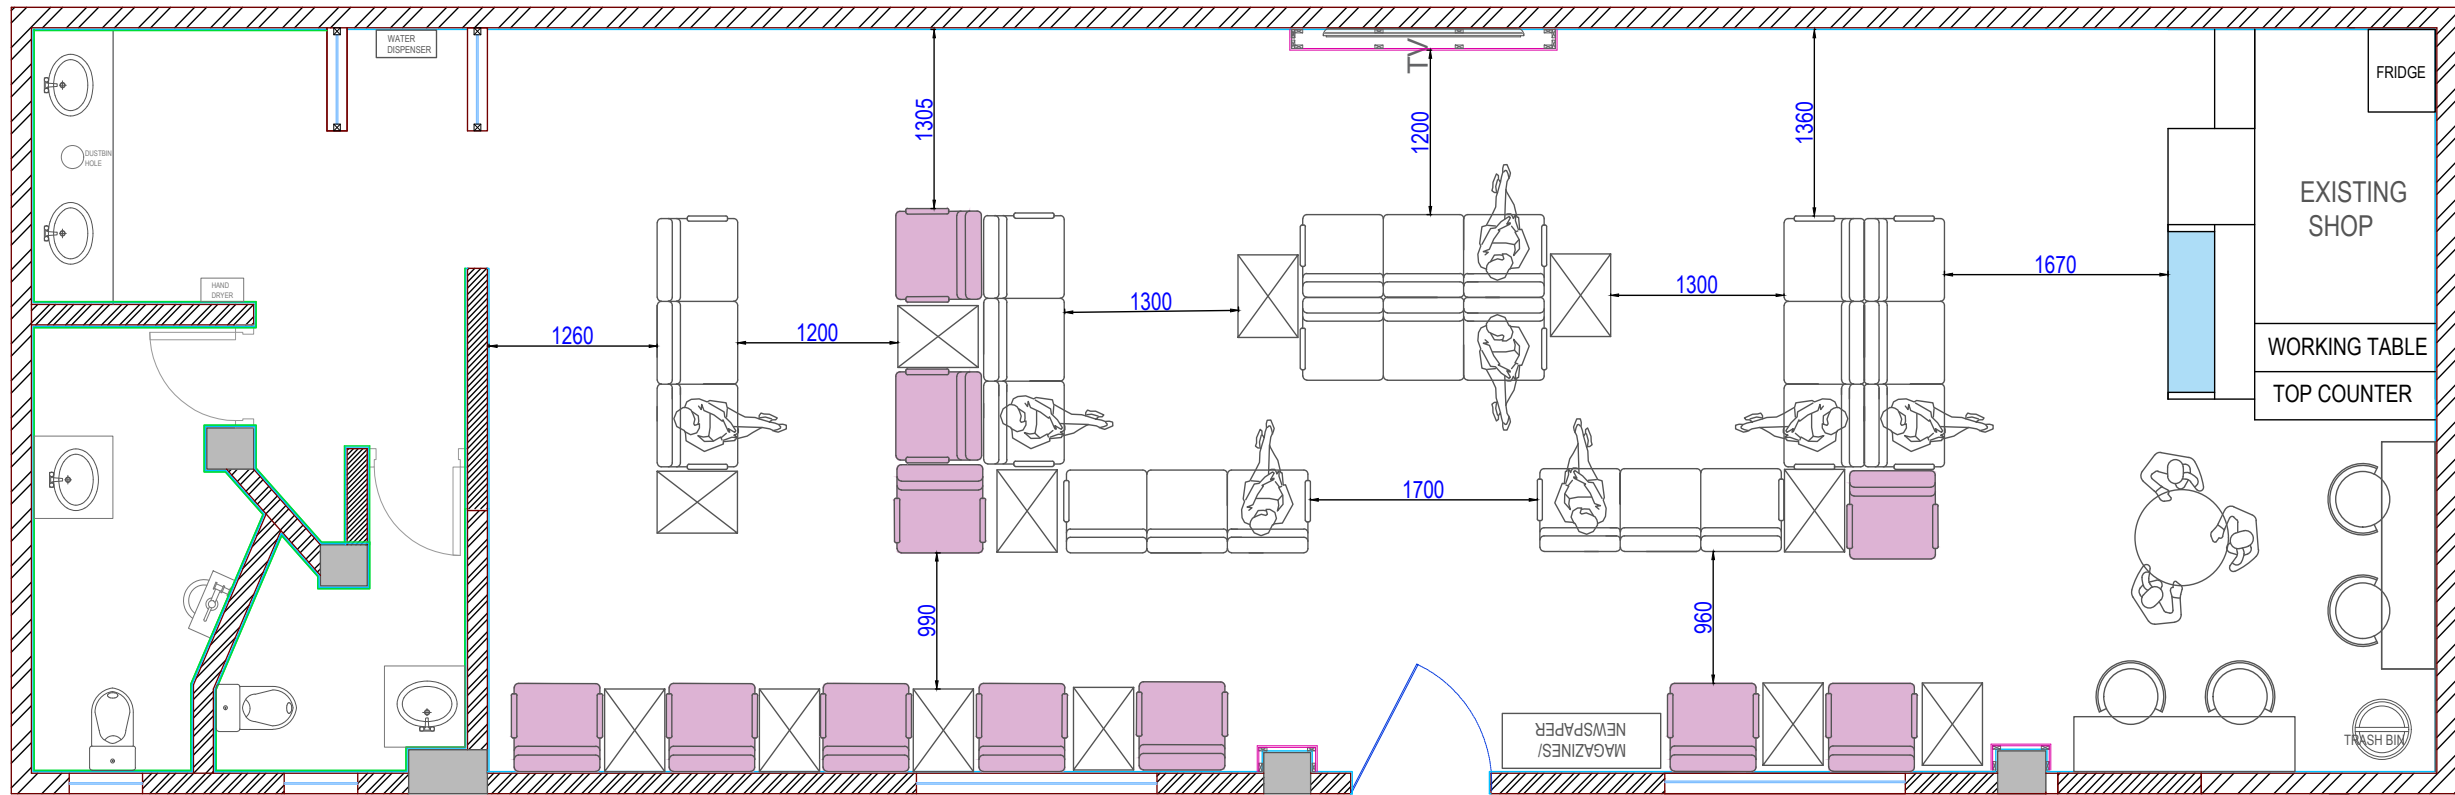

LEGEND	
	3 SEATER
	1 SEATER
	CHARGING UNIT JUNCTION BOX
	HIGH RISE SEATINGS
	STAINLESS ROUND TABLE

AC WAITING HALL OPTION 1 - 35

DESIGN SYNC COLLABORATIVE
DESIGN SYNC CONSULTING & ADVISORY PVT LTD
BRIGADE METROPOLIS WHITEFIELD ROAD

080:25350922
studio@designsync.in
www.designsync.in

AC WAITING HALL-PLATFORM 1
KARNATAKA


STAGE	PURPOSE
☐ F EASIBILITY	☐ T ENDER REVIEW
☒ D ESIGN	☒ C O-ORDINATION
☐ C ONSTRUCTION	☐ E XECUTION

TITLE
AC WAITING HALL
GENERAL ARRANGEMENT

DRAWING NUMBER SCALE ISSUED
A-300 1:50 15 FEB 2023


VERSION
R0

01

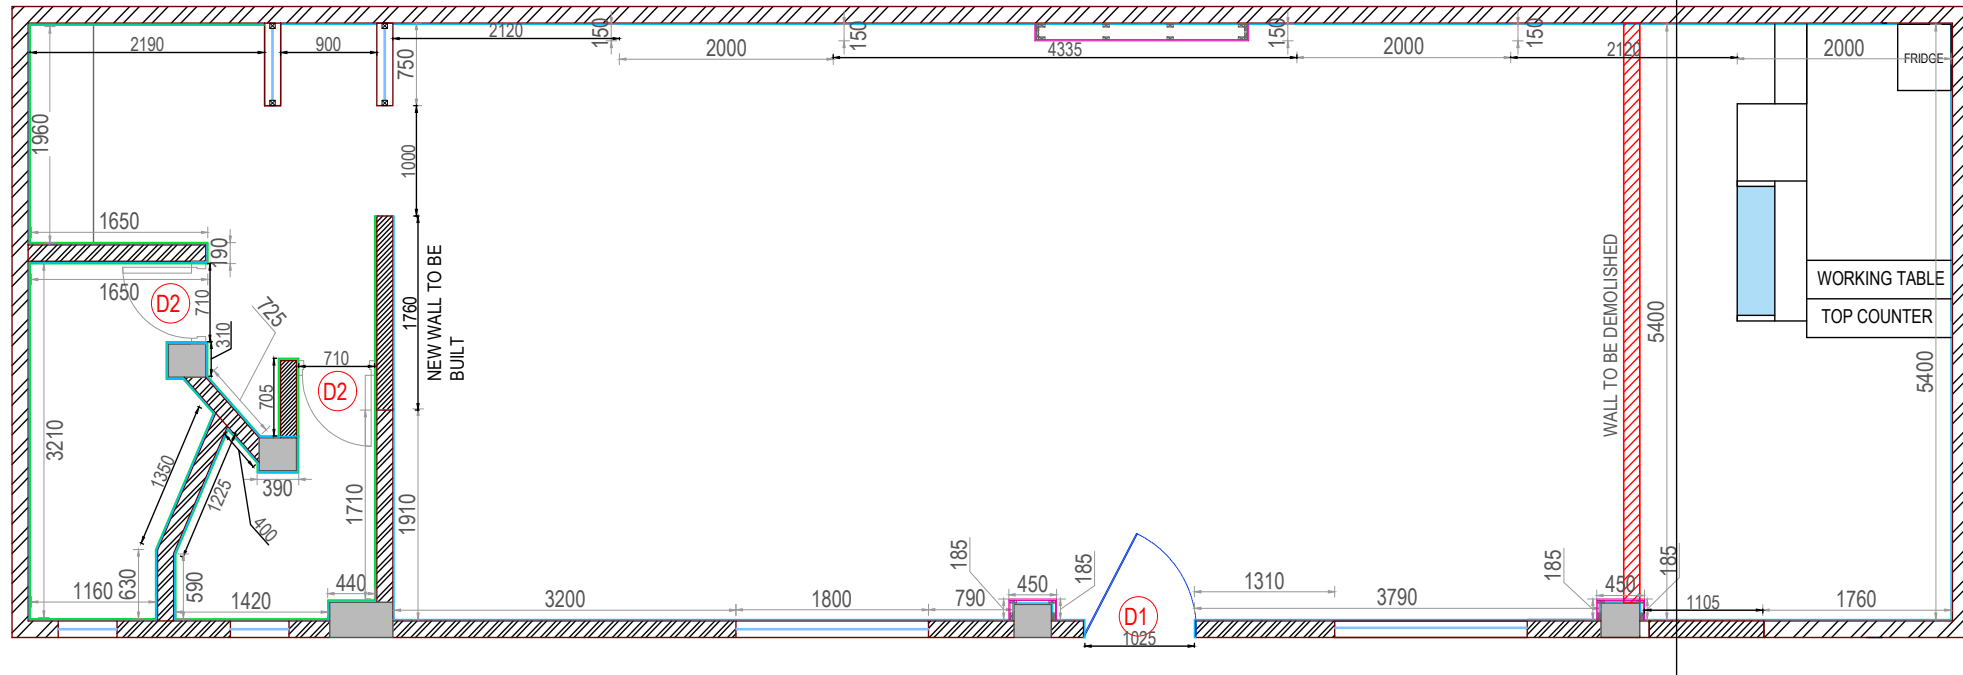

1 CIVIL LAYOUT

Scale: 1:50

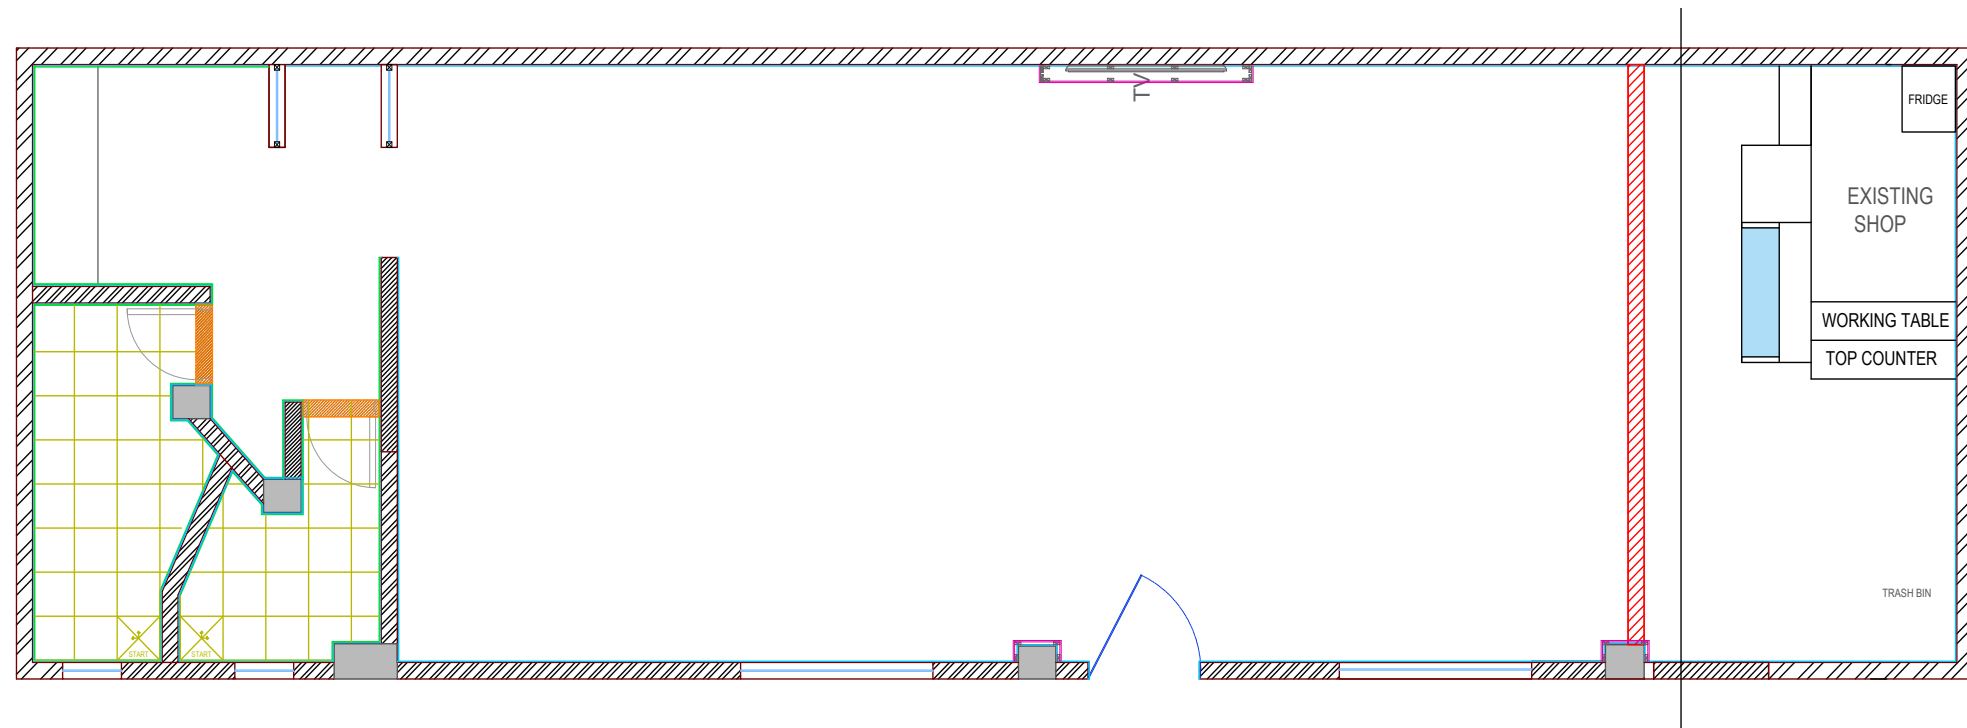


2 FLOORING LAYOUT

Scale: 1:50

LEGEND	
	EXISTING WALL
	NEW WALL
	DEMOLITION WALL

	ENTRY DOOR 1025MM
	TOILET DOOR 710MM

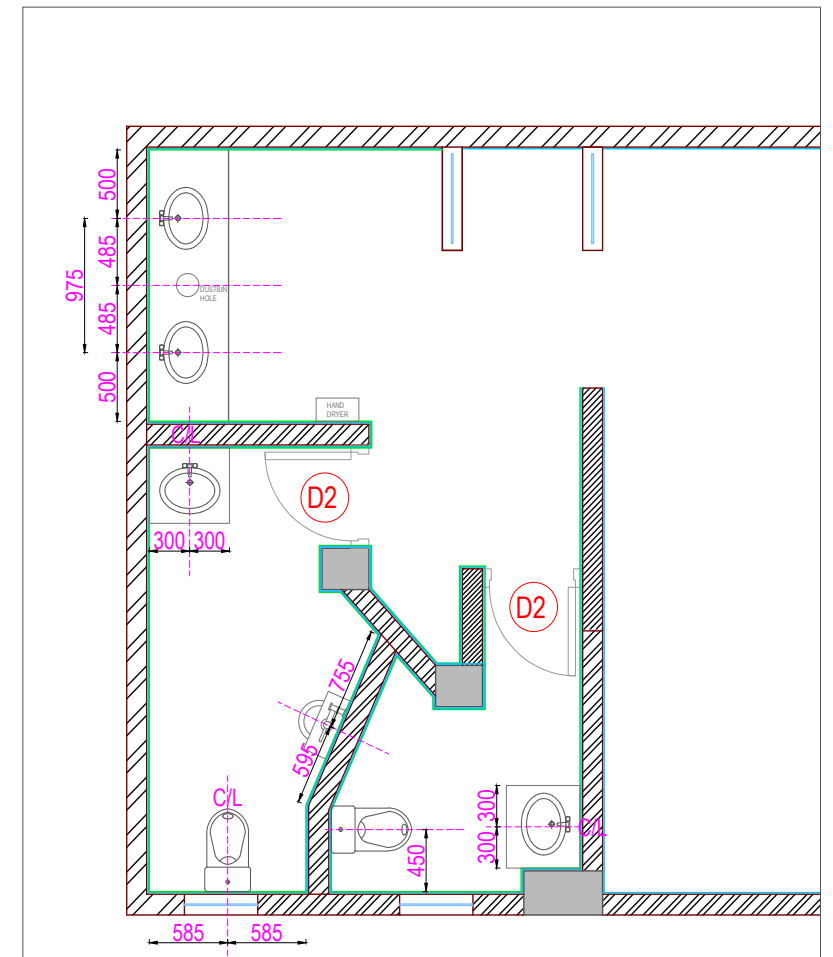

3 TOILET FIXTURE ALIGNMENT LAYOUT

Scale: 1:40

DESIGN SYNC COLLABORATIVE
DESIGN SYNC CONSULTING & ADVISORY PVT LTD
BRIGADE METROPOLIS WHITEFIELD ROAD

080:25350922
studio@designsync.in
www.designsync.in

AC WAITING HALL-PLATFORM 1
KARNATAKA


STAGE	PURPOSE
☐ F EASIBILITY	☐ T ENDER REVIEW
☒ D EIGN	☒ C O-ORDINATION
☐ C ONSTRUCTION	☐ E XECUTION

TITLE
AC WAITING HALL
CIVIL LAYOUT

DRAWING NUMBER SCALE ISSUED
A-301 NDS 20 FEB 2023


VERSION
R0

02

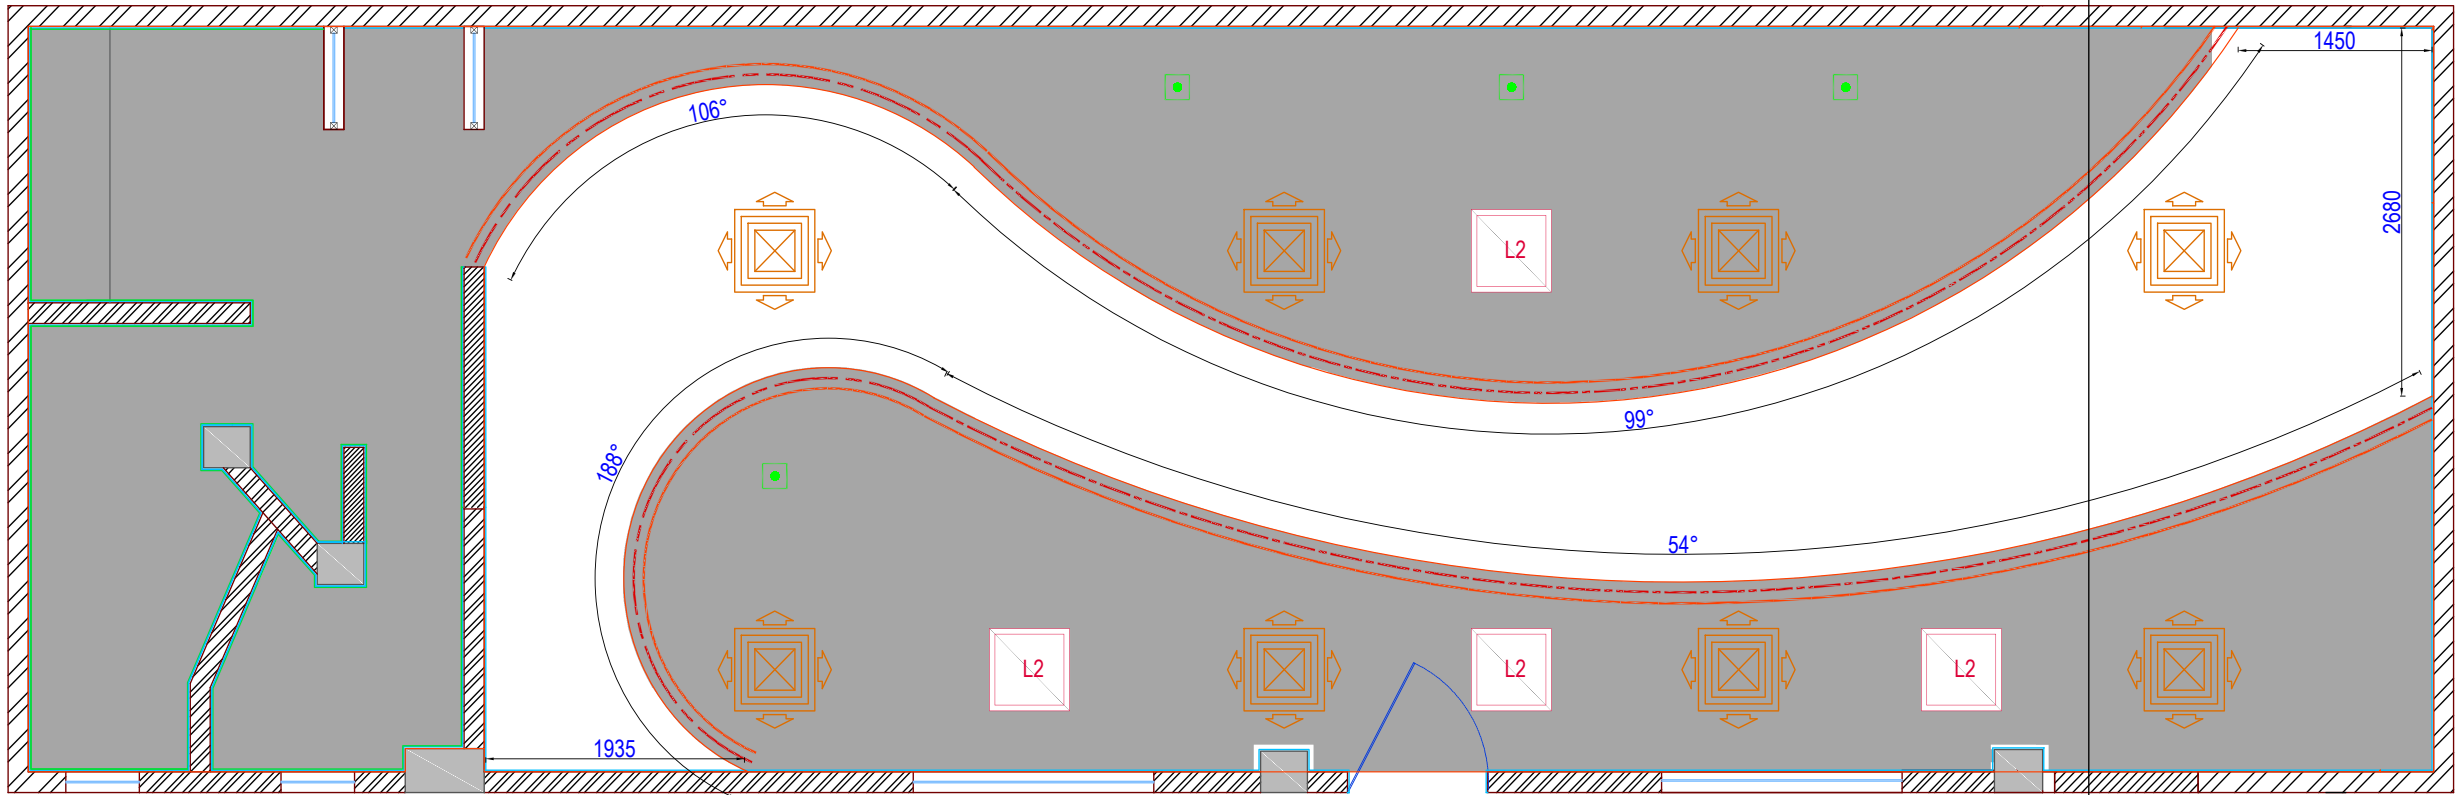

PAINT FINISHES		
A-P1	AGATE GREY (RAL 7038)- DULUXE	LUSTRE
A-P2	SIGNAL WHITE DULUX- RAL 9003-	LUSTRE

- GYPSUM FALSE CEILING FINISHED IN AP-2
- GYPSUM FALSE CEILING FINISHED IN AP-1
- GYPSUM VERTICAL BULKHEAD FINISHED IN AP-2
- COVE LIGHT
- 32W LED LIGHT FIXTURE
- LED DOWNLIGHT FIXTURE

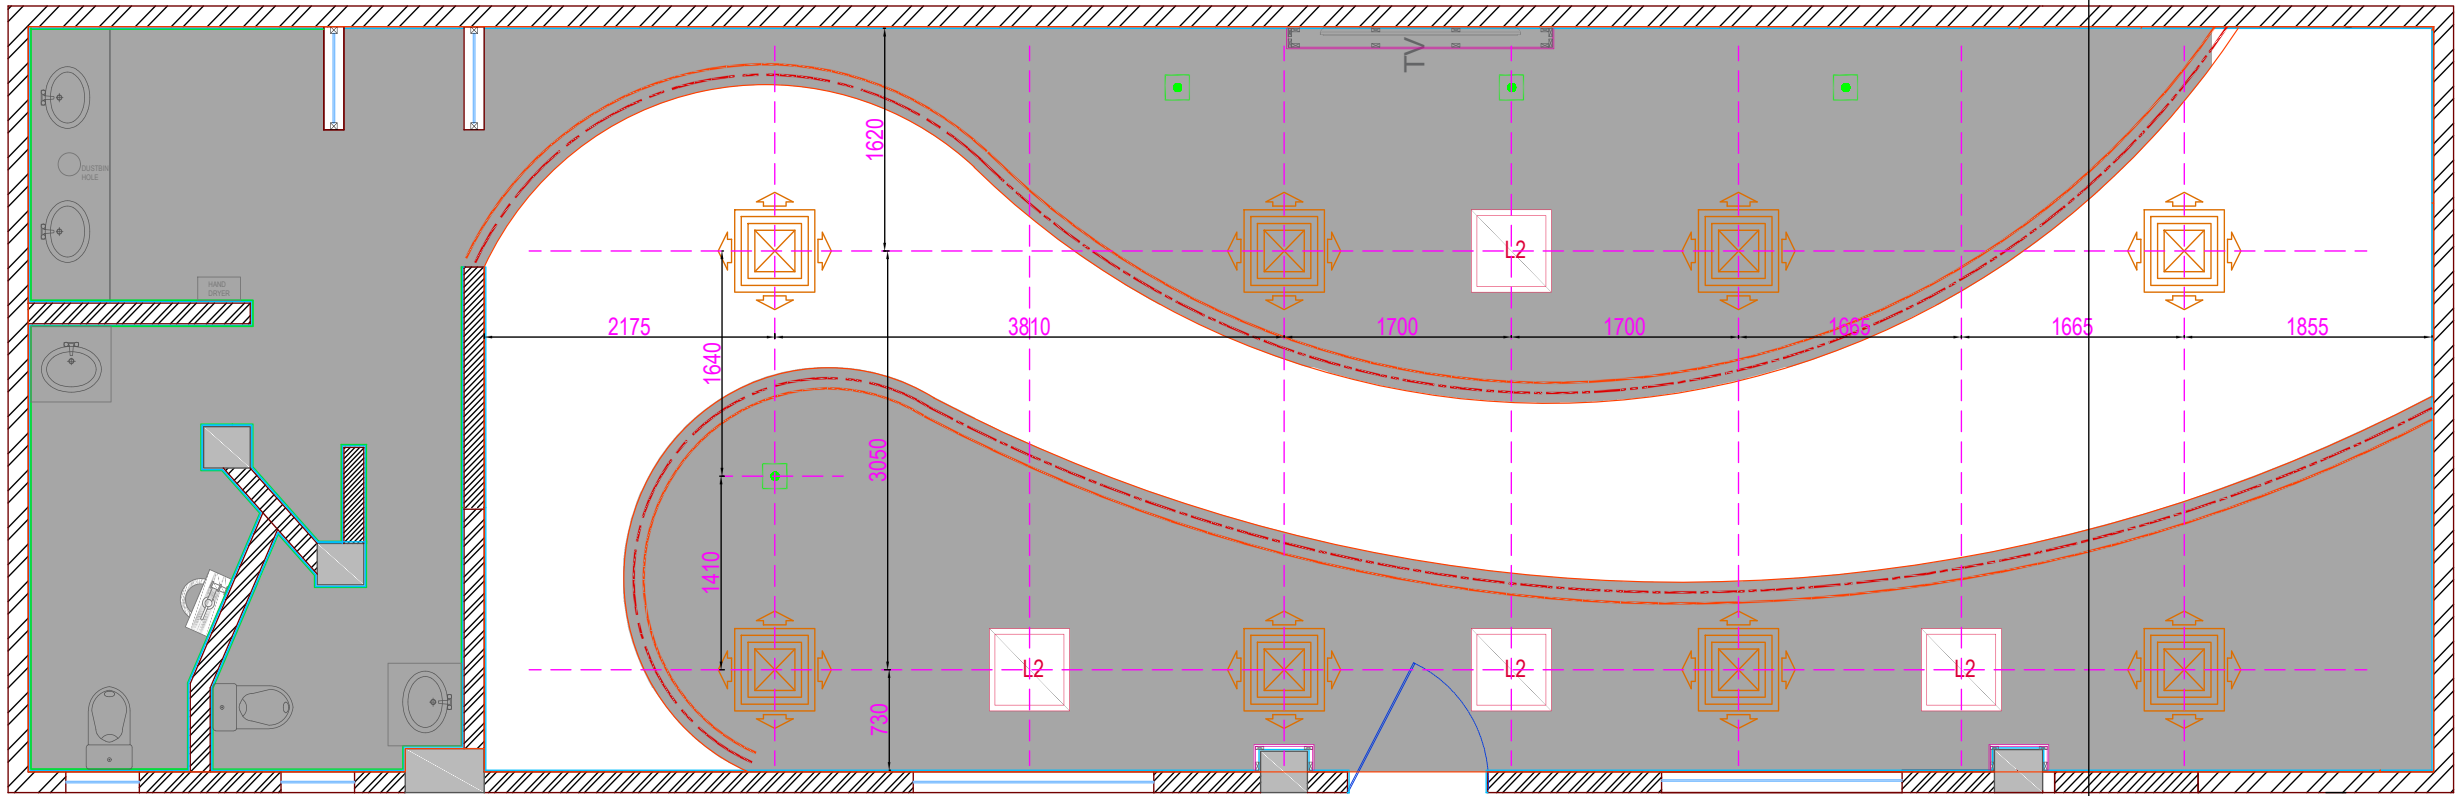

DESIGN SYNC COLLABORATIVE
DESIGN SYNC CONSULTING & ADVISORY PVT LTD
BRIGADE METROPOLIS WHITEFIELD ROAD

080:25350922
studio@designsync.in
www.designsync.in

AC WAITING HALL-PLATFORM 1





KARNATAKA

STAGE	PURPOSE
☐ F EASIBILITY	☐ T ENDER REVIEW
☒ D ESIGN	☒ C O-ORDINATION
☐ C ONSTRUCTION	☐ E XECUTION

TITLE
AC WAITING HALL
FALSE CEILING AND LIGHTING LAYOUT


DRAWING NUMBER	SCALE	ISSUED	VERSION
A-302	1:40	15 FEB 2023	R0

03

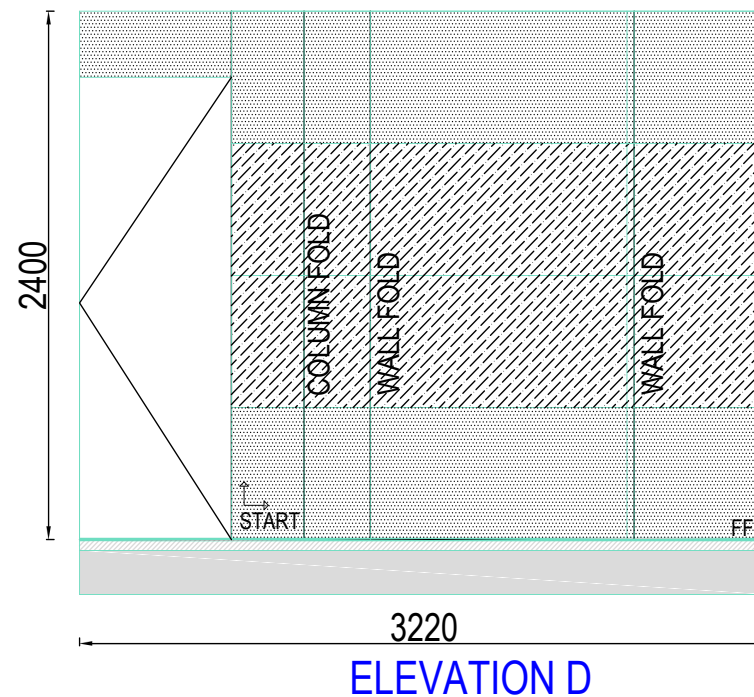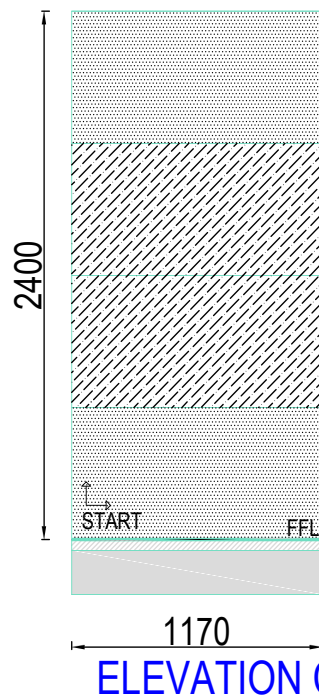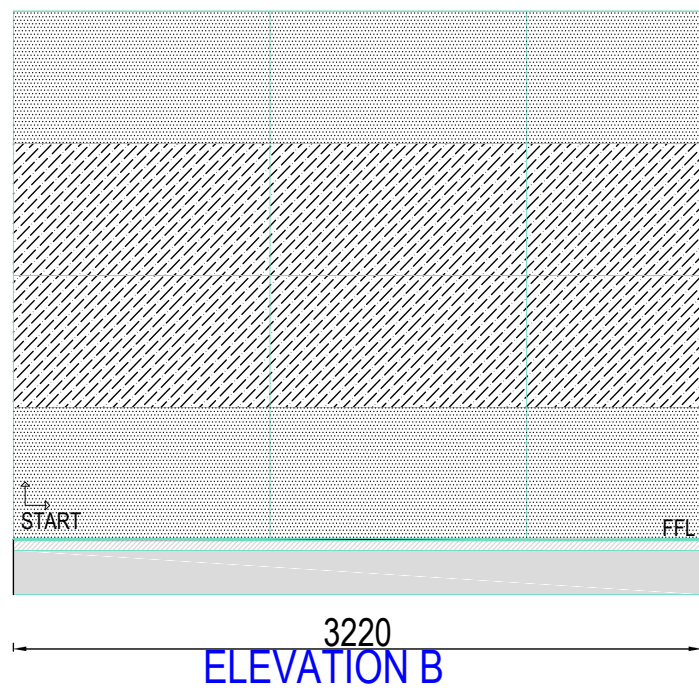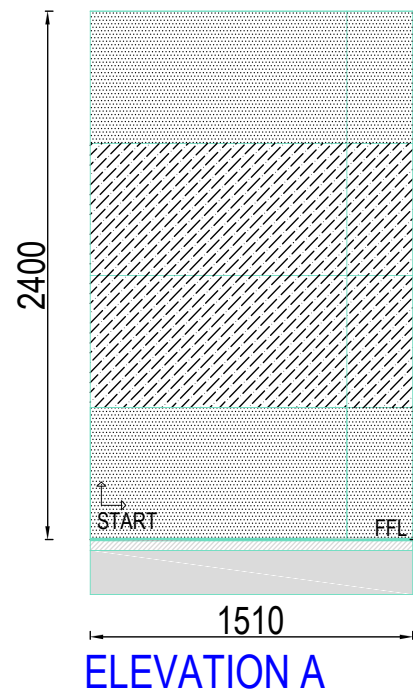





1 TOILET BLOCK WALL ELEVATION

Scale: 1:25

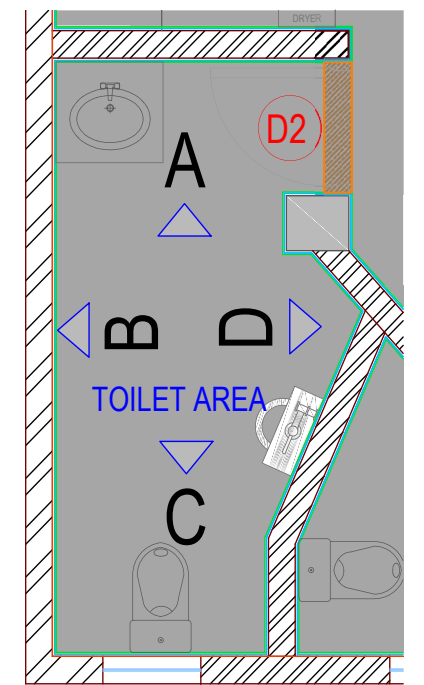


1 TOILET BLOCK PLAN

Scale: 1:30

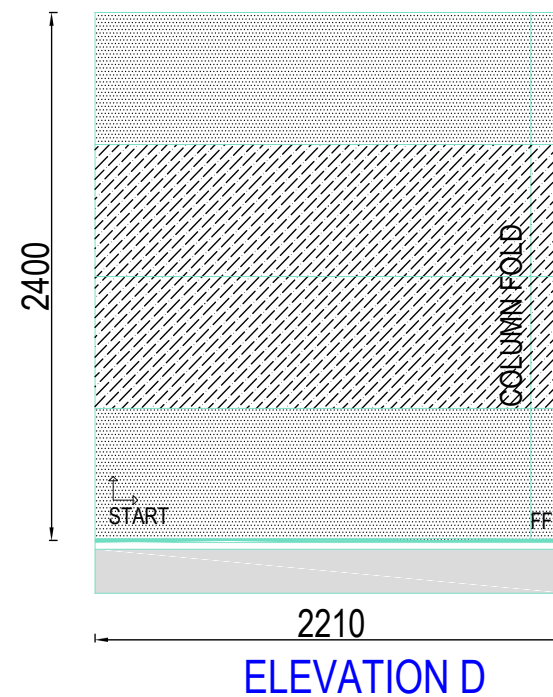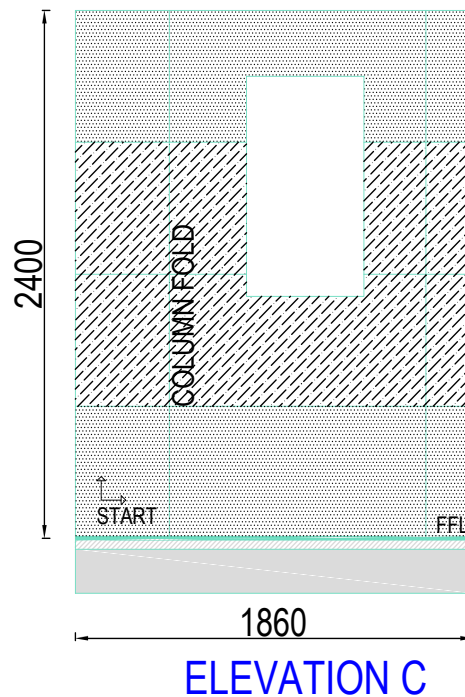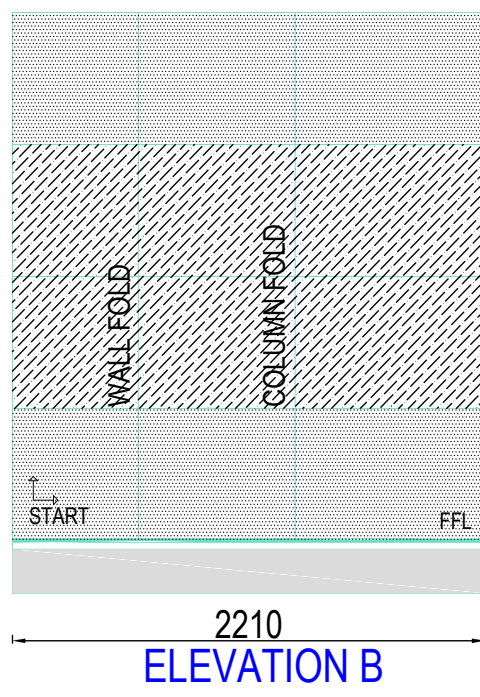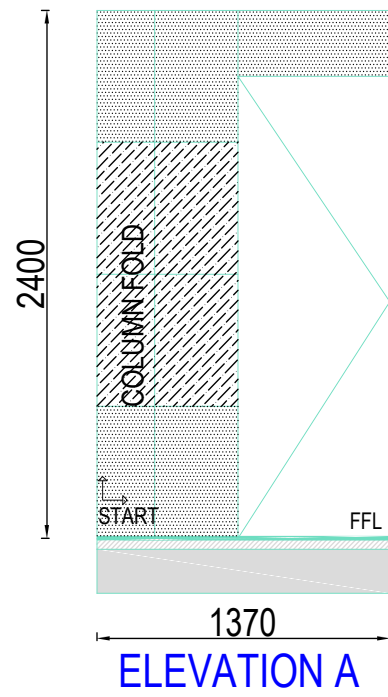

2 TOILET BLOCK WALL ELEVATION

Scale: 1:25

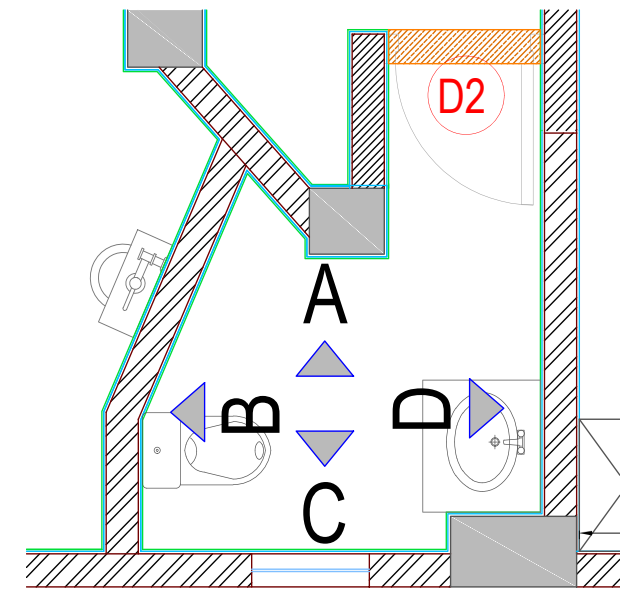

2 TOILET BLOCK PLAN

Scale: 1:25

DESIGN SYNC COLLABORATIVE
DESIGN SYNC CONSULTING & ADVISORY PVT LTD
BRIGADE METROPOLIS WHITEFIELD ROAD

080:25350922
studio@designsync.in
www.designsync.in

AC WAITING HALL-PLATFORM 1
KARNATAKA

STAGE
☐ F EASIBILITY
☒ D ESIGN
☐ C ONSTRUCTION


PURPOSE
☐ T ENDER REVIEW
☒ C O-ORDINATION
☐ E XECUTION

TITLE
AC WAITING HALL
TOILET ELEVATIONS


DRAWING NUMBER SCALE ISSUED
A-303 NDS 20 FEB 2023

VERSION
R1


04

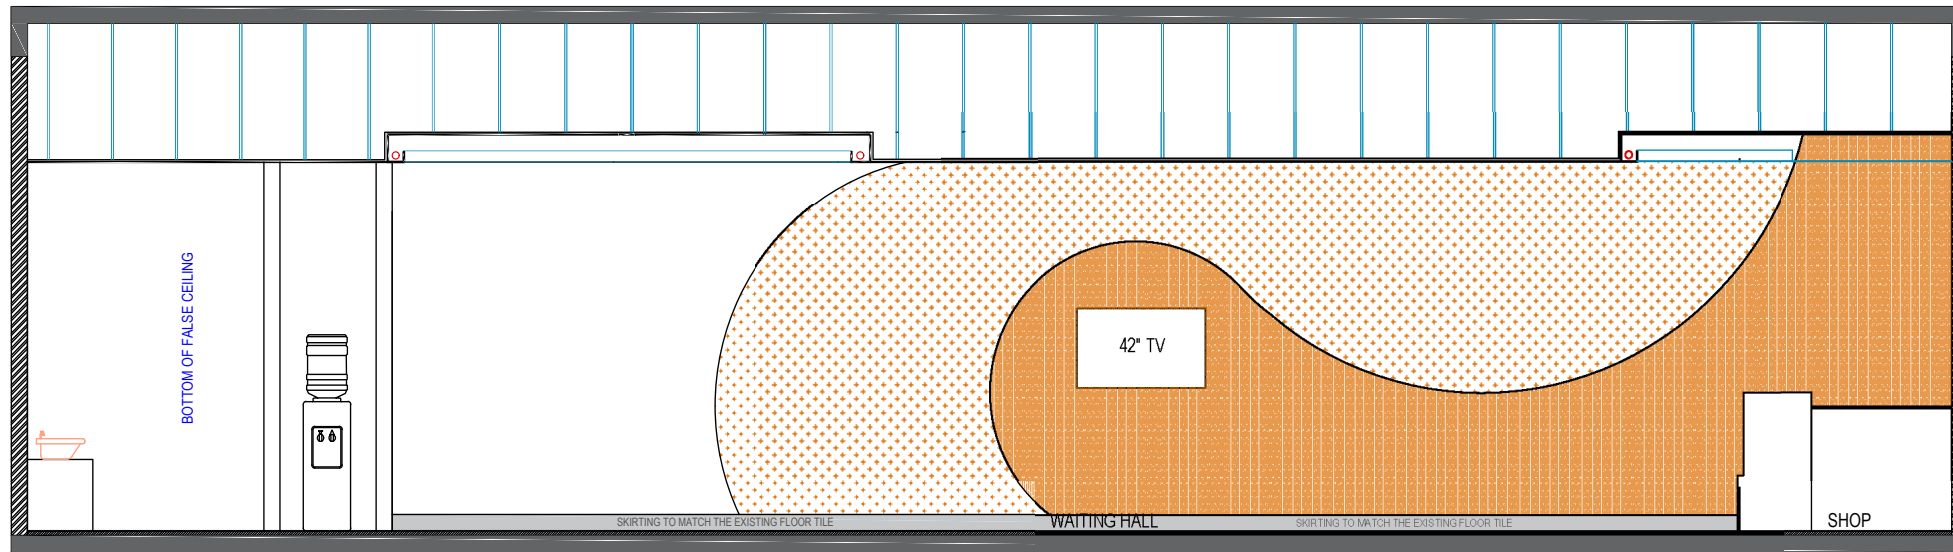

01 WALL ELEVATION A
1:50

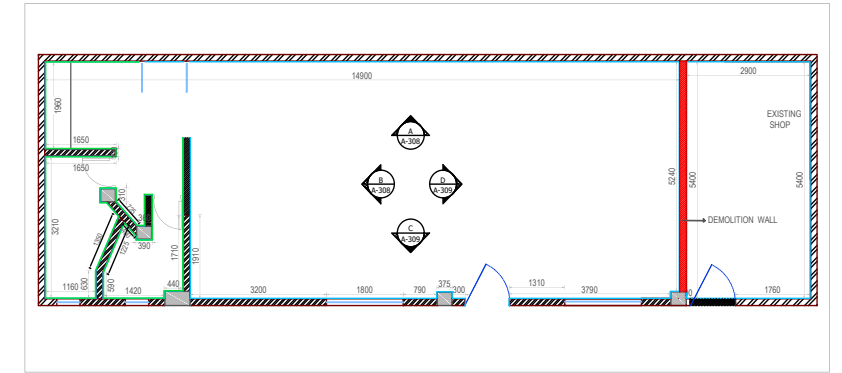

05 KEY PLAN

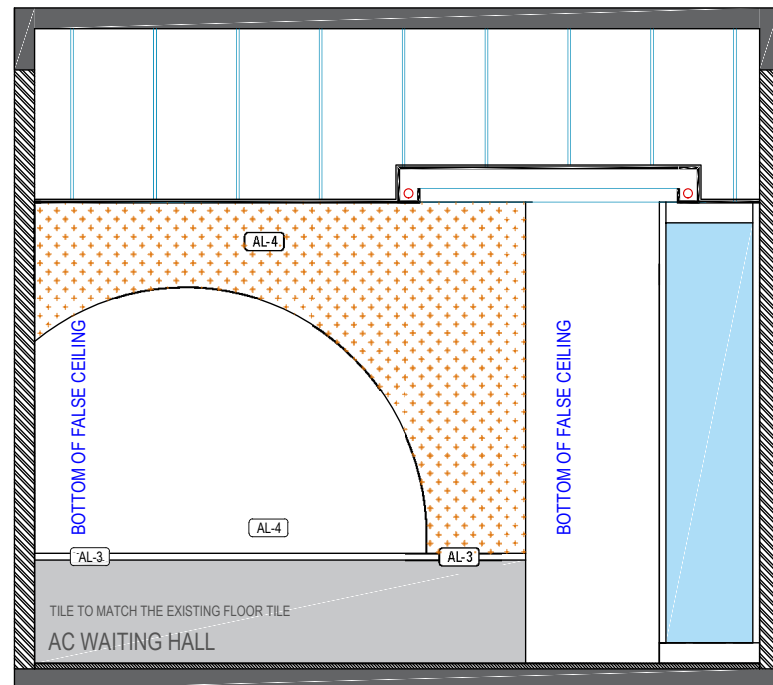


02 WALL ELEVATION B
1:40

GYPSUM CEILING FINISHED IN
AP-1 @3600MM FROM FFL

COVE LIGHT

GYPSUM CEILING FINISHED IN
AP-2 @3350MM FROM FFL

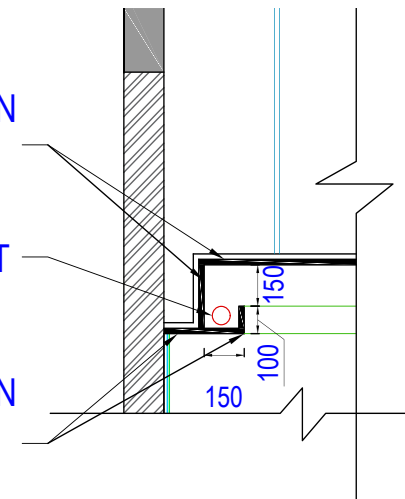

03 TYPICAL COVE DETAIL
1:20

PAINT FINISHES

A-P1	AGATE GREY (RAL 7038)- DULUXE	LUSTRE
A-P2	SIGNAL WHITE DULUX- RAL 9003-	LUSTRE

LAMINATE

CODE	COLOUR	MAKE
A-L1	WHITE	CF-132 ROYAL TOUCHE
A-L2	SLATE GREY	CF-184 ROYAL TOUCHE
A-L3	MATT BLACK	CF-106 ROYAL TOUCHE
A-L4	RURAL OAK	CF-489 ROYAL TOUCHE

12x12MM SS CORNER GUARD/ TILE STRIPS
FIXED FINISHED IN POLISHED GOLD

AF-1 BLUE LEATHER

DESIGN SYNC COLLABORATIVE
DESIGN SYNC CONSULTING & ADVISORY PVT LTD
BRIGADE METROPOLIS WHITEFIELD ROAD

080:25350922
studio@designsync.in
www.designsync.in

AC WAITING HALL-PLATFORM 1 KARNATAKA

STAGE
☐ F EASIBILITY
☒ D ESIGN
☐ C ONSTRUCTION

PURPOSE
☐ T ENDER REVIEW
☒ C O-ORDINATION
☐ E XECUTION

TITLE
AC WAITING HALL
WALL ELEVATIONS

DRAWING NUMBER SCALE ISSUED
A-304 NDS 20 FEB 2023

VERSION
R1

05




LAMINATE		
CODE	COLOUR	MAKE
A-L1	WHITE	CF-132 ROYAL TOUCHE
A-L2	SLATE GREY	CF-184 ROYAL TOUCHE
A-L3	MATT BLACK	CF-106 ROYAL TOUCHE
A-L4	RURAL OAK	CF-489 ROYAL TOUCHE

 12x12MM SS CORNER GUARD/ TILE STRIPS
FIXED FINISHED IN POLISHED GOLD




AC WAITING HALL

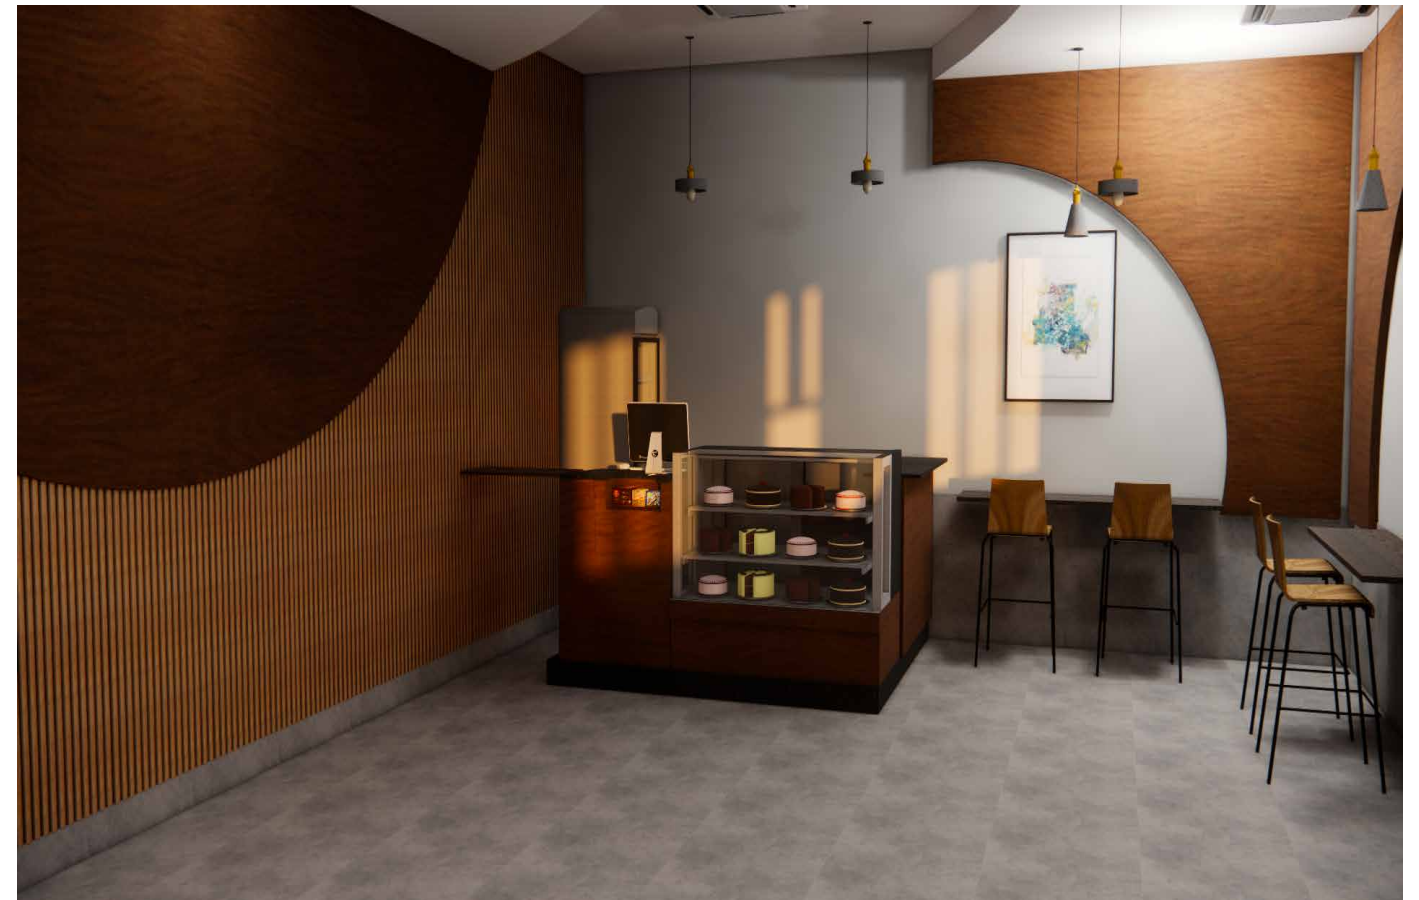




BELGAUM **McDONALDS** STORE




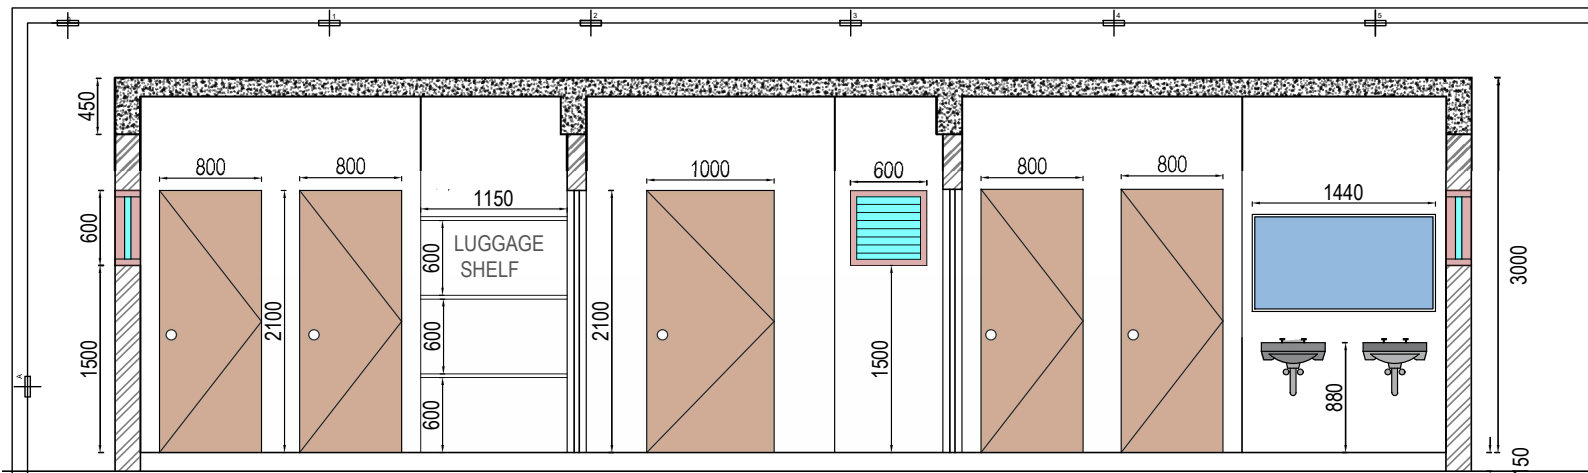


SECTION A

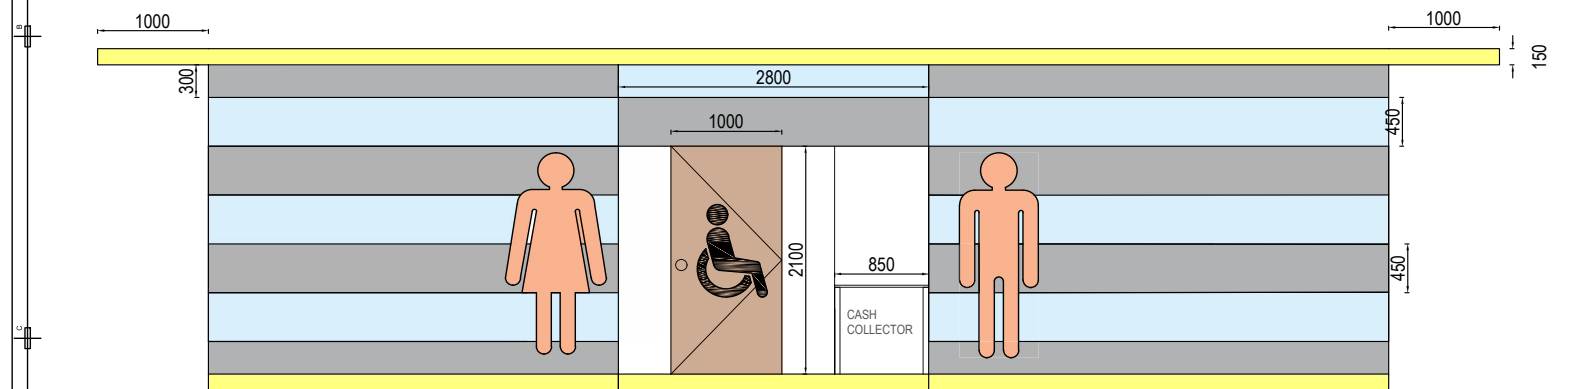


FRONT ELEVATION

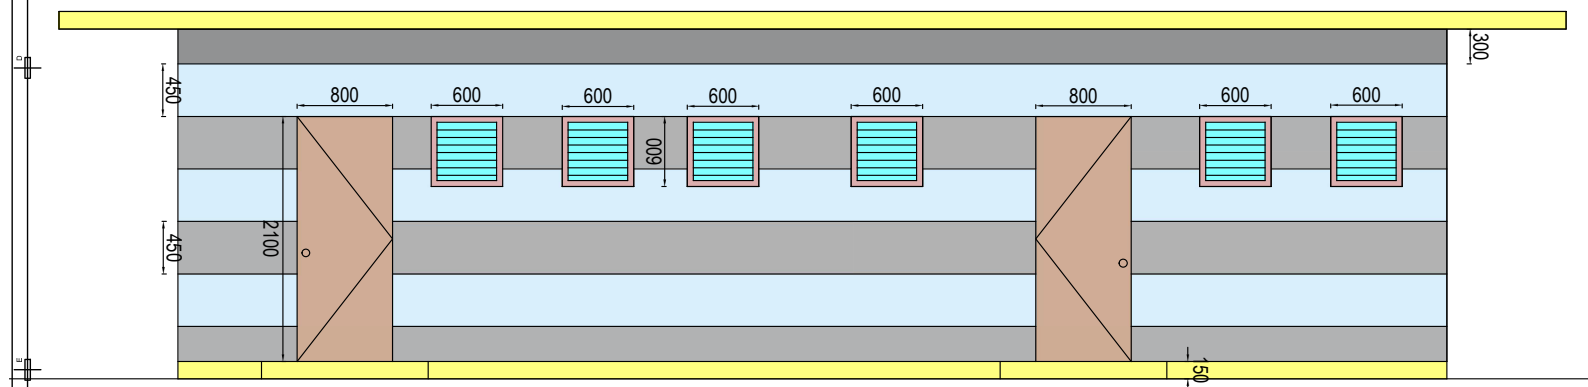

SOUTH ELEVATION

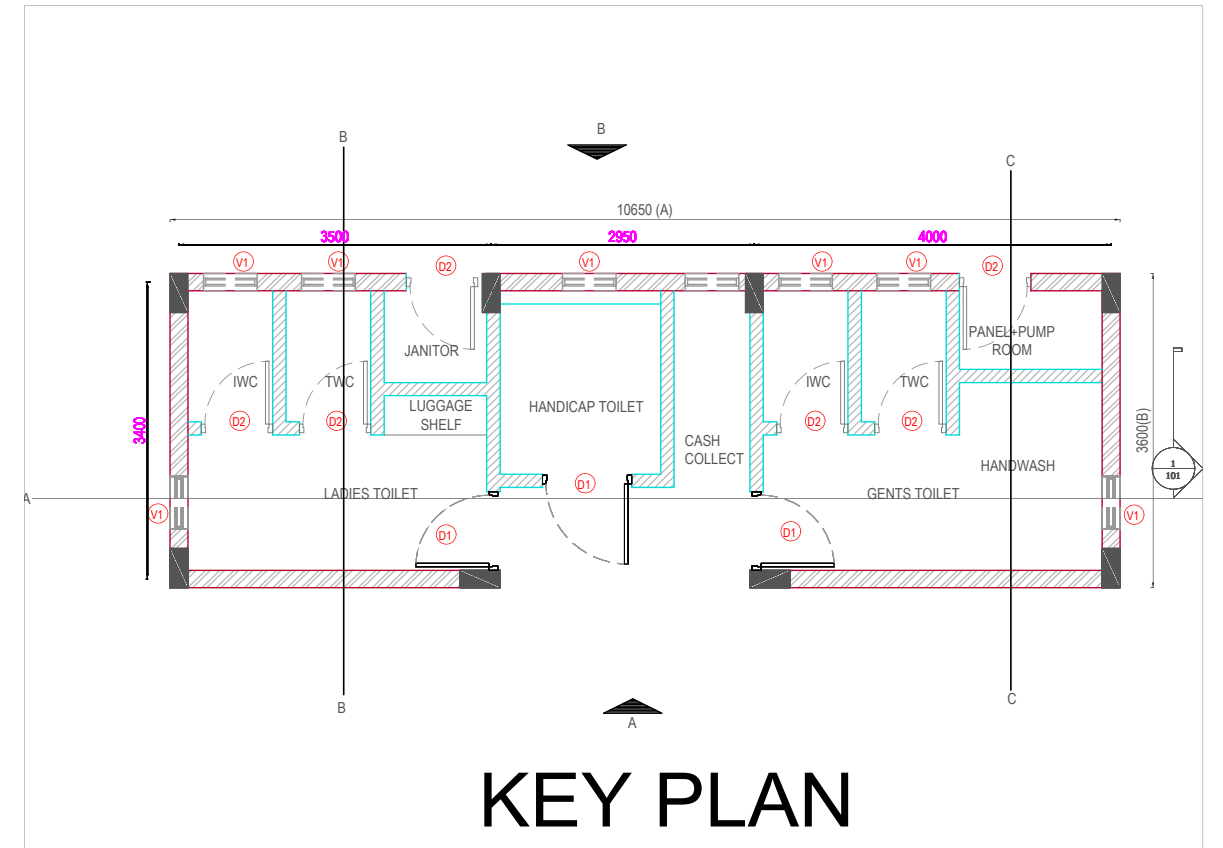

KEY PLAN

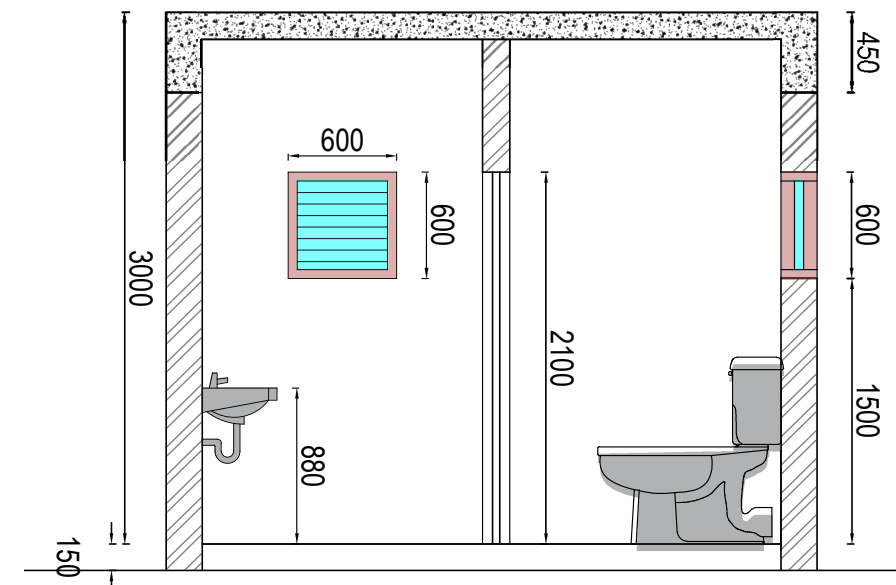

SECTION B

DESIGN SYNC COLLABORATIVE
DESIGN SYNC CONSULTING & ADVISORY PVT LTD
BRIGADE METROPOLIS WHITEFIELD ROAD

studio@designsync.in
www.designsync.in

SBC SECOND ENTRY
SWR - BLR - DIVISION

KARNATAKA


STAGE
☐ F EASIBILITY
☒ D ESIGN
☐ C ONSTRUCTION

PURPOSE
☐ T ENDER REVIEW
☒ C O-ORDINATION
☐ E XECUTION

TITLE
SBC SECOND ENTRY
TOILET BLOCK


DRAWING NUMBER SCALE ISSUED VERSION
A-101 1:25 22 NOV 2022 R0

01

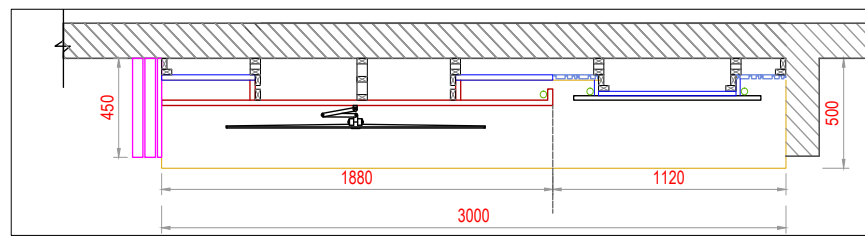


02 PLAN

Scale: 1:25

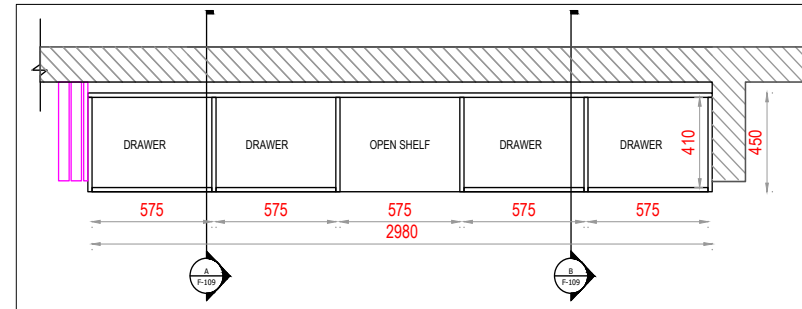


03 PLAN

Scale: 1:25

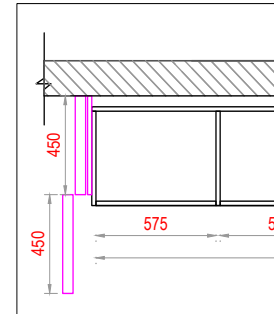


04 PLAN

Scale: 1:25

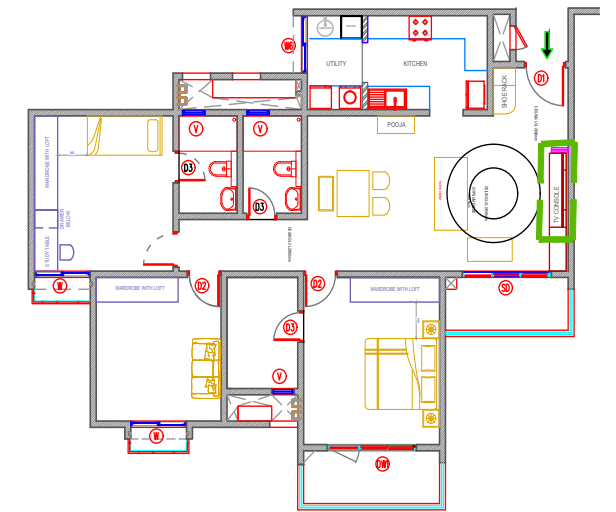


01 KEY PLAN

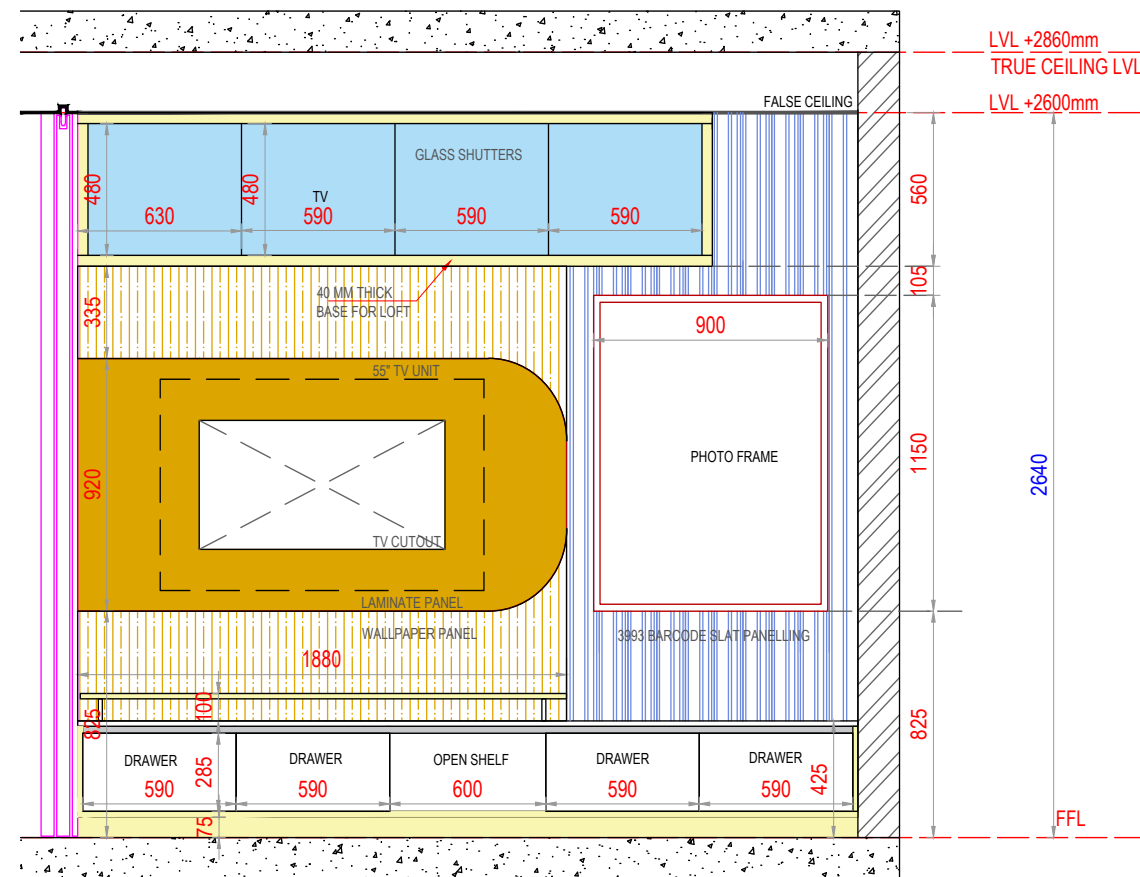


05 ELEVATION

Scale: 1:20

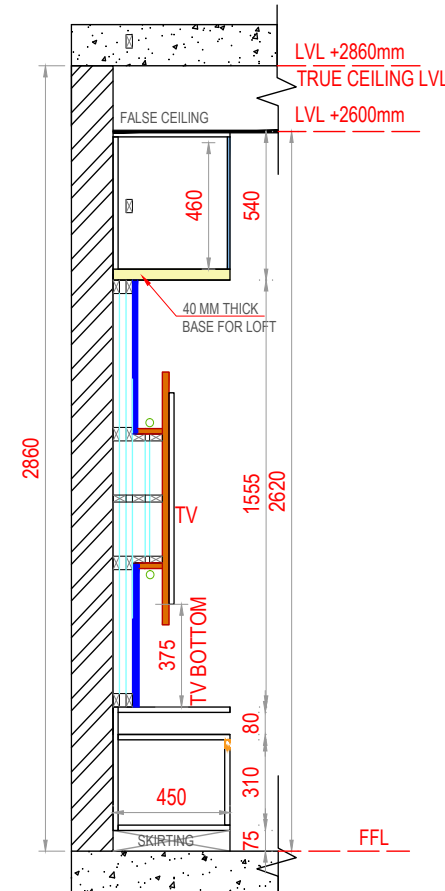


06 SECTION A

Scale: 1:20

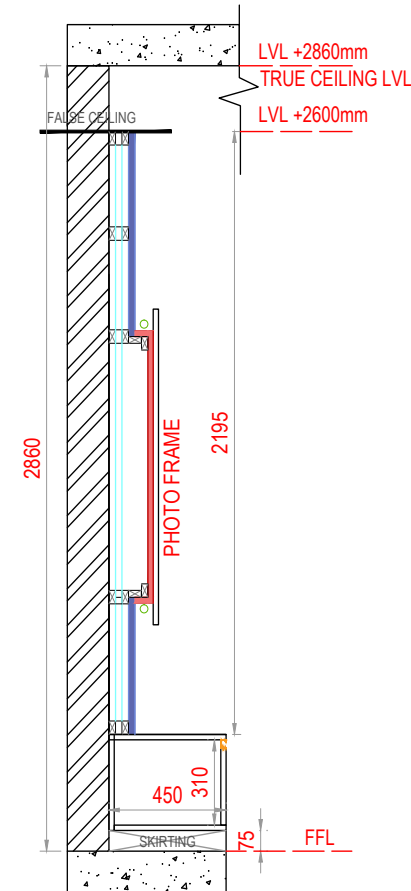

07 SECTION B

Scale: 1:20

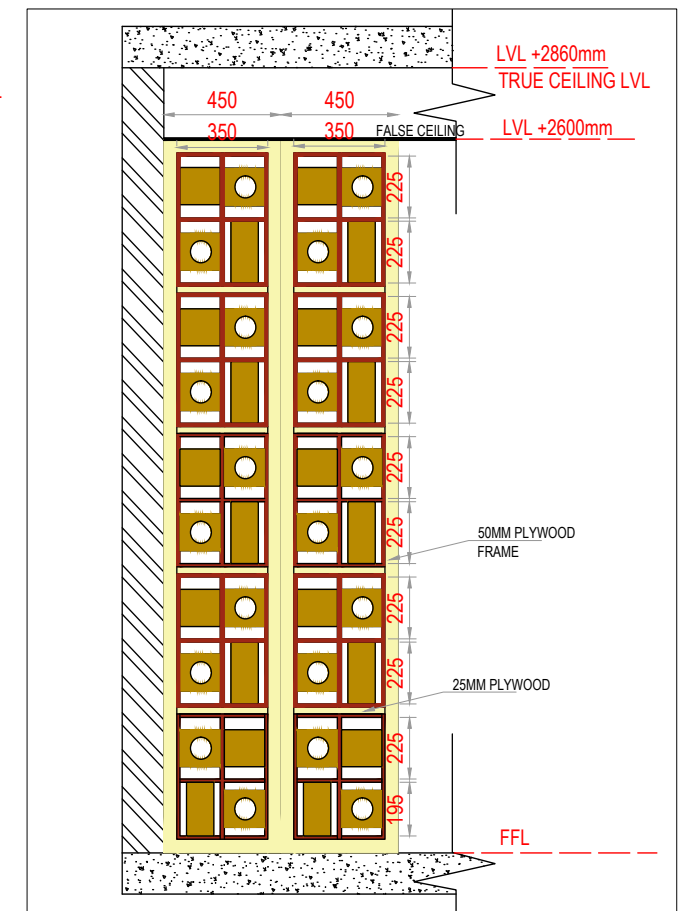

08 SLIDER ELEVATION

Scale: 1:20

DESIGN SYNC COLLABORATIVE
DESIGN SYNC CONSULTING & ADVISORY PVT LTD
BRIGADE METROPOLIS WHITEFIELD ROAD

080125350922
studio@designsync.in
www.designsync.in

INTERIOR FIT OUT
FOR INDU AND MANOJ

BANGALORE

TITLE
LIVING ROOM
TV UNIT AND SHOWCASE

DRAWING NUMBER SCALE ISSUED
F-109 NTS 13 MAR 2022


VERSION

R0


01

02 PLAN

Scale: 1:20

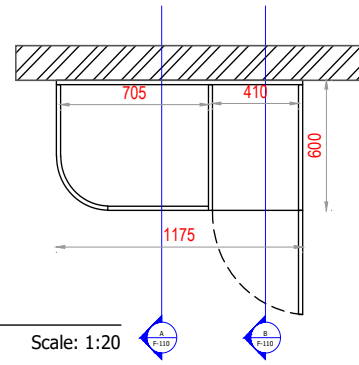


01 KEY PLAN

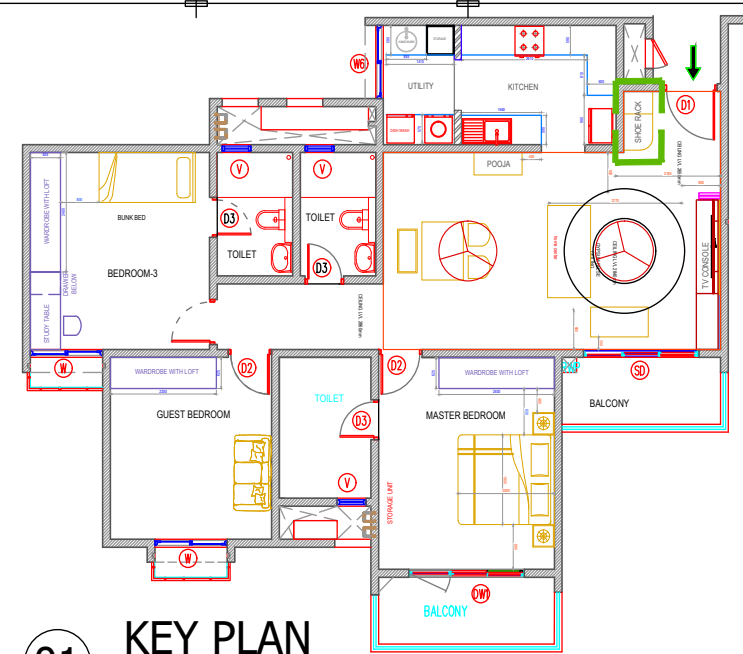


03 ELEVATION

Scale: 1:15

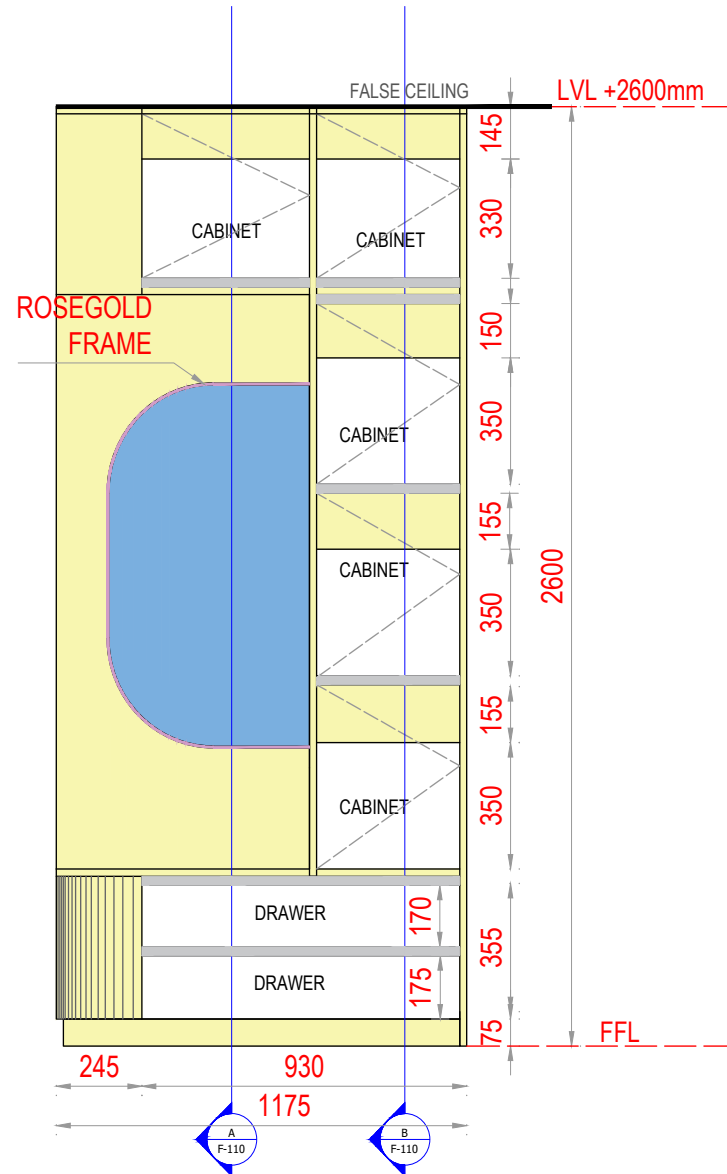


03 INTERNAL ELEVATION

Scale: 1:15

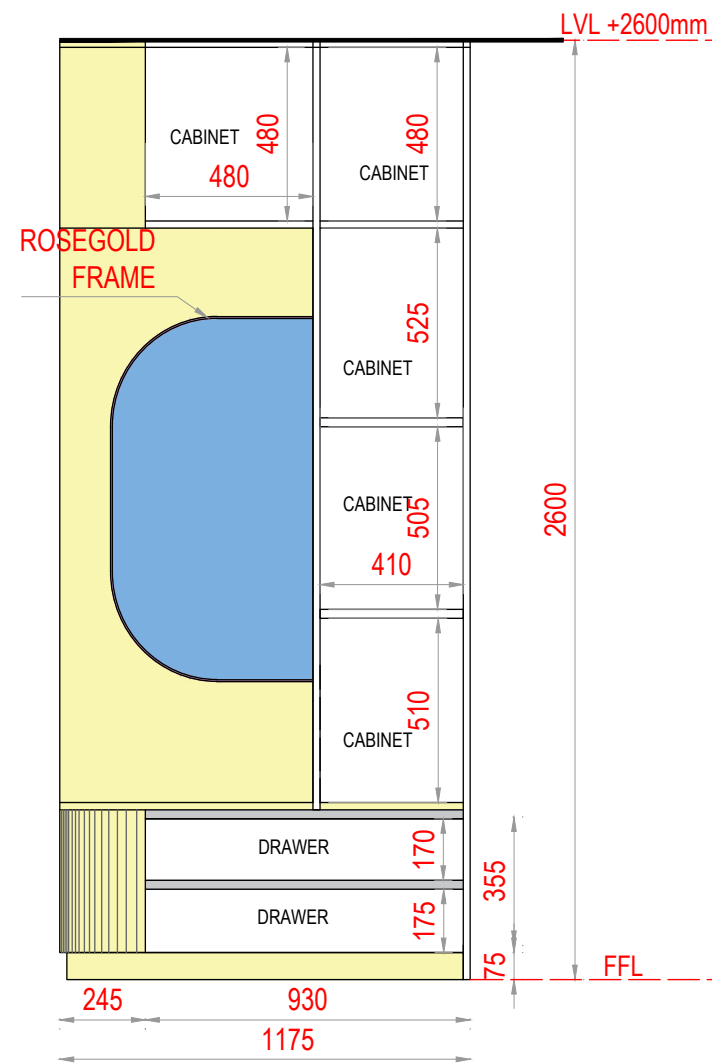


04 SECTION A

Scale: 1:20

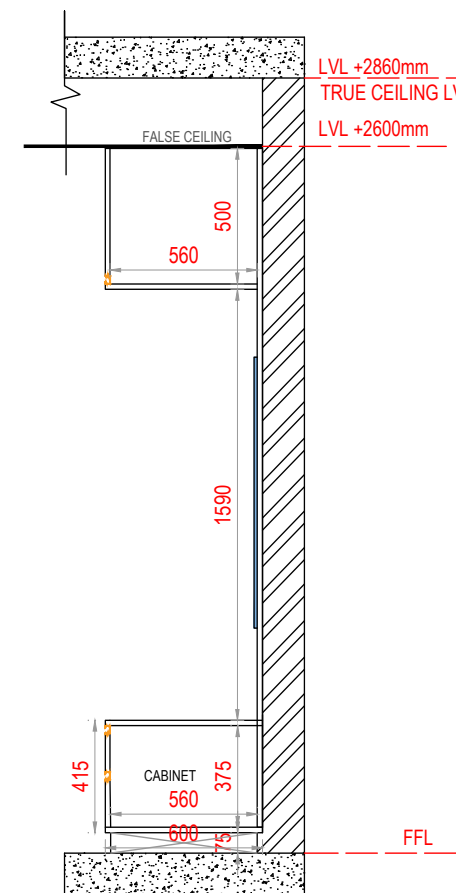

05 SECTION B

Scale: 1:20

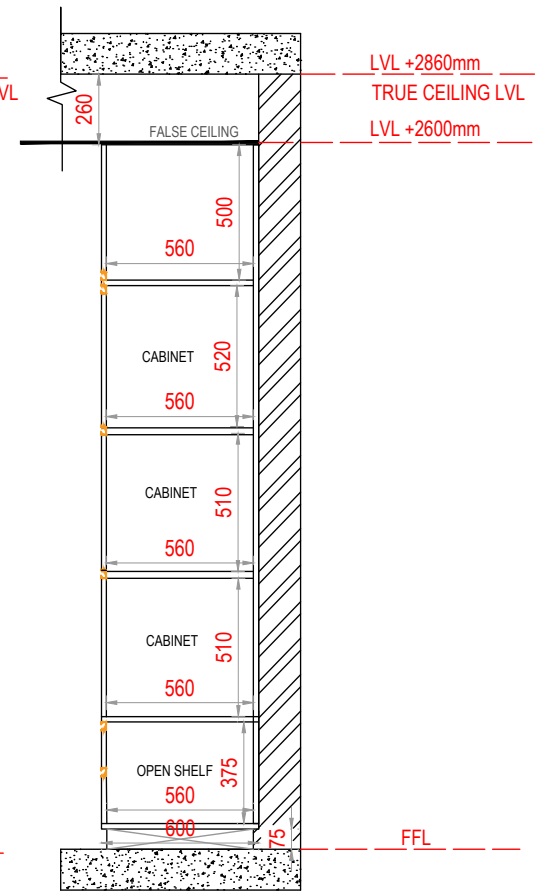

DESIGN SYNC COLLABORATIVE
DESIGN SYNC CONSULTING & ADVISORY PVT LTD
BRIGADE METROPOLIS WHITEFIELD ROAD

080125350922
studio@designsync.in
www.designsync.in

INTERIOR FIT OUT
FOR INDU AND MANOJ


BANGALORE

TITLE
LIVING ROOM
SHOE RACK


DRAWING NUMBER SCALE ISSUED
F-109 NTS 13 MAR 2022

02


VERSION
R0

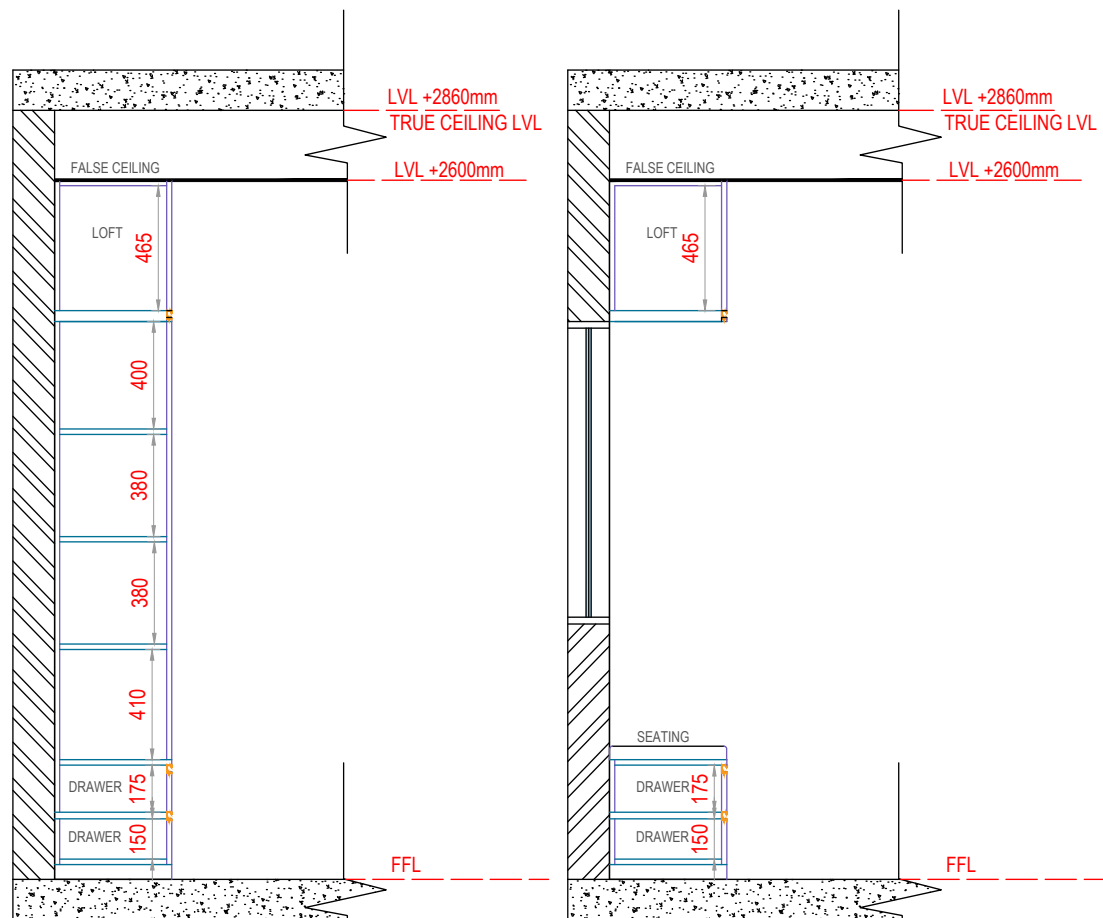


05 SECTION A
Scale: 1:20

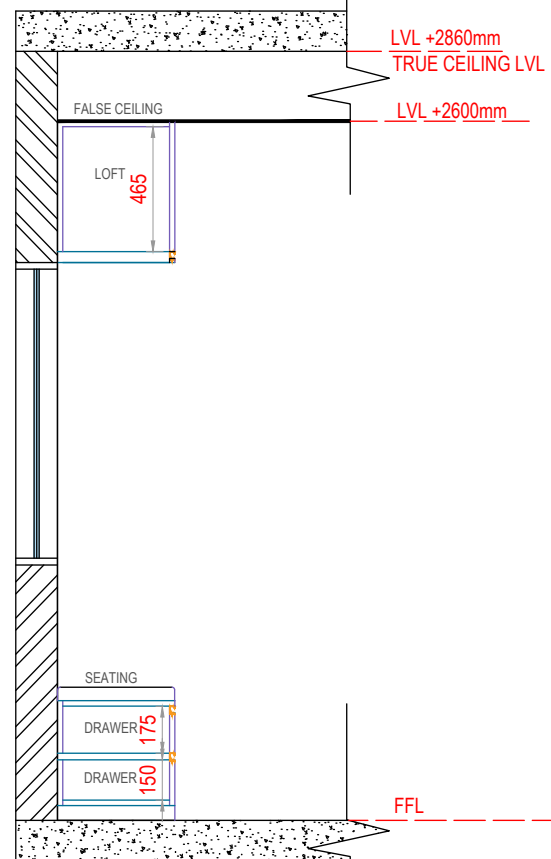


06 SECTION B
Scale: 1:20

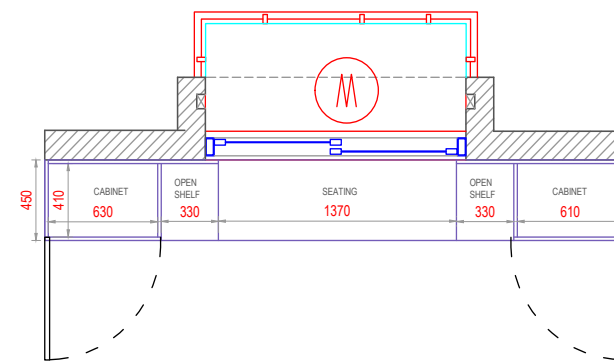


02 PLAN
Scale: 1:30

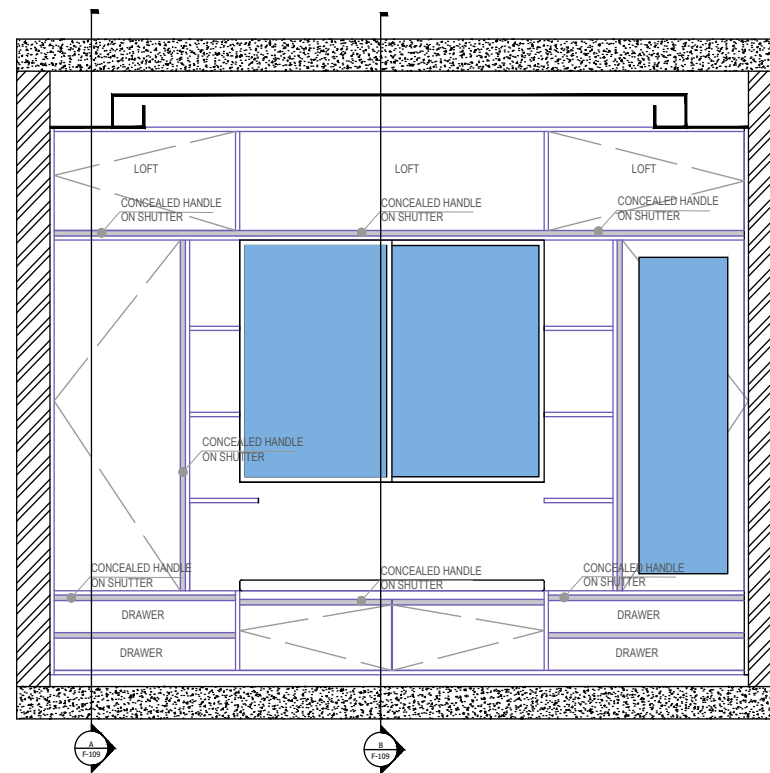

03 ELEVATION
Scale: 1:25

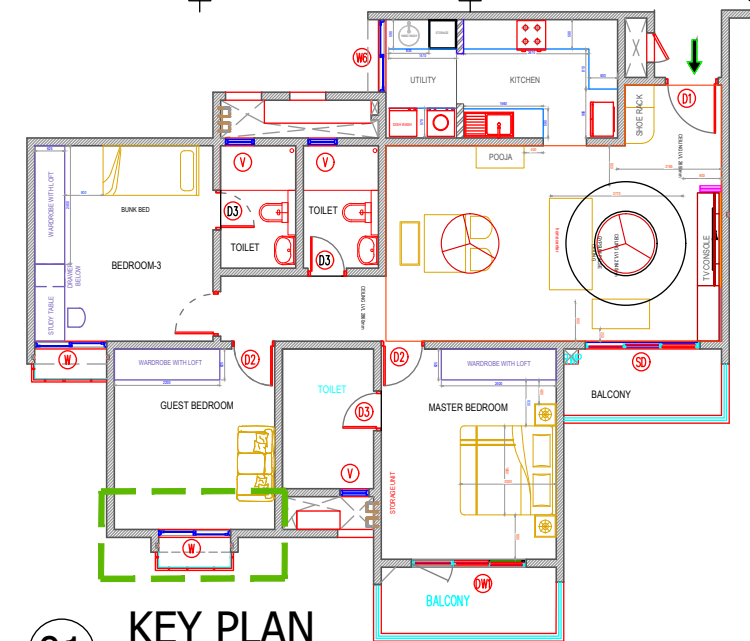

01 KEY PLAN

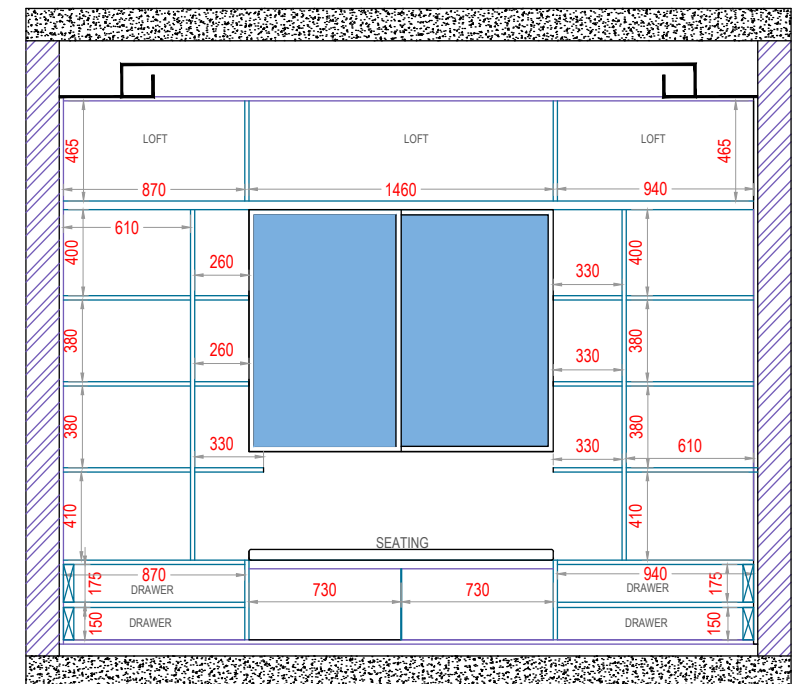

04 INTERNAL ELEVATION
Scale: 1:25

DESIGN SYNC COLLABORATIVE
DESIGN SYNC CONSULTING & ADVISORY PVT LTD
BRIGADE METROPOLIS WHITEFIELD ROAD

08025350922
studio@designsync.in
www.designsync.in

INTERIOR FIT OUT FOR INDU AND MANOJ

BANGALORE

TITLE

MASTER BEDROOM
WARDROBE

DRAWING NUMBER

F-109

SCALE

NTS


ISSUED

13 MAR 2022


VERSION

R0


03

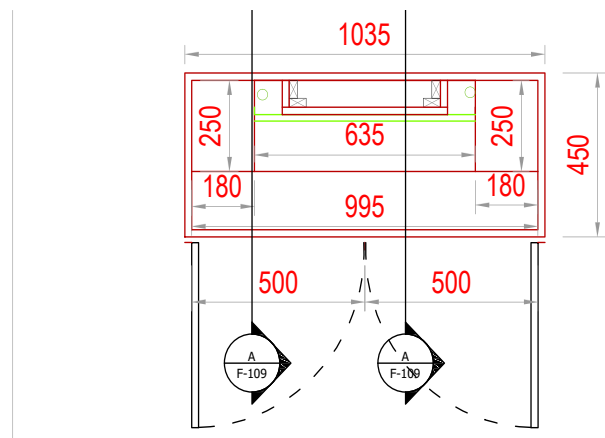


02 PLAN
Scale: 1:10

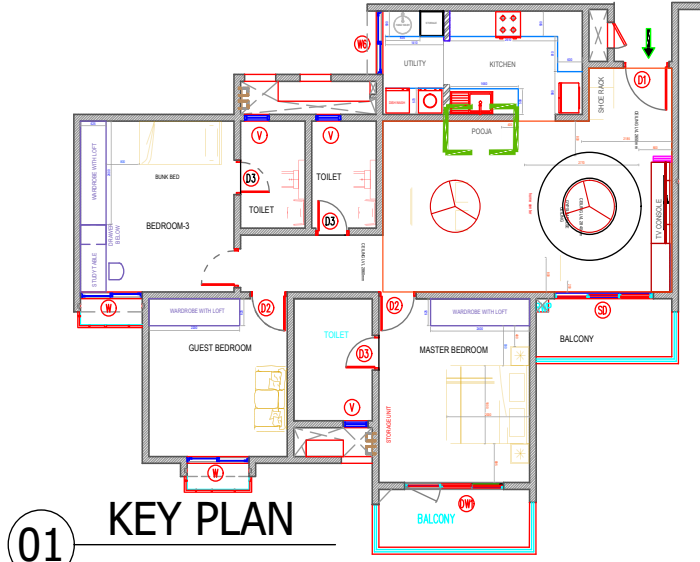


01 KEY PLAN

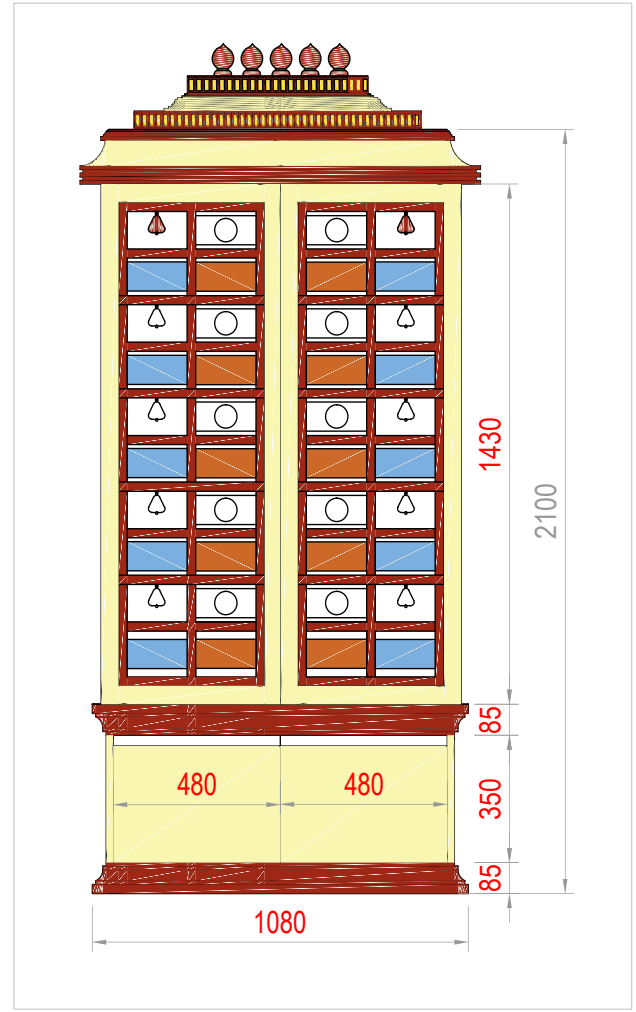


03 ELEVATION
Scale: 1:10

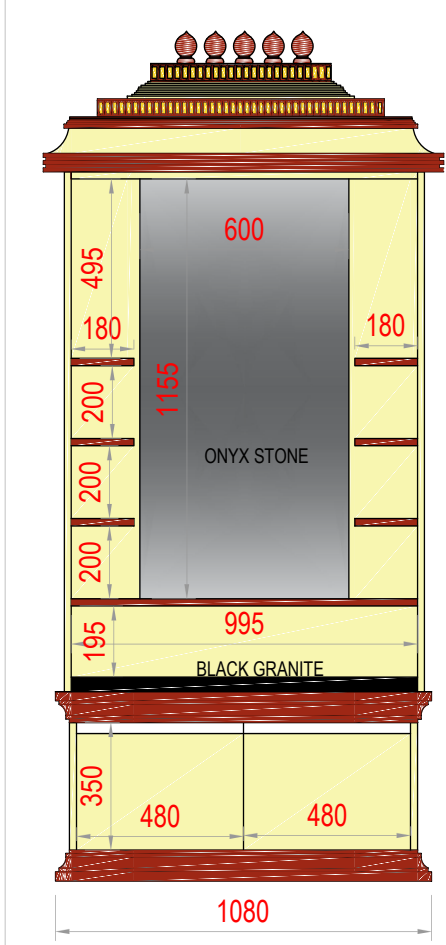

04 INTERNAL ELEVATION
Scale: 1:10

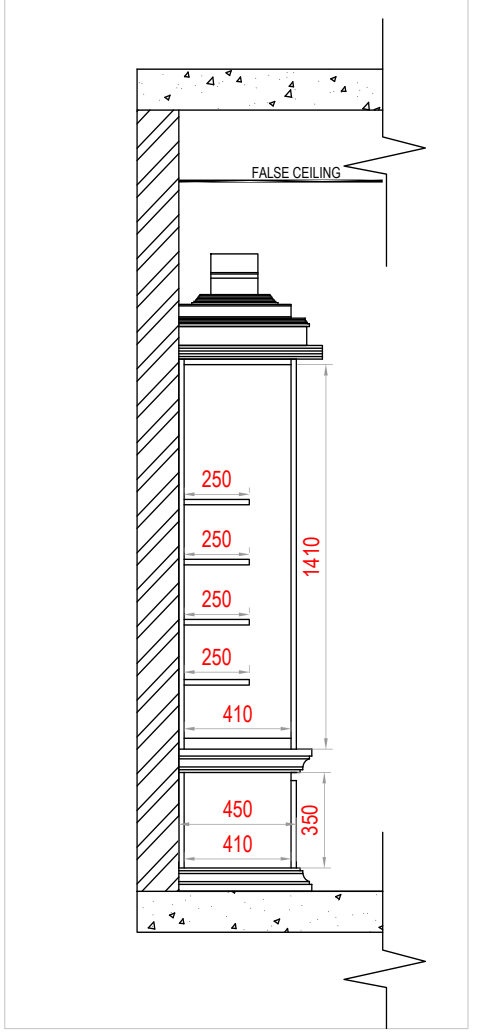

05 SECTION A
Scale: 1:10

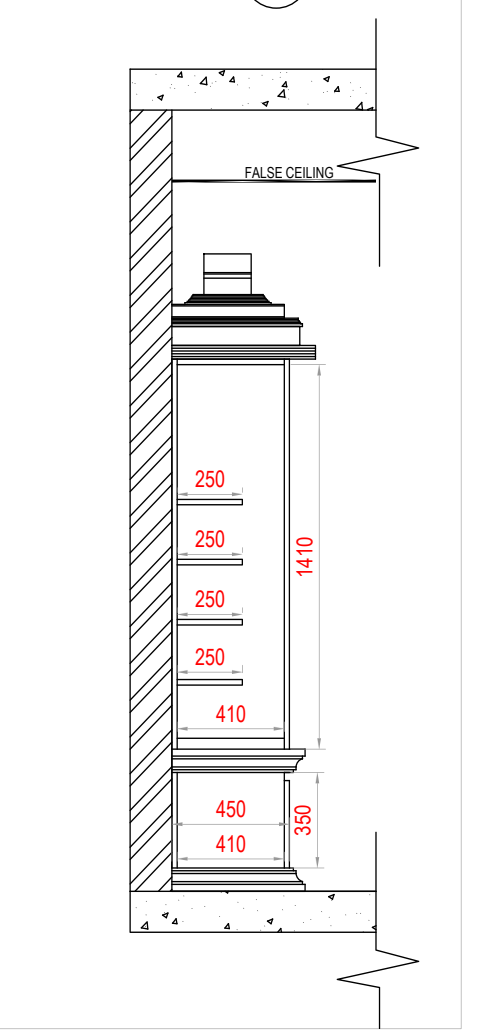

06 SECTION B
Scale: 1:10

DESIGN SYNC COLLABORATIVE
DESIGN SYNC CONSULTING & ADVISORY PVT LTD
BRIGADE METROPOLIS WHITEFIELD ROAD

080125350922
studio@designsync.in
www.designsync.in

INTERIOR FIT OUT FOR INDU AND MANOJ

BANGALORE

TITLE
LIVING ROOM
POOJA UNIT

DRAWING NUMBER SCALE ISSUED
F-109 NTS 13 MAR 2022


04

VERSION
R0



NAYANDAHALLI RAILWAY STATION



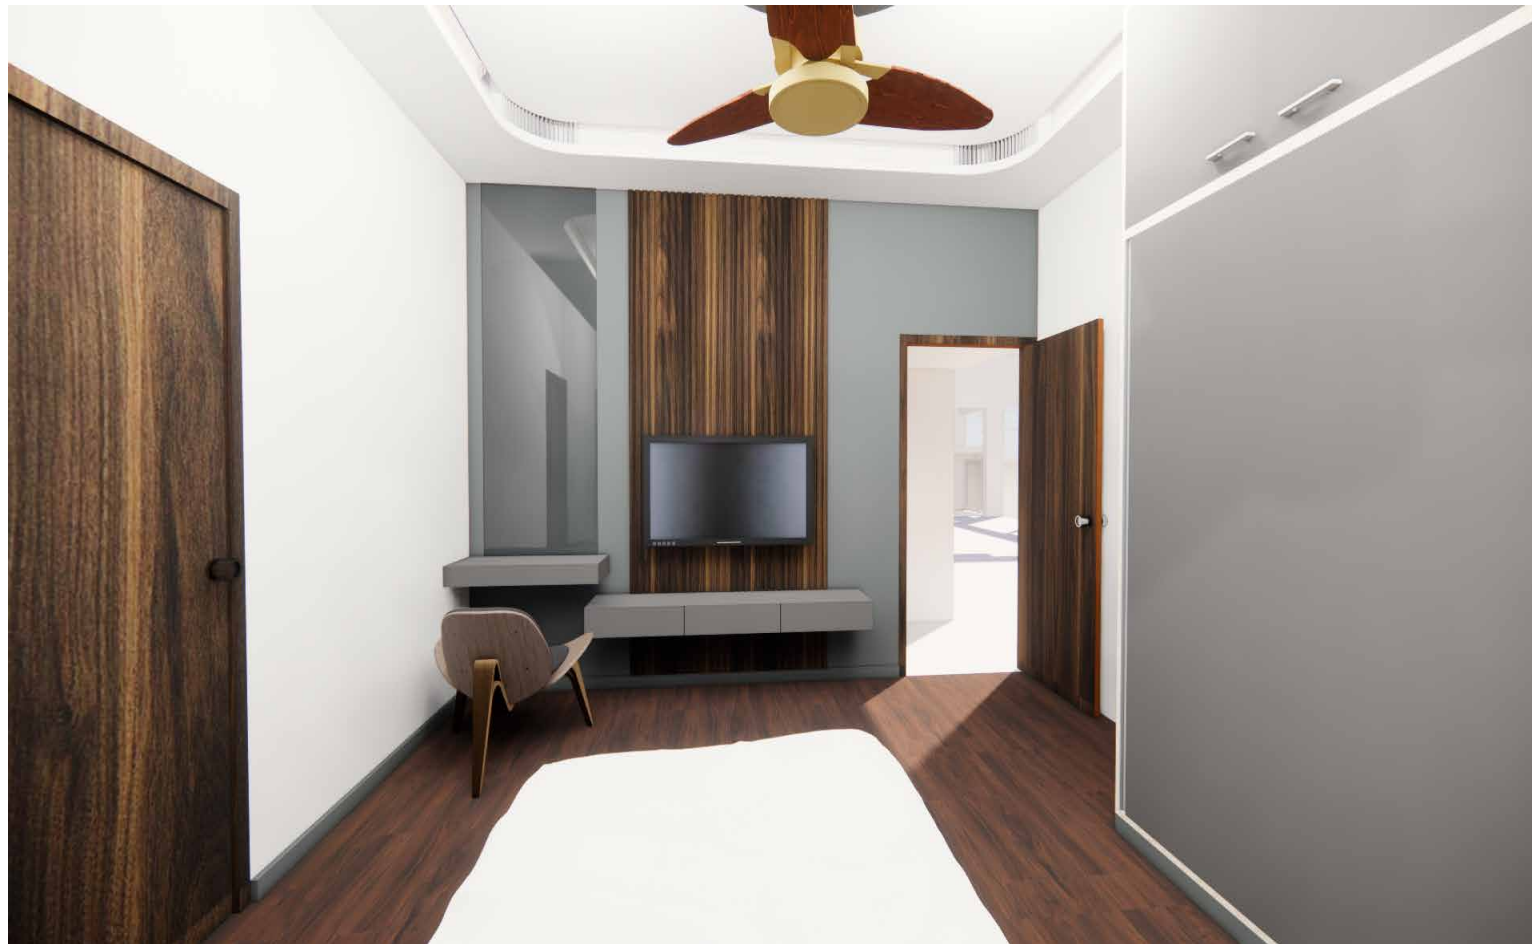

RS RESIDENCE GUEST BEDROOM