



SATHYABAMA

INSTITUTE OF SCIENCE AND TECHNOLOGY
(DEEMED TO BE UNIVERSITY)

Accredited with “A” grade by NAAC | 12B Status by UGC | Approved by AICTE

Jeppiaar Nagar, Rajiv Gandhi Salai, Chennai – 600 119

www.sathyabama.ac.in

SCHOOL OF BUILDING AND ENVIRONMENT

DEPARTMENT OF ARCHITECTURE

PRACTICAL TRAINING PORTFOLIO (S102PT1)

B.Des – Interior Design


DECEMBER 2022

Name of the Student : **M. DURGAA**

Batch : **2019 - 2023**

Reg No. : **39102001**

Semester : **VII**

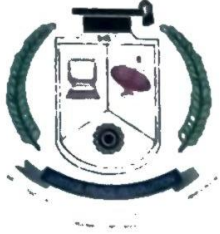

SATHYABAMA

INSTITUTE OF SCIENCE AND TECHNOLOGY
(DEEMED TO BE UNIVERSITY)

Accredited with "A" grade by NAAC | 12B Status by UGC | Approved by AICTE

Jeppiaar Nagar, Rajiv Gandhi Salai, Chennai – 600 119

www.sathyabama.ac.in

SCHOOL OF BUILDING AND ENVIRONMENT

DEPARTMENT OF ARCHITECTURE

B.Des – Interior Design

VIVA-VOCE EXAMINATION

This is to certify that the practical training S102PT1 is the work of **M. DURGAA** who had undergone training in **DESIGNWORKS** has been monitored by the continuous assessment during JUNE 2022 to NOVEMBER 2022.

A handwritten signature in black ink, appearing to read 'Devyani'.

Dr. Devyani Gangopadhyay
DEAN

Submitted for Viva voce Examination held on 13/12/2022

A handwritten signature in black ink, appearing to read 'C. Vignesh'.

Internal Examiner

A handwritten signature in black ink, appearing to read 'Dr. K. S. Srinivasan'.

External Examiner



SATHYABAMA

INSTITUTE OF SCIENCE AND TECHNOLOGY
(DEEMED TO BE UNIVERSITY)

Accredited with "A" grade by NAAC | 12B Status by UGC | Approved by AICTE

Jeppiaar Nagar, Rajiv Gandhi Salai, Chennai – 600 119

www.sathyabama.ac.in

DECLARATION

I, **M. DURGAA** by declaring that the Training Report **JUNE 2022 to NOVEMBER 2022** done by me under the guidance of

Ar. RAJESH KUMAR .G is submitted in partial fulfillment of the requirements for the completion of a practical training session.

DATE : 13/12/2022

PLACE : CHENNAI

M. Durgaa.

SIGNATURE OF CANDIDATE

ACKNOWLEDGEMENT

I am pleased to acknowledge my sincere thanks to the Board **of Management of SATHYABAMA** for their kind encouragement in doing this practical training and for completing it successfully. I am grateful to them.

I convey my thanks to **Dr. Devyani Gangopadhyay**, Dean, School of Building and Environment and **Ar. Sarath Chandra Kanth**, Design Chair, Department of Architecture for having been a constant source of support and encouragement.

I wish to express my thanks to all Teaching and Non-teaching staff members of the Department who were helpful in many ways for the completion of the project.

I also wish to thank **Ar. SATHISH KUMAR JAYABALAN** for the experience of interning at their firm.

11th May 2022

To
The HOD
Sathyabama Institute of Science & Technology
Chennai

Dear Sir / Madam,

This is to inform that Ms. M Durgaa student of 4th year Bachelor of Design (Interior Design) , Sathyabama Institute Of Science and Technology will be inducted with us as Interior Design Trainee from 1st June 2022 to 30th November 2022 . (Irrespective of the minimum working days as prescribed by your curriculum)

For Designworks




Rajesh Kumar G

RAJESH KUMAR G . B.ARCH
CA/2004/34394



Head Office
II Floor, #25, 6th Main Road,
R.A.Puram, Chennai-600 028,
Ph : +91 - 44 - 42303731/32/33,
Fax : +91 - 44 - 42303734

Branch Office
II Floor, #1222 Lakshmi Nivas,
4th Cross, New Tippasandra Hal
III stage Bangalore - 560 075,
Ph : +91 - 80 - 41573086

**SCHOOL OF BUILDING AND ENVIRONMENT
DEPARTMENT OF ARCHITECTURE**

PROFESSIONAL TRAINING REPORT (DD/MM/YY 05/07/2022)

(Continuous progress report of the interior designer trainee for the period of one month in the office to be submitted to HOD by the trainee in charge of the organization)

1. Name of the office / organization: **DESIGN WORKS**

2. Address & Contact Number :

3. Name of the student : **M. Durgaa**

4. Duration : From **01/06/2022** To **01/07/2022**

5. Total No. of days : **22**

6. Evaluation of Performance criteria shall be on

* Note: Kindly grade the student as per his/her overall performance in the office during the assessment month; which will be converted to the allotted 20 marks by the department.

DESCRIPTION	EXCELLENT	GOOD	FAIR	POOR	N/A
Understanding of office culture	✓				
Participation in the office	✓				
Reading of drawings		✓			
Presentation Techniques		✓			
Understanding of construction details		✓			
Drafting Skills (Manual / Computer)	✓				
Site Supervision / Discussion with clients	✓				
Adherence to Time schedule	✓				
Other computer skills		✓			
Coordination with other consultants					✓
OVERALL GRADING	A				

(A - 9.0, B - 8.0, C - 7.0, D - 6.0, E - 5.0)

7. Any other Remarks :

Very eager to learn and quick in understanding concepts & details

8. Signature of the:

Head of the Office
Organization (With Seal)



Designworks
1st Floor, No.33, Ranjith Road
Kotturpuram, Chennai 600085
Ph: 044 42303732 / 33



SATHYABAMA

INSTITUTE OF SCIENCE AND TECHNOLOGY

(DEEMED TO BE UNIVERSITY)

Accredited "A" Grade by NAAC | 12B Status by UGC | Approved by AICTE

www.sathyabama.ac.in

SCHOOL OF BUILDING AND ENVIRONMENT

DEPARTMENT OF ARCHITECTURE

PROFESSIONAL TRAINING REPORT (DD/MM/YY 04/08/2022)

(Continuous progress report of the interior designer trainee for the period of one month in the office to be submitted to HOD by the trainee in charge of the organization)

1. Name of the office / organization: DESIGN WORKS

2. Address & Contact Number :

3. Name of the student : M. Durgaa

4. Duration : From 01/07/2022 To 01/08/2022

5. Total No. of days : 23

6. Evaluation of Performance criteria shall be on

* Note: Kindly grade the student as per his/her overall performance in the office during the assessment month; which will be converted to the allotted 20 marks by the department.

DESCRIPTION	EXCELLENT	GOOD	FAIR	POOR	N/A
Understanding of office culture		✓			
Participation in the office		✓			
Reading of drawings		✓			
Presentation Techniques	✓				
Understanding of construction details		✓			
Drafting Skills (Manual / Computer)		✓			
Site Supervision / Discussion with clients		✓			
Adherence to Time schedule	✓				
Other computer skills		✓			
Coordination with other consultants		✓			
OVERALL GRADING	<u>A</u>				

(A - 9.0, B - 8.0, C - 7.0, D - 6.0, E - 5.0)

7. Any other Remarks : _____

8. Signature of the:

Head of the Office /
Organization (With Seal)



SATHYABAMA

INSTITUTE OF SCIENCE AND TECHNOLOGY

(DEEMED TO BE UNIVERSITY)

Accredited "A" Grade by NAAC | 12B Status by UGC | Approved by AICTE

www.sathyabama.ac.in

SCHOOL OF BUILDING AND ENVIRONMENT

DEPARTMENT OF ARCHITECTURE

PROFESSIONAL TRAINING REPORT (DD/MM/YY 07/09/2022)

(Continuous progress report of the interior designer trainee for the period of one month in the office to be submitted to HOD by the trainee in charge of the organization)

1. Name of the office / organization: DESIGN WORKS

2. Address & Contact Number :

3. Name of the student : M. Durgaa

4. Duration : From 01/08/2022 To 01/09/2022

5. Total No. of days : 23

6. Evaluation of Performance criteria shall be on

* Note: Kindly grade the student as per his/her overall performance in the office during the assessment month; which will be converted to the allotted 20 marks by the department.

DESCRIPTION	EXCELLENT	GOOD	FAIR	POOR	N/A
Understanding of office culture		✓			
Participation in the office	✓				
Reading of drawings	✓				
Presentation Techniques		✓			
Understanding of construction details	✓				
Drafting Skills (Manual / Computer)	✓				
Site Supervision / Discussion with clients		✓			
Adherence to Time schedule	✓				
Other computer skills	✓				
Coordination with other consultants	✓				
OVERALL GRADING	<u>A</u>				

(A - 9.0, B - 8.0, C - 7.0, D - 6.0, E - 5.0)

7. Any other Remarks : _____

8. Signature of the:

Head of the Office /
Organization (With Seal)



SCHOOL OF BUILDING AND ENVIRONMENT
DEPARTMENT OF ARCHITECTURE

PROFESSIONAL TRAINING REPORT (DD/MM/YY 08/10/2022)

(Continuous progress report of the interior designer trainee for the period of one month in the office to be submitted to HOD by the trainee in charge of the organization)

1. Name of the office / organization: DESIGN WORKS

2. Address & Contact Number :

3. Name of the student : M. Durgaa

4. Duration : From 01/09/2022 To 01/10/2022

5. Total No. of days : 24


6. Evaluation of Performance criteria shall be on

* Note: Kindly grade the student as per his/her overall performance in the office during the assessment month; which will be converted to the allotted 20 marks by the department.

DESCRIPTION	EXCELLENT	GOOD	FAIR	POOR	N/A
Understanding of office culture	✓				
Participation in the office	✓				
Reading of drawings	✓				
Presentation Techniques		✓			
Understanding of construction details	✓				
Drafting Skills (Manual / Computer)	✓				
Site Supervision / Discussion with clients		✓			
Adherence to Time schedule	✓				
Other computer skills		✓			
Coordination with other consultants					✓
OVERALL GRADING	A				

(A - 9.0, B - 8.0, C - 7.0, D - 6.0, E - 5.0)

 7. Any other Remarks : Very Hardworking.

8. Signature of the: 
Head of the Office /
Organization (With Seal)



Designworks
1st Floor, No.33, Rajjith Road
Kotturpuram, Chennai 600083
Ph: 044 42303732 / 33

SCHOOL OF BUILDING AND ENVIRONMENT
DEPARTMENT OF ARCHITECTURE

PROFESSIONAL TRAINING REPORT (DD/MM/YY 01/11/2022)

(Continuous progress report of the interior designer trainee for the period of one month in the office to be submitted to HOD by the trainee in charge of the organization)

1. Name of the office / organization: DESIGNWORKS

2. Address & Contact Number :

3. Name of the student : M. Durgaa

4. Duration : From 01/10/2022 To 05/11/2022

5. Total No. of days : 29


6. Evaluation of Performance criteria shall be on

* Note: Kindly grade the student as per his/her overall performance in the office during the assessment month; which will be converted to the allotted 20 marks by the department.

DESCRIPTION	EXCELLENT	GOOD	FAIR	POOR	N/A
Understanding of office culture	✓				
Participation in the office		✓			
Reading of drawings	✓				
Presentation Techniques		✓			
Understanding of construction details		✓			
Drafting Skills (Manual / Computer)		✓			
Site Supervision / Discussion with clients	✓				
Adherence to Time schedule		✓			
Other computer skills		✓			
Coordination with other consultants					✓
OVERALL GRADING	A				

(A - 9.0, B - 8.0, C - 7.0, D - 6.0, E - 5.0)

 7. Any other Remarks : Eager to learn and Hardworking.

8. Signature of the: 
Head of the Office /
Organization (With Seal)





1st November 2022

To
Dr. Devyani Gangopadhyay
Dean, School of Building & Environment,
Sathyabama Institute of Science and Technology,
Chennai 600 119

Dear Sir / Madam,

Sub: Completion certificate for practical training program
Student : Ms. M Durgaa
Reg no : 39102001

This is to certify that Ms. M Durgaa (Reg No : 39102001) VII sem, B.des student of your institution had joined our office for her internship program and has successfully completed her internship from 1st June 2022 to 5th November 2022 for 120 days.

She has no pending assignments and is relieved from this office. Drawings used for the report was done by her, under the supervision of Ar. Rajesh Kumar G (DESIGN WORKS).

Certified further that all the drawings used for the report are a property of the office and have been used with prior consent.

Her conduct has been - **Excellent** / **V. Good** / **Good** / **Fair** / **Bad**

SIGNATURE OF CHIEF ARCHITECT



(Rajesh Kumar G)

RAJESH KUMAR G . B.ARCH
CA/2004/34394



Head Office
II Floor, #25, 6th Main Road,
R.A.Puram, Chennai-600 028,
Ph : +91 - 44 - 42303731/32/33,
Fax : +91 - 44 - 42303734

Branch Office
II Floor, #1222 Lakshmi Nivas,
4th Cross, New Tippasandra Hal
III stage Bangalore - 560 075,
Ph : +91 - 80 - 41573086

WORK DIARY

DATES	PROJECT NAME	NATURE OF WORK DONE
01-06-2022	SIGNATURE VILLAS	ELECTRICAL LAYOUTS FOR PLOT - 19A
02-06-2022	VISHWA HOMES	FIRST FLOOR ELECTRICAL LAYOUT
06-06-2022 - 07-06-2022	PYCROFTS ROAD APARTMENT	ELECTRICAL LAYOUT
08-06-2022 - 14-06-2022	SIVABALAN RESIDENCE	WARDROBES DETAIL - 2D
15-06-2022	ANBUMANI RESIDENCE	ELECTRICAL LAYOUT
16-06-2022	SIVABALAN RESIDENCE	WARDROBES DETAIL - 2D
18-06-2022	SIVABALAN RESIDENCE	WARDROBES DETAIL - 3D, PRESENTATION & CLIENT MEETING
20-06-2022	LANDMARK	ELECTRICAL LAYOUT
21-06-2022	SUSEE MAHAL	3D MODEL FOR GROUND FLOOR
22-06-2022	SIVABALAN RESIDENCE	WARDROBES DETAIL - 2D
23-06-2022	THYAGRAJAN RESIDENCE	SITE VISIT - MRC NAGAR
24-06-2022	ANBUMANI RESIDENCE	BASIC 3D MODEL
	AUTOMOBILE DEALERSHIP FOR M/S. ARAS GROUP	FURNITURE LAYOUT, LANDSCAPE, DIMENSIONS CORRECTION & OTHER INCOMPLETE WORKS ON THE DWG
25-06-2022	SHIVAKUMAR RESIDENCE	ELECTRICAL LAYOUT - FIRST FLOOR
27-06-2022	THYAGRAJAN RESIDENCE	SITE VISIT - MRC NAGAR
	SHIVAKUMAR RESIDENCE	ELECTRICAL LAYOUT - FIRST FLOOR
28-06-2022	SHIVAKUMAR RESIDENCE	ELECTRICAL LAYOUT - ENTERTAINMENT BLOCK'S FIRST FLOOR, CAR PORCH
29-06-2022	SHIVAKUMAR RESIDENCE	ELECTRICAL LAYOUT - FIRST FLOOR
30-06-2022 - 05-07-2022	ADROIT DEVELOPERS	CLUB HOUSE - RECEPTION TABLE DETAIL

06-07-2022	PYCROFTS ROAD APARTMENT	ELECTRICAL LAYOUT
07-07-2022 - 10-07-2022	THYAGRAJAN RESIDENCE	FURNITURE LAYOUTS, FALSE CEILING & ELECTRICAL LAYOUTS, FLOORING LAYOUTS, WALL ELEVATIONS
11-07-2022 - 12-07-2022	SIGNATURE VILLAS	ELECTRICAL LAYOUTS FOR PLOT - 10, 11 & 15
13-07-2022	ANBUMANI RESIDENCE	SITE VISIT - ROYAPURAM, CORRECTIONS IN FURNITURE LAYOUTS
14-07-2022 - 15-07-2022	YERCAUD RESIDENCE	ELECTRICAL LAYOUTS, EXCEL FOR ELECTRICAL FITTINGS
16-07-2022	ANBUMANI RESIDENCE	BASIC 3D MODEL, CORRECTIONS IN ELECTRICAL LAYOUTS
	LANGUAGE SHOWROOM	FLOOR PLAN COLOURING IN PHOTOSHOP
18-07-2022 - 19-07-2022	THYAGRAJAN RESIDENCE	DOOR DETAIL, FALSE CEILING & ELECTRICAL LAYOUTS, FLOORING LAYOUTS, WALL ELEVATIONS
20-07-2022	YERCAUD RESIDENCE	BASIC 3D MODEL
21-07-2022	ANBUMANI RESIDENCE	SITE VISIT - ROYAPURAM
	YERCAUD RESIDENCE	BASIC 3D MODEL
22-07-2022	SUBRAMANI RESIDENCE	HOME OFFICE - 3D MODEL
23-07-2022	UDAY VILAS	CLUB HOUSE - BASIC WALL ELEVATIONS
25-07-2022	SUBRAMANI RESIDENCE	HOME OFFICE - 3D MODEL
26-07-2022	SUBRAMANI RESIDENCE	HOME OFFICE - 2D FURNITURE LAYOUT
	SUBRAMANI RESIDENCE	SITE VISIT - ADYAR
27-07-2022	SUBRAMANI RESIDENCE	HOME OFFICE - 2D FALSE CEILING LAYOUT
29-07-2022	SUBRAMANI RESIDENCE	HOME OFFICE - 3D MODEL
30-07-2022	SUBRAMANI RESIDENCE	HOME OFFICE - 2D FALSE CEILING LAYOUT
	SUBRAMANI RESIDENCE	SITE VISIT - ADYAR
01-08-2022	AMMA NAANA	EXTERIOR HPL PANEL DESIGN & DETAIL
02-08-2022	SUBRAMANI RESIDENCE	HOME OFFICE - FC ELECTRICAL LAYOUT

03-08-2022 - 04-08-2022	AMMA NAANA	EXTERIOR HPL PANEL DESIGN & DETAIL
05-08-2022	NANDHITHA RESIDENCE	ELECTRICAL LAYOUT FOR COMPOUND WALL
06-08-2022 - 07-08-2022	SIGNATURE VILLAS	ELECTRICAL LAYOUTS FOR PLOT - 18
08-08-2022	SIGNATURE VILLAS	ELECTRICAL LAYOUTS FOR PLOT - 18
	AMMA NAANA	EXTERIOR HPL PANEL DESIGN
09-08-2022	PYCROFTS ROAD APARTMENT	ELECTRICAL LAYOUT
10-08-2022 - 11-08-2022	OLIVE WAVES - CONTAINER HOMES	FLOOR PLAN COLOURING IN PHOTOSHOP
12-08-2022	SHIVAKUMAR RESIDENCE	CAR PORCH ELECTRICAL LAYOUT
13-08-2022	YERCAUD RESIDENCE	FALSE CEILING LAYOUTS FOR GROUND FLOOR - 2D
16-08-2022	YERCAUD RESIDENCE	FALSE CEILING LAYOUTS FOR GROUND FLOOR - 2D
	SHIVAKUMAR RESIDENCE	ENTERTAINMENT BLOCK'S FIRST FLOOR - ELECTRICAL LAYOUT
17-08-2022 - 18-08-2022	YERCAUD RESIDENCE	FALSE CEILING LAYOUTS, STRUCTURAL LAYOUT - 3D
19-08-2022 - 20-08-2022	YERCAUD RESIDENCE	ELECTRICAL LAYOUT
22-08-2022 - 05-09-2022	UDAY VILAS	FURNITURE LAYOUT, FALSE CEILING LAYOUTS, ELECTRICAL LAYOUTS & WALL ELEVATIONS
06-09-2022	SUBRAMANI RESIDENCE	HOME OFFICE - FC ELECTRICAL & LIGHTING LAYOUT, WALL ELEVATIONS
09-09-2022	KARTHIK RESIDENCE	ELECTRICAL LAYOUT
10-09-2022 - 17-09-2022	SUBRAMANI RESIDENCE	HOME OFFICE - ELECTRICAL LAYOUT, WALL ELEVATIONS & STORAGE CABINET DETAILS
	UDAY VILAS	FC LAYOUTS, ELECTRICAL LAYOUTS & WALL ELEVATIONS
19-09-2022 - 21-09-2022	YERCAUD RESIDENCE	SUNKEN SEATING 2D DRAWING WITH DETAILS
22-09-2022	YERCAUD RESIDENCE	FALSE CEILING LAYOUTS FOR GROUND FLOOR - 2D
23-09-2022	SIGNATURE VILLAS	ELECTRICAL LAYOUTS FOR PLOT - 15
24-09-2022 - 26-09-2022	OTHAKADAI	MOCK ELECTRICAL LAYOUT

	YERCAUD RESIDENCE	FALSE CEILING LAYOUTS FOR GROUND FLOOR - 2D
27-09-2022 - 08-10-2022	YERCAUD RESIDENCE	TOILETS - WALL ELEVATIONS, PLUMBING LAYOUTS, TILE LAYOUTS, FITTINGS DETAIL
10-10-2022	OTHAKADAI	MOCK ELECTRICAL LAYOUT
11-10-2022 - 12-10-2022	CHOO LAIMEDU	ELECTRICAL LAYOUTS
	UDAY VILAS	SITE VISIT - GOPALAPURAM
14-10-2022 - 05-11-2022	YERCAUD RESIDENCE	FLOORING DETAILS & LAYOUT, TOILETS - WALL ELEVATIONS, FITTINGS DETAIL, TILE LAYOUTS, PLUMBING LAYOUTS & 3D MODEL

CHIEF ARCHITECT'S SIGNATURE :

OFFICE SEAL :

TABLE OF CONTENTS

SL. NO.	TITLE OF THE PROJECT	PAGE NO.
1	ABOUT THE FIRM	1
2	SIGNATURE VILLAS	02 - 10
3	LANDMARK APARTMENT	11
4	PYCROFTS ROAD APARTMENT	12
5	ADROIT DEVELOPERS	13
6	THYAGRAJAN RESIDENCE	14 - 34
7	ANBUMANI RESIDENCE	35 - 37
8	AMMA NAANA - COMMERCIAL	38
9	NANDHITHA RESIDENCE	39
10	LANDMARK - UDAY VILAS	40 - 51
11	SHIVAKUMAR RESIDENCE	52 - 55
12	SUBRAMANI RESIDENCE - HOME OFFICE	56 - 62
13	CHOO LAIMEDU RESIDENCE	63 - 65
14	YERCAUD RESIDENCE	66 - 79
15	CRITICAL OVERVIEW OF THE FIRM	80

AT DESIGNWORKS

we believe that design is what works
efficiently

DESIGNWORKS

ARCHITECTS | INTERIOR DESIGNERS | PLANNERS



ABOUT THE FIRM

Design works is a multi-disciplinary firm that has evolved over the years in the architecture and interior design industry. We offer superior design, value construction and certainty of outcome for over 20+ years.

The firm was established in the year 2002 in the name of DESIGNWORKS by Ar. Sathish kumar Jayabalan. The firm, today, continues to operate under the same name and is managed by Ar. Sathish kumar Jayabalan as the chief architect.

Design works provides consultancy services in architecture, interior design & master planning . We design a wide range of : Residential buildings – Villas, Individual residences, Row houses, Flats, Apartments, Gated communities, Townships ; Commercial buildings – Showrooms, Offices, Complexes ; Hospitality buildings – Resorts, Hotels, Restaurants, Club houses, Wedding halls, etc.

We use creativity, imagination and knowledge of our entire team to design buildings & spaces of the highest quality. Above all, Client is the soul of the project. Our main goal is to give clients peace of mind that their project will be completed the way it was perceived and planned.

TITLE OF THE PROJECT

PROJECT TYPOLOGY

CLIENT

LOCATION

PROJECT STATUS

:

:

:

:

:


SIGNATURE VILLAS

RESIDENCE - VILLAS

Mr. JAYARAJ

MADURAI

ON-GOING

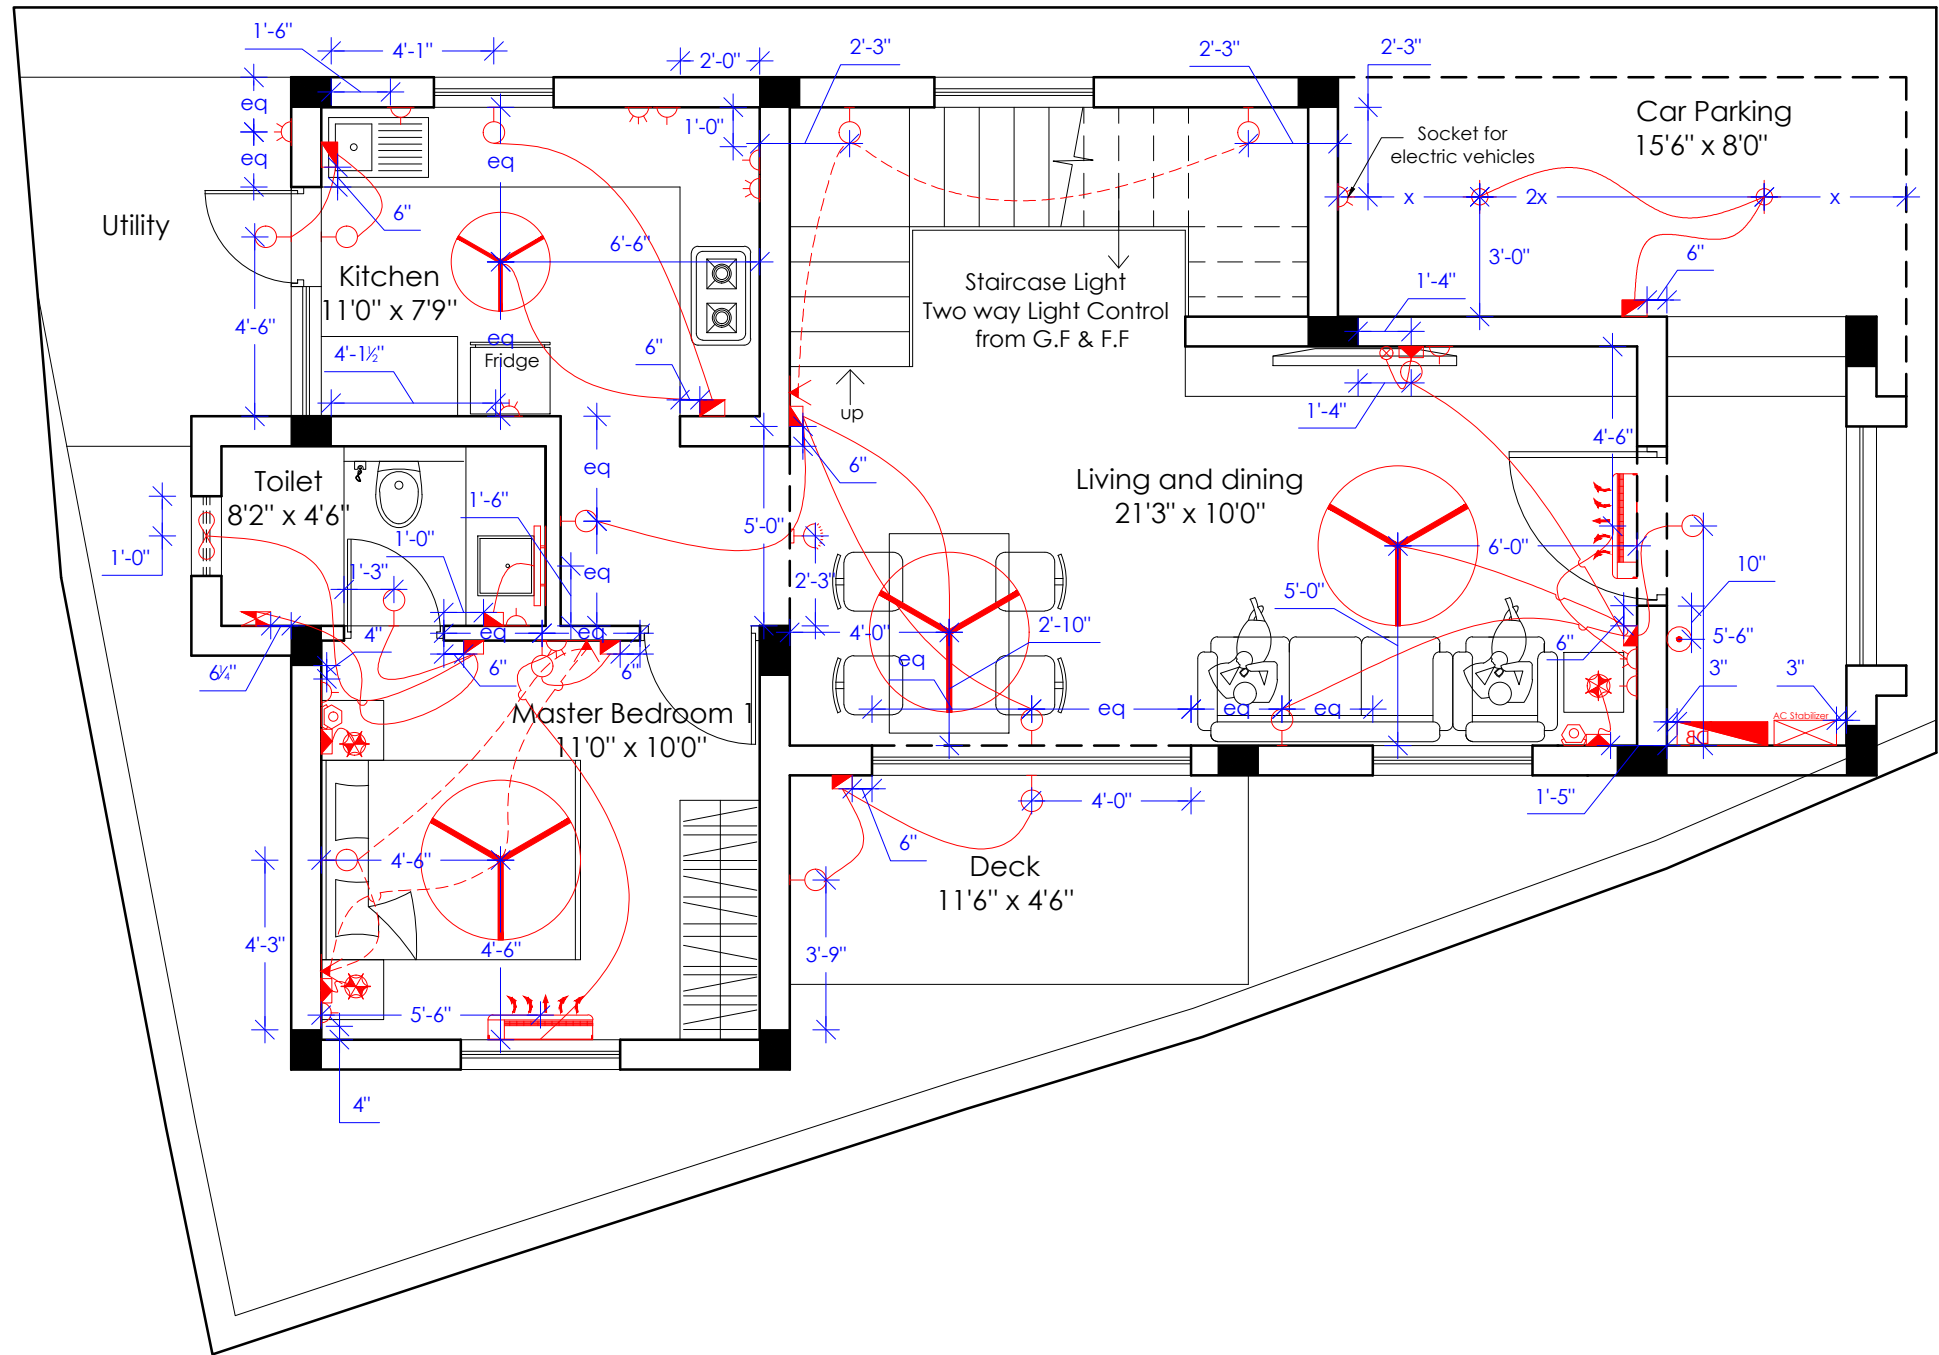

NOTES:
This drawing is the property of designworks & cannot be used or reproduced any form without their written permission.

Any discrepancy should be brought to the notice of the architects.

Only written dimensions should be followed, the drawing is not to be scaled.

For Discussion	☐	Site Copy	☐
For Approval	☐	Clients Copy	☐
Good For Construction	☐	Contractors Copy	☐

Drawn : Durgaa	Scale : NTS	Date: 01.06.'22
Checked : Divya	dwg no :	
Sign :		

drawing : Plot - 19A
Ground floor plan - Electrical layout

Project : Proposed development for Mr. Jayaraj - Signature Villas, Madurai

DESIGNWORKS
Architects | Interior Designers | Planners

First Floor, 33,Ranjit Road,
kotturpuram, Chennai - 600 085, India
Tel: +91- 44 - 4230 3731/32/33
Fax: +91- 44 - 42303734
E-mail: mail@designworks.in
Web: www.designworks.in

	DISTRIBUTION BOARD		CHANDILER LIGHT		SWITCH BOARD WITH 1No 5AMPS SOCKET @ 1'9" LVL		3/4" PVC PIPE ELECTRICAL
	A/C INDOOR UNIT		EXHAUST FAN		SWITCH BOARD WITH 1No 5AMPS SOCKET @ 4'0" LVL		1" PVC PIPE ELECTRICAL
	TABLE LAMP		15 AMPS SWITCH WITH SOCKET		AC STABILIZER		CEILING FAN
	TELEPHONE POINT		GEYSER 15 AMPS @ 9' HT.		TWO WAY SWITCH CONTROL		CEILING LIGHT
	MIRROR LIGHT		5 AMPS SWITCH WITH SOCKET		BUZZER		
	T.V POINT @ 4'6" lvl. 3" PVC PIPE		WALL LIGHT		BELL PUSH SWITCH		


3" Dia Pvc Pipe Concealed in Wall

F.F lvl


T.V Point provision

NOTE : Need to provide a dummy switch in switch board in every room

NOTES:
This drawing is the property of designworks & cannot be used or reproduced any form without their written permission.
Any discrepancy should be brought to the notice of the architects.
Only written dimensions should be followed, the drawing is not to be scaled.

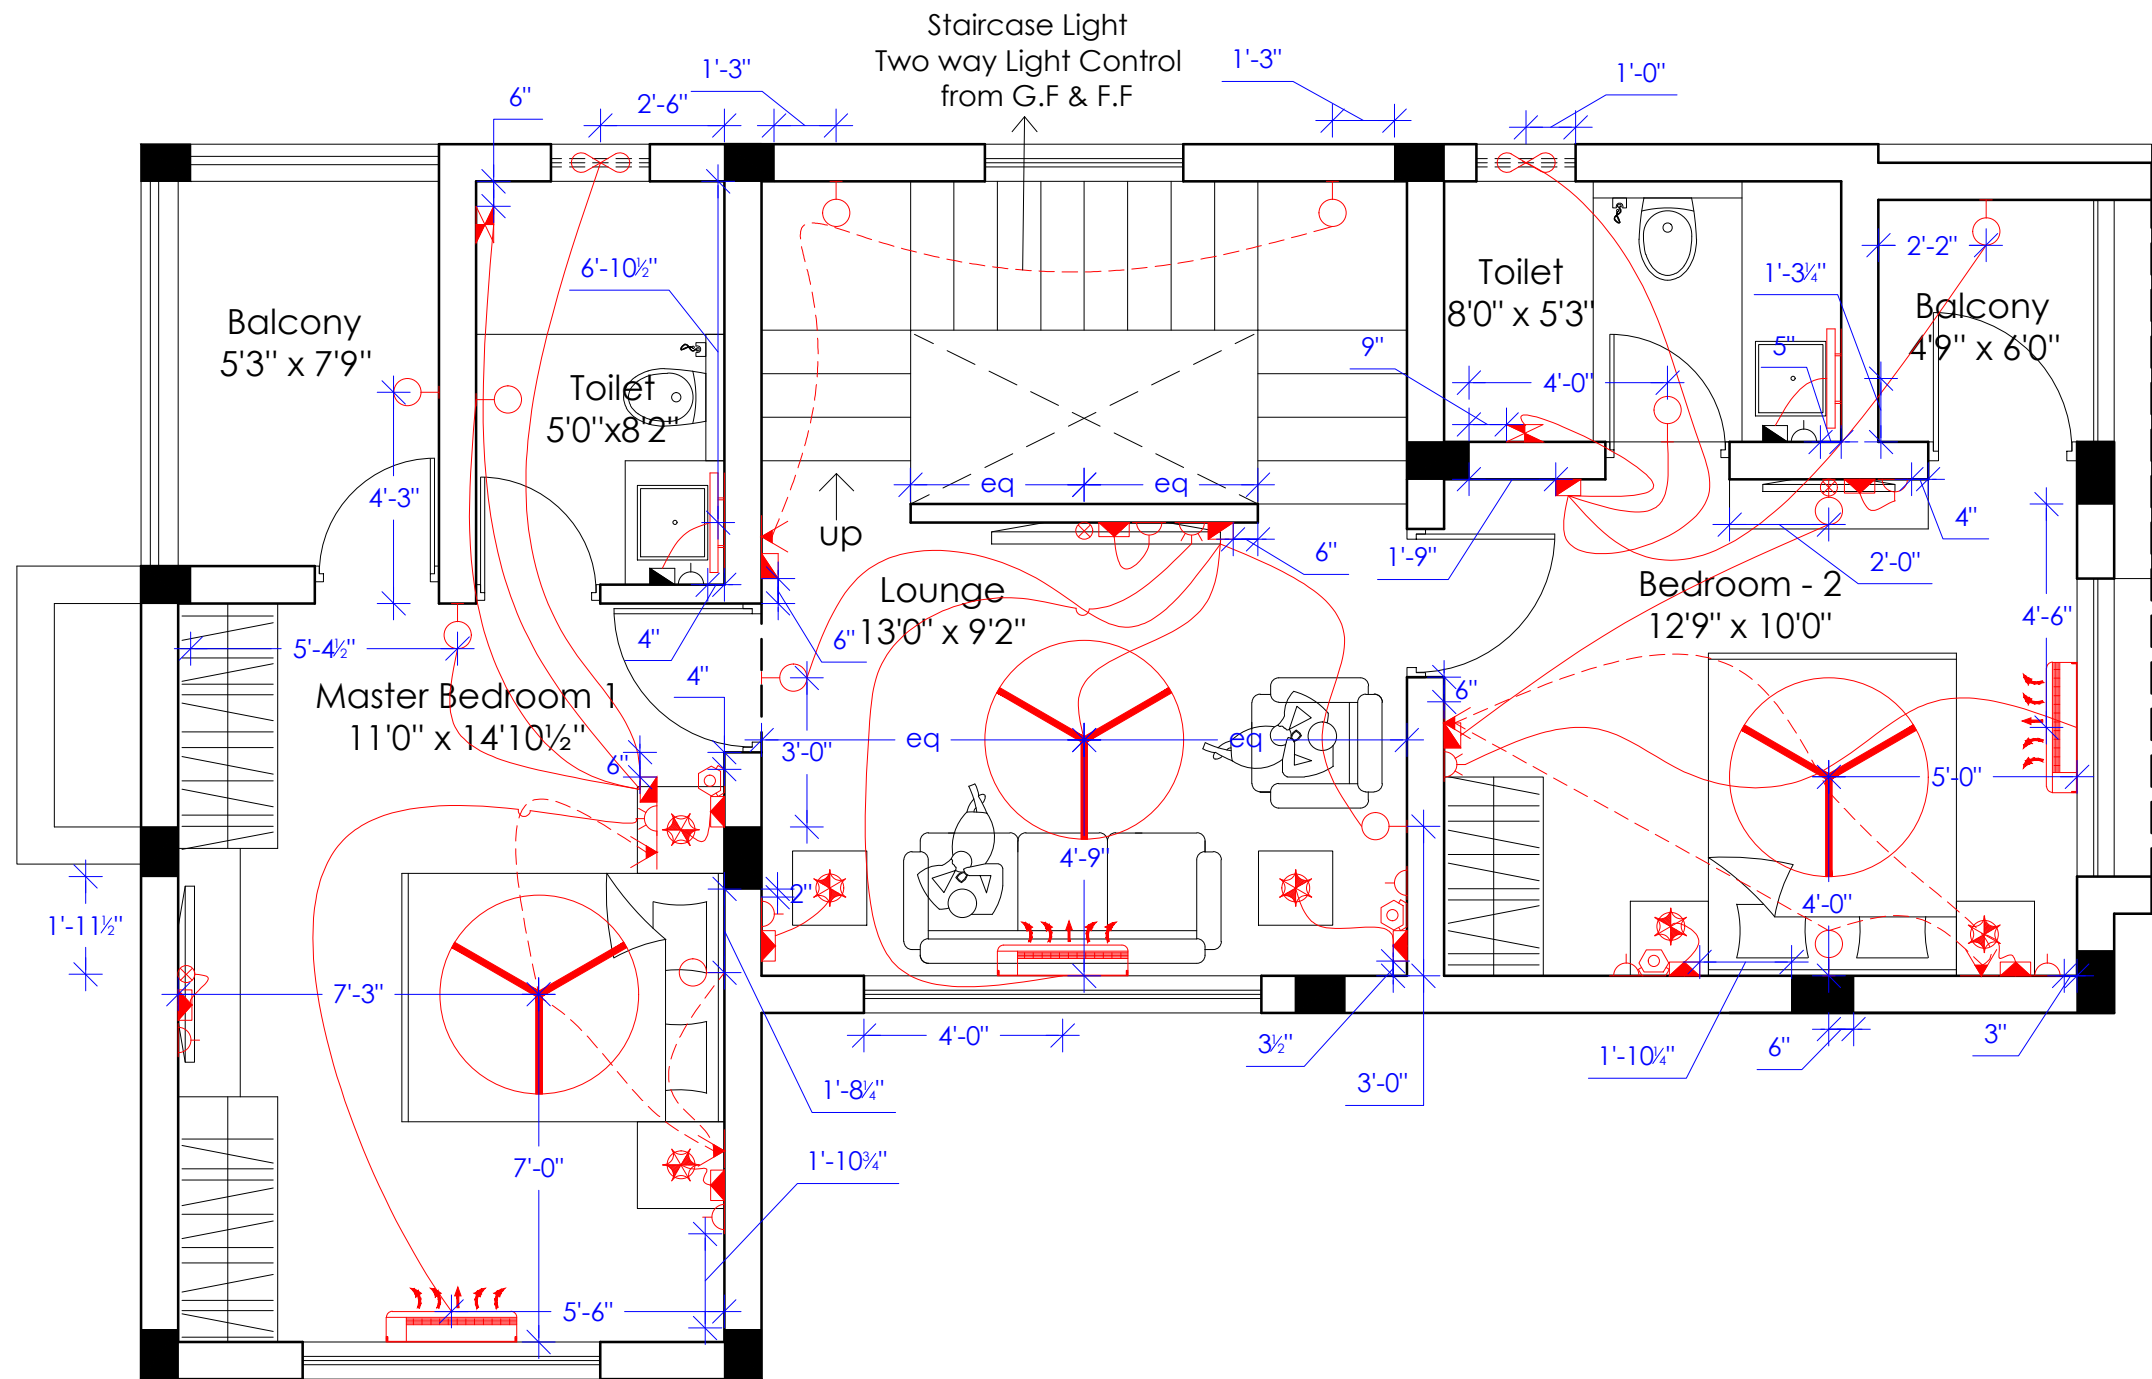

	DISTRIBUTION BOARD		CHANDILER LIGHT		SWITCH BOARD WITH 1No 5AMPS SOCKET @ 1'9" LVL
	A/C INDOOR UNIT		EXHAUST FAN		SWITCH BOARD WITH 1No 5AMPS SOCKET @ 4'0" LVL
	TABLE LAMP		15 AMPS SWITCH WITH SOCKET		AC STABILIZER
	TELEPHONE POINT		GEYSER 15 AMPS @ 9' HT.		TWO WAY SWITCH CONTROL
	MIRROR LIGHT		5 AMPS SWITCH WITH SOCKET		BUZZER
	T.V POINT @ 4'6" M. 3" PVC PIPE		WALL LIGHT		BELL PUSH SWITCH

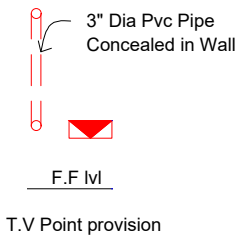

NOTE : Need to provide a dummy switch in switch board in every room

For Discussion	☐	Site Copy	☐
For Approval	☐	Clients Copy	☐
Good For Construction	☐	Contractors Copy	☐

Drawn : Durgaa	Scale : NTS	Date: 01.06.22
Checked : Divya	dwg no :	
Sign :		N

drawing : Plot - 19A
First floor plan -
Electrical layout


Project :
Proposed development for
Mr. Jayaraj - Signature Villas,
Madurai

DESIGNWORKS
Architects | Interior Designers | Planners
First Floor, 33,Ranjit Road,
kotturpuram, Chennai - 600 085, India
Tel: +91- 44 - 4230 3731/32/33
Fax: +91- 44 - 42303734
E-mail: mail@designworks.in
Web: www.designworks.in

NOTES:
This drawing is the property of designworks & cannot be used or reproduced any form without their written permission.

Any discrepancy should be brought to the notice of the architects.

Only written dimensions should be followed, the drawing is not to be scaled.

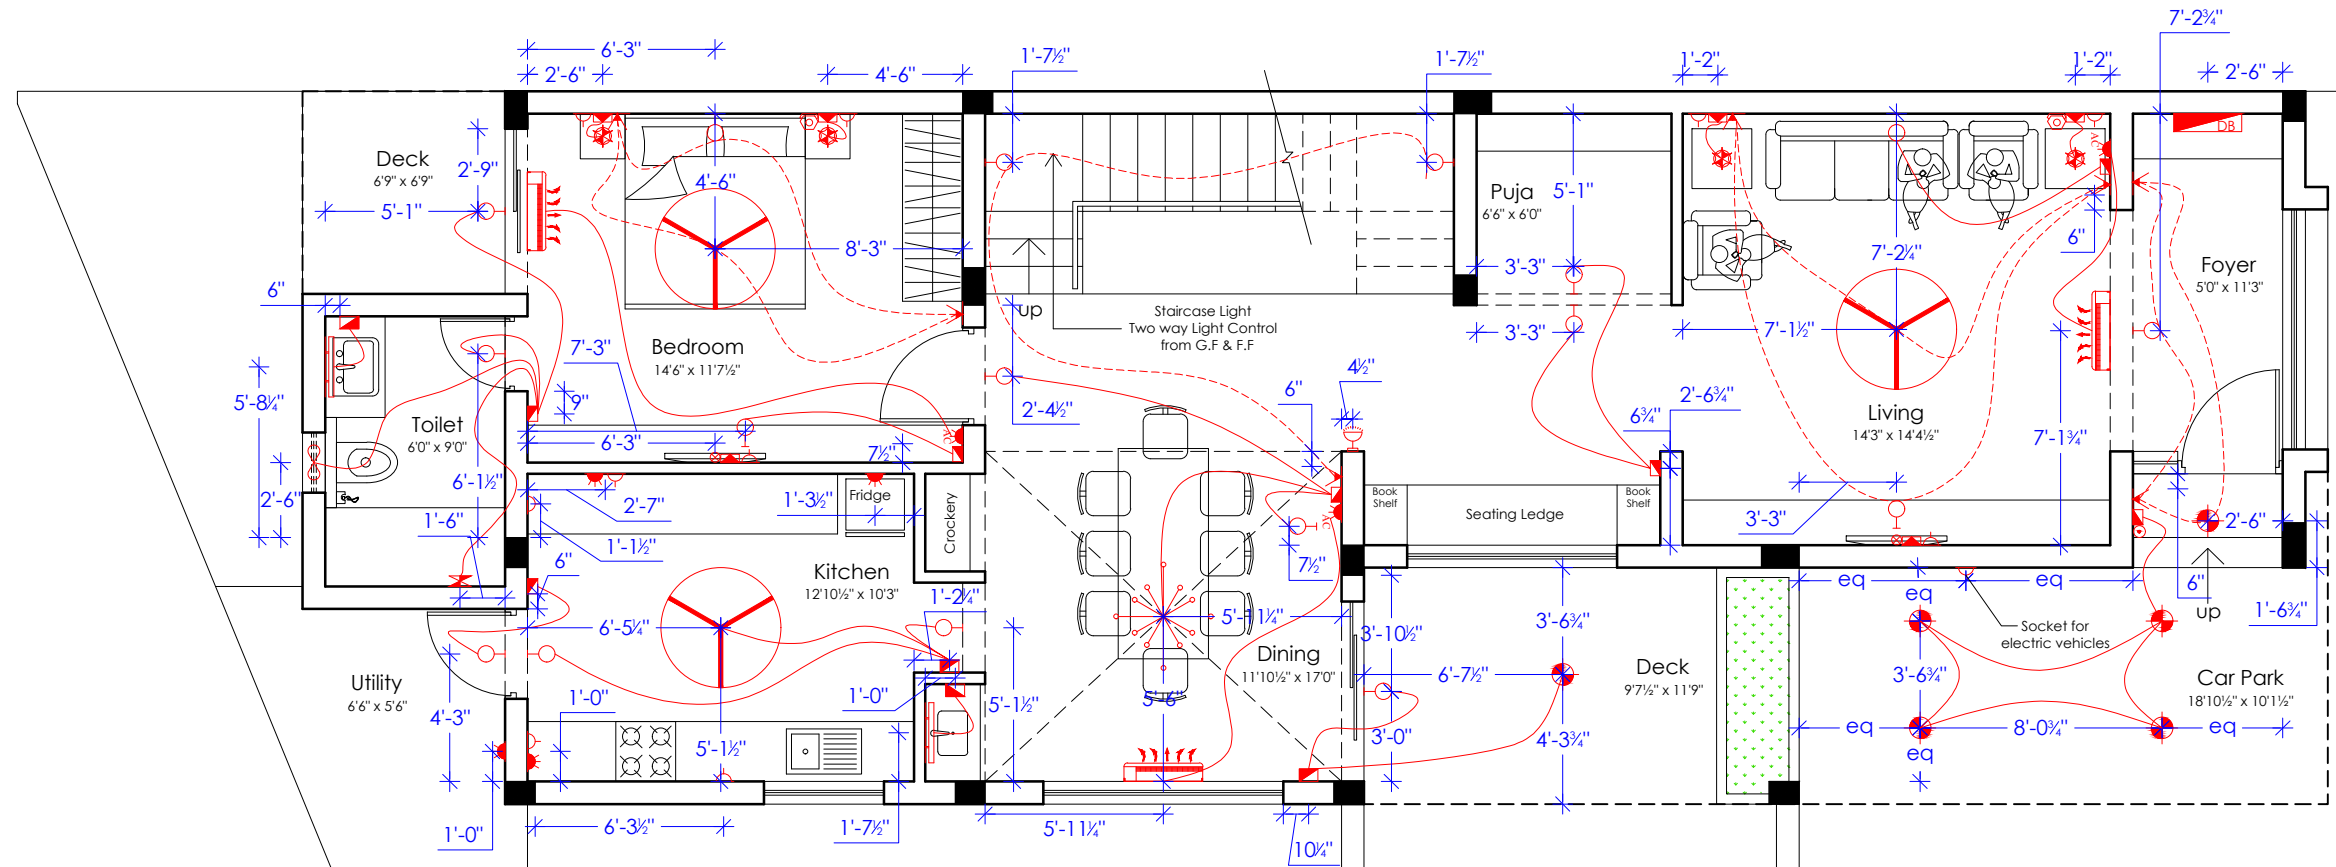

	DISTRIBUTION BOARD		CHANDLER LIGHT		SWITCH BOARD WITH 1No 5AMPS SOCKET @ 1'9" LVL		3/4" PVC PIPE electrical
	A/C INDOOR UNIT		EXHAUST FAN		SWITCH BOARD WITH 1No 5AMPS SOCKET @ 4'0" LVL		1" PVC PIPE electrical
	TABLE LAMP		15 AMPS Switch with Socket		CEILING LIGHT		CEILING FAN
	TELEPHONE POINT		GEYSER 15 amp @ 9' HT		TWO WAY SWITCH CONTROL		
	MIRROR LIGHT		5 AMPS Switch with Socket		BUZZER		
	T.V Point @ 4'6" Lvl 3" Pvc Pipe		WALL LIGHT		BELL PUSH SWITCH		

3" Dia Pvc Pipe
Concealed in Wall

F.F Lvl

T.V Point provision

drawing : plot - 15
Ground floor plan (NF)
Electrical layout

Project :
proposed residential development
for Mr. Jayaraj @ Madurai

DESIGNWORKS
Architects | Interior Designers | Planners


First Floor, 33.Ranjit Road,
kotturpuram, Chennai - 600 085, India
Tel: +91- 44 - 4230 3731/32/33
Fax: +91- 44 - 42303734
E-mail: mail@designworks.in
Web: www.designworks.in

NOTE : Need to provide a dummy switch in switch board in every room

NOTES:
This drawing is the property of designworks & cannot be used or reproduced any form without their written permission.

Any discrepancy should be brought to the notice of the architects.

Only written dimensions should be followed, the drawing is not to be scaled.

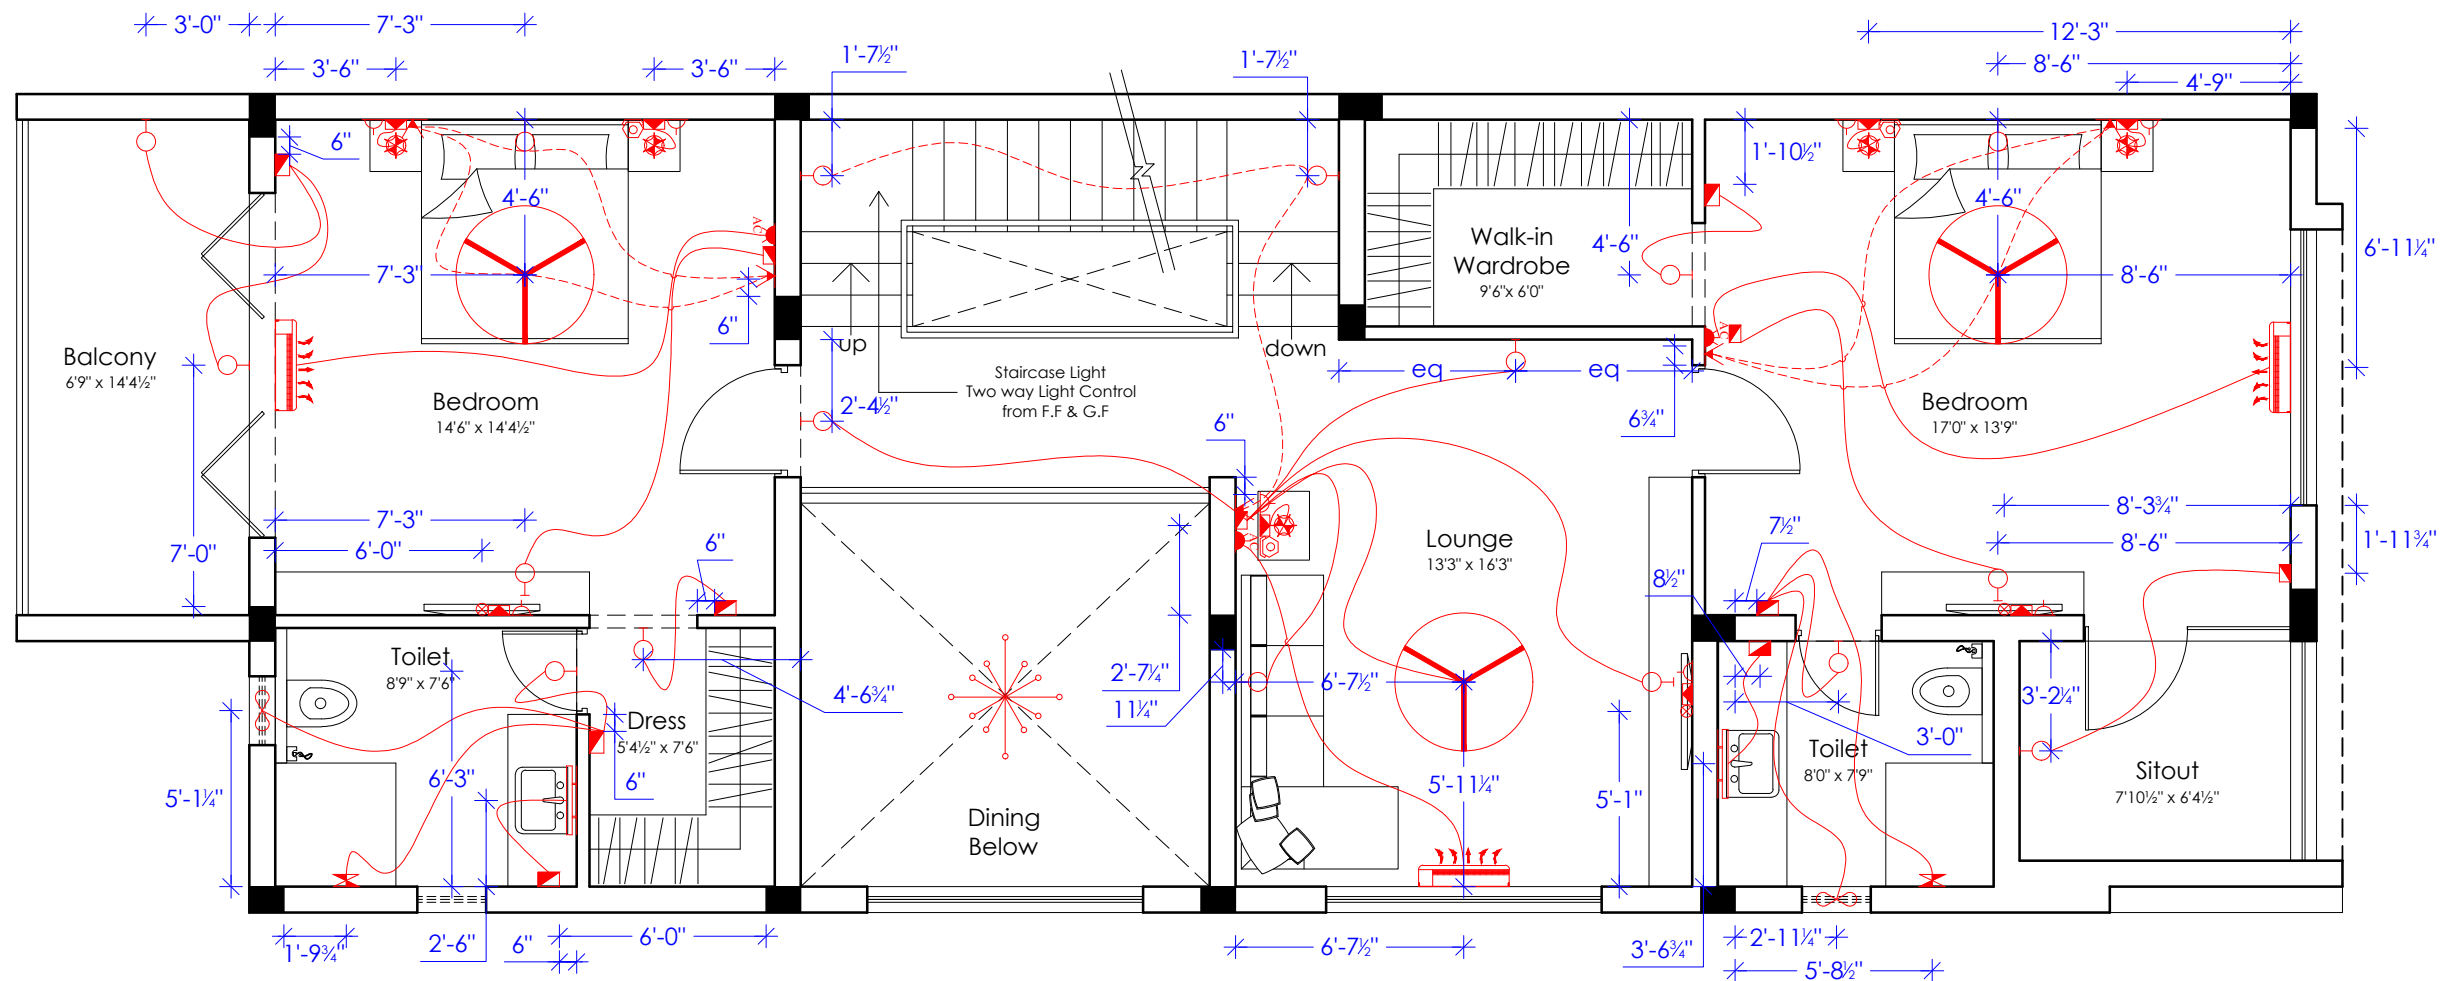

	DISTRIBUTION BOARD		CHANDILER LIGHT		SWITCH BOARD WITH 1No 5AMPS SOCKET @ 1'9" LVL		3/4" PVC PIPE electrical
	A/C INDOOR UNIT		EXHAUST FAN		SWITCH BOARD WITH 1No 5AMPS SOCKET @ 4'0" LVL		1" PVC PIPE electrical
	TABLE LAMP		15 AMPS Switch with Socket		CEILING LIGHT		CEILING FAN
	TELEPHONE POINT		GEYSER 15 amp @ 9' HT		TWO WAY SWITCH CONTROL		
	MIRROR LIGHT		5 AMPS Switch with Socket		BUZZER		
	T.V Point @ 4'6" Lvl 3" Pvc Pipe		WALL LIGHT		BELL PUSH SWITCH		

3" Dia Pvc Pipe
Concealed in Wall

F.F Lvl
T.V Point provision

drawing : plot - 15
First floor plan (NF)
Electrical layout

Project :
proposed residential development
for Mr. Jayaraj @ Madurai

DESIGNWORKS
Architects | Interior Designers | Planners


First Floor, 33.Ranjit Road,
kotturpuram, Chennai - 600 085, India
Tel: +91- 44 - 4230 3731/32/33
Fax: +91- 44 - 42303734
E-mail: mail@designworks.in
Web: www.designworks.in

NOTE : Need to provide a dummy switch in switch board in every room

NOTES:
This drawing is the property of designworks & cannot be used or reproduced any form without their written permission.

Any discrepancy should be brought to the notice of the architects.

Only written dimensions should be followed, the drawing is not to be scaled.

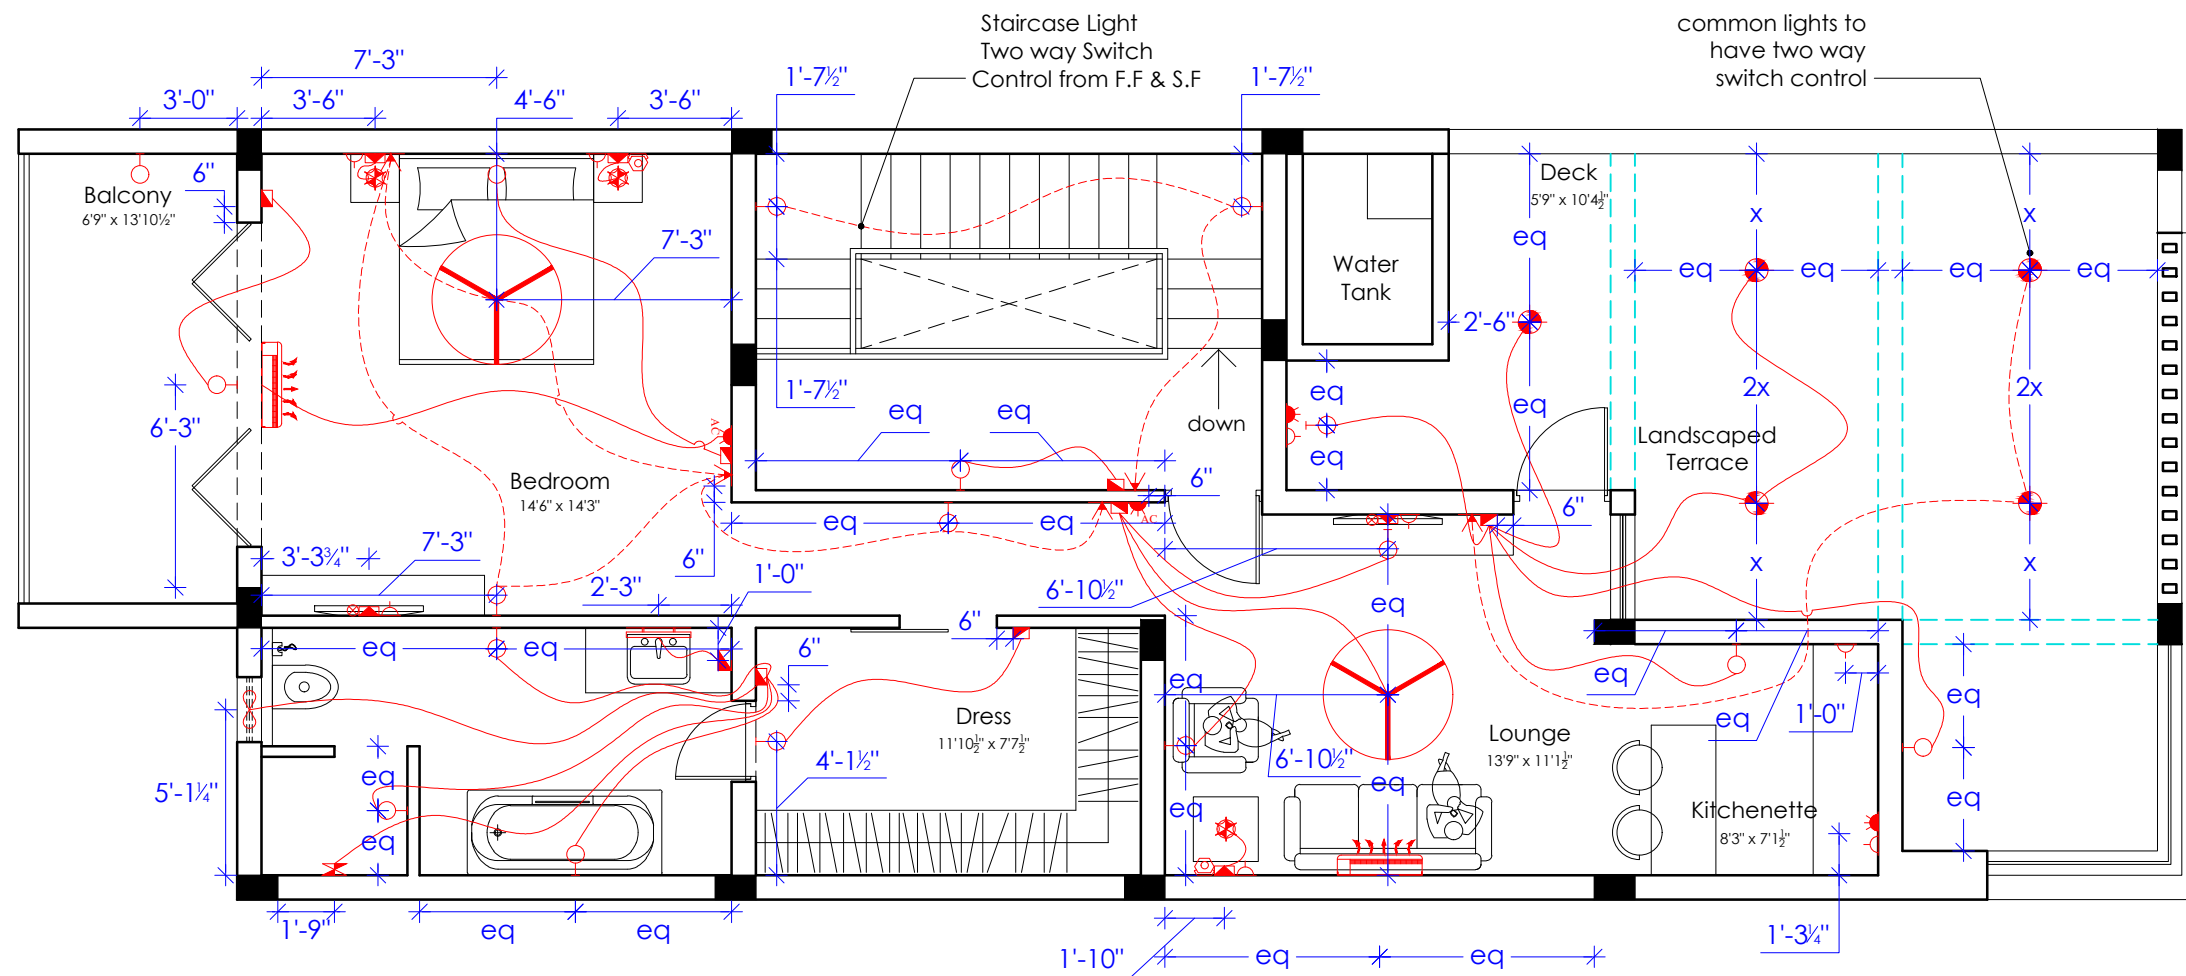

	DISTRIBUTION BOARD		CHANDILER LIGHT		SWITCH BOARD WITH 1No 5AMPS SOCKET @ 1'9" LVL		3/4" PVC PIPE electrical
	A/C INDOOR UNIT		EXHAUST FAN		SWITCH BOARD WITH 1No 5AMPS SOCKET @ 4'0" LVL		1" PVC PIPE electrical
	TABLE LAMP		15 AMPS Switch with Socket		CEILING LIGHT		CEILING FAN
	TELEPHONE POINT		GEYSER 15 amp @ 9' HT		TWO WAY SWITCH CONTROL		
	MIRROR LIGHT		5 AMPS Switch with Socket		BUZZER		
	T.V Point @ 4'6" Lvl 3" Pvc Pipe		WALL LIGHT		BELL PUSH SWITCH		

3" Dia Pvc Pipe Concealed in Wall

F.F M

T.V Point provision

NOTE : Need to provide a dummy switch in switch board in every room

For Discussion	☐	Site Copy	☐
For Approval	☐	Clients Copy	☐
Good For Construction	☐	Contractors Copy	☐


Drawn : Durgaa	Scale : nts	Date: 23.09/22
Checked : Divya Sign :	dwg no :	

drawing : plot - 15
Second floor plan (NF)
Electrical layout

Project :
Proposed residential development
for Mr. Jayaraj @ Madurai

DESIGNWORKS
Architects | Interior Designers | Planners

First Floor, 33.Ranjit Road,
kotturpuram, Chennai - 600 085, India
Tel: +91 - 44 - 4230 3731/32/33
Fax: +91 - 44 - 42303734
E-mail: mail@designworks.in
Web: www.designworks.in

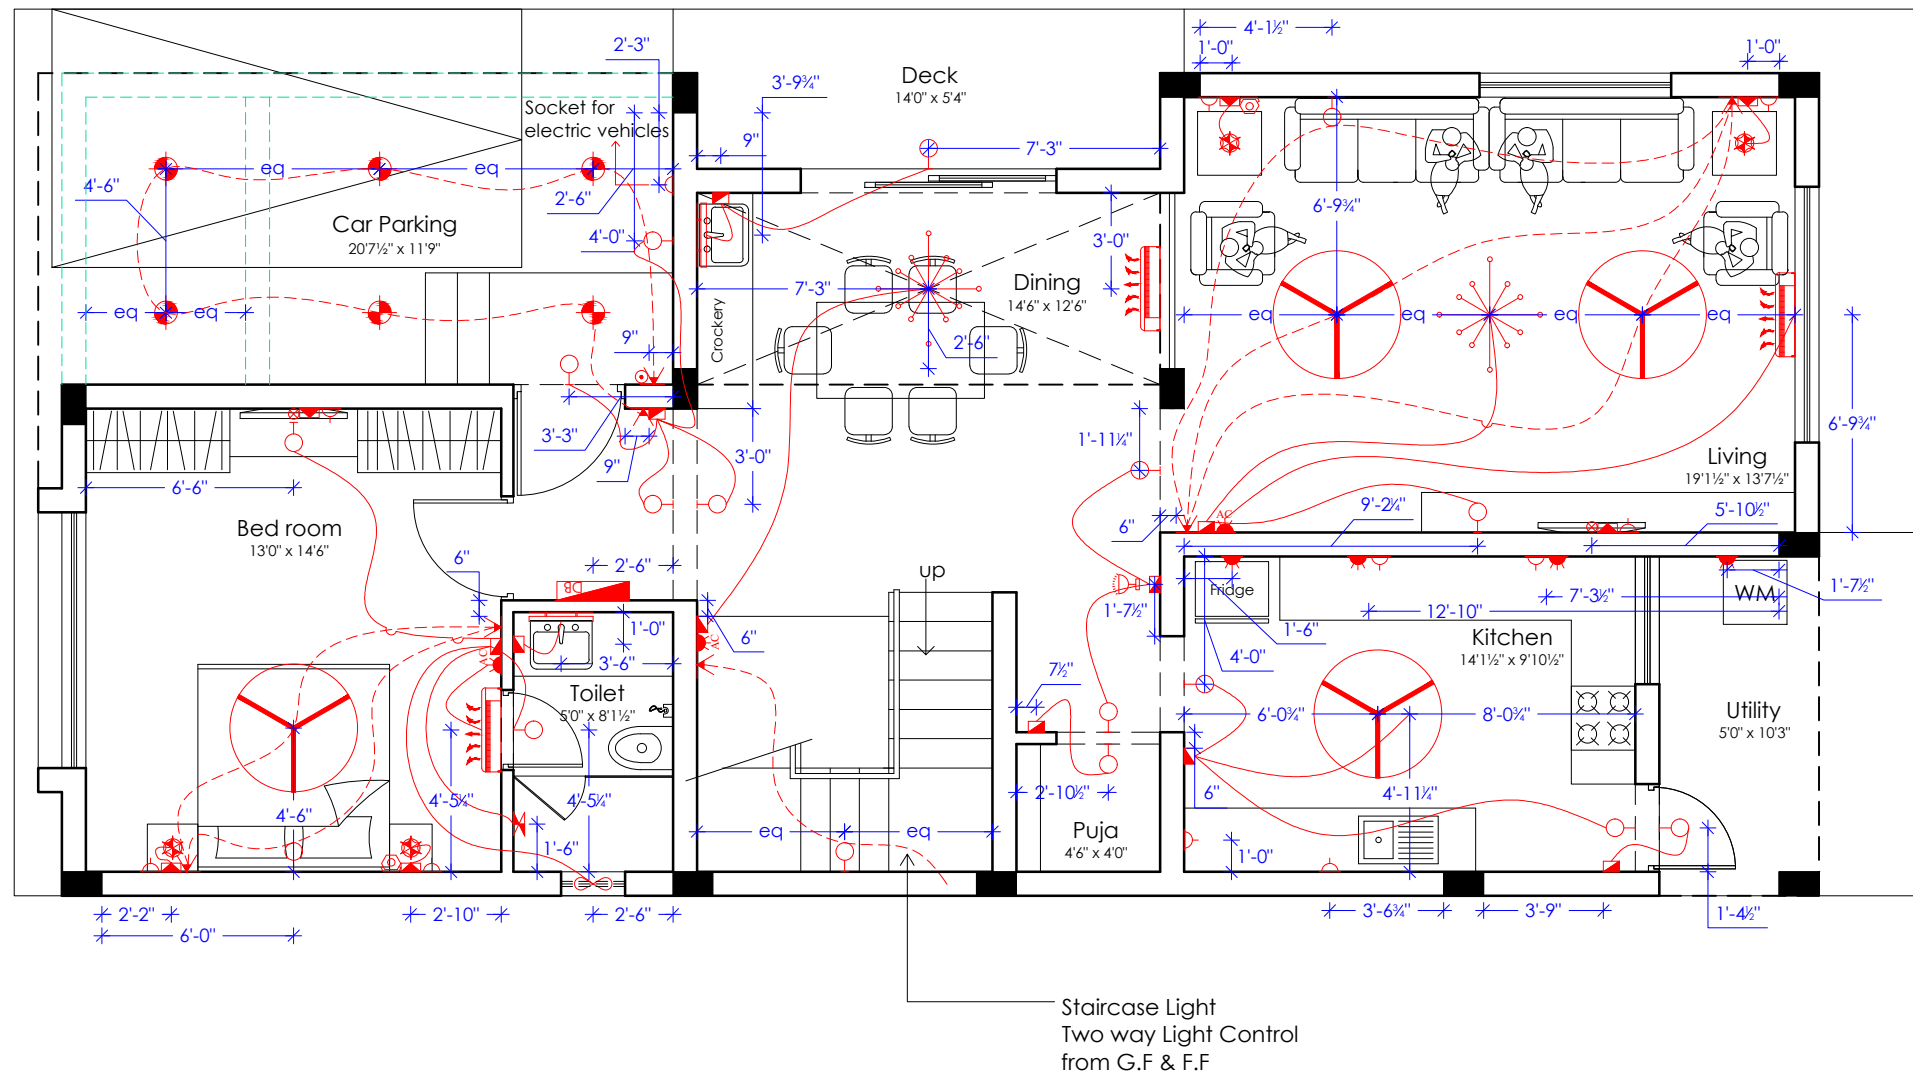

	DISTRIBUTION BOARD		CHANDLER LIGHT		SWITCH BOARD WITH 1No 5AMPS SOCKET @ 1'9" LVL		3/4" PVC PIPE electrical
	A/C INDOOR UNIT		EXHAUST FAN		SWITCH BOARD WITH 1No 5AMPS SOCKET @ 4'0" LVL		1" PVC PIPE electrical
	TABLE LAMP		15 AMPS Switch with Socket		CEILING LIGHT		CEILING FAN
	TELEPHONE POINT		GEYSER 15 amp @ 9' HT		TWO WAY SWITCH CONTROL		
	MIRROR LIGHT		5 AMPS Switch with Socket		BUZZER		
	T.V Point @ 4'6" Lvl 3" Pvc Pipe		WALL LIGHT		BELL PUSH SWITCH		

3" Dia Pvc Pipe
Concealed in Wall

F.F M

T.V Point provision

NOTE : Need to provide a dummy switch in switch board in every room

NOTES:
This drawing is the property of designworks & cannot be used or reproduced any form without their written permission.

Any discrepancy should be brought to the notice of the architects.

Only written dimensions should be followed, the drawing is not to be scaled.

For Discussion	☐	Site Copy	☐
For Approval	☐	Clients Copy	☐
Good For Construction	☐	Contractors Copy	☐

Drawn : Durgaa	Scale : NTS	Date : 08.08.22
Checked : Divya Sign :	dwg no :	

drawing : plot - 18
ground floor plan (WF)
Electrical layout

Project :
Proposed residential development
for Mr. Jayaraj @ Madurai


DESIGNWORKS
Architects | Interior Designers | Planners

First Floor, 33.Ranjit Road,
kotturpuram, Chennai - 600 085, India
Tel: +91- 44 - 4230 3731/32/33
Fax: +91- 44 - 42303734
E-mail: mail@designworks.in
Web: www.designworks.in

NOTES:
This drawing is the property of designworks & cannot be used or reproduced any form without their written permission.

Any discrepancy should be brought to the notice of the architects.

Only written dimensions should be followed, the drawing is not to be scaled.

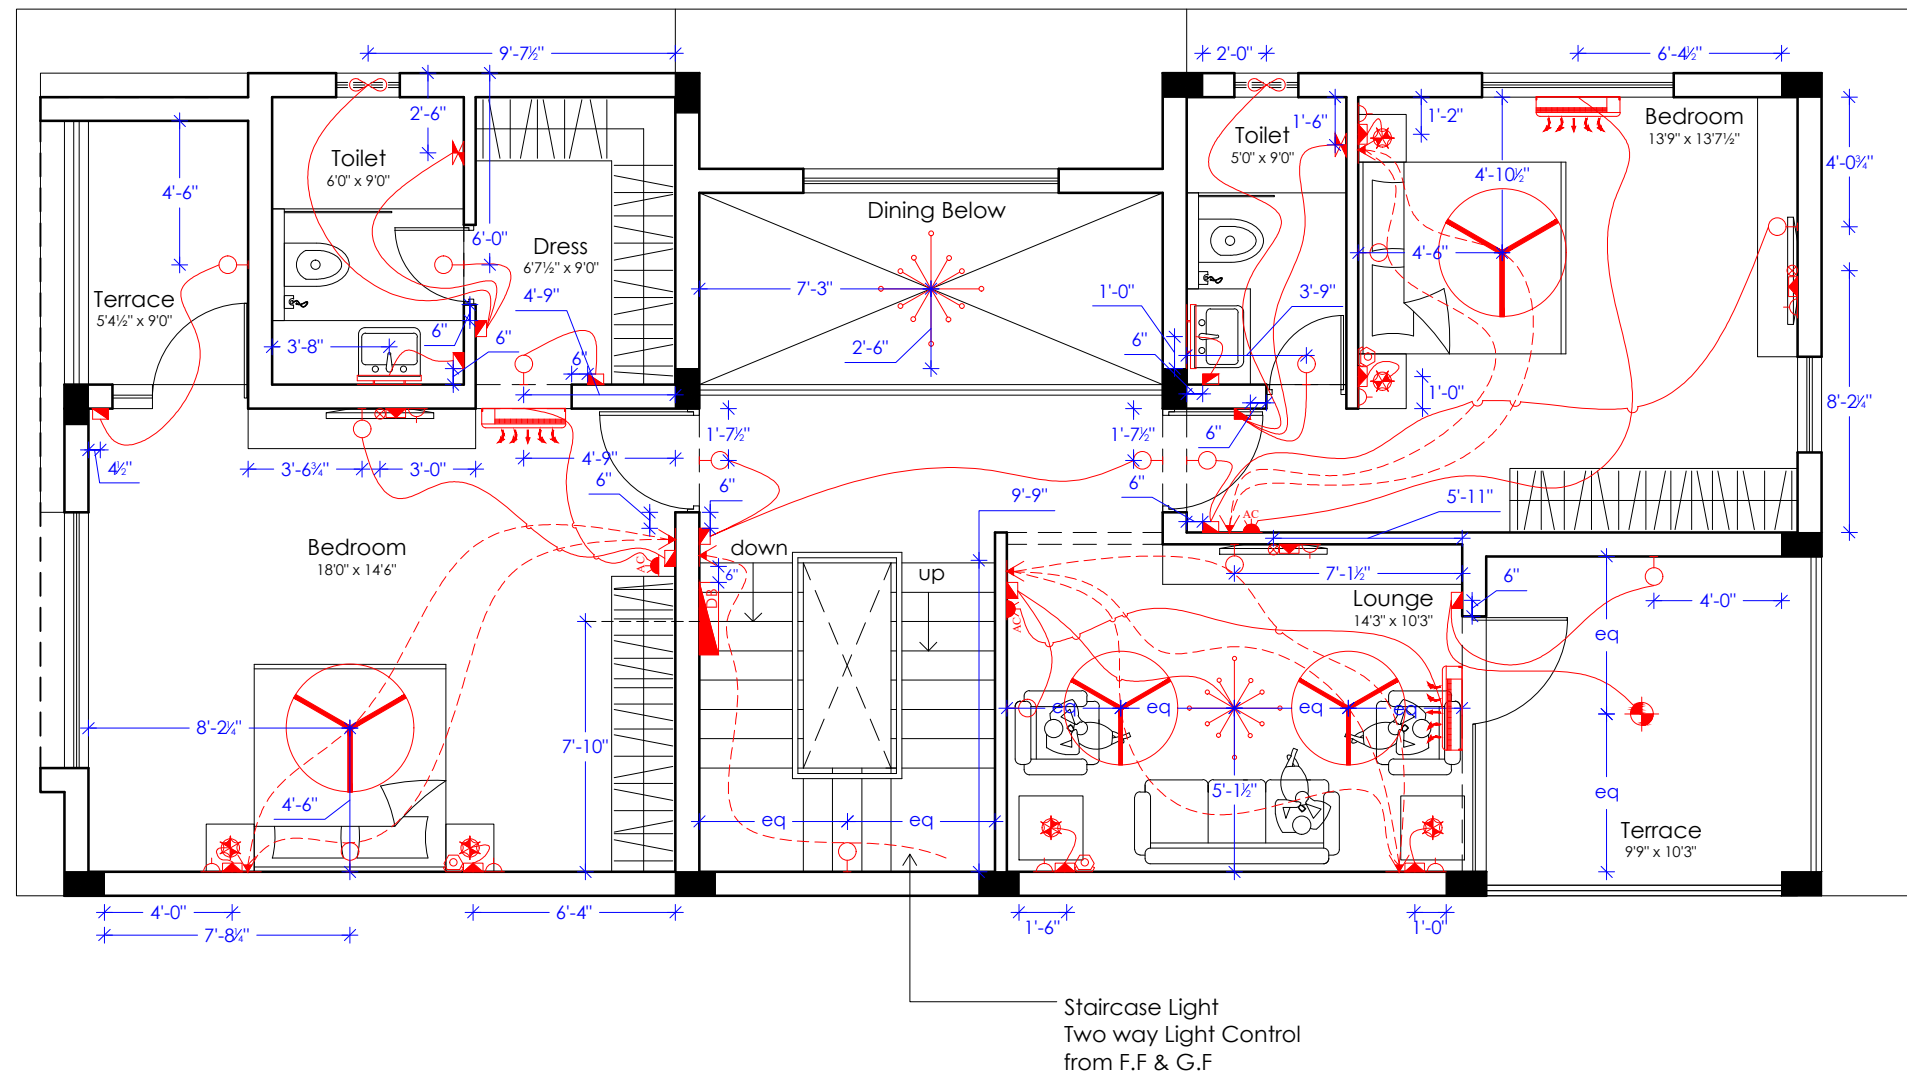

	DISTRIBUTION BOARD		CHANDLER LIGHT		SWITCH BOARD WITH 1No 5AMPS SOCKET @ 1'9" LVL		3/4" PVC PIPE electrical
	A/C INDOOR UNIT		EXHAUST FAN		SWITCH BOARD WITH 1No 5AMPS SOCKET @ 4'0" LVL		1" PVC PIPE electrical
	TABLE LAMP		15 AMPS Switch with Socket		CEILING LIGHT		CEILING FAN
	TELEPHONE POINT		GEYSER 15 amp @ 9' HT		TWO WAY SWITCH CONTROL		
	MIRROR LIGHT		5 AMPS Switch with Socket		BUZZER		
	T.V Point @ 4'6" Lvl 3" Pvc Pipe		WALL LIGHT		BELL PUSH SWITCH		

3" Dia Pvc Pipe
Concealed in Wall

F.F lvl

T.V Point provision

NOTE : Need to provide a dummy switch in switch board in every room

For Discussion	☐	Site Copy	☐
For Approval	☐	Clients Copy	☐
Good For Construction	☐	Contractors Copy	☐


Drawn : Durgaa	Scale : NTS	Date : 08.08.22
Checked : Divya Sign :	dwg no :	

drawing : plot - 18
First floor plan (WF)
Electrical layout

Project :
Proposed residential development
for Mr. Jayaraj @ Madurai

DESIGNWORKS
Architects | Interior Designers | Planners

First Floor, 33.Ranjit Road,
kotturpuram, Chennai - 600 085, India
Tel: +91- 44 - 4230 3731/32/33
Fax: +91- 44 - 42303734
E-mail: mail@designworks.in
Web: www.designworks.in

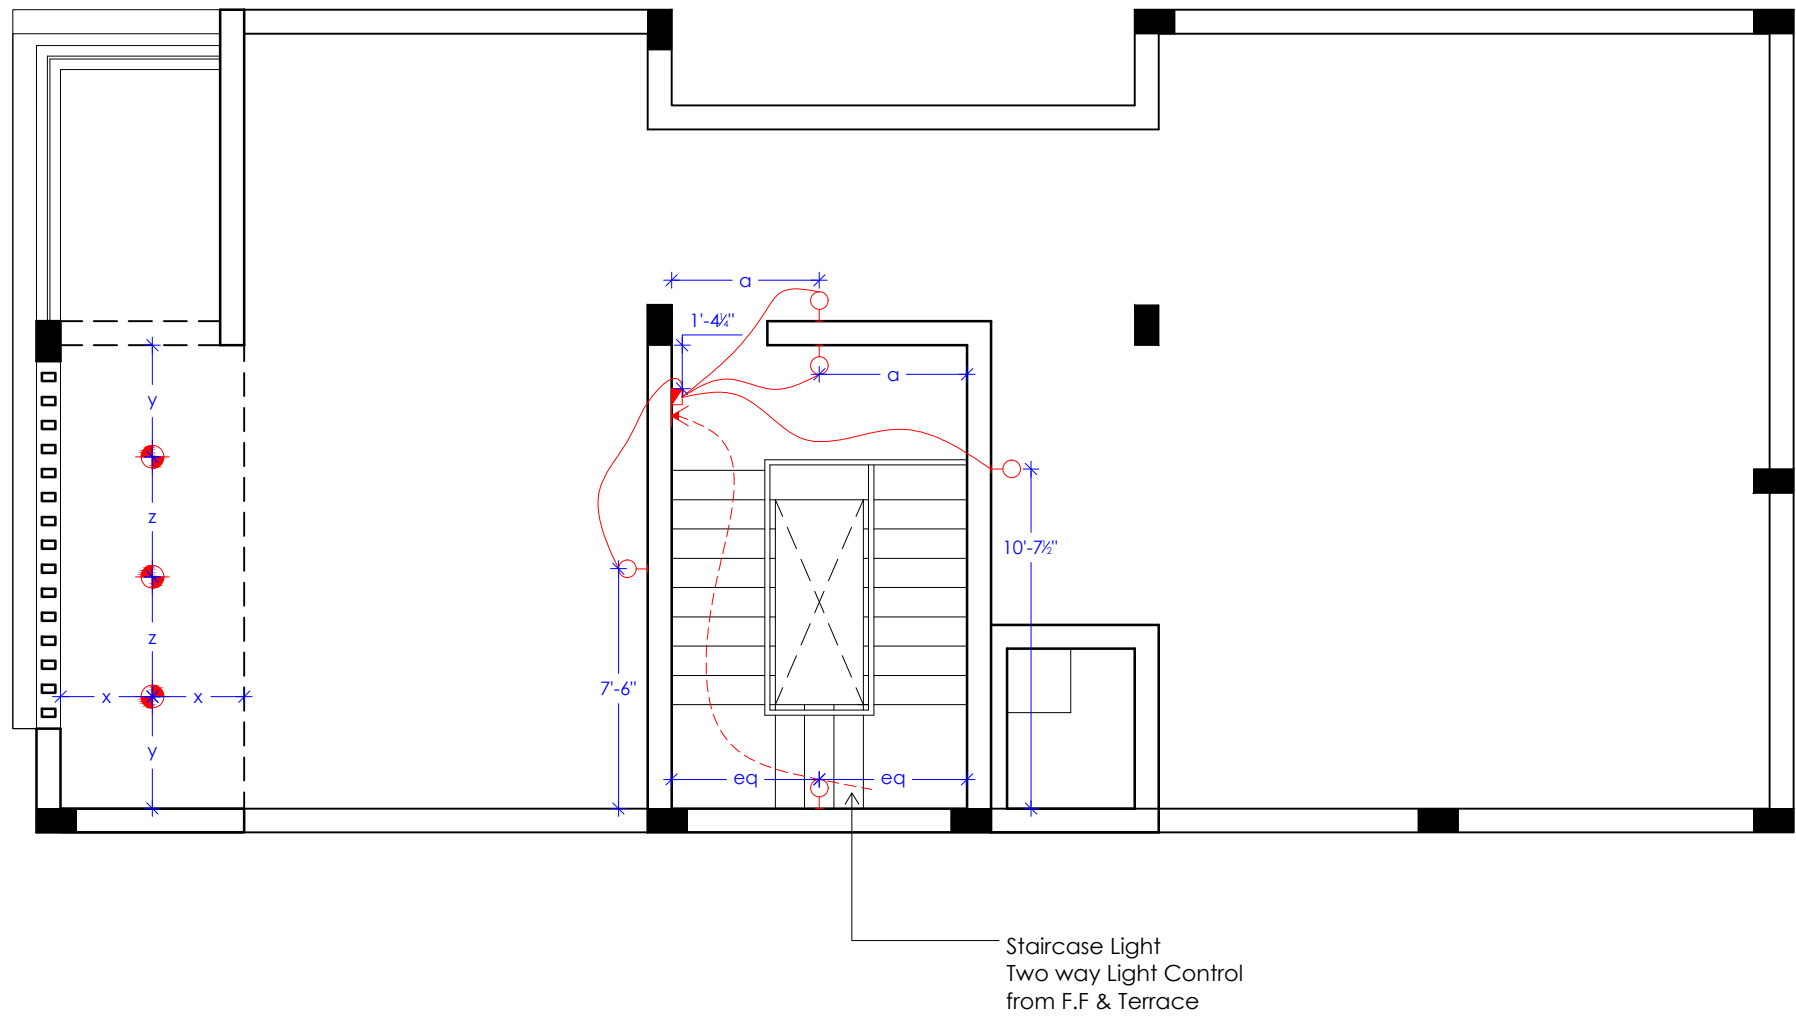

Staircase Light
Two way Light Control
from F.F & Terrace

	DISTRIBUTION BOARD		CHANDILER LIGHT		SWITCH BOARD WITH 1No 5AMPS SOCKET @ 1'9" LVL		3/4" PVC PIPE electrical
	A/C INDOOR UNIT		EXHAUST FAN		SWITCH BOARD WITH 1No 5AMPS SOCKET @ 4'0" LVL		1" PVC PIPE electrical
	TABLE LAMP		15 AMPS Switch with Socket		CEILING LIGHT		CEILING FAN
	TELEPHONE POINT		GEYSER 15 amp @ 9' HT		TWO WAY SWITCH CONTROL		
	MIRROR LIGHT		5 AMPS Switch with Socket		BUZZER		
	T.V Point @ 4'6" Lvl 3" Pvc Pipe		WALL LIGHT		BELL PUSH SWITCH		

NOTE : Need to provide a dummy switch in switch board in every room

NOTE : All common lights will be connected to the common switch board

NOTES:
This drawing is the property of designworks & cannot be used or reproduced any form without their written permission.

Any discrepancy should be brought to the notice of the architects.

Only written dimensions should be followed, the drawing is not to be scaled.

For Discussion	☐	Site Copy	☐
For Approval	☐	Clients Copy	☐
Good For Construction	☐	Contractors Copy	☐

Drawn : Durgaa	Scale : NTS	Date : 08.08'22
Checked : Divya Sign :	dwg no :	

drawing : plot - 18
Terrace floor plan (WF)
Electrical layout

Project :
Proposed residential development
for Mr. Jayaraj @ Madurai


DESIGNWORKS
Architects | Interior Designers | Planners

First Floor, 33.Ranjit Road,
kotturpuram, Chennai - 600 085, India
Tel: +91- 44 - 4230 3731/32/33
Fax: +91- 44 - 42303734
E-mail: mail@designworks.in
Web: www.designworks.in

NOTES:
This drawing is the property of
designworks & cannot be used or
reproduced any form without their
written permission.

Any discrepancy should be brought
to the notice of the architects.


Only written dimensions should be
followed, the drawing is not to be
scaled.

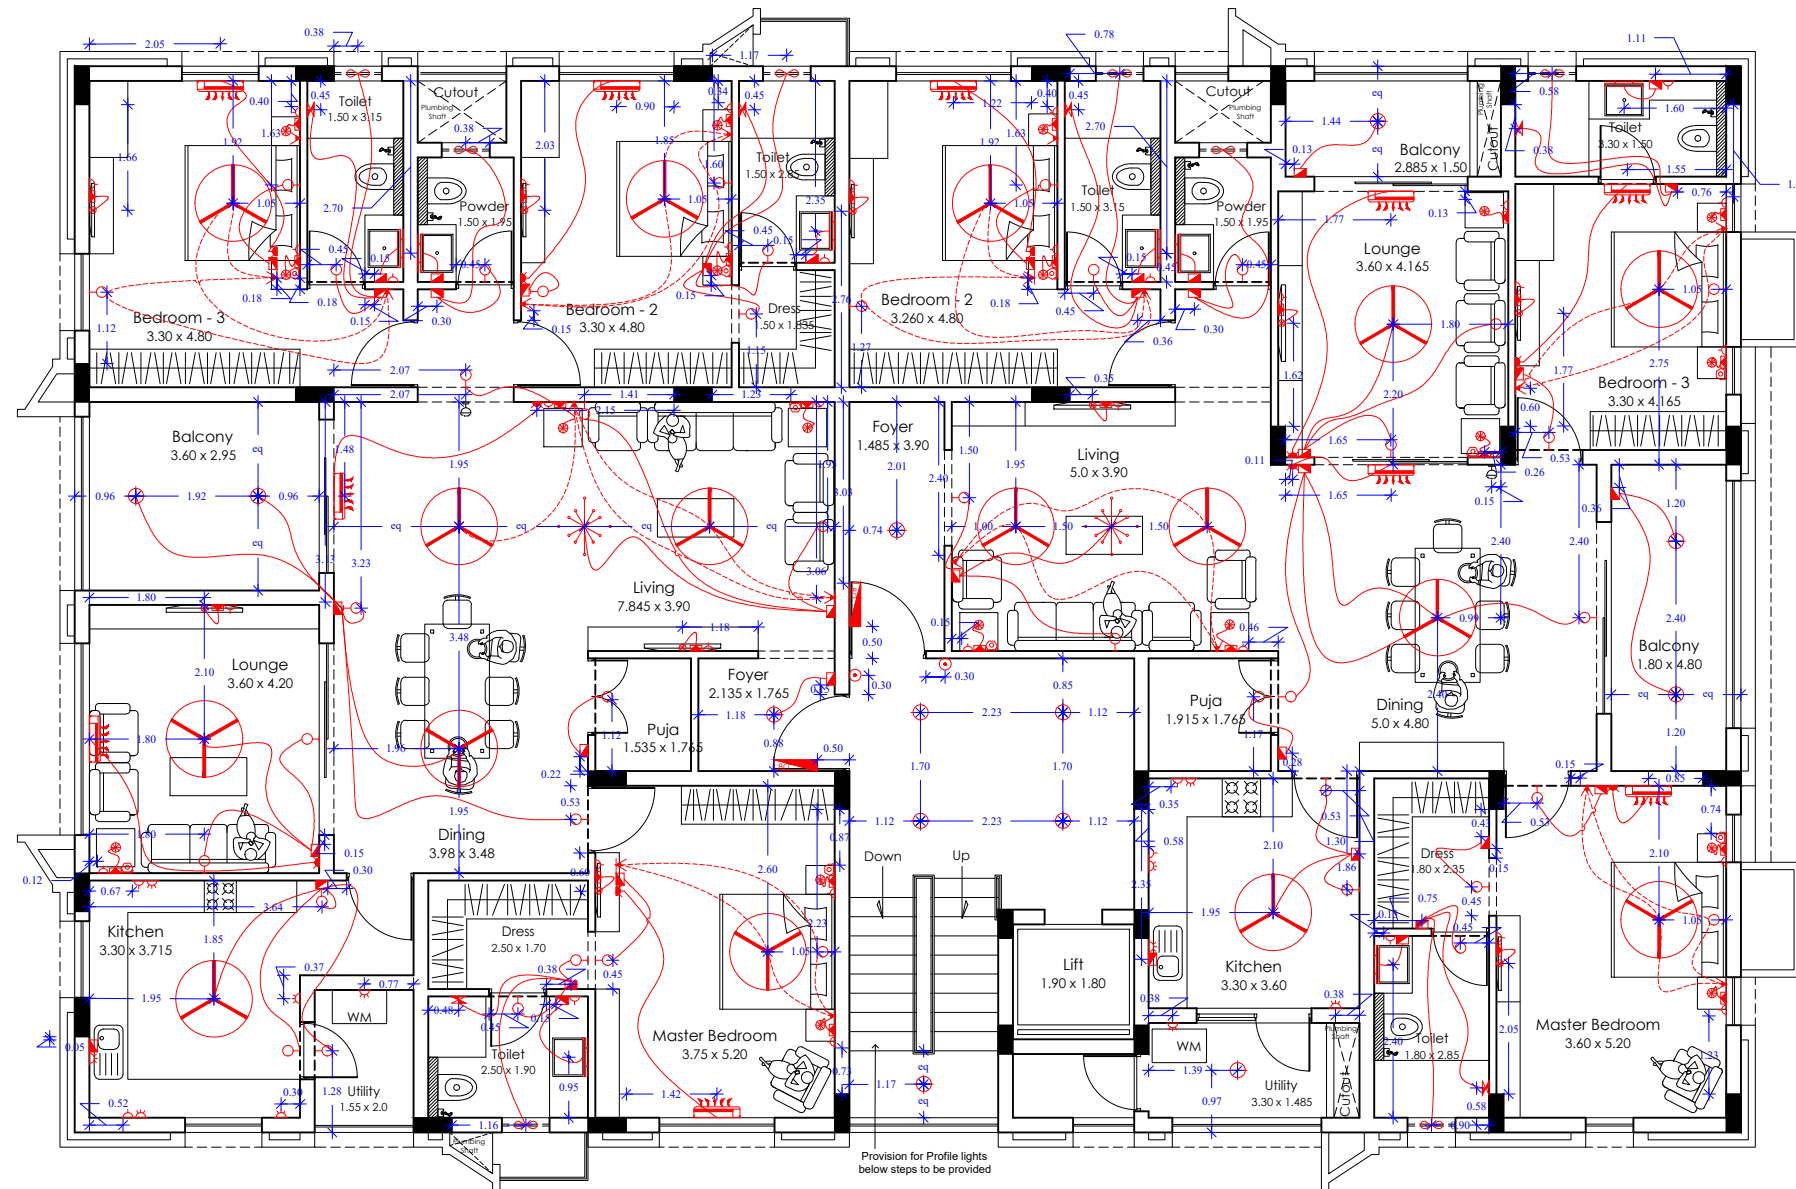

Provision for Profile lights
below steps to be provided

	DISTRIBUTION BOARD		CHANDILER LIGHT		SWITCH BOARD WITH 1No 5AMPS SOCKET @ 1'9" LVL		3/4" PVC PIPE electrical
	A/C INDOOR UNIT		EXHAUST FAN		SWITCH BOARD WITH 1No 5AMPS SOCKET @ 4'0" LVL		1" PVC PIPE electrical
	SUSPENDED LIGHT		15 AMPS Switch with Socket		CEILING LIGHT		CEILING FAN
	TELEPHONE POINT		GEYSER 15 amp @ 9' HT		TWO WAY SWITCH CONTROL		BELL PUSH SWITCH
	MIRROR LIGHT		5 AMPS Switch with Socket		AC socket		
	T.V Point @ 4'6" Lvl 3" Pvc Pipe		WALL LIGHT		BUZZER		

NOTE : Need to provide a dummy switch in switch board in every room

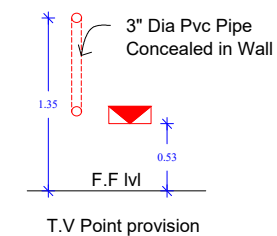

For Discussion	☐	Site Copy	☐
For Approval	☐	Clients Copy	☐
Good For Construction	☐	Contractors Copy	☐

Drawn : Durgaa	Scale : NTS	Date : 20.06.'22
Checked : Rajesh Sign :	dwg no :	


File Path:

drawing :
First floor - Electrical Layout

project :
PROPOSED APARTMENT FOR LANDMARK
@ VALMIKI NAGAR, T.NAGAR

DESIGNWORKS

First Floor, 33,Ranjit Road,
kotturpuram, Chennai - 600 085, India
Tel: +91- 44 - 4230 3731/32/33
Fax: +91- 44 - 42303734
E-mail: mail@designworks.in
Web: www.designworks.in

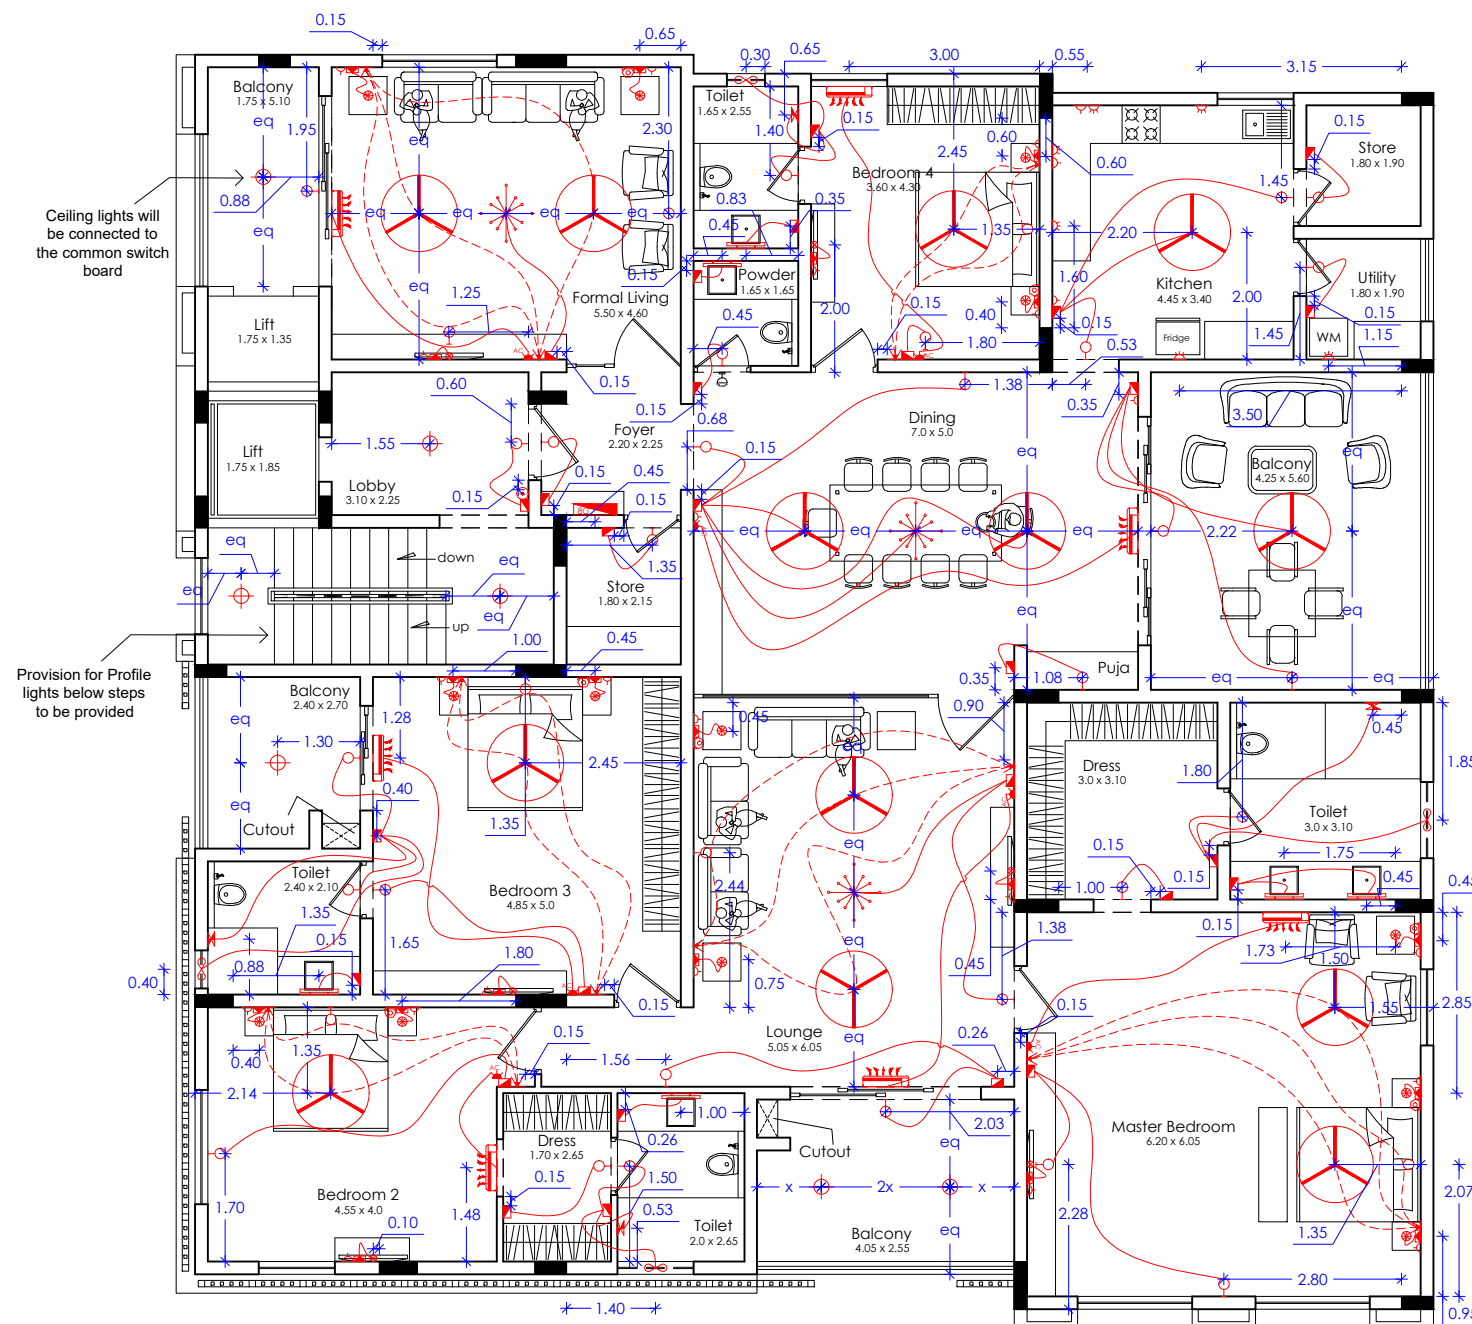

NOTES:
This drawing is the property of designworks & cannot be used or reproduced any form without their written permission.

Any discrepancy should be brought to the notice of the architects.

Only written dimensions should be followed, the drawing is not to be scaled.

For Discussion	☐	Site Copy	☐
For Approval	☐	Clients Copy	☐
Good For Construction	☐	Contractors Copy	☐

Drawn : Durgaa	Scale : NTS	Date : 09.08.22
Checked : Rajesh	dwg no :	


drawing :
Electrical layout

project :
Proposed Apartment
@ Pycrofts Road


DESIGNWORKS
Architects | Interior Designers | Planners

First Floor, 33, Ranjit Road,
Kotturpuram, Chennai - 600 085, India
Tel: +91- 44 - 4230 3731/32/33
Fax: +91- 44 - 42303734
E-mail: mail@designworks.in
Web: www.designworks.in




	DISTRIBUTION BOARD		CHANDILER LIGHT		SWITCH BOARD WITH 1No 5AMPS SOCKET @ 1'9" LVL		3/4" PVC PIPE electrical
	A/C INDOOR UNIT		EXHAUST FAN		SWITCH BOARD WITH 1No 5AMPS SOCKET @ 4'0" LVL		1" PVC PIPE electrical
	SUSPENDE LIGHT		15 AMPS Switch with Socket		CEILING LIGHT		CEILING FAN
	TELEPHONE POINT		GEYSER 15 amp @ 9' HT		TWO WAY SWITCH CONTROL		BELL PUSH SWITCH
	MIRROR LIGHT		5 AMPS Switch with Socket		AC socket		
	T.V Point @ 4'6" Lvl 3" Pvc Pipe		WALL LIGHT		BUZZER		

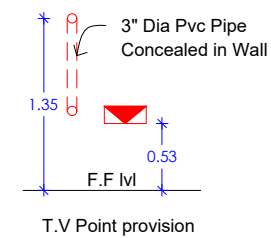

NOTE : Need to provide a dummy switch in switch board in every room

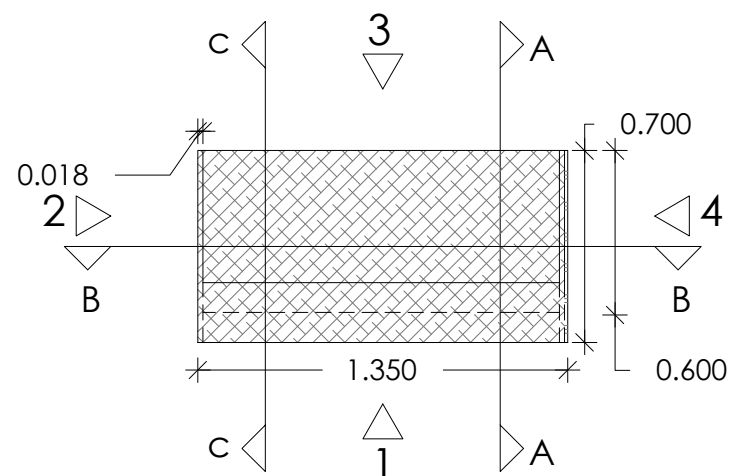


TOP VIEW

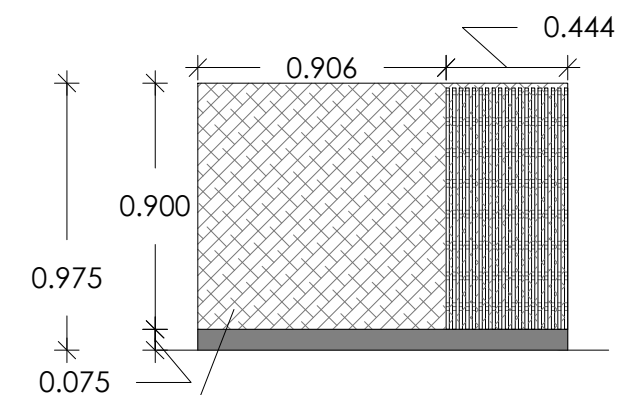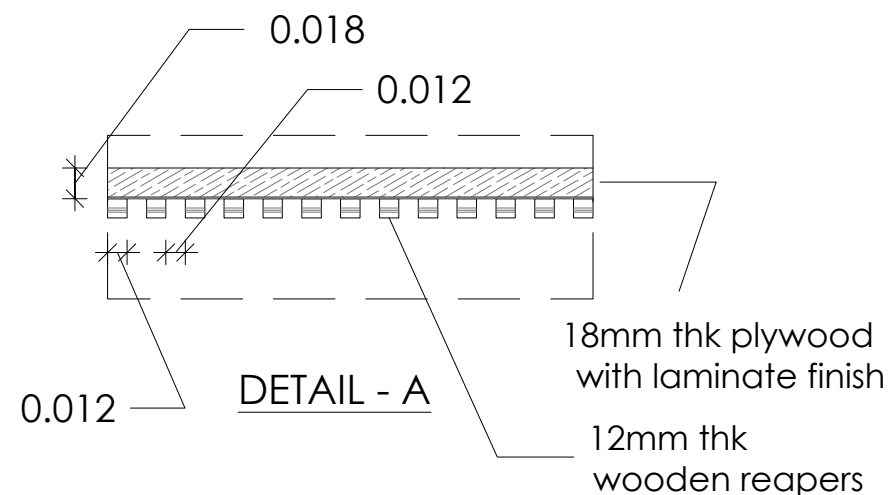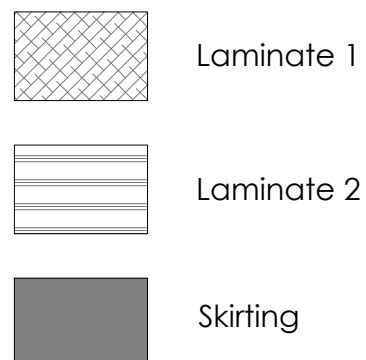


ELEVATION 1


Plywood Table finished with Laminate

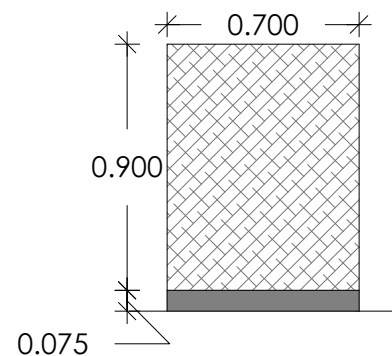


ELEVATION 2

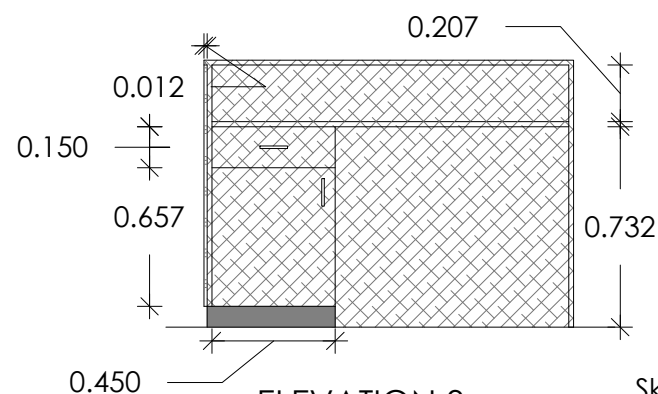


ELEVATION 3

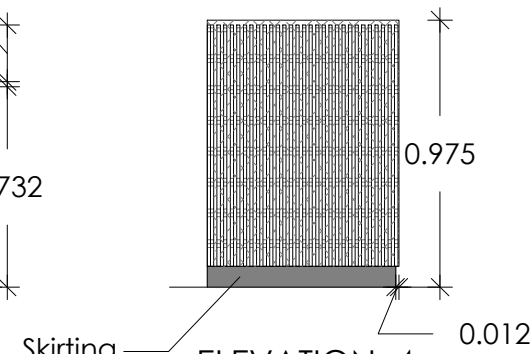


ELEVATION 4

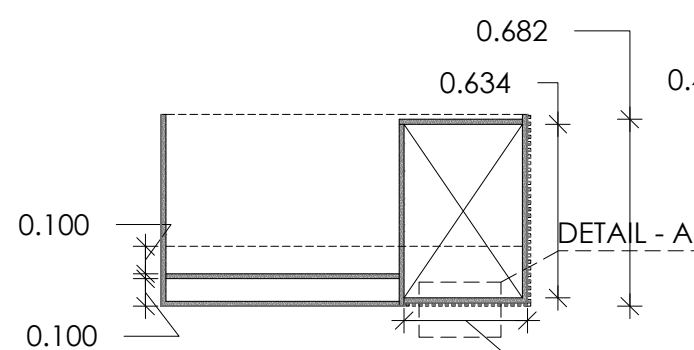


PLAN @ 1 Ft. LEVEL

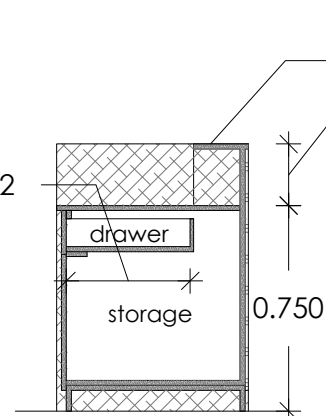

SECTION AA

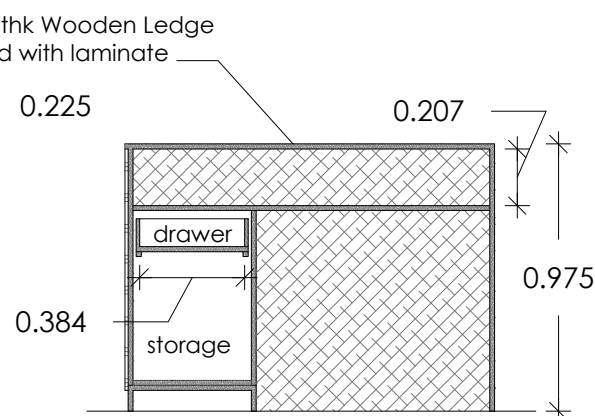

SECTION BB

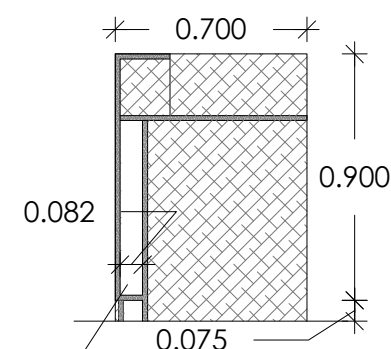

SECTION CC

Plywood boxing finished with Laminate

- NOTES:
- This drawing is the property of designworks & cannot be used or reproduced in any form without their written permission.
 - Any discrepancy should be brought to the notice of the architects.
 - Only written dimensions should be followed, the drawing is not to be scaled.

remarks:

For Discussion	☐	Site Copy	☐
For Approval	☐	Clients Copy	☐
Good For Construction	☐	Contractors Copy	☐

Drawn : Durgaa	Scale : NTS	Date : 04.07.22
Checked : Divya Sign :	Sheet No :	

File Path:


drawing:
Club house - Reception Table detail

project:
Proposed residential development @ Sholinganallur for Adroit developers

DESIGNWORKS
Architects | Interior Designers | Planners

33, First Floor, Ranjith Road,
Kotturpuram, Chennai - 600 085.
Tel: +91- 44 - 4230 3732/33
E-mail: mail@designworks.in
Web: www.designworks.in

TITLE OF THE PROJECT	:	THYAGRAJAN RESIDENCE
PROJECT TYPOLOGY	:	RESIDENCE - RENOVATION
CLIENT	:	Mr. THYAGRAJAN
LOCATION	:	MRC NAGAR, CHENNAI
PROJECT STATUS	:	COMPLETED

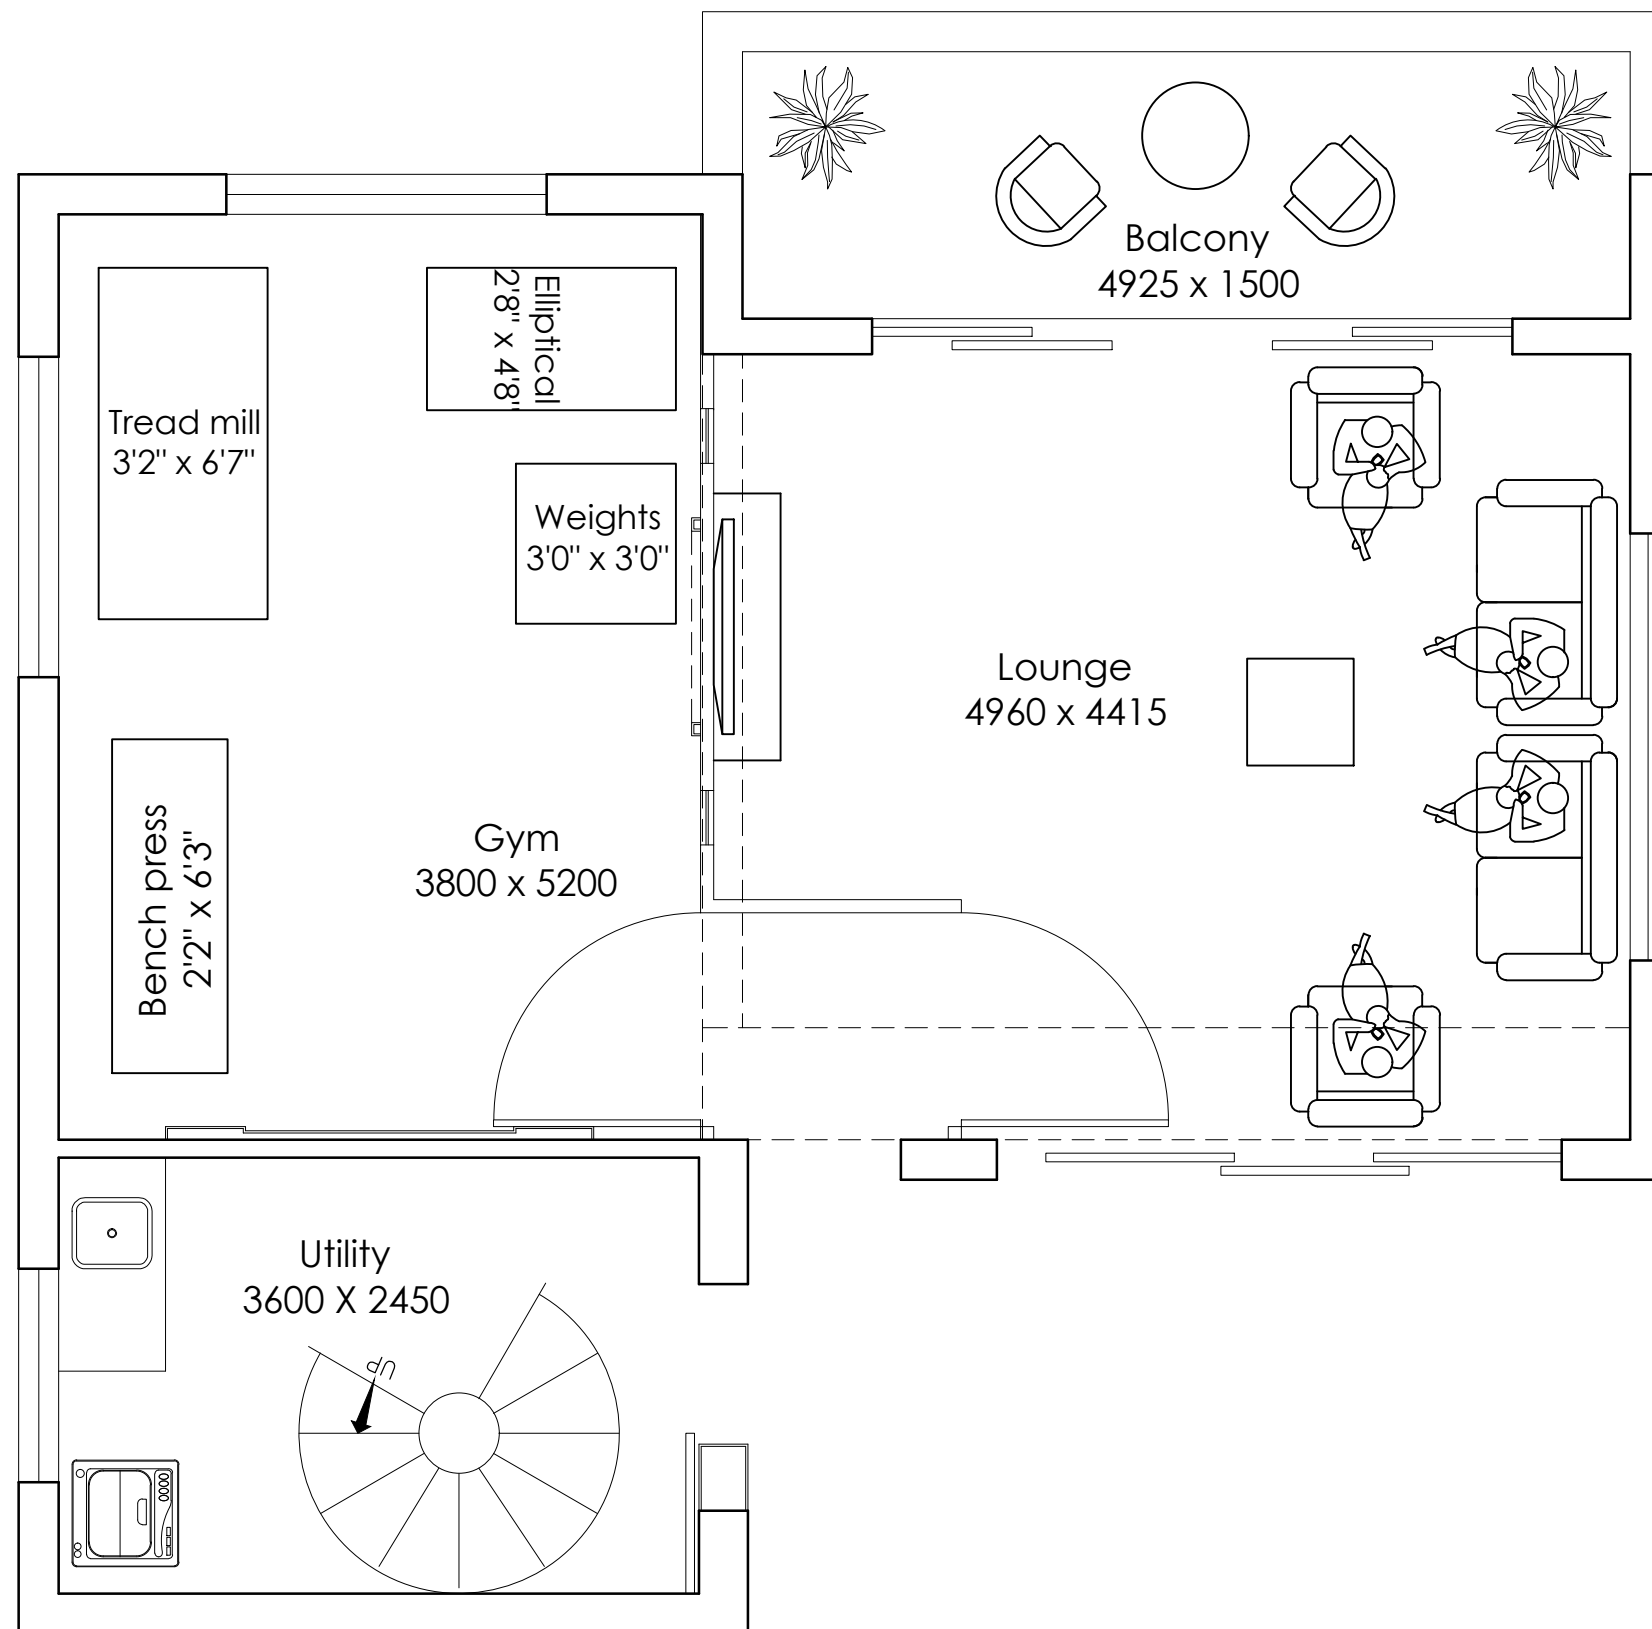

NOTES:
This drawing is the property of designworks & cannot be used or reproduced any form without their written permission.

Any discrepancy should be brought to the notice of the architects.

Only written dimensions should be followed, the drawing is not to be scaled.

For Discussion	☐	Site Copy	☐
For Approval	☐	Clients Copy	☐
Good For Construction	☐	Contractors Copy	☐


Drawn : Durgaa	Scale :	Date : 07.07.'22
Checked : Divya Sign :	dwg no :	
File Path :		


drawing:
Second Floor Plan -
Furniture layout


project:
Proposed Residence for
Mr. Thyagrajan @ M.R.C nagar


DESIGNWORKS

 
First Floor, 33,Ranjit Road,
kotturpuram, Chennai - 600 085, India
Tel: +91 - 44 - 4230 3731/32/33
Fax: +91 - 44 - 42303734
E-mail: mail@designworks.in
Web: www.designworks.in

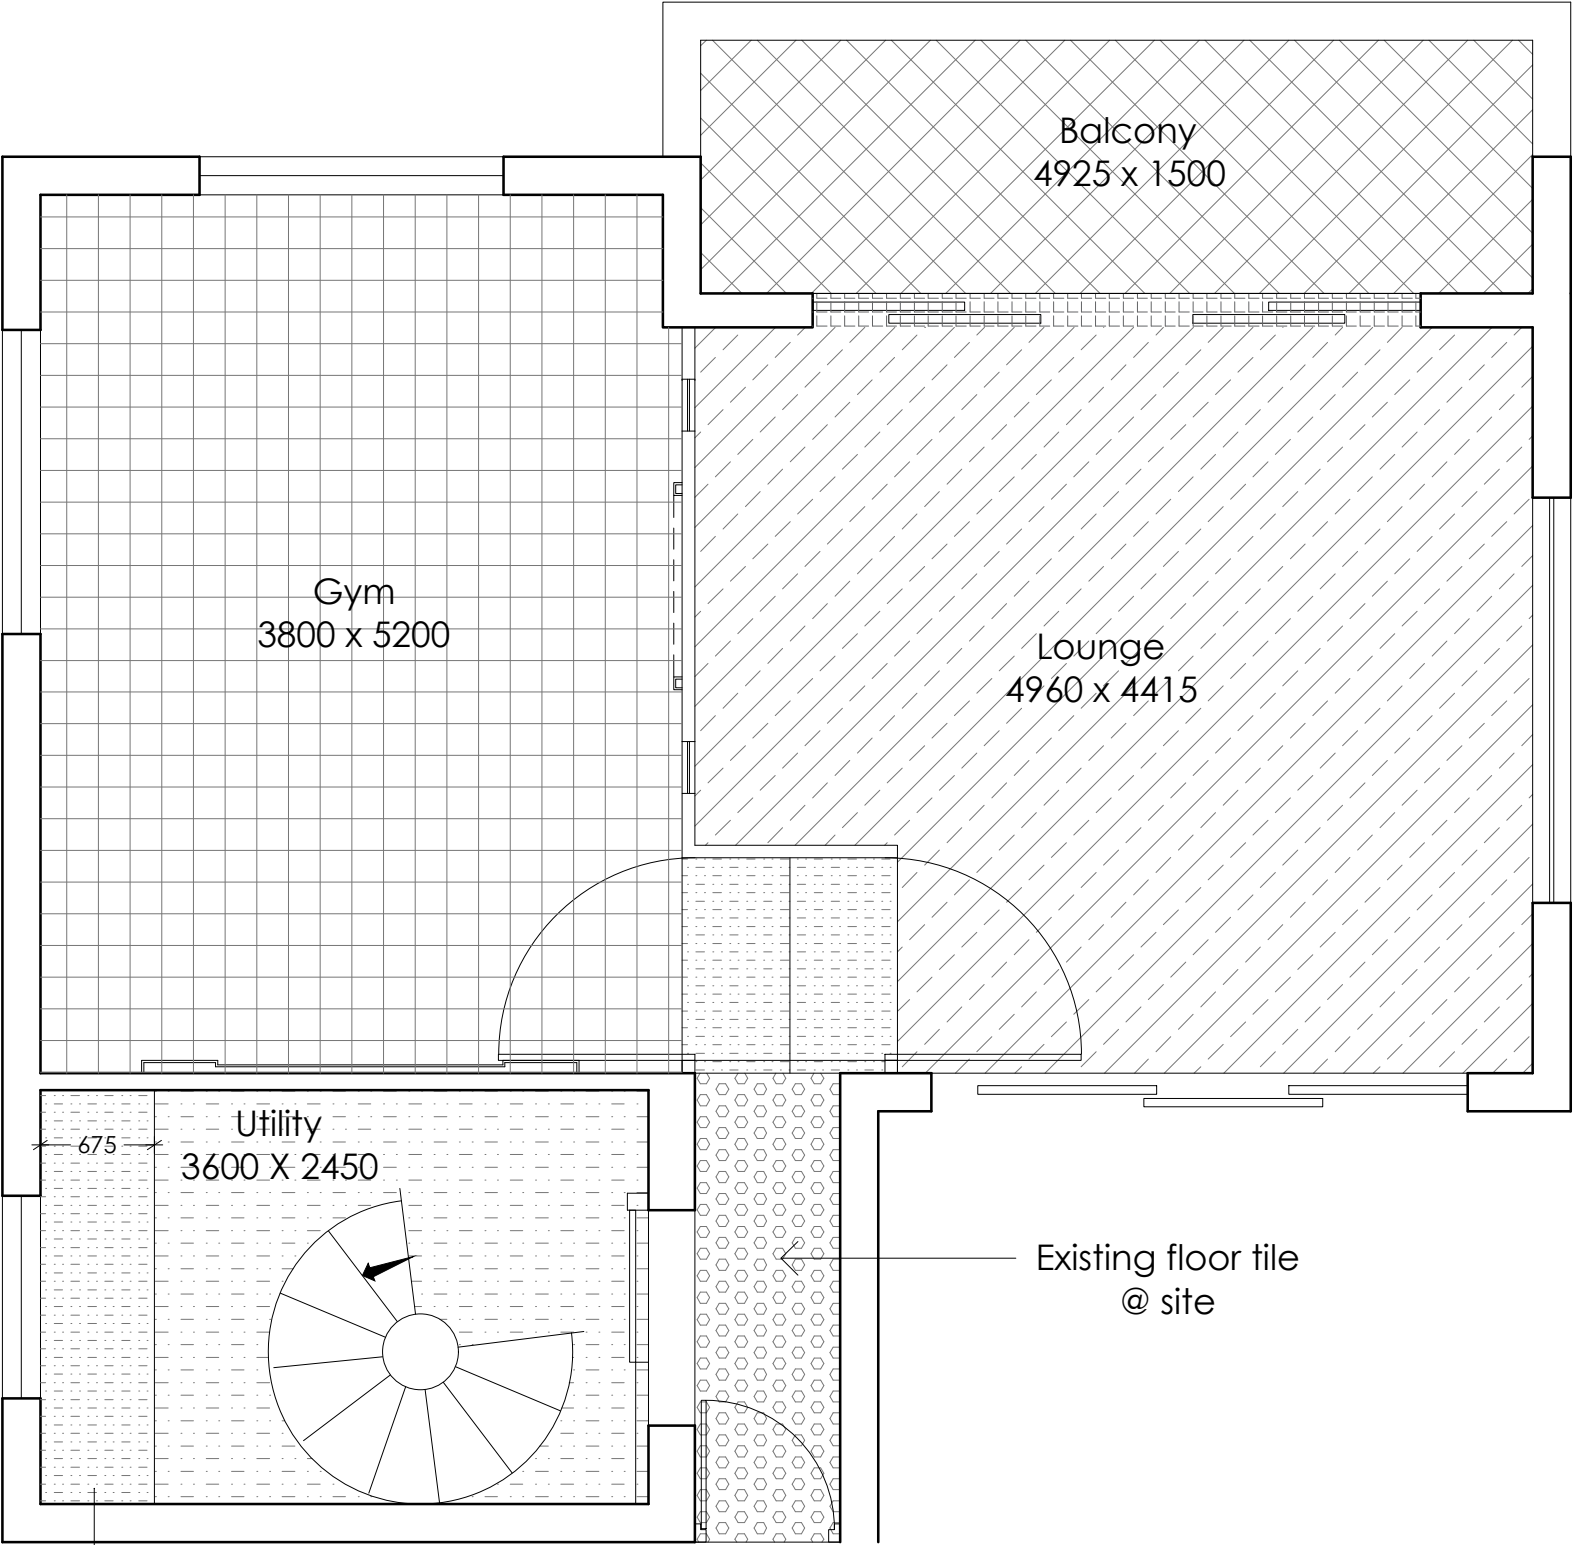

  Rubber flooring - Blue colour
(with Basic tile below)

  Tile (matching to the
Existing corridor flooring)

 Balcony tile
(to be selected by client)

  American Dark Walnut
(Ego - Easy collection -
Prelam Wooden flooring)

 Basic tile

NOTES:
This drawing is the property of
designworks & cannot be used or
reproduced any form without their
written permission.

Any discrepancy should be brought
to the notice of the architects.

Only written dimensions should be
followed, the drawing is not to be
scaled.

For Discussion	☐	Site Copy	☐
For Approval	☐	Clients Copy	☐
Good For Construction	☐	Contractors Copy	☐

Drawn : Durgaa	Scale :	Date : 07.07.22
Checked : Divya Sign :	dwg no :	

File Path :

drawing:
Second Floor - Flooring layout

project:
Proposed Residence for
Mr. Thyagrajan @ M.R.C nagar



DESIGNWORKS

First Floor, 33,Ranjit Road,
kotturpuram, Chennai - 600 085, India
Tel: +91- 44 - 4230 3731/32/33
Fax: +91- 44 - 42303734
E-mail: mail@designworks.in
Web: www.designworks.in


NOTES:
This drawing is the property of designworks & cannot be used or reproduced any form without their written permission.

Any discrepancy should be brought to the notice of the architects.

Only written dimensions should be followed, the drawing is not to be scaled.

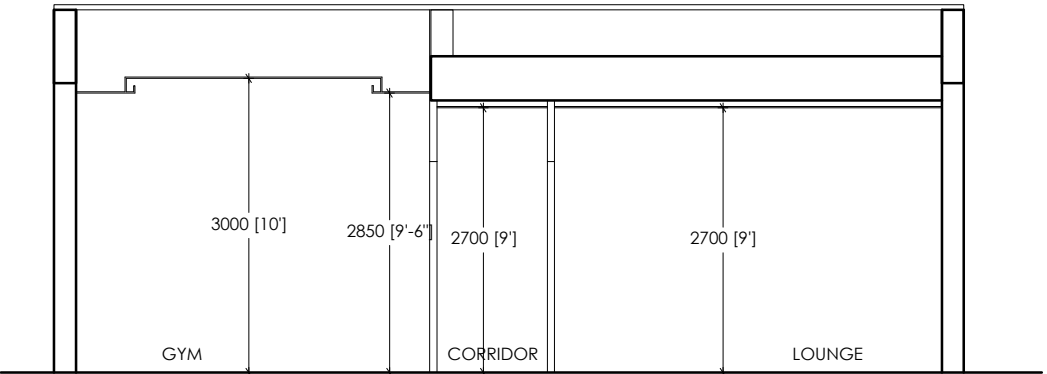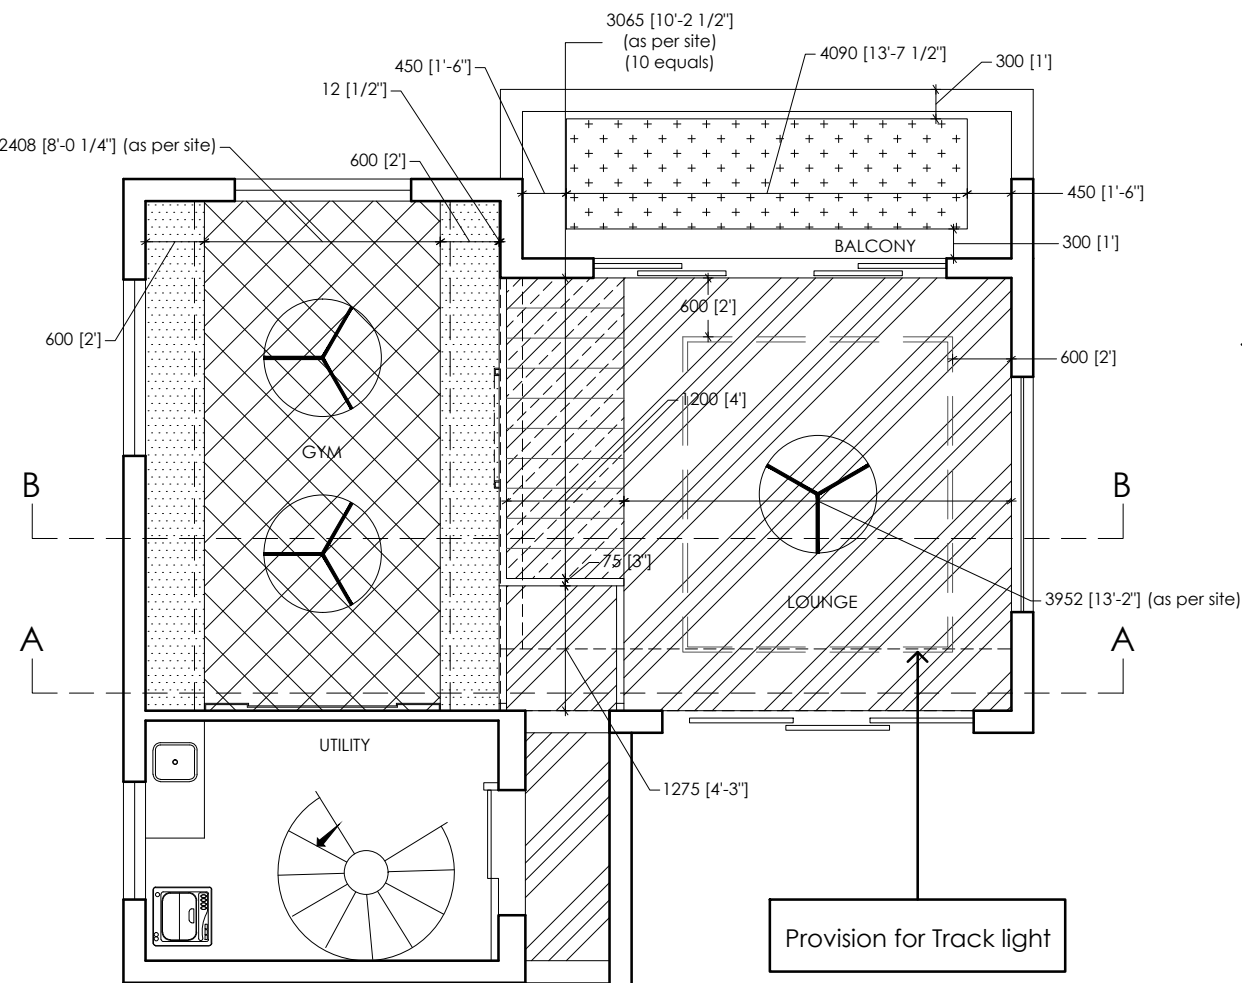

SECTION AA

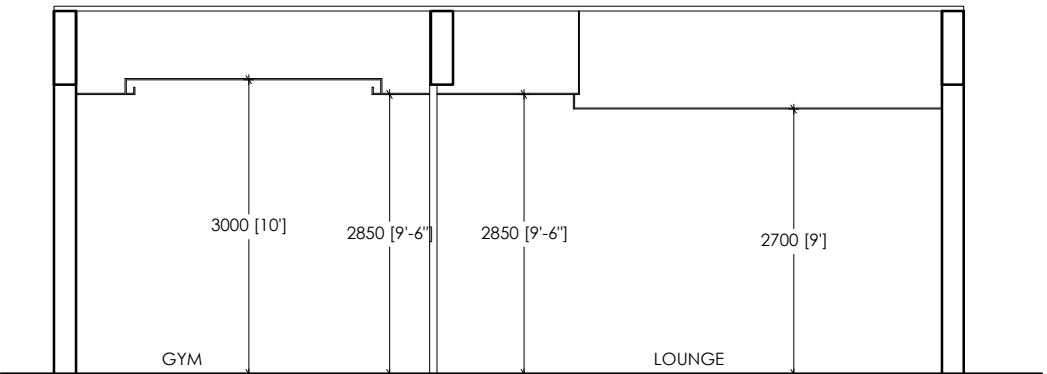

SECTION BB

NOTE:
Track light provision to be considered while providing False ceiling supports

For Discussion	☐	Site Copy	☐
For Approval	☐	Clients Copy	☐
Good For Construction	☐	Contractors Copy	☐


Drawn : Durgaa	Scale :	Date: 08.07.22
Checked : Divya Sign :	dwg no :	

File Path:


drawing :
FALSE CEILING LAYOUT

project:
Proposed Residence for Mr. Thyagrajan @ M.R.C nagar

 
DESIGNWORKS
First Floor, 33,Ranjit Road, kotturpuram, Chennai - 600 085, India
Tel: +91- 44 - 4230 3731/32/33
Fax: +91- 44 - 42303734
E-mail: mail@designworks.in
Web: www.designworks.in



 
Gypsum board false ceiling @ 9'0" from FFL



 Gypsum board false ceiling @ 9'6" from FFL



 
Vox ceiling to be 4" above the elevation acp bottom band




Plywood false ceiling finished with veneer @ 9'6" from FFL




Gypsum board false ceiling @ 10'0" from FFL

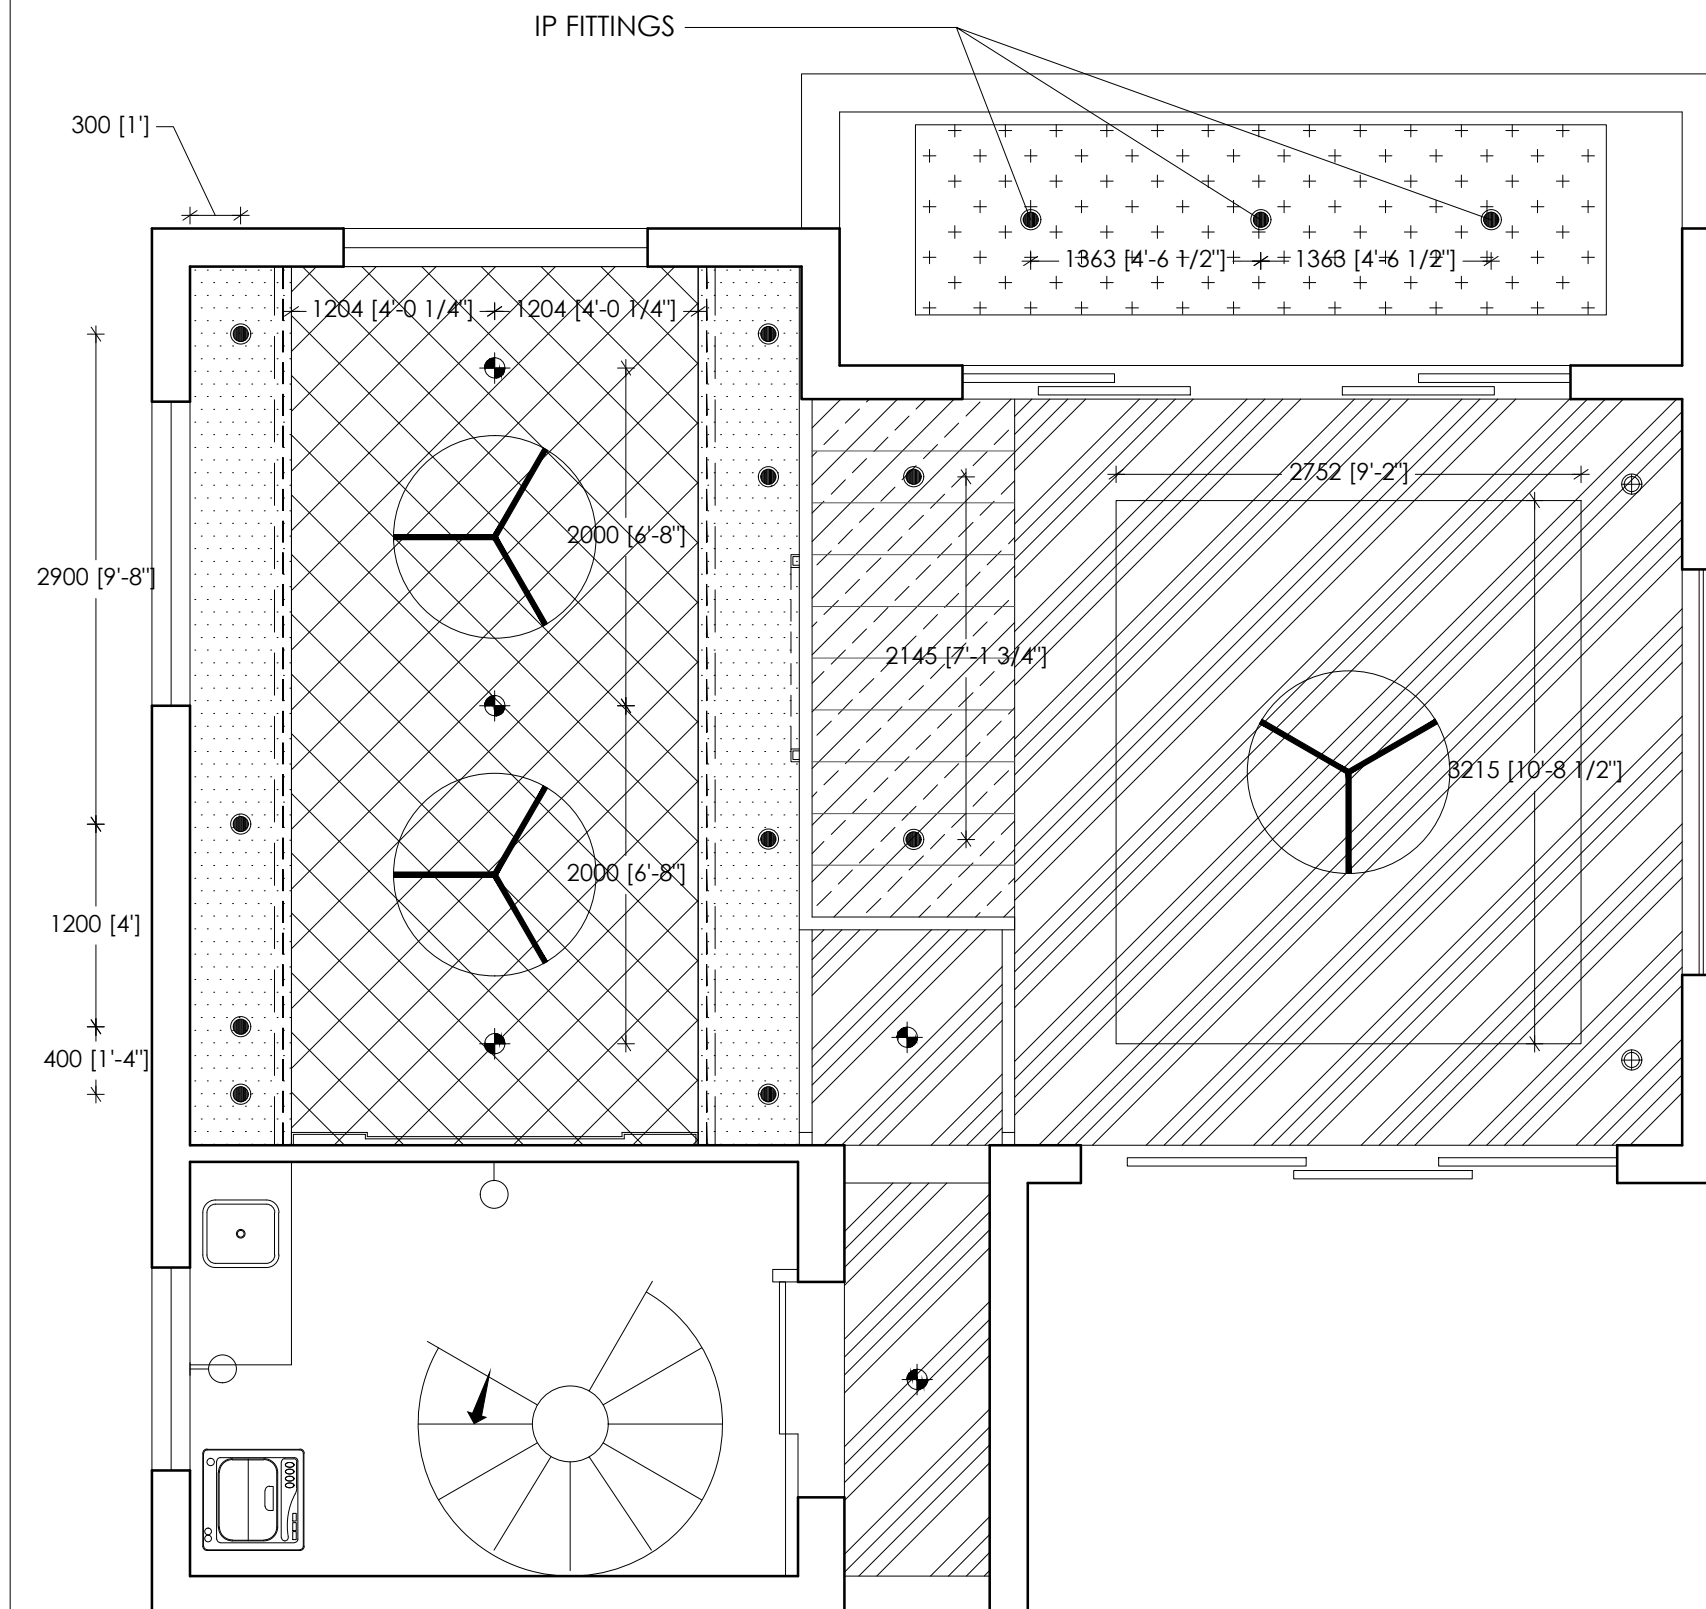

 
Gypsum board false ceiling
@ 9'0" from FFL



 Gypsum board false ceiling
@ 9'6" from FFL



 Plywood false ceiling finished
with veneer @ 9'6" from FFL



Vox ceiling to be 4" above the
elevation acp bottom band



Gypsum board false ceiling
@ 10'0" from FFL

NOTES:

This drawing is the property of
designworks & cannot be used or
reproduced any form without their
written permission.

Any discrepancy should be brought
to the notice of the architects.

Only written dimensions should be
followed, the drawing is not to be
scaled.

For Discussion	☐	Site Copy	☐
For Approval	☐	Clients Copy	☐
Good For Construction	☐	Contractors Copy	☐

Drawn : Durga	Scale :	Date: 08.07.22
Checked : Divya Sign :	dwg no :	
File Path:		

drawing:
Lighting & False ceiling layout

project :
Proposed Residence for Mr. Thyagrajan @ M.R.C nagar

DESIGNWORKS

First Floor, 33,Ranjit Road,
kotturpuram, Chennai - 600 085, India
Tel: +91- 44 - 4230 3731/32/33
Fax: +91- 44 - 42303734
E-mail: mail@designworks.in
Web: www.designworks.in



Hanging light



LED Spotlight - 3W



LED Downlight - 12W




LED Profile light



Recessed Track light



Wall light - Tubelight

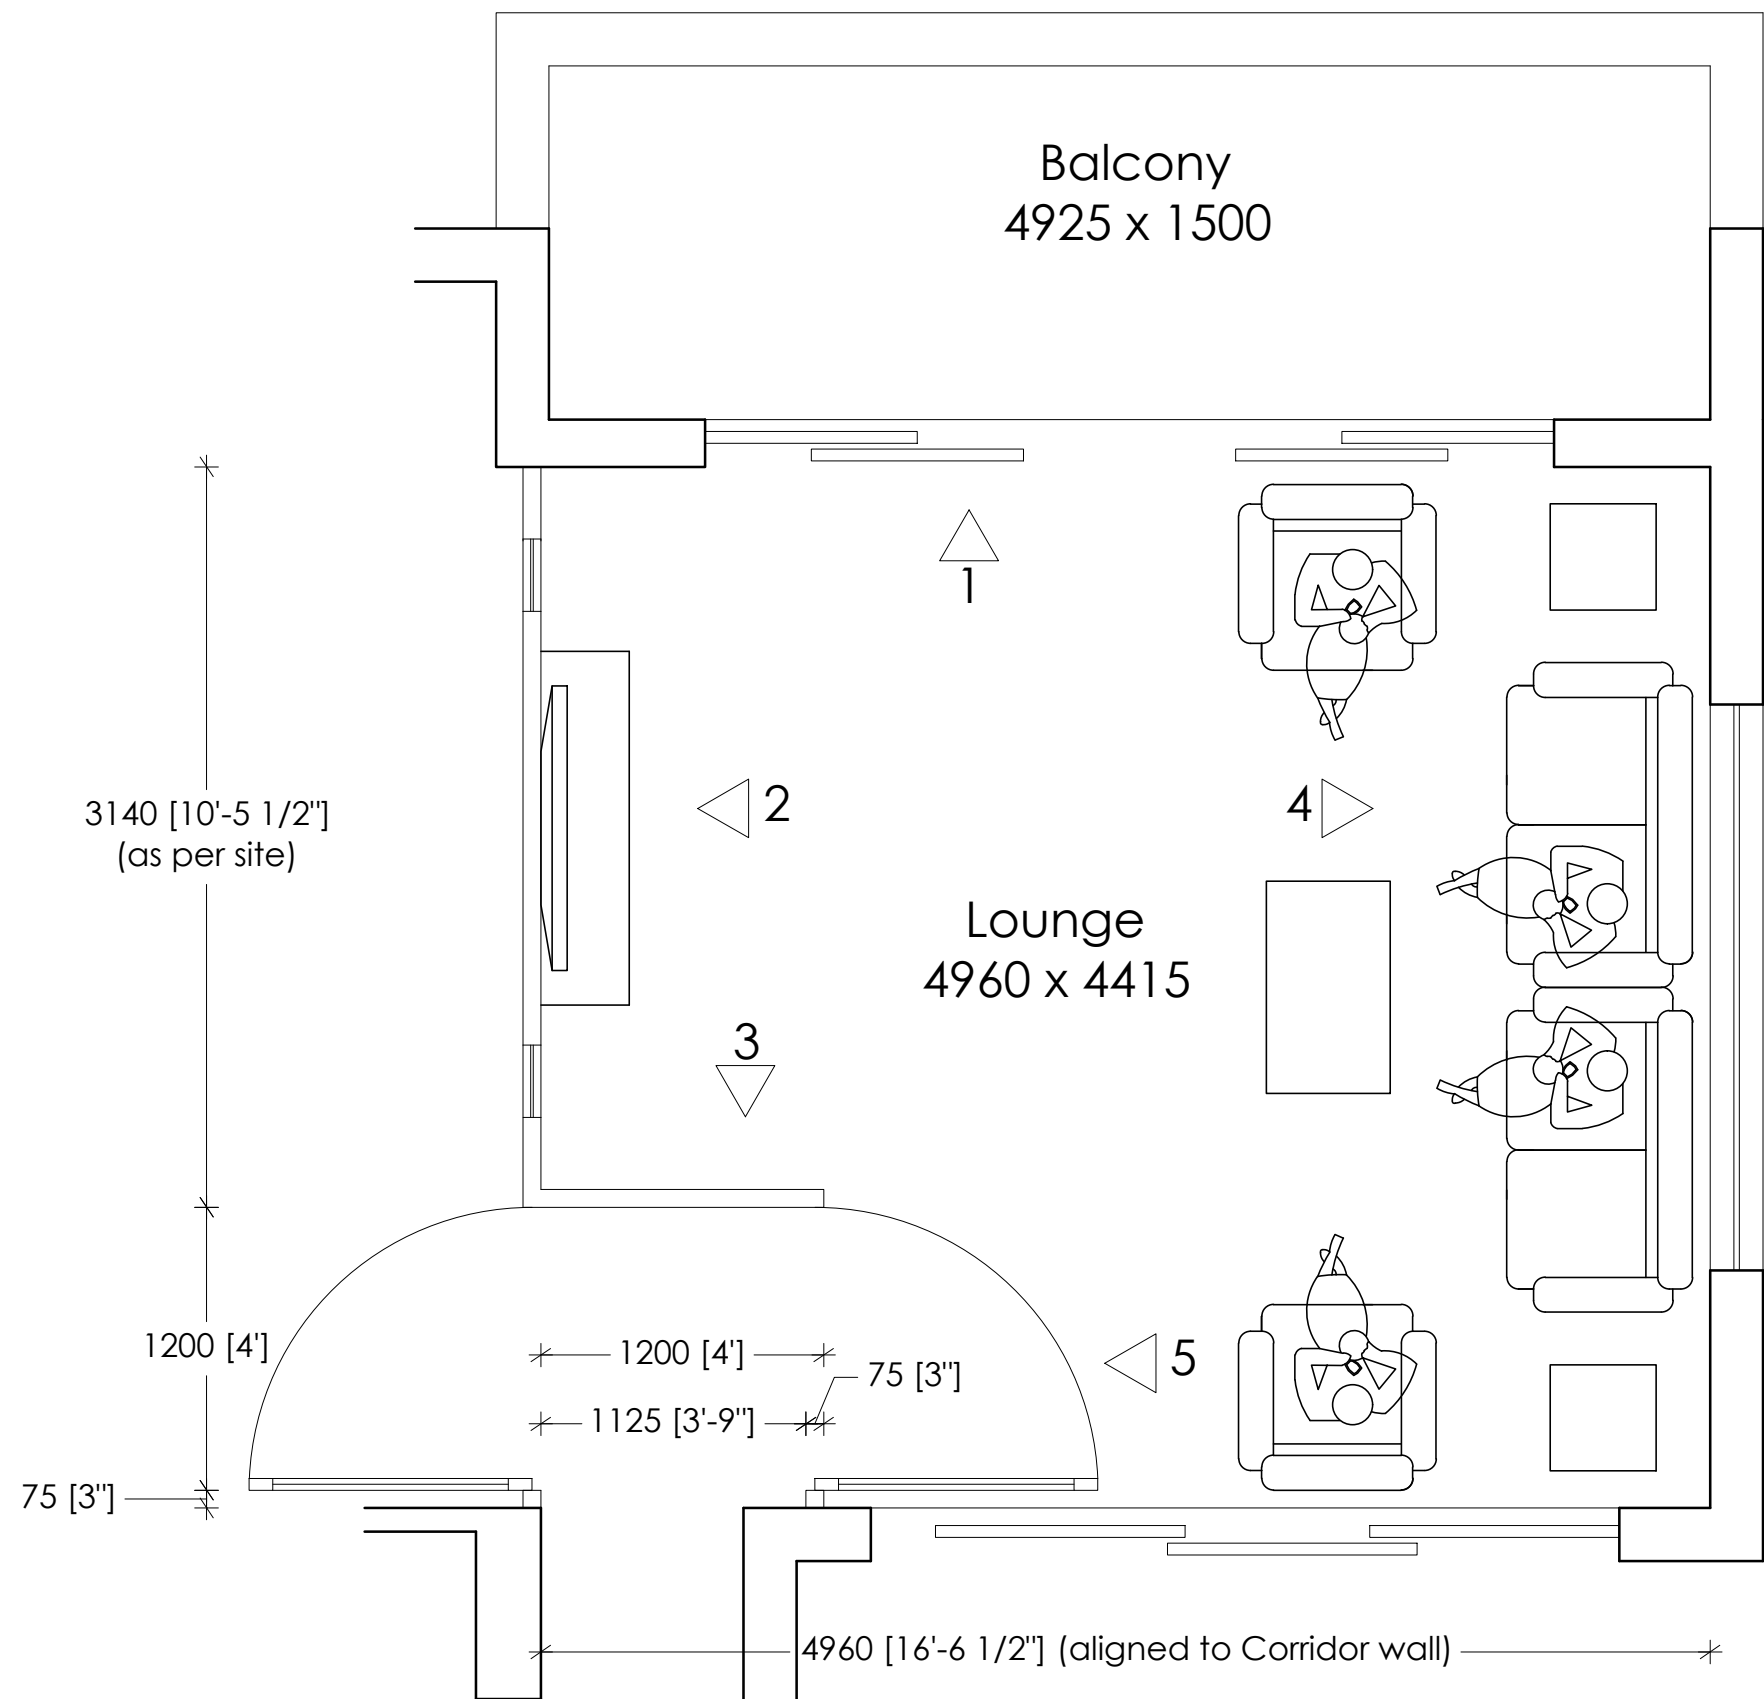

NOTES:
This drawing is the property of designworks & cannot be used or reproduced any form without their written permission.

Any discrepancy should be brought to the notice of the architects.

Only written dimensions should be followed, the drawing is not to be scaled.

For Discussion	☐	Site Copy	☐
For Approval	☐	Clients Copy	☐
Good For Construction	☐	Contractors Copy	☐


Drawn : Durgaa	Scale : NTS	Date: 07.07.22
Checked : Divya Sign :	dwg no:	

File Path :


drawing:
LOUNGE - LAYOUT

project:
Proposed Residence for Mr. Thyagrajan @ M.R.C nagar


DESIGNWORKS
First Floor, 33,Ranjit Road, kotturpuram, Chennai - 600 085, India
Tel: +91 - 44 - 4230 3731/32/33
Fax: +91- 44 - 42303734
E-mail: mail@designworks.in
Web: www.designworks.in

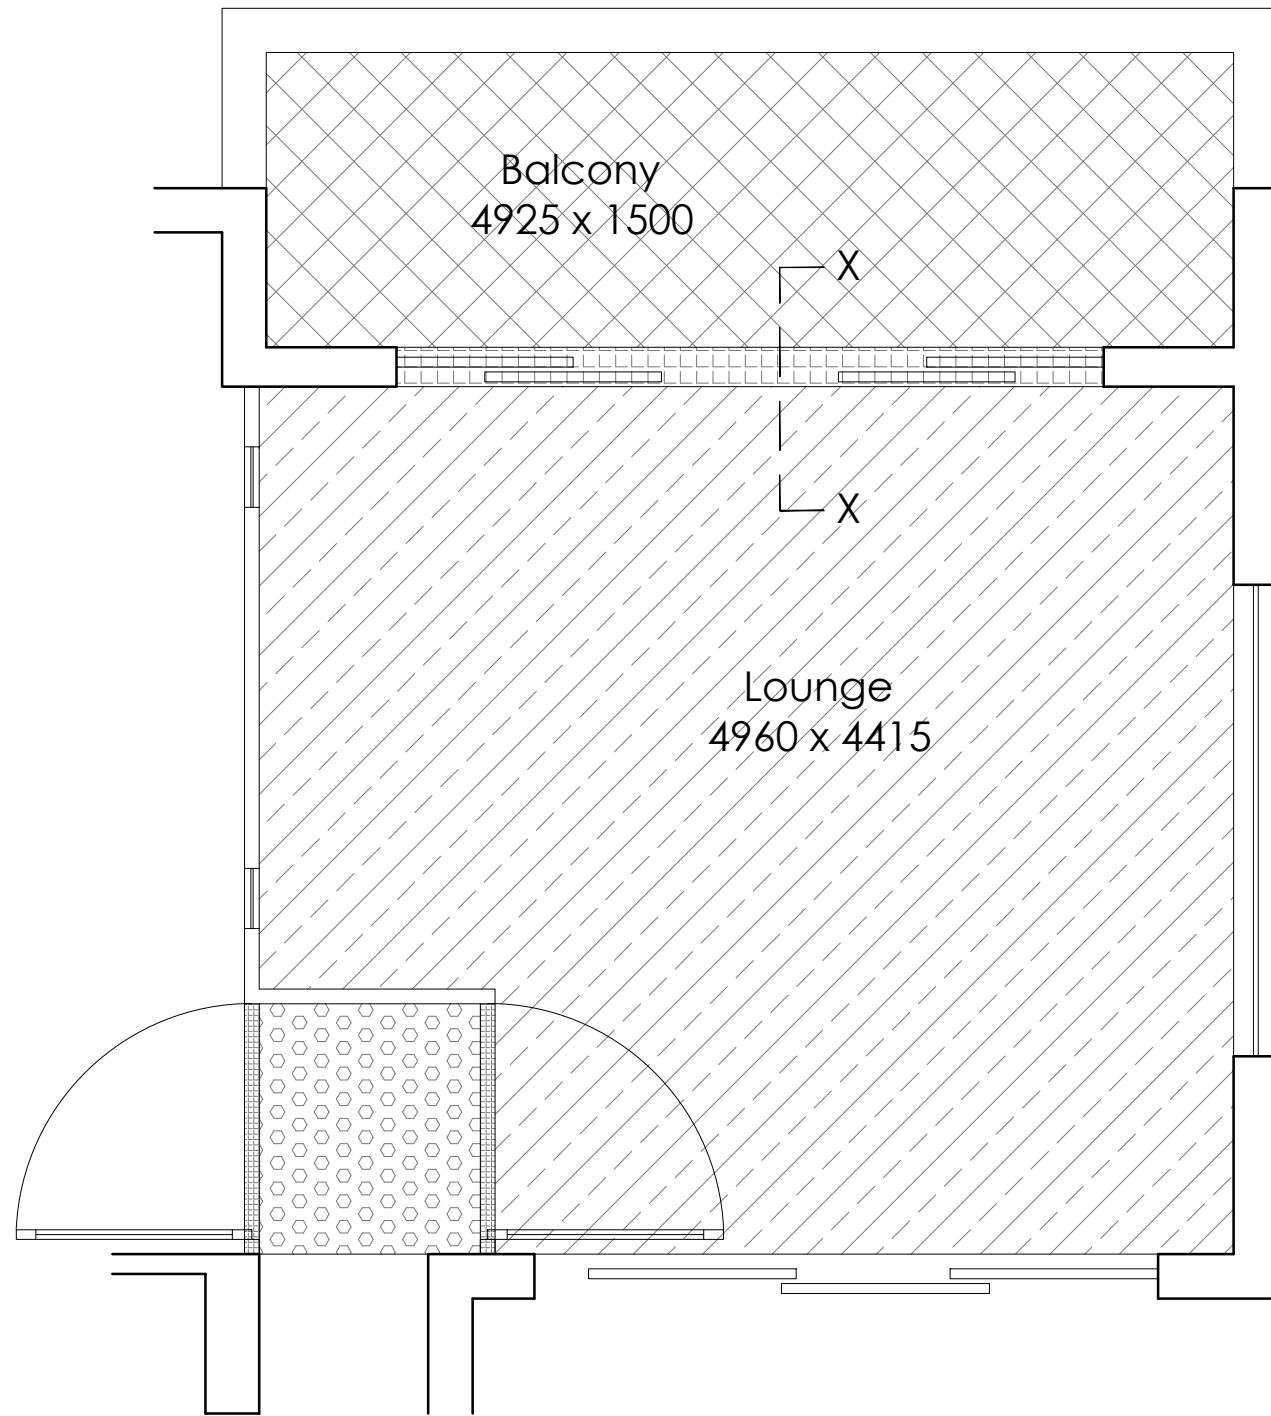

PLAN

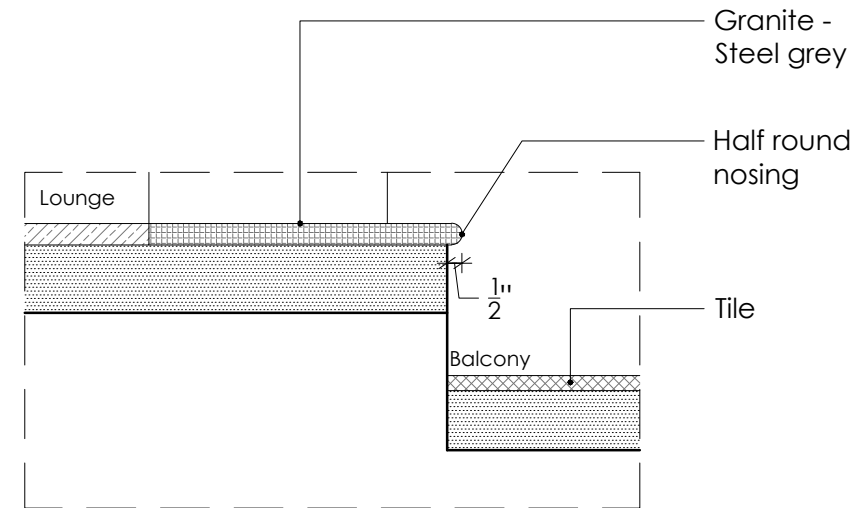

SECTION XX

 

Tile
(matching to the Existing corridor flooring)



Balcony tile
(to be selected)



American Dark Walnut
(Ego - Easy collection - Prelam Wooden flooring)



Granite - Steel Grey

NOTES:
This drawing is the property of designworks & cannot be used or reproduced any form without their written permission.

Any discrepancy should be brought to the notice of the architects.

Only written dimensions should be followed, the drawing is not to be scaled.

For Discussion	☐	Site Copy	☐
For Approval	☐	Clients Copy	☐
Good For Construction	☐	Contractors Copy	☐

Drawn : Durga	Scale : NTS	Date: 07.07.22
Checked : Divya Sign :	dwg no:	





File Path :

drawing :
LOUNGE - FLOORING LAYOUT

project :
Proposed Residence for
Mr. Thyagrajan @ M.R.C nagar

DESIGNWORKS

First Floor, 33,Ranjit Road,
kotturpuram, Chennai - 600 085, India
Tel: +91- 44 - 4230 3731/32/33
Fax: +91- 44 - 42303734
E-mail: mail@designworks.in
Web: www.designworks.in

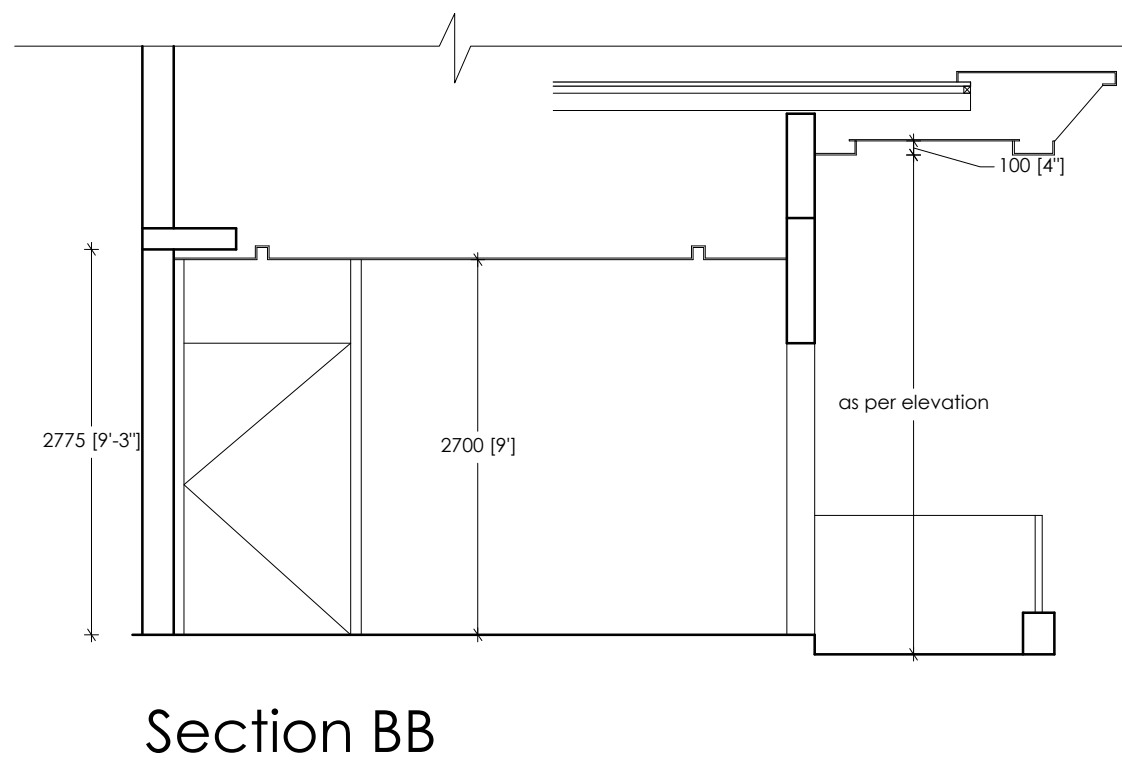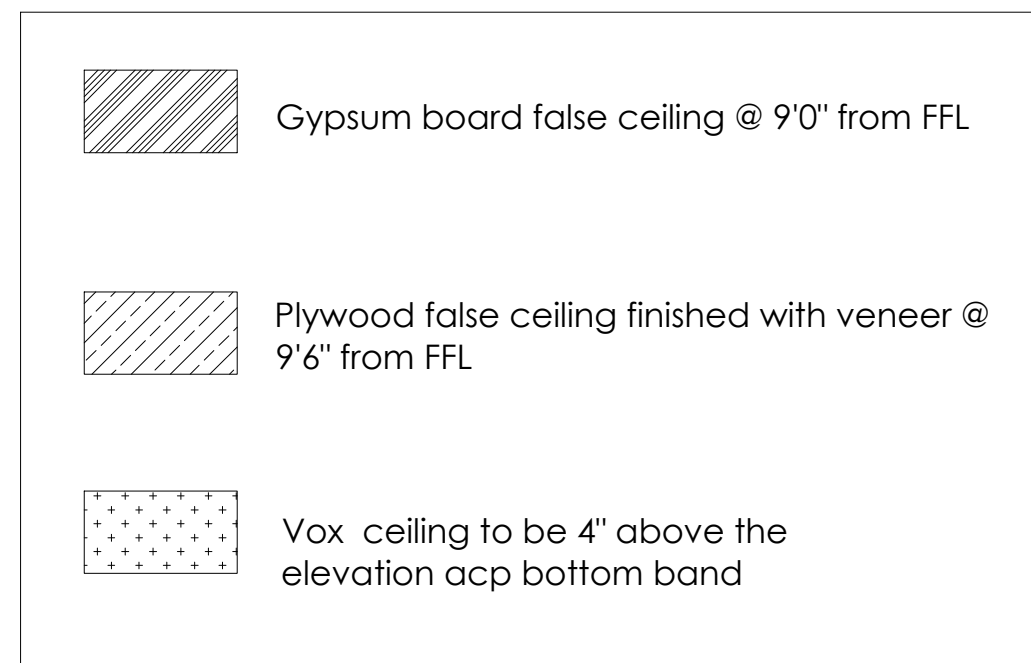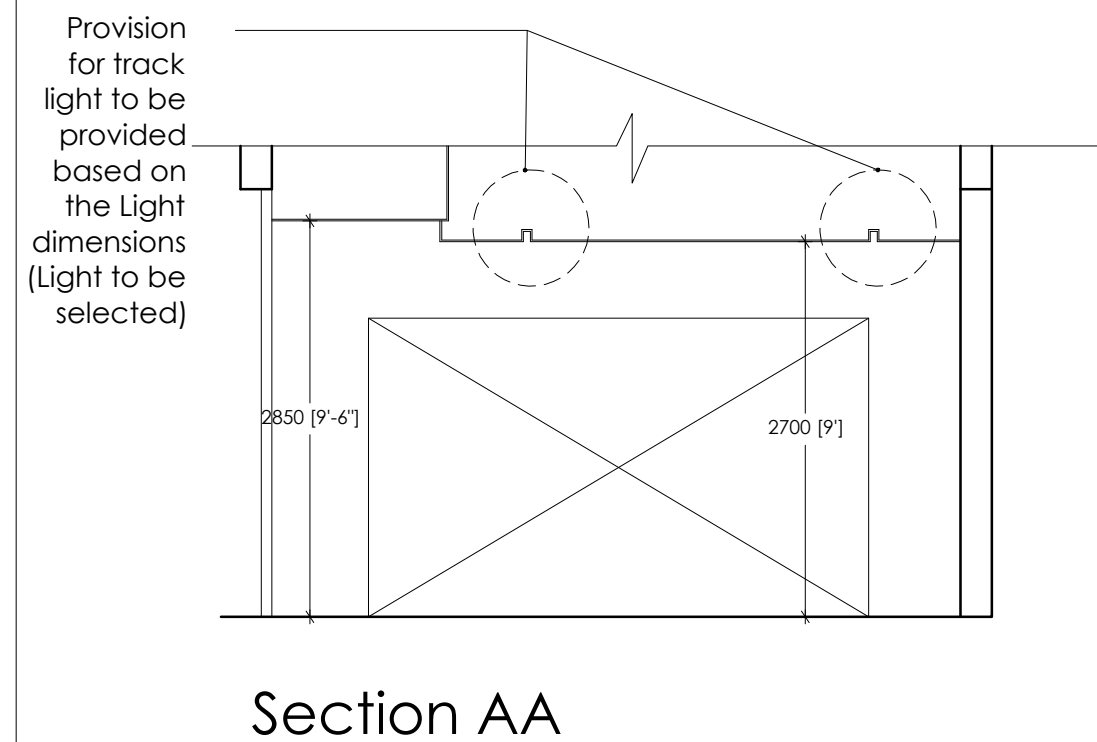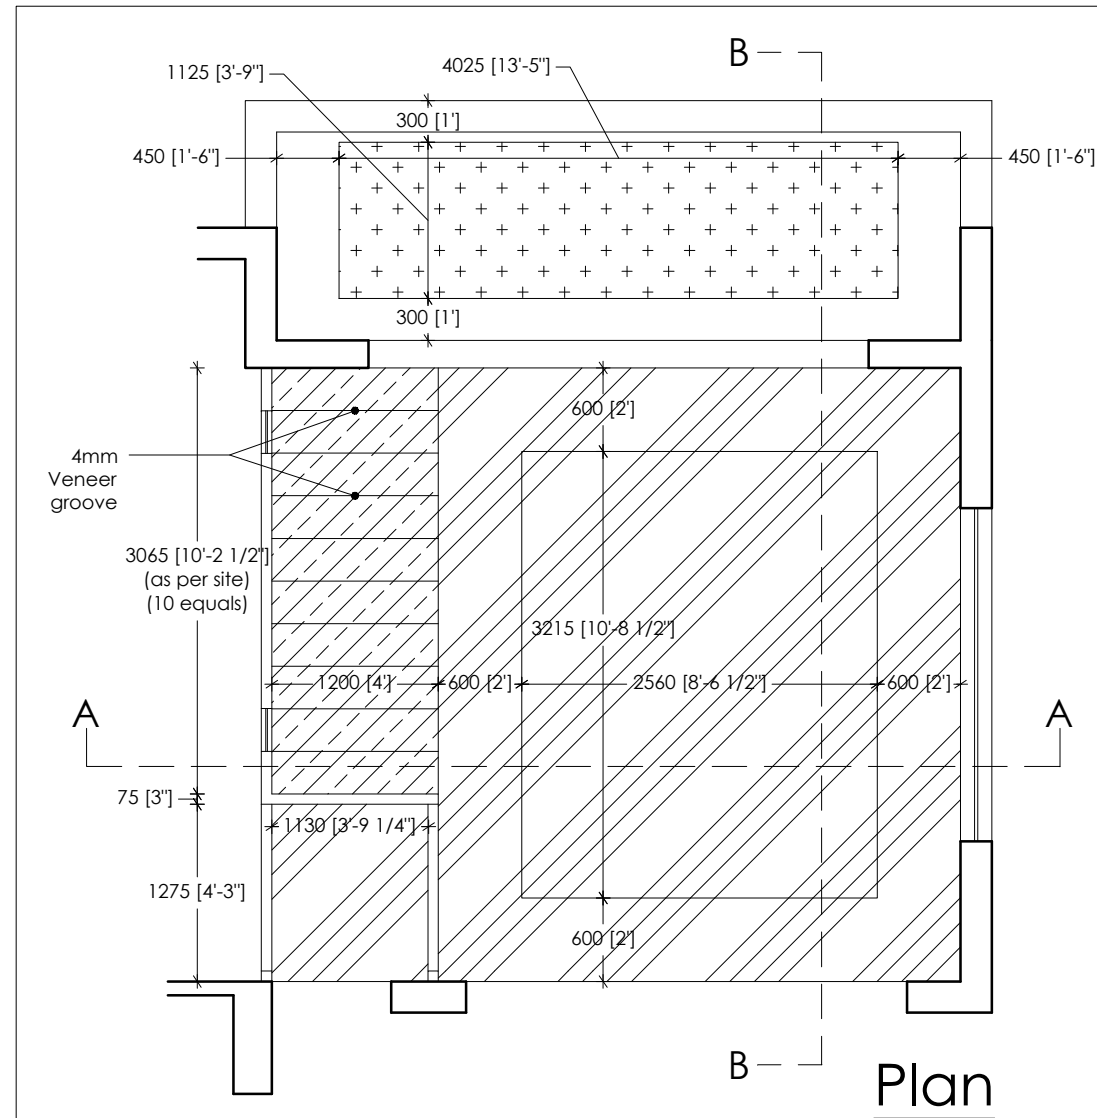

NOTES:

This drawing is the property of designworks & cannot be used or reproduced any form without their written permission.

Any discrepancy should be brought to the notice of the architects.

Only written dimensions should be followed, the drawing is not to be scaled.

For Discussion	☐	Site Copy	☐
For Approval	☐	Clients Copy	☐
Good For Construction	☐	Contractors Copy	☐

Drawn : Durgaa	Scale : NTS	Date : 08.07.22
Checked : Divya	dwg no :	
Sign :		


File Path :

drawing :
LOUNGE - FALSE CEILING LAYOUT


project :
Proposed Residence for
Mr. Thyagrajan @ M.R.C nagar

DESIGNWORKS

First Floor, 33,Ranjit Road,
kotturpuram, Chennai - 600 085, India
Tel: +91 - 44 - 4230 3731/32/33
Fax: +91 - 44 - 42303734
E-mail: mail@designworks.in
Web: www.designworks.in

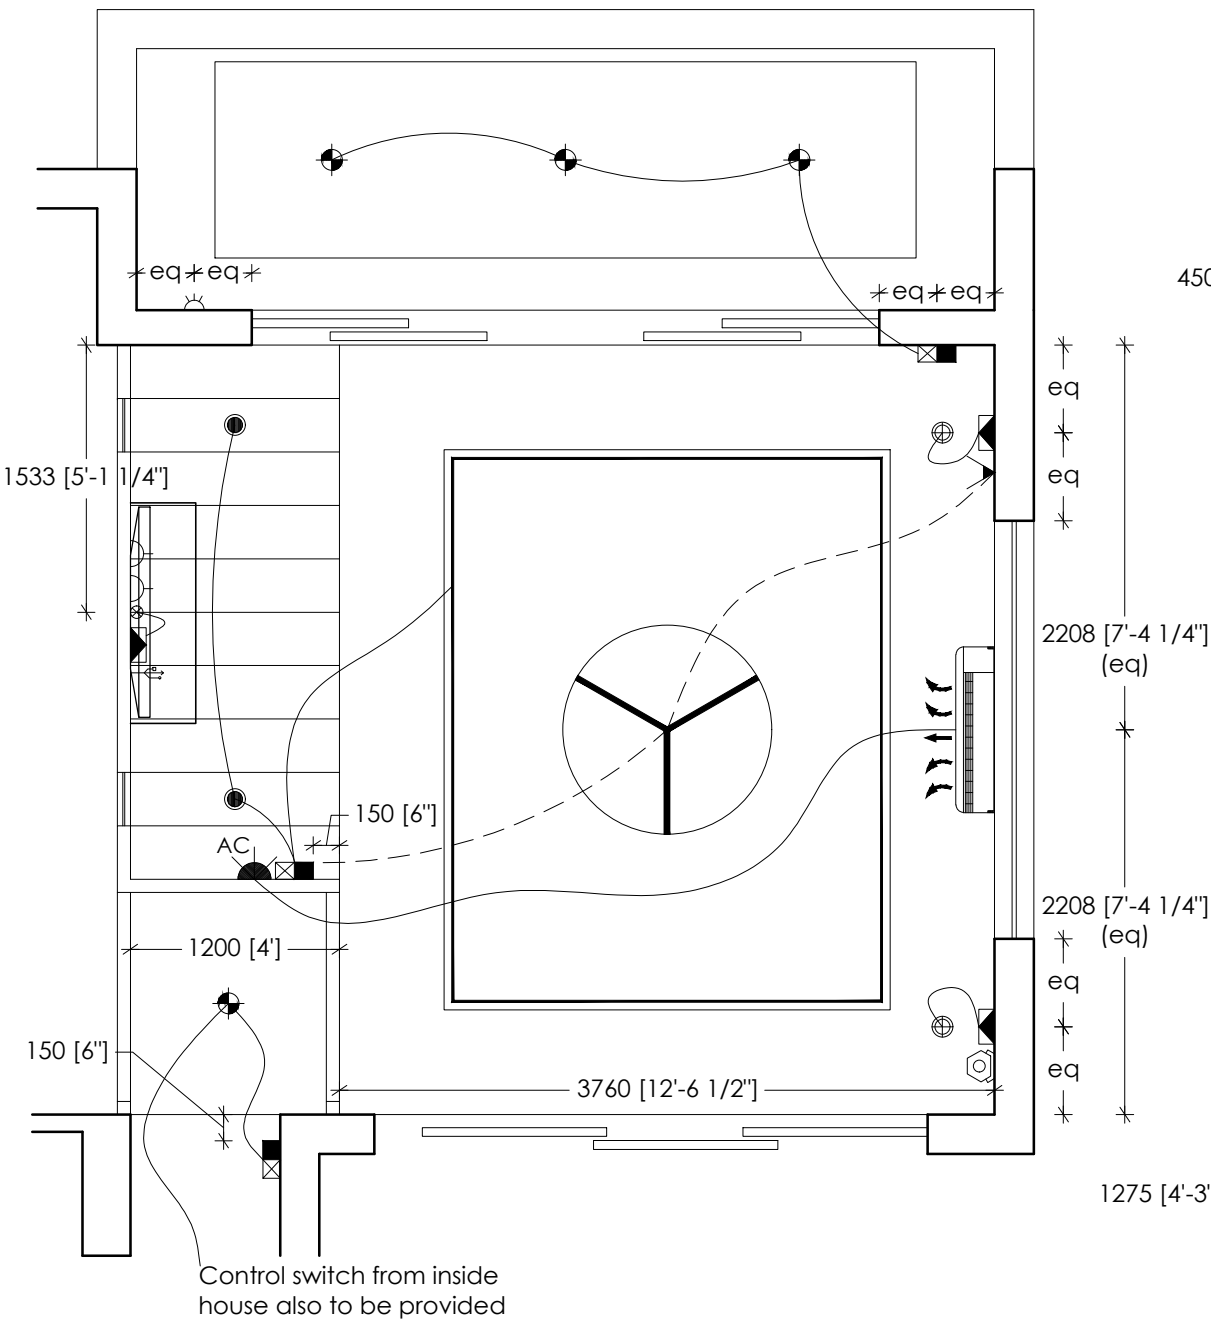

ELECTRICAL LAYOUT

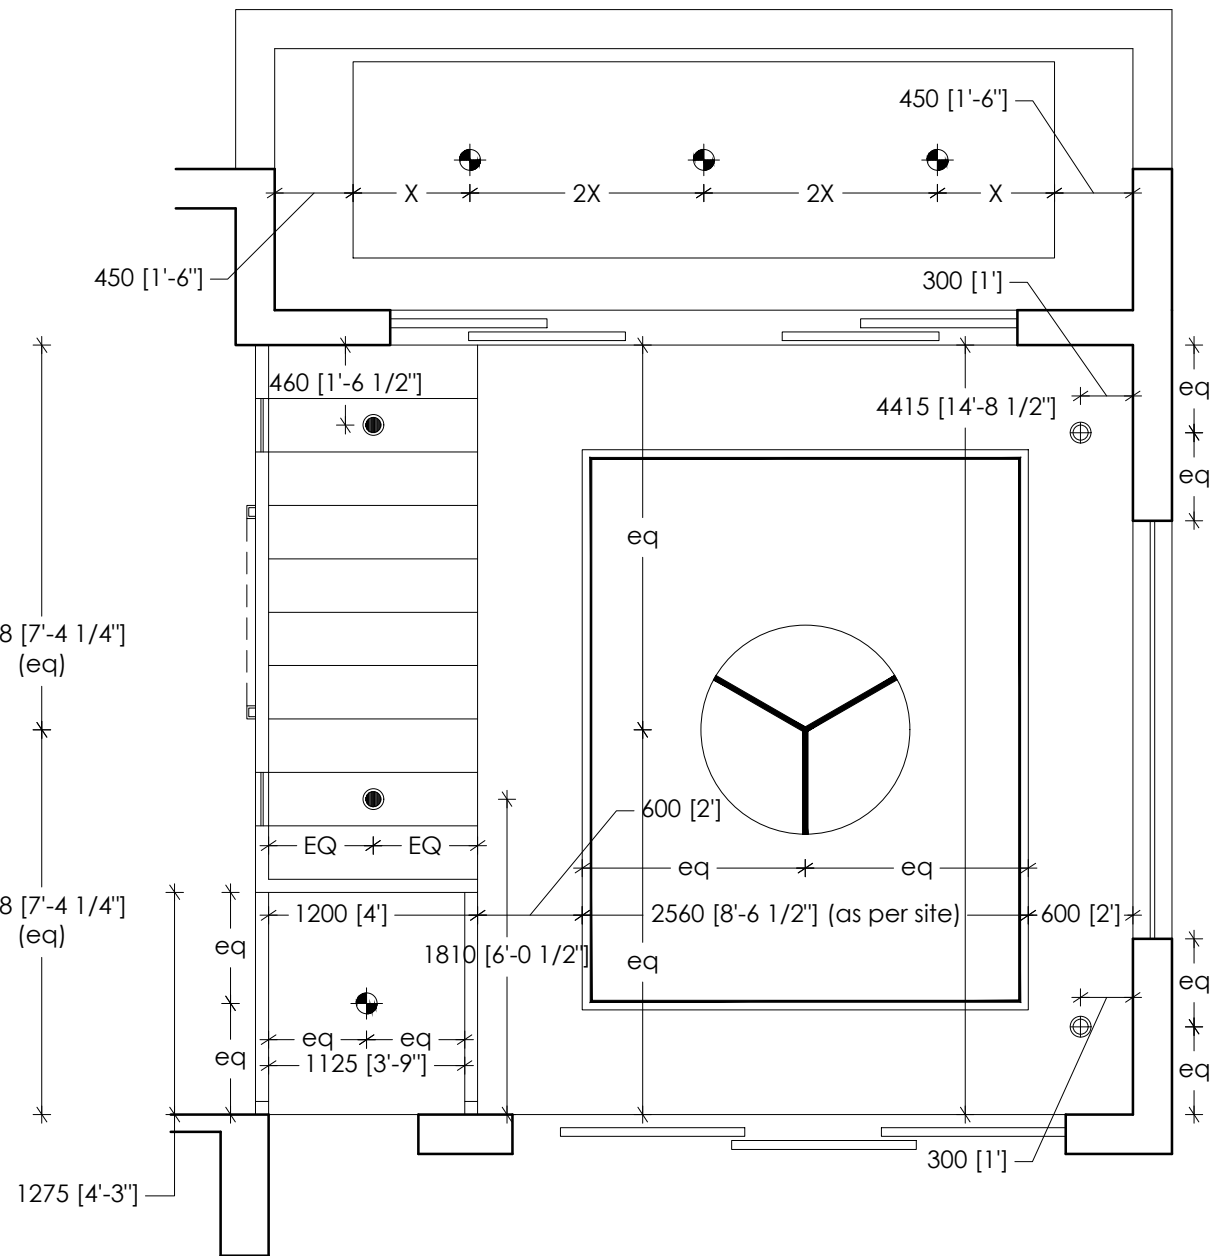

LIGHTING LAYOUT

NOTES:
This drawing is the property of designworks & cannot be used or reproduced any form without their written permission.
Any discrepancy should be brought to the notice of the architects.
Only written dimensions should be followed, the drawing is not to be scaled.

NOTE:
2'0" X 2'0" Plywood support to be provided for the hanging lights

For Discussion	☐	Site Copy	☐
For Approval	☐	Clients Copy	☐
Good For Construction	☐	Contractors Copy	☐

Drawn : Durgaa	Scale : NTS	Date: 09.07.22
Checked : Divya Sign :	dwg no :	

File Path:


drawing :
Lounge - Electrical & Lighting Layout

project :
Proposed Residence for Mr. Thyagrajan @ M.R.C nagar


DESIGNWORKS

First Floor, 33,Ranjit Road, kotturpuram, Chennai - 600 085, India
Tel: +91 - 44 - 4230 3731/32/33
Fax: +91 - 44 - 42303734
E-mail: mail@designworks.in
Web: www.designworks.in


	1 NO. 5amps socket + switch with socket bottom @ 1'9" from F.F.L		1 NO. 15/5amps combined socket + switch with socket bottom @ 1'9" from F.F.L		Switch box with 1no. 5amps socket + switch with socket bottom @ 4'0" from F.F.L		Provision for Data	
	LED Spotlight		Hanging light		Switch box with 2nos. 5amps socket + switch with socket bottom @ 1'9" from F.F.L			
	LED Downlight		AC Control		Ceiling automation fan - 4'0" Dia		Telephone point	
	Track light		AC Indoor unit				2 way control	

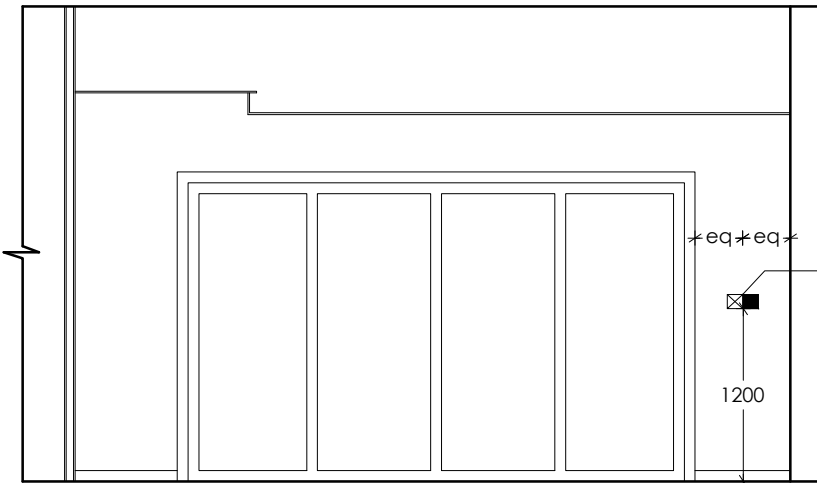

ELEVATION 1

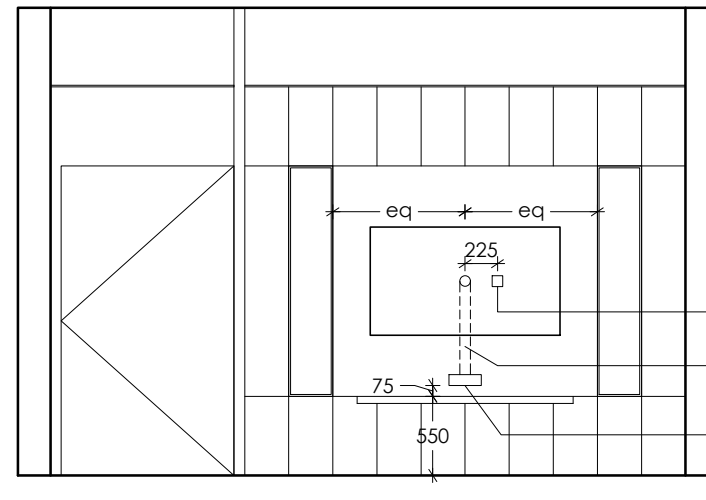


ELEVATION 2

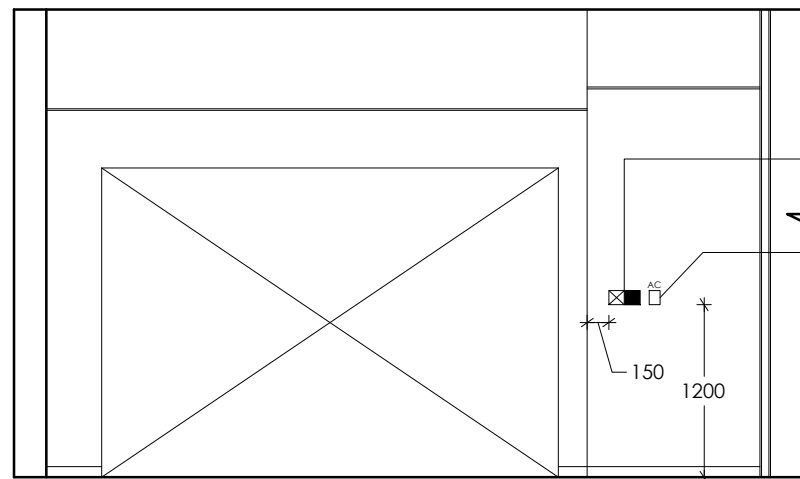

ELEVATION 3

1nos. 5amps socket with switch +
Two way control for Fan +
Control switch for FC lights +
Control switch for FC spot lights
AC Control

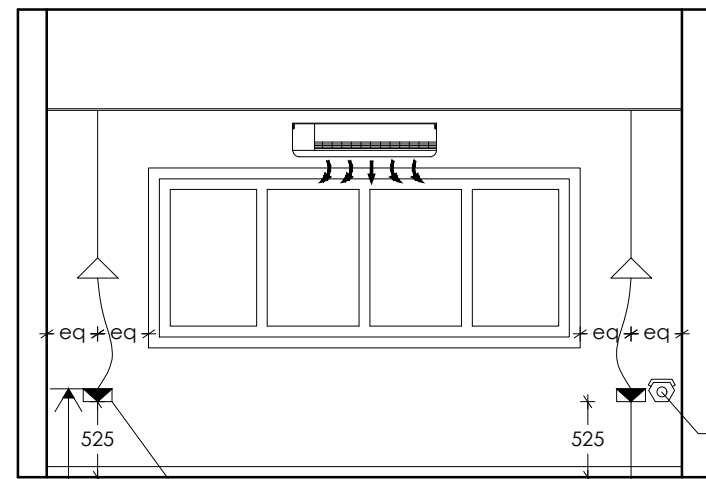

ELEVATION 4

2nos. 5amps socket with switch +
Control switch for Hanging light

Two way control for Fan

Telephone point

2nos. 5amps
socket with switch
+ Control switch
for Hanging light

NOTES:
This drawing is the property of
designworks & cannot be used or
reproduced any form without their
written permission.

Any discrepancy should be brought
to the notice of the architects.

Only written dimensions should be
followed, the drawing is not to be
scaled.

For Discussion	☐	Site Copy	☐
For Approval	☐	Clients Copy	☐
Good For Construction	☐	Contractors Copy	☐

Drawn : Durgaa	Scale :	Date: 19.07.22
Checked : Divya Sign :	dwg no :	

File Path:

drawing :
Lounge - Electrical wall elevations


project :
Proposed Residence for
Mr. Thyagrajan @ M.R.C nagar

DESIGNWORKS

First Floor, 33.Ranjit Road,
kotturpuram, Chennai - 600 085, India
Tel: +91- 44 - 4230 3731/32/33
Fax: +91- 44 - 42303734
E-mail: mail@designworks.in
Web: www.designworks.in




PLAN 1

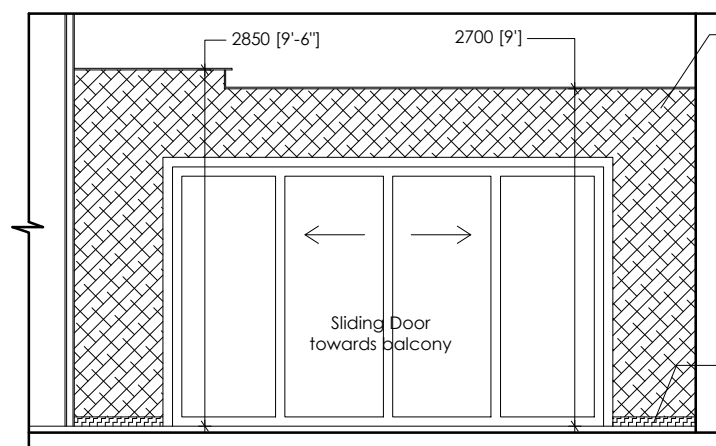


ELEVATION 1

Wall surface finished with Wall paint - Asian paints - Morning Glory - 0765

Skirting

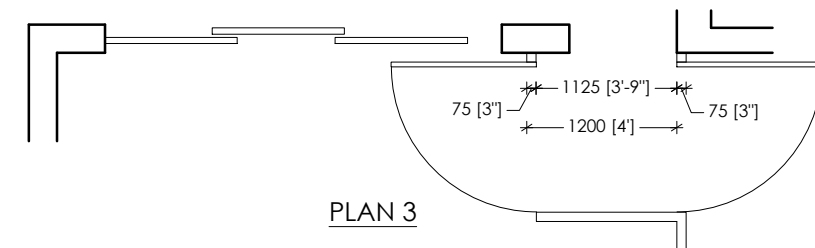


PLAN 3

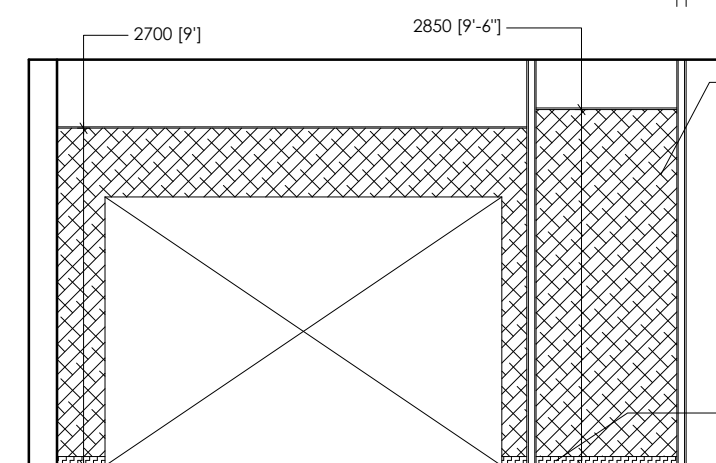


ELEVATION 3

Wall surface finished with Wall paint - Asian paints - Morning Glory - 0765

Skirting

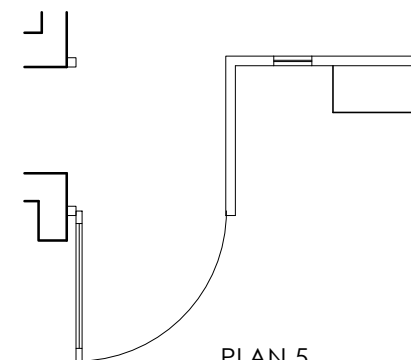

PLAN 5

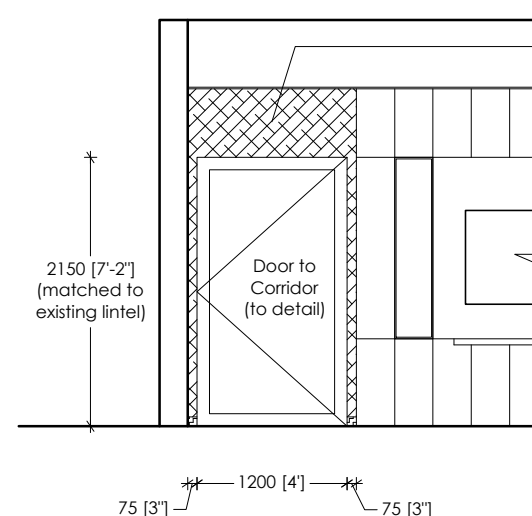

ELEVATION 5

4mm MDF Fixed over Plywood Partition finished with Lacquer PU - Asian paints Woodtech Spectra - Pure white RAL 9010

NOTES:
This drawing is the property of designworks & cannot be used or reproduced any form without their written permission.

Any discrepancy should be brought to the notice of the architects.

Only written dimensions should be followed, the drawing is not to be scaled.

Lacquer PU - Asian paints Woodtech Spectra - Pure white RAL 9010

Skirting

Wallpaper

For Discussion	☐	Site Copy	☐
For Approval	☐	Clients Copy	☐
Good For Construction	☐	Contractors Copy	☐


Drawn : Durgaa	Scale :	Date: 10.07.22
Checked : Divya Sign :	dwg no :	
File Path:		

drawing :
Lounge wall elevations

project :
Proposed Residence for Mr. Thyagrajan @ M.R.C nagar

DESIGNWORKS

First Floor, 33,Ranjit Road, kotturpuram, Chennai - 600 085, India
Tel: +91 - 44 - 4230 3731/32/33
Fax: +91 - 44 - 42303734
E-mail: mail@designworks.in
Web: www.designworks.in

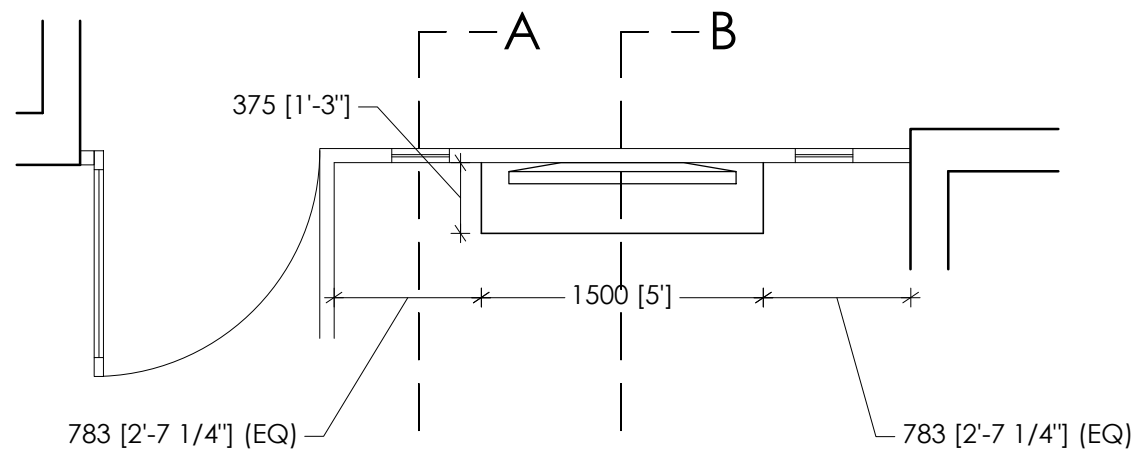

PLAN 2


4mm MDF Fixed over Plywood Partition finished with Lacquer PU - Asian paints Woodtech Spectra - Pure white RAL 9010

10mm thk Toughened Clear glass with Stickers


Plywood Ledge finished with Red Oak Veneer

3" thk Plywood partition finished with Red Oak Veneer


4mm Veneer groove

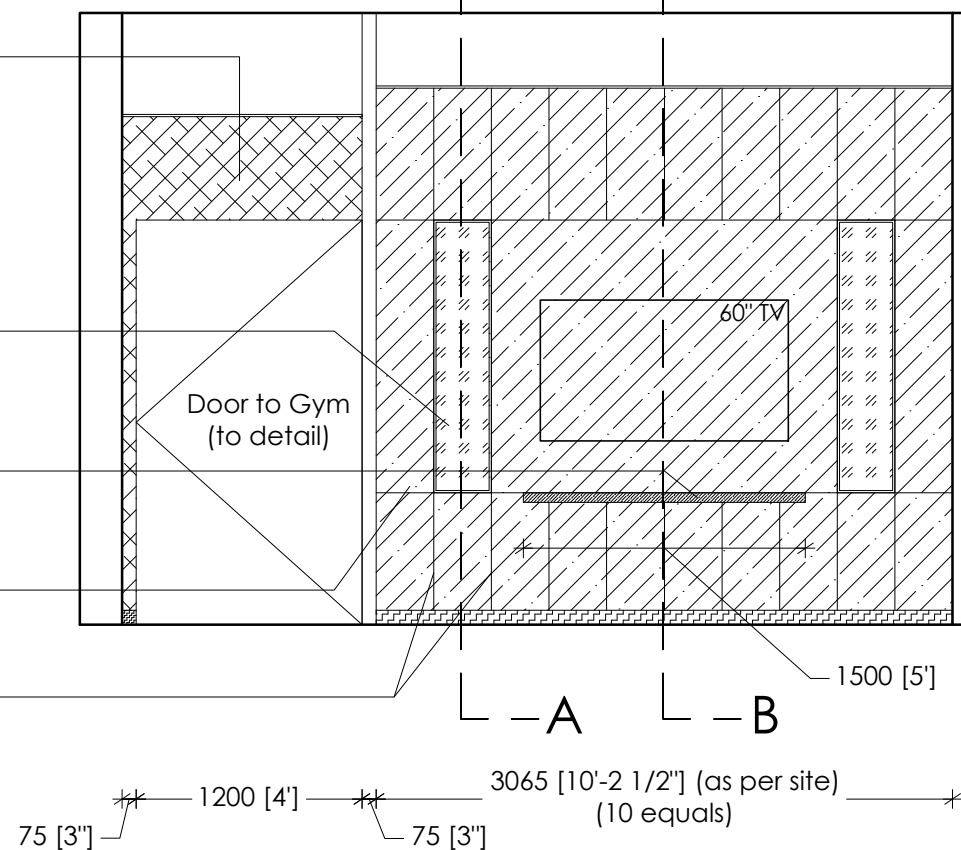

ELEVATION 2

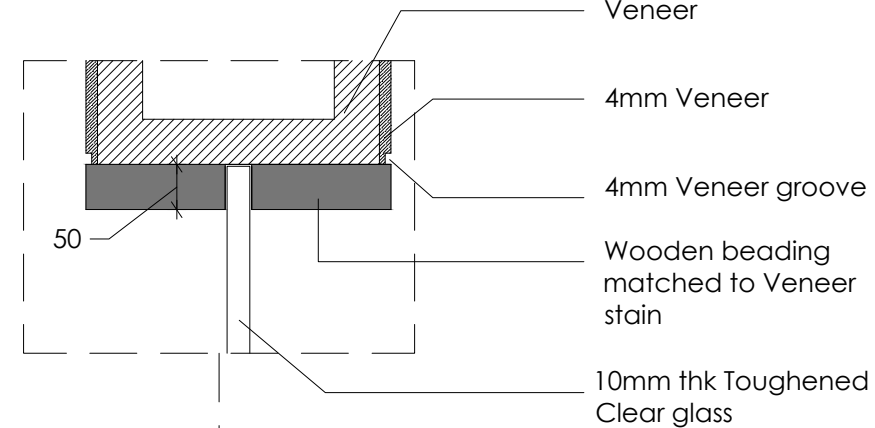

SECTION AA

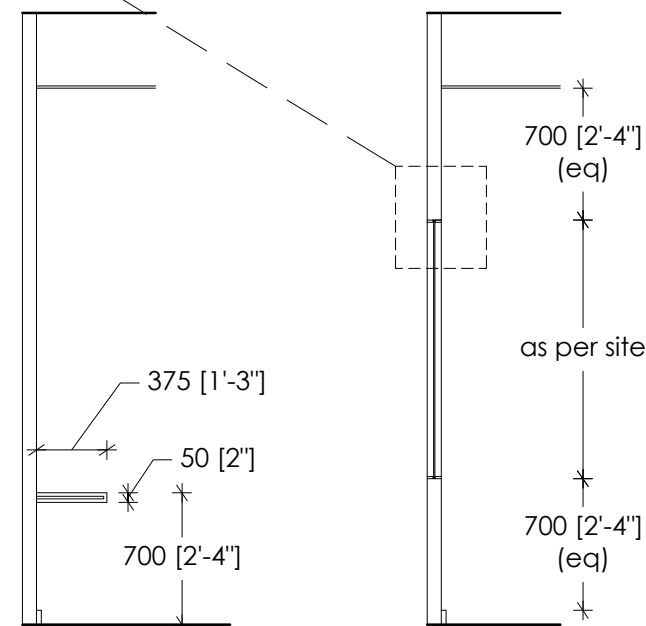

SECTION BB

NOTES:
This drawing is the property of designworks & cannot be used or reproduced any form without their written permission.
Any discrepancy should be brought to the notice of the architects.
Only written dimensions should be followed, the drawing is not to be scaled.

For Discussion	☐	Site Copy	☐
For Approval	☐	Clients Copy	☐
Good For Construction	☐	Contractors Copy	☐

Drawn : Durgaa	Scale:	Date: 10.07.22
Checked : Divya Sign :	dwg no:	

File Path:

drawing:
Lounge wall elevations

 
project:
Proposed Residence for Mr. Thyagrajan @ M.R.C nagar

DESIGNWORKS


First Floor, 33,Ranjit Road, kotturpuram, Chennai - 600 085, India
Tel: +91 - 44 - 4230 3731/32/33
Fax: +91 - 44 - 42303734
E-mail: mail@designworks.in
Web: www.designworks.in



Lacquer PU - Asian paints Woodtech Spectra - Pure white RAL 9010



Veneer - Red oak

 

10mm thk Toughened Clear glass with stickering

Any discrepancy should be brought to the notice of the architects.

Handle & Lock

12mm thk Toughened
Glass door

— 100 [4'']

as per site

2150 [7'-2"]
(matched to
existing lintel @site)

— 100 [4"]

– 1000 [3'-4'']

100 [4'']

1200 [4']

— 100 [4"]

ELEVATION

Lounge

Gym

Solid wood Door frame
matched to Veneer stain
(100mm x 40mm)

PLAN

For Discussion	☐	Site Copy	☐
For Approval	☐	Clients Copy	☐
Good For Construction	☐	Contractors Copy	☐

Drawn : Durgaa	Scale :	Date : 19.07.
Checked : Divya Sign :	dwg no :	

File Path:


drawing:
Lounge & Gym door

project:

Proposed Residence for
Mr. Thyagrajan @ M.R.C nagar

DESIGNWORKS

First Floor, 33.Ranjit Road,
kotturpuram, Chennai - 600 085, India
Tel: +91- 44 - 4230 3731/32/33
Fax: +91- 44 - 42303734
E-mail: mail@designworks.in
Web: www.designworks.in

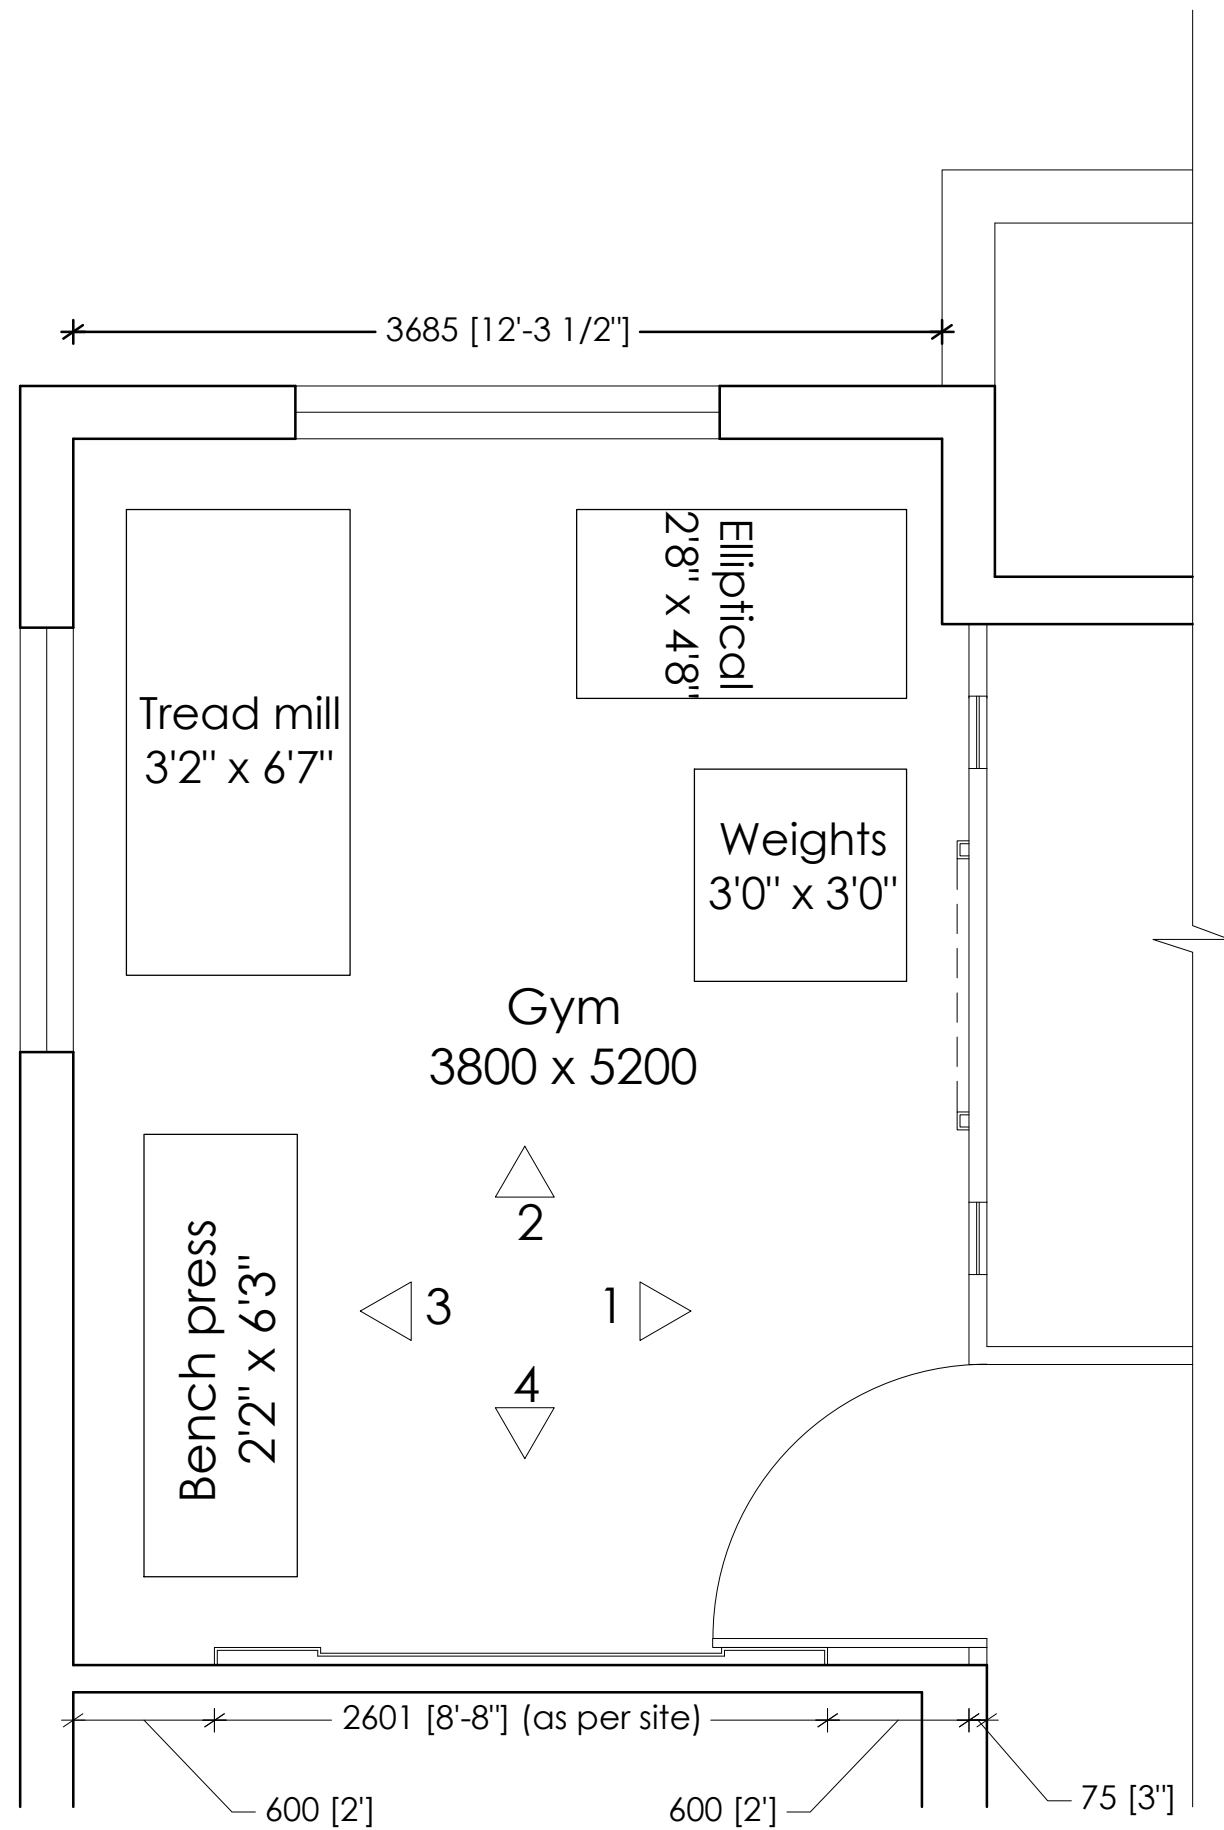

NOTES:
This drawing is the property of designworks & cannot be used or reproduced any form without their written permission.
Any discrepancy should be brought to the notice of the architects.
Only written dimensions should be followed, the drawing is not to be scaled.



For Discussion	☐	Site Copy	☐
For Approval	☐	Clients Copy	☐
Good For Construction	☐	Contractors Copy	☐

Drawn : Durgaa	Scale : NTS	Date: 07.07.22
Checked : Divya Sign :	dwg no :	
File Path :		

drawing:
GYM - LAYOUT

project:
Proposed Residence for
Mr. Thyagrajan @ M.R.C nagar

DESIGNWORKS
First Floor, 33,Ranjit Road,
kotturpuram, Chennai - 600 085, India
Tel: +91 - 44 - 4230 3731/32/33
Fax: +91- 44 - 42303734
E-mail: mail@designworks.in
Web: www.designworks.in

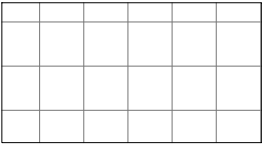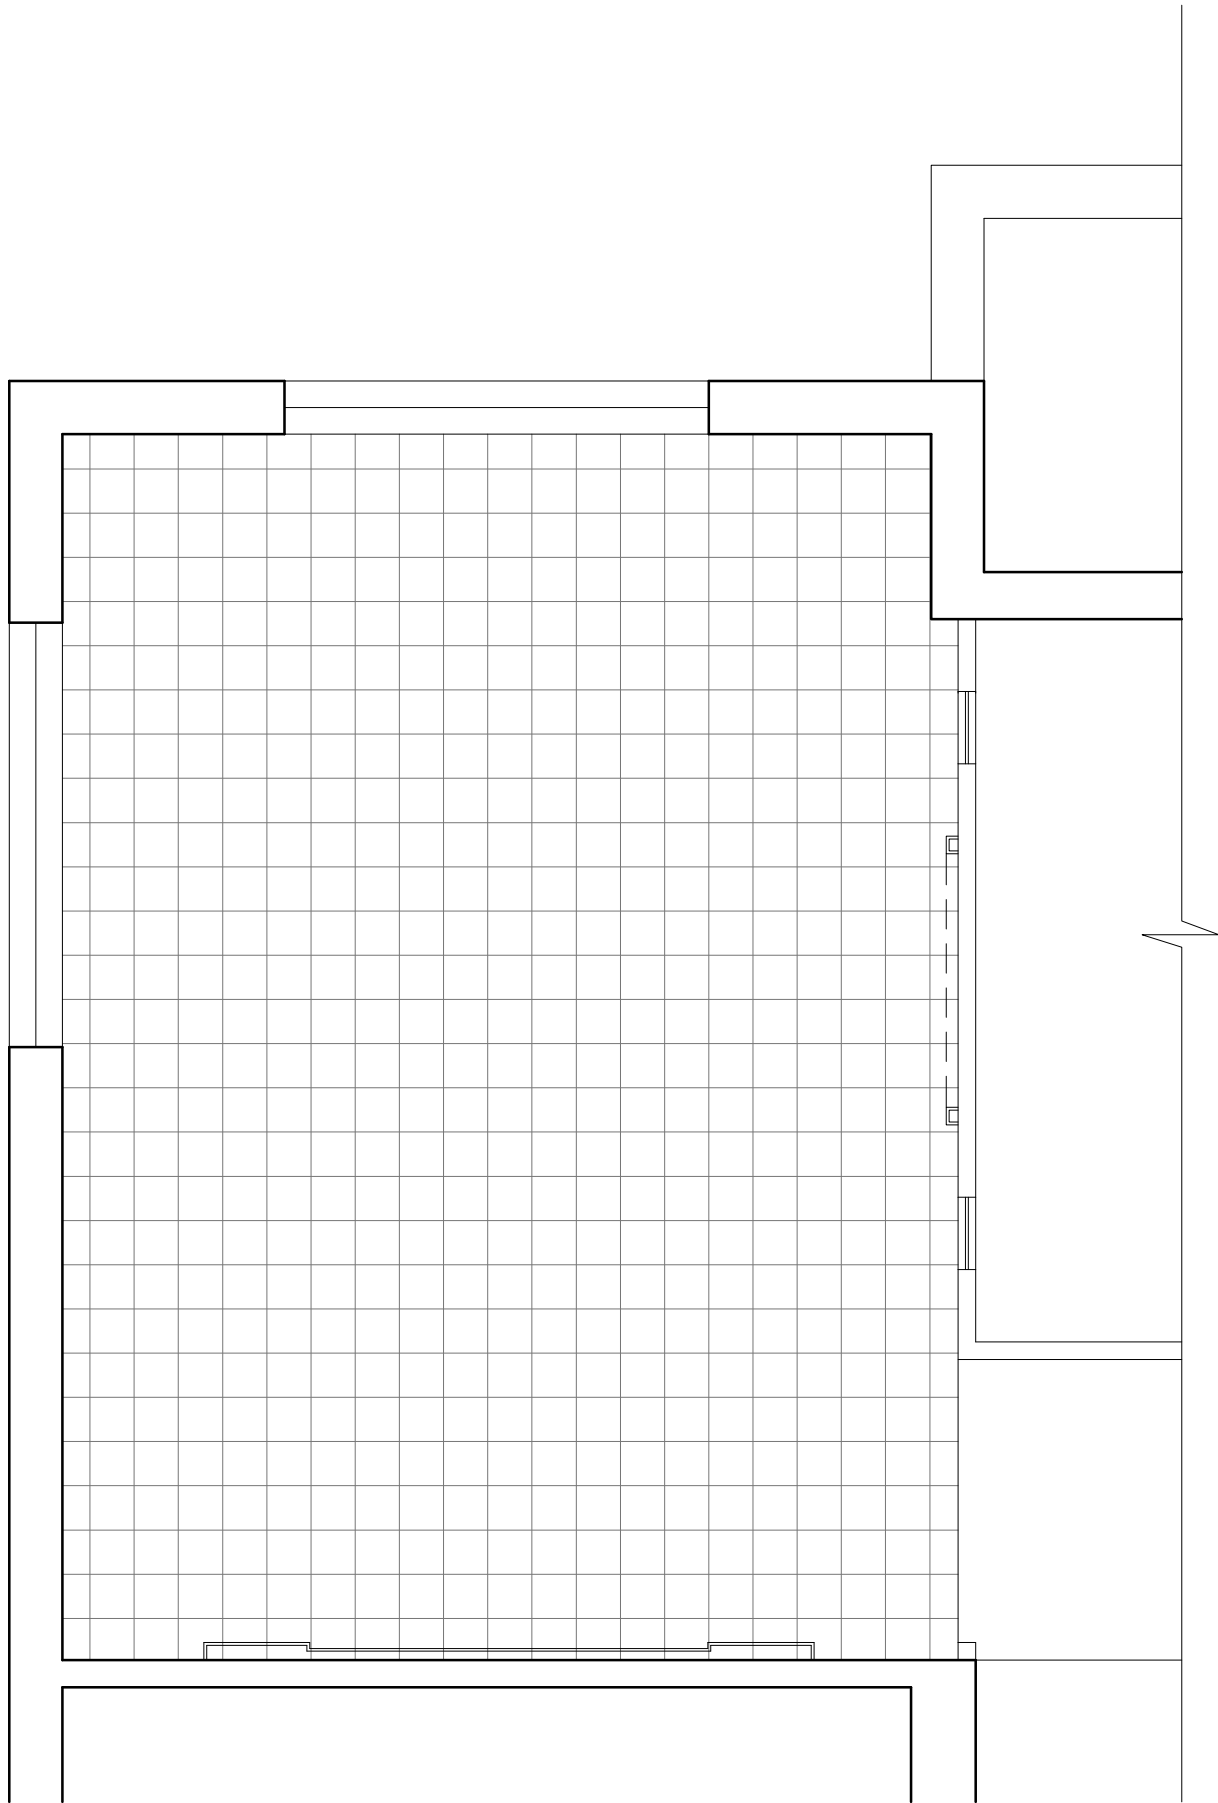

Rubber flooring
(with Basic tile
below)

NOTES:
This drawing is the property of
designworks & cannot be used or
reproduced any form without their
written permission.

Any discrepancy should be brought
to the notice of the architects.

Only written dimensions should be
followed, the drawing is not to be
scaled.

For Discussion	☐	Site Copy	☐
For Approval	☐	Clients Copy	☐
Good For Construction	☐	Contractors Copy	☐


Drawn : Durgaa	Scale : NTS	Date: 07.07.22
Checked : Divya Sign :	dwg no :	
File Path :		

drawing :
GYM - FLOORING LAYOUT


project:
Proposed Residence for
Mr. Thyagrajan @ M.R.C nagar

DESIGNWORKS



First Floor, 33,Ranjit Road,
kotturpuram, Chennai - 600 085, India
Tel: +91 - 44 - 4230 3731/32/33
Fax: +91- 44 - 42303734
E-mail: mail@designworks.in
Web: www.designworks.in

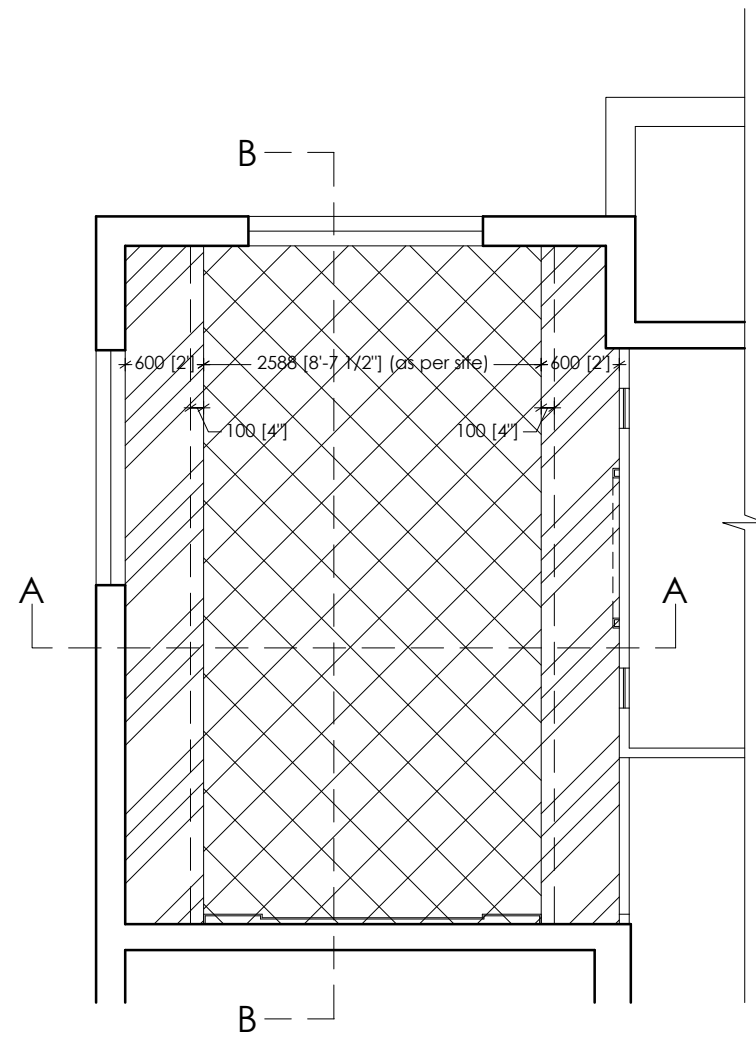

FALSE CEILING LAYOUT- PLAN

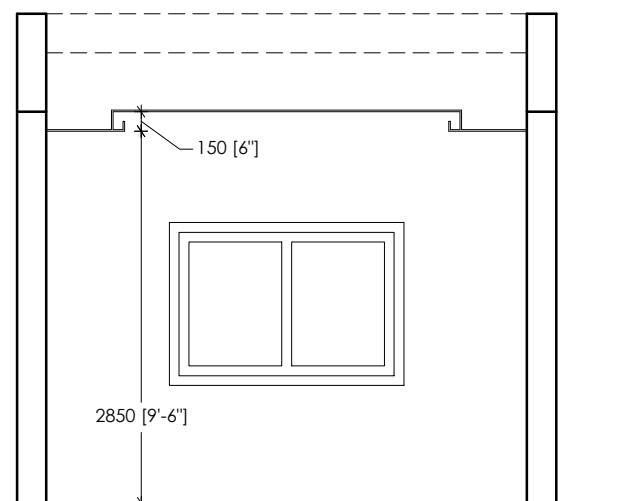

Section AA

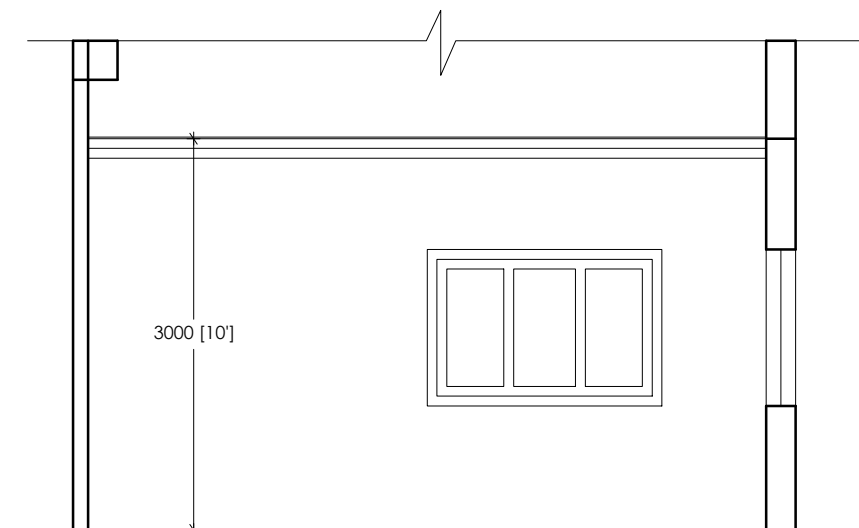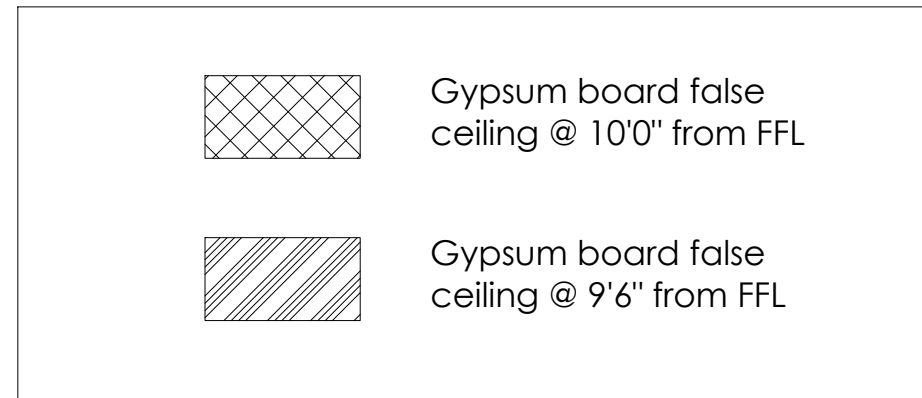

Section BB

NOTES:
This drawing is the property of designworks & cannot be used or reproduced any form without their written permission.

Any discrepancy should be brought to the notice of the architects.

Only written dimensions should be followed, the drawing is not to be scaled.

For Discussion	☐	Site Copy	☐
For Approval	☐	Clients Copy	☐
Good For Construction	☐	Contractors Copy	☐

Drawn : Durgaa	Scale: NTS	Date: 08.07.22
Checked : Divya Sign :	dwg no :	


File Path:

drawing:
Gym - False ceiling layout


project:
Proposed Residence for
Mr. Thyagrajan @ M.R.C nagar

DESIGNWORKS

First Floor, 33.Ranjit Road,
kotturpuram, Chennai - 600 085, India
Tel: +91- 44 - 4230 3731/32/33
Fax: +91- 44 - 42303734
E-mail: mail@designworks.in
Web: www.designworks.in

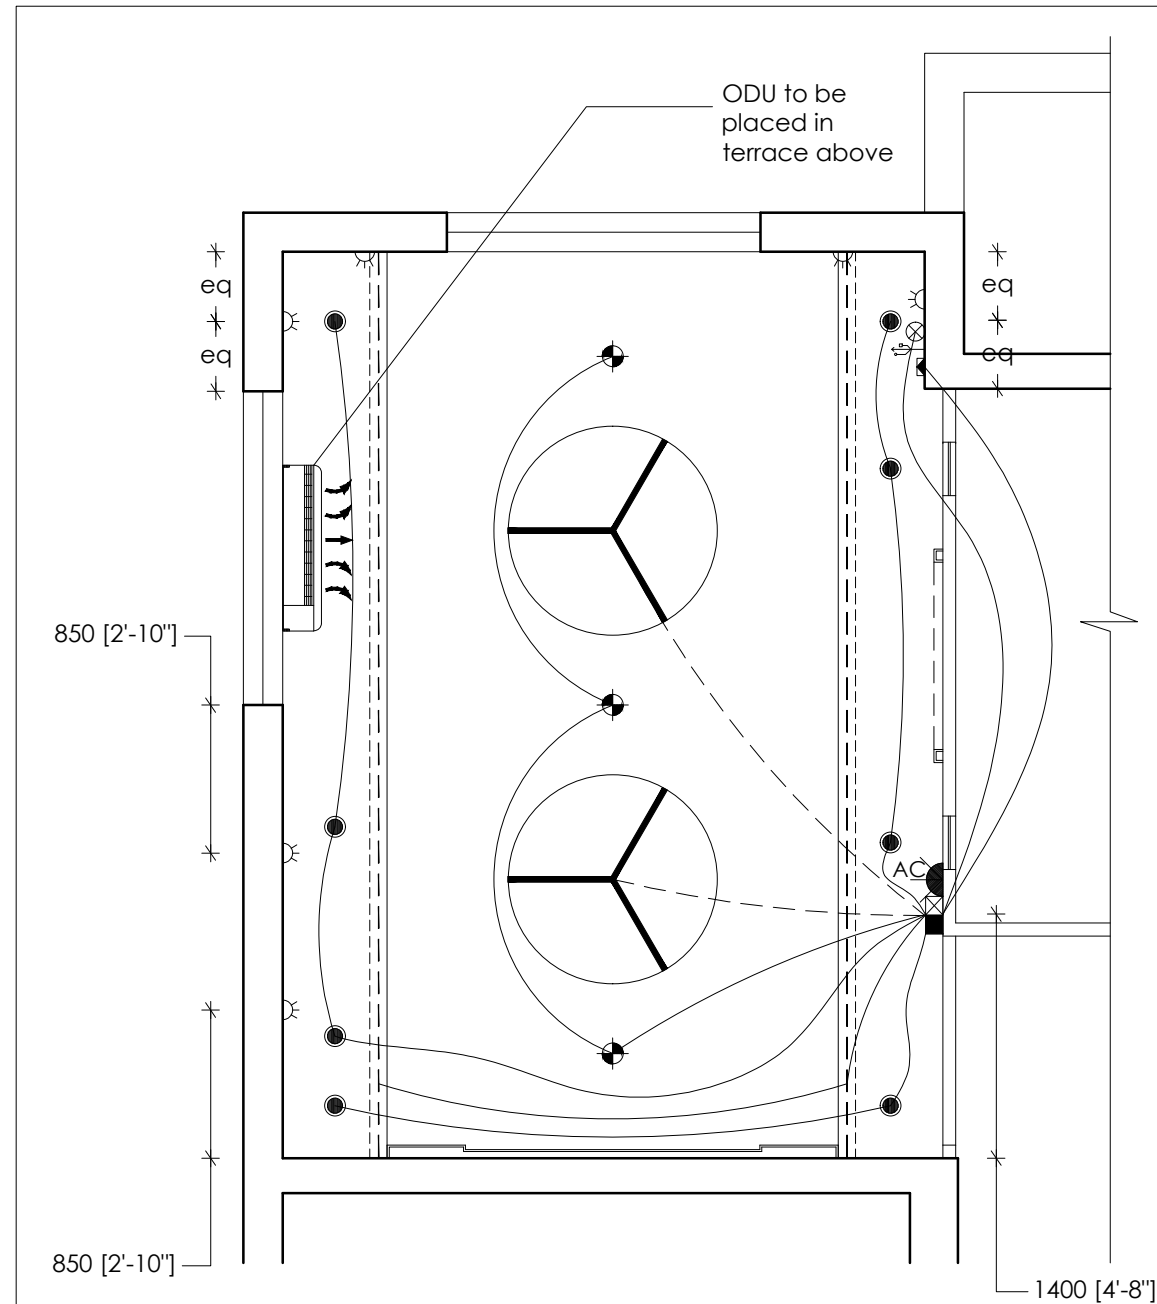

ELECTRICAL LAYOUT

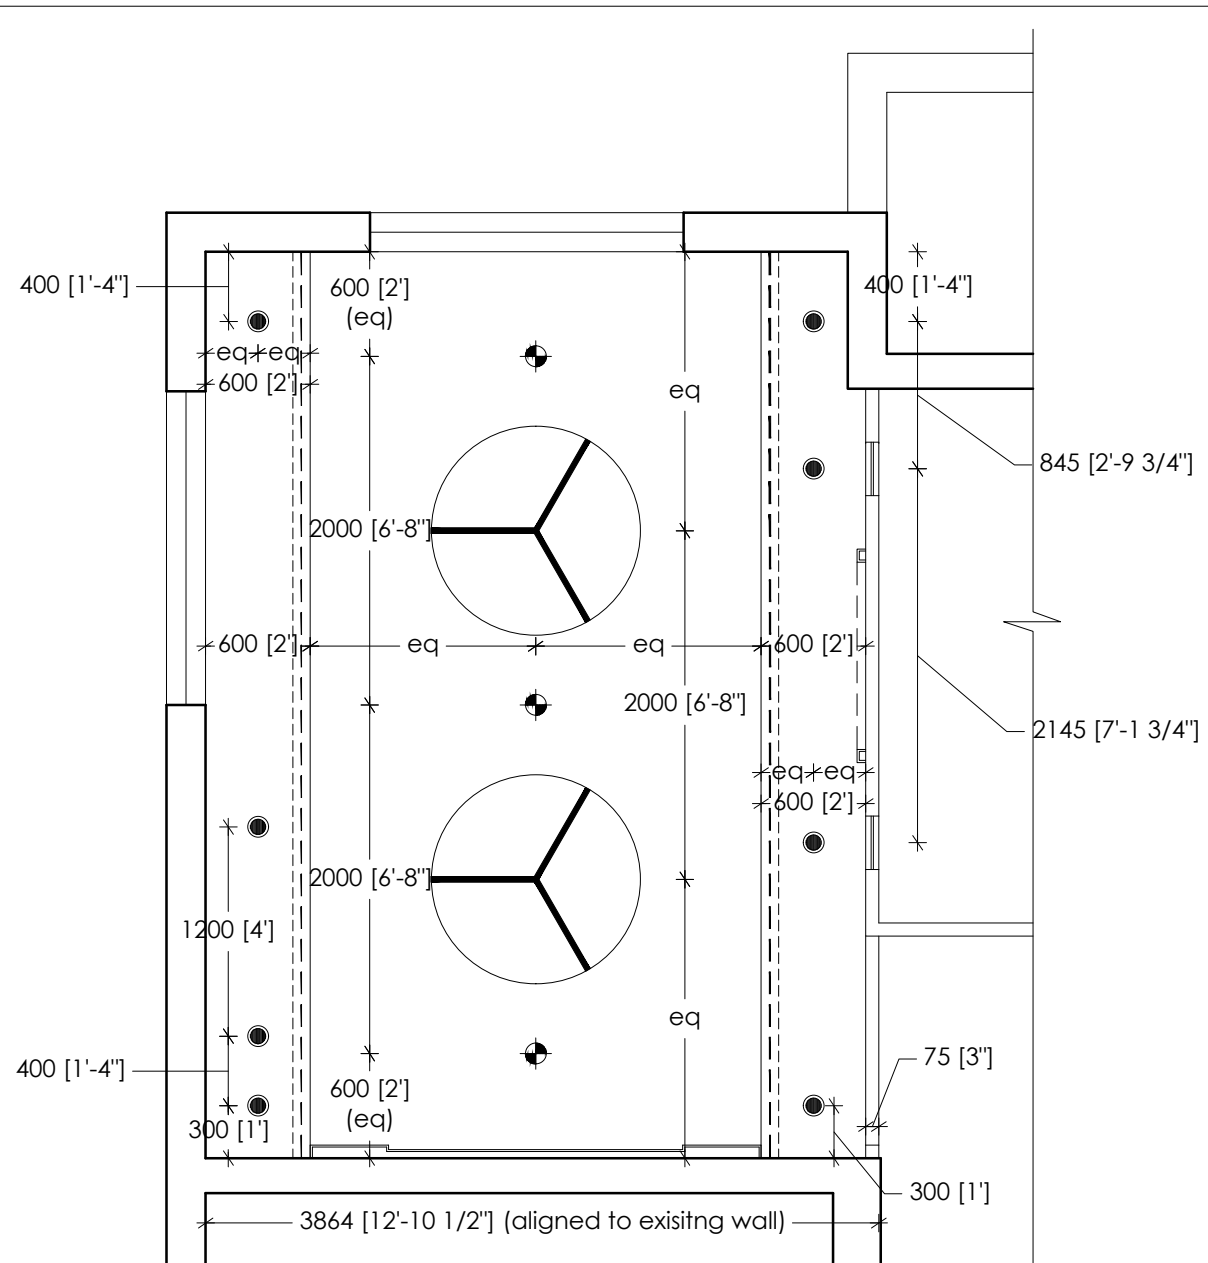

LIGHTING LAYOUT

NOTES:
This drawing is the property of designworks & cannot be used or reproduced any form without their written permission.
Any discrepancy should be brought to the notice of the architects.
Only written dimensions should be followed, the drawing is not to be scaled.

For Discussion	☐	Site Copy	☐
For Approval	☐	Clients Copy	☐
Good For Construction	☐	Contractors Copy	☐

Drawn : Durgaa	Scale : NTS	Date: 09.07.22
Checked : Divya Sign :	dwg no :	


File Path:


drawing :
Gym - Electrical & Lighting Layout

project :
Proposed Residence for
Mr. Thyagrajan @ M.R.C nagar


DESIGNWORKS
First Floor, 33,Ranjit Road,
kotturpuram, Chennai - 600 085, India
Tel: +91 - 44 - 4230 3731/32/33
Fax: +91 - 44 - 42303734
E-mail: mail@designworks.in
Web: www.designworks.in

	1 NOS. 5 / 15 amps combined socket + switch with socket bottom @ 1'9" from F.F.L		Switch box with 1no. 5amps socket + switch with socket bottom @ 4'0" from F.F.L		Provision for Data
	LED Spotlight		AC Control		2 NOs. 5amps socket @ 5'6" from F.F.L
	LED Downlight		1 NO. 5amps socket + switch with socket bottom @ 3'6" from F.F.L		
	LED Striplight		Ceiling fan - 4'0" Dia		
	AC Indoor unit				

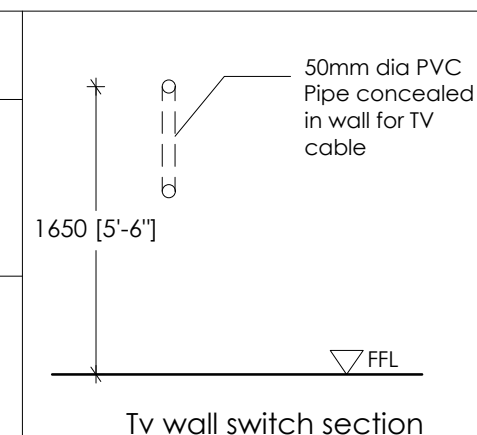


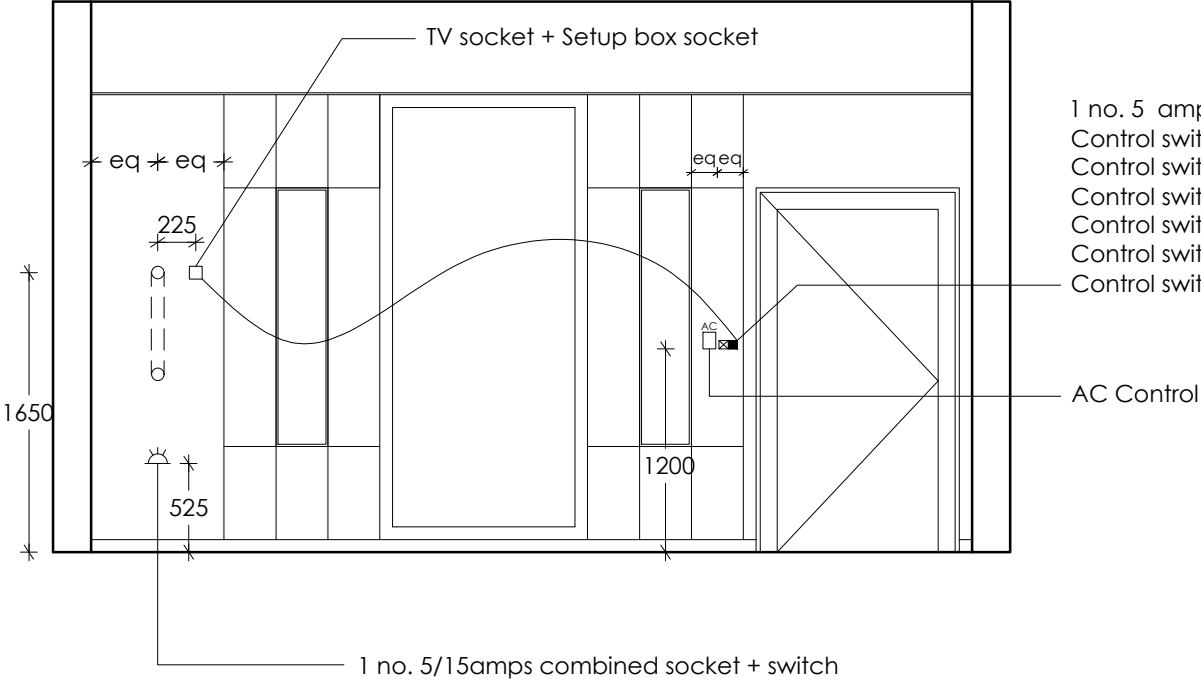


ELEVATION 1

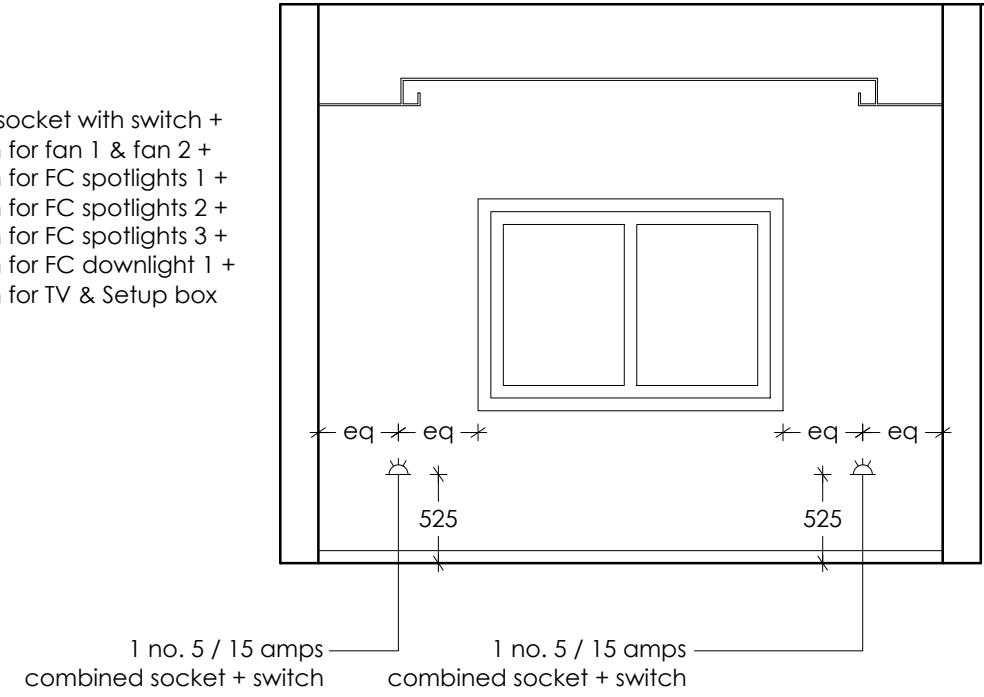

ELEVATION 2

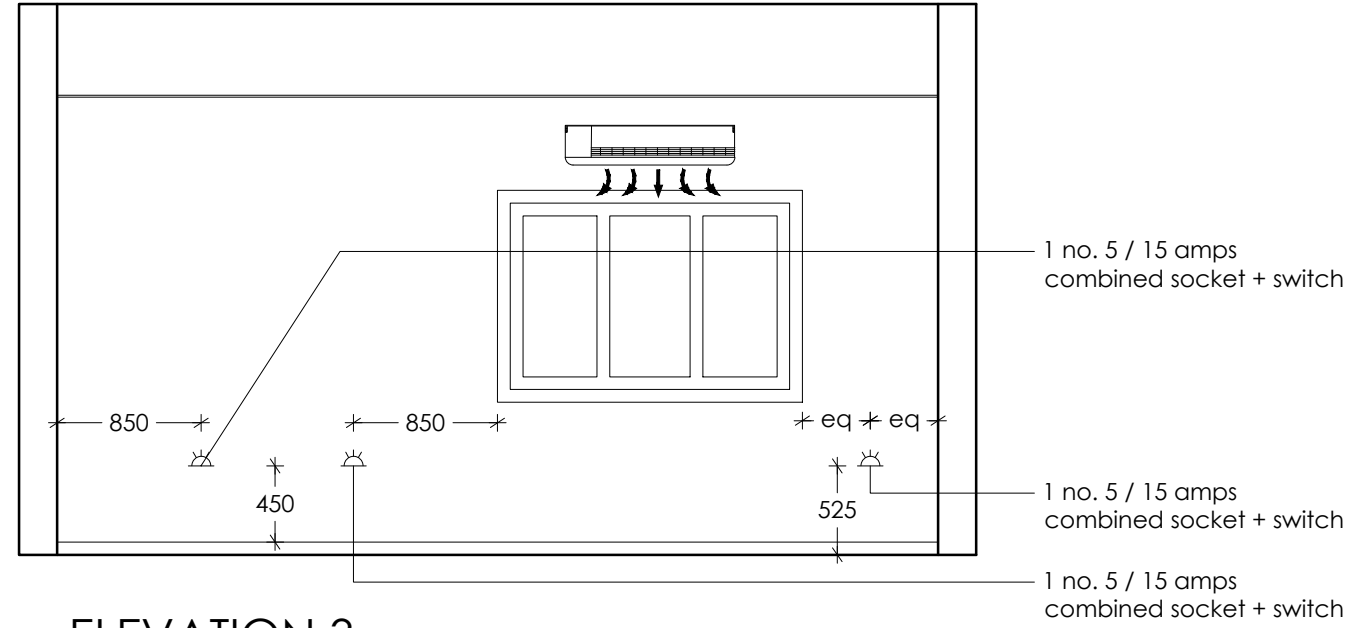

ELEVATION 3

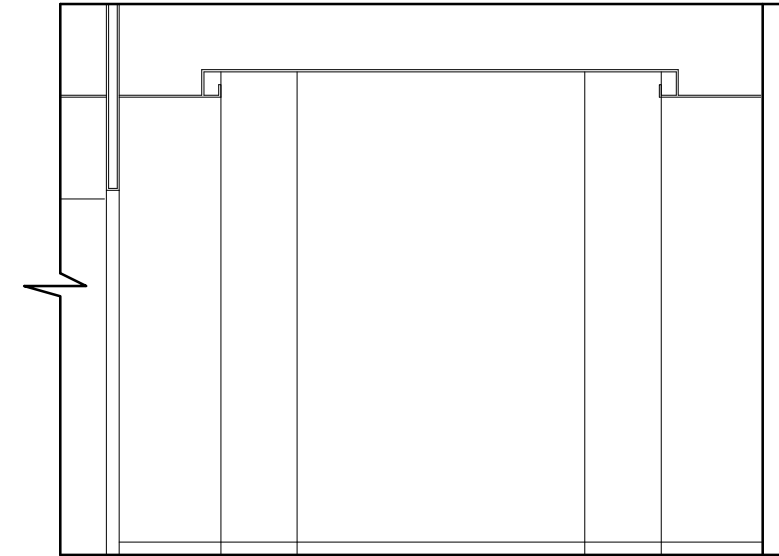

ELEVATION 4

NOTES:
This drawing is the property of
designworks & cannot be used or
reproduced any form without their
written permission.

Any discrepancy should be brought
to the notice of the architects.

Only written dimensions should be
followed, the drawing is not to be
scaled.

For Discussion	☐	Site Copy	☐
For Approval	☐	Clients Copy	☐
Good For Construction	☐	Contractors Copy	☐

Drawn : Durgaa	Scale :	Date: 19.07.22
Checked : Divya Sign :	dwg no :	


File Path:

drawing :
Gym - Electrical wall elevations


project :
Proposed Residence for
Mr. Thyagrajan @ M.R.C nagar

DESIGNWORKS

First Floor, 33,Ranjit Road,
kotturpuram, Chennai - 600 085, India
Tel: +91 - 44 - 4230 3731/32/33
Fax: +91- 44 - 42303734
E-mail: mail@designworks.in
Web: www.designworks.in

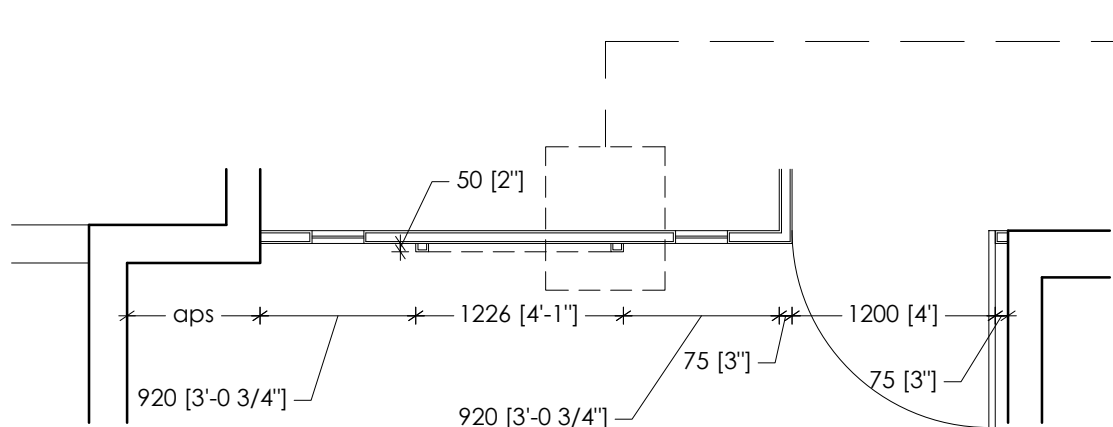


PLAN 1

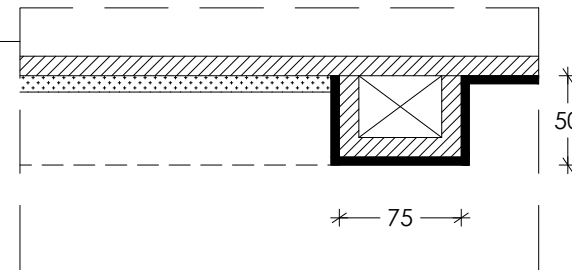

NOTES:
This drawing is the property of designworks & cannot be used or reproduced any form without their written permission.

Any discrepancy should be brought to the notice of the architects.

Only written dimensions should be followed, the drawing is not to be scaled.

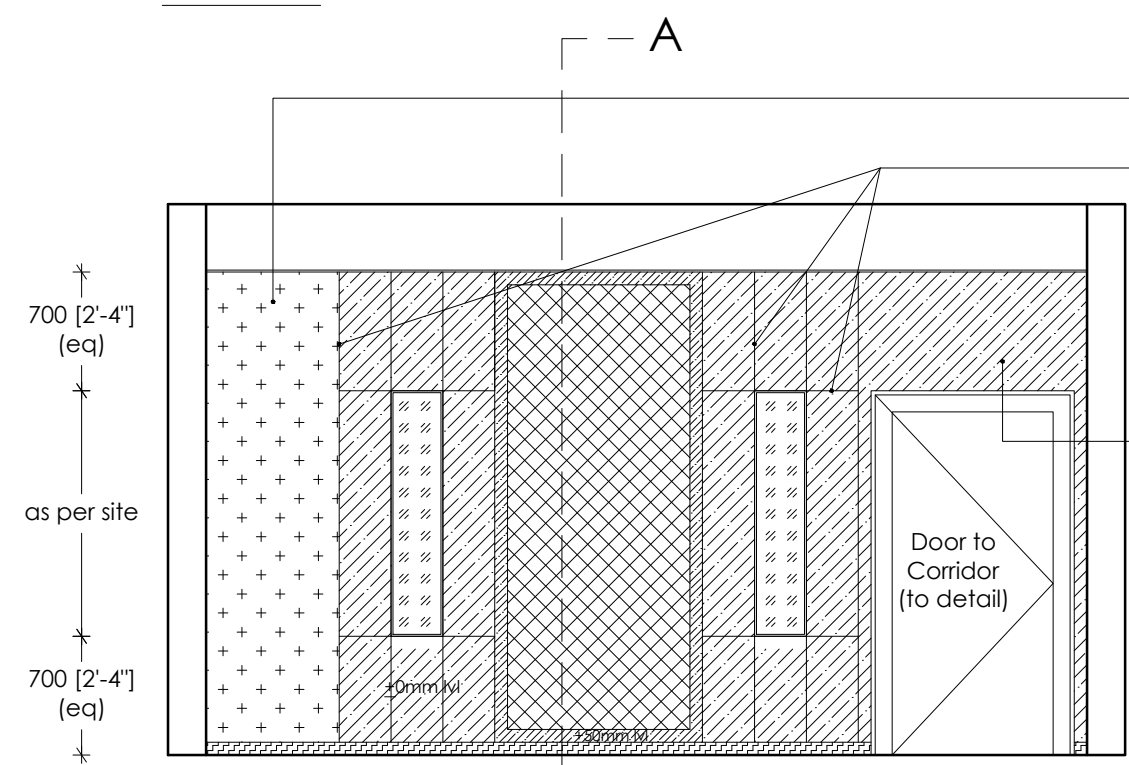


ELEVATION 1

Wall surface finished with Wall paint - Asian paints - Morning Glory - 0765



4mm Veneer groove

3" thk Plwood partition finished with Veneer

Door to Corridor (to detail)

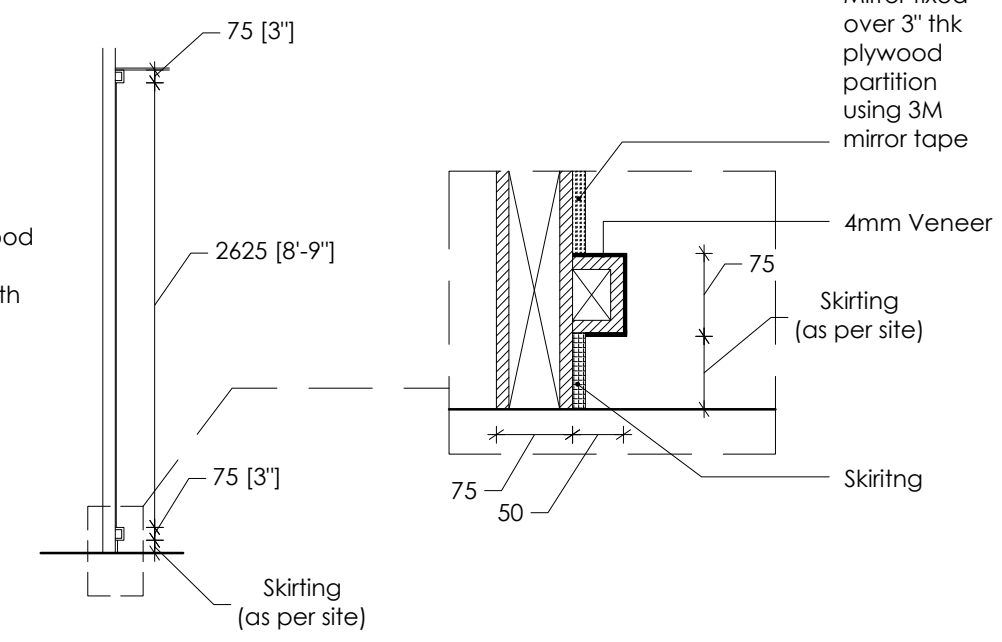


SECTION AA

 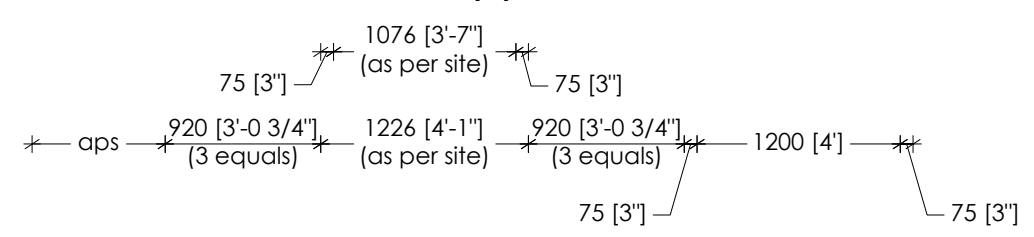


Red Oak Veneer



 6mm thk Mirror



10mm thk Toughened Clear glass

 

Wall paint - Asian paints - Morning Glory - 0765

For Discussion	☐	Site Copy	☐
For Approval	☐	Clients Copy	☐
Good For Construction	☐	Contractors Copy	☐


Drawn : Durgaa	Scale : NTS	Date: 18.07.22
Checked : Divya Sign :	dwg no :	

File Path:

drawing:
Gym wall elevations

project:
Proposed Residence for Mr. Thyagrajan @ M.R.C nagar


DESIGNWORKS
First Floor, 33,Ranjit Road, kotturpuram, Chennai - 600 085, India
Tel: +91- 44 - 4230 3731/32/33
Fax: +91- 44 - 42303734
E-mail: mail@designworks.in
Web: www.designworks.in

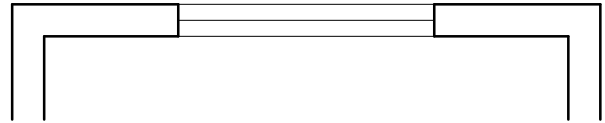

PLAN 2

2850 [9'-6"]


3000 [10']

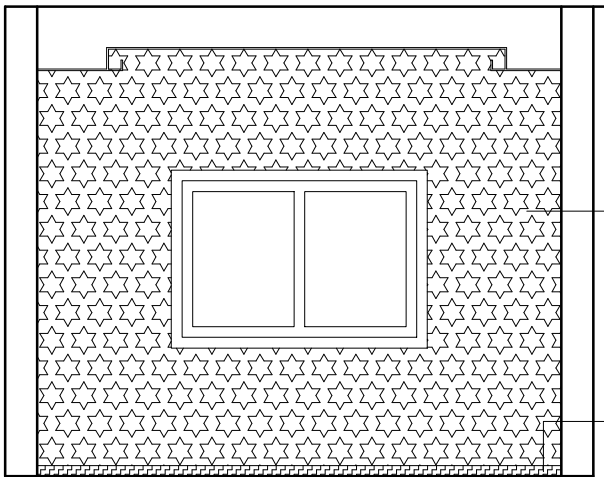

Wall surface finished with Wallpaper 1

Skirting


ELEVATION 2

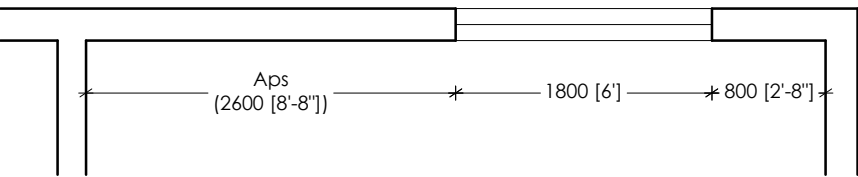

PLAN 3


2850 [9'-6"]

2850 [9'-6"]

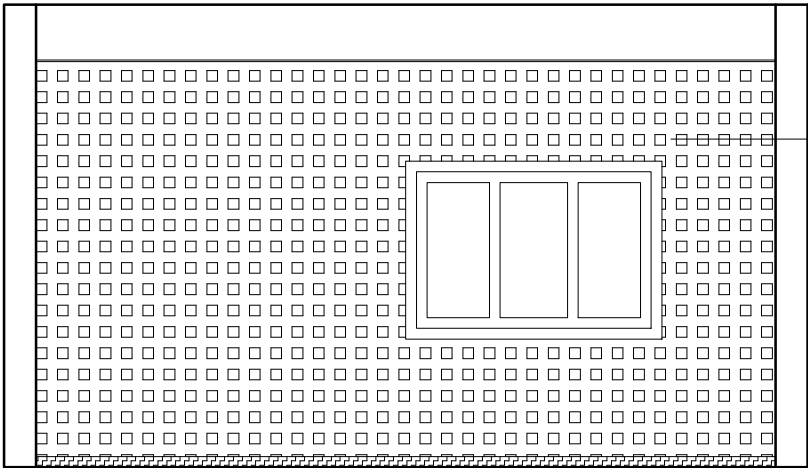

Wall surface finished with Wallpaper 2


ELEVATION 3

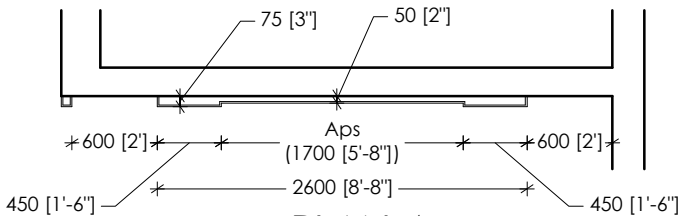

PLAN 4

2850 [9'-6"]

3000 [10']

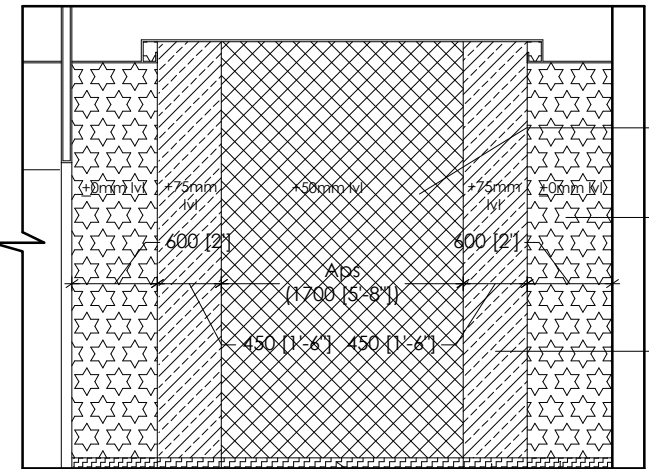

Mirror fixed over 12mm ply


Wall finished with wallpaper 1

Plywood finished with Red Oak veneer


Skirting

Skirting fixed over panelling

 
ELEVATION 4




Wallpaper 1

 


Wallpaper 2

 

Red Oak Veneer

 

Mirror

 

Skirting

NOTES:
This drawing is the property of designworks & cannot be used or reproduced any form without their written permission.

Any discrepancy should be brought to the notice of the architects.

Only written dimensions should be followed, the drawing is not to be scaled.

For Discussion	☐	Site Copy	☐
For Approval	☐	Clients Copy	☐
Good For Construction	☐	Contractors Copy	☐

Drawn : Durgaa	Scale : NTS	Date: 18.07.22
Checked : Divya Sign :	dwg no:	


File Path:

drawing:
Gym wall elevations

project:
Proposed Residence for Mr. Thyagrajan @ M.R.C nagar

DESIGNWORKS
First Floor, 33,Ranjit Road, kotturpuram, Chennai - 600 085, India
Tel: +91 - 44 - 4230 3731/32/33
Fax: +91 - 44 - 42303734
E-mail: mail@designworks.in
Web: www.designworks.in


Utility
3600 X 2450

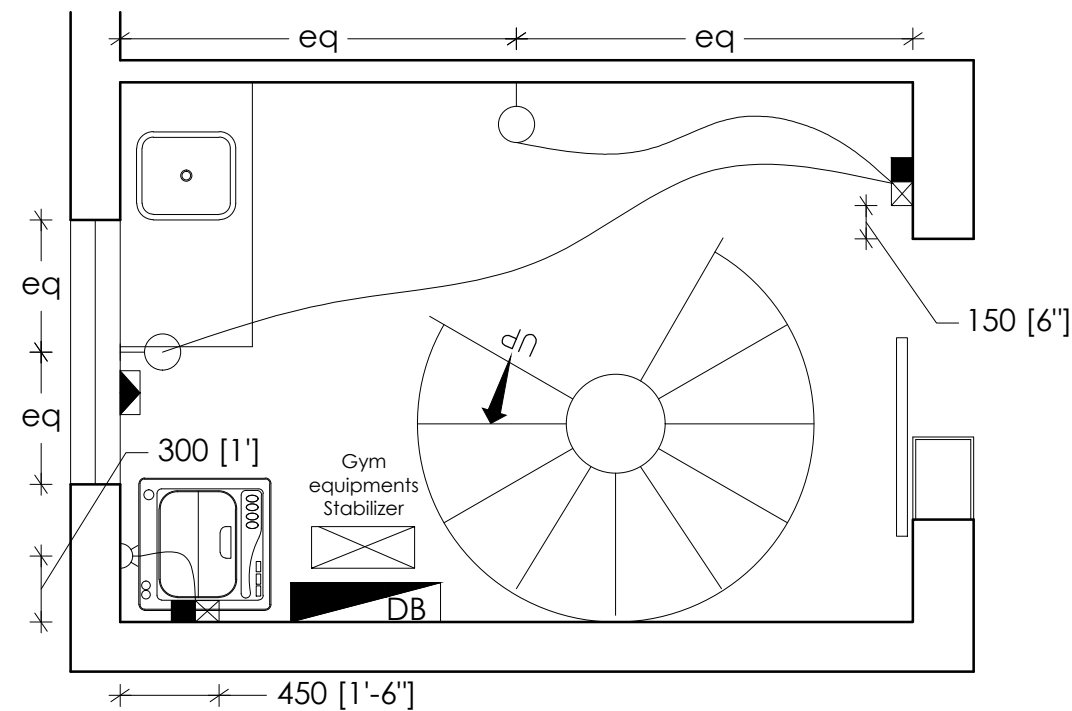

ELECTRICAL LAYOUT

Utility

Terrace

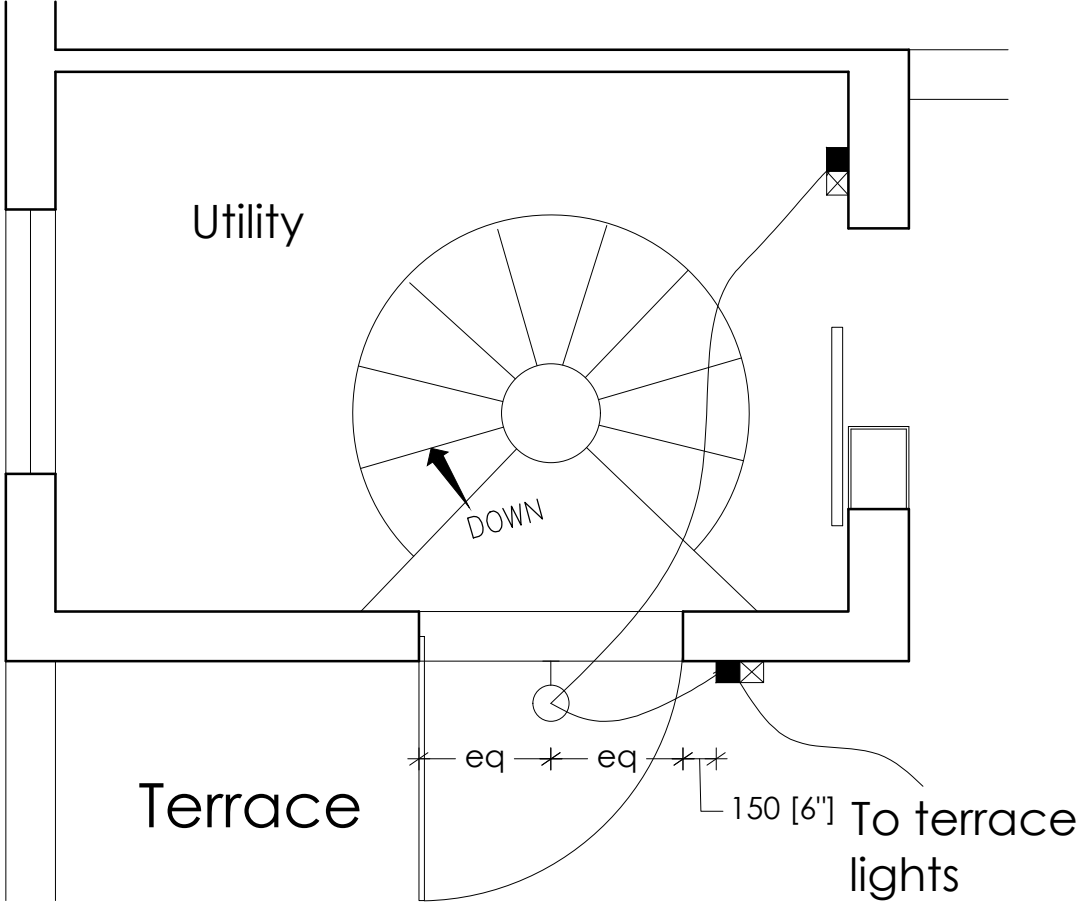

ELECTRICAL LAYOUT

NOTES:
This drawing is the property of designworks & cannot be used or reproduced any form without their written permission.
Any discrepancy should be brought to the notice of the architects.
Only written dimensions should be followed, the drawing is not to be scaled.

For Discussion	☐	Site Copy	☐
For Approval	☐	Clients Copy	☐
Good For Construction	☐	Contractors Copy	☐

Drawn : Durgaa	Scale : NTS	Date : 09.07.22
Checked : Divya	dwg no :	
Sign :		

File Path :

drawing :
Utility - Electrical Layout

project:
Proposed Residence for
Mr. Thyagrajan @ M.R.C nagar

DESIGNWORKS
First Floor, 33,Ranjit Road,
kotturpuram, Chennai - 600 085, India
Tel: +91 - 44 - 4230 3731/32/33
Fax: +91 - 44 - 42303734
E-mail: mail@designworks.in
Web: www.designworks.in

	Electrical DB		Stabilizer for Gym Equipments
	Switch box with 1 no. 5amps socket + switch with socket bottom @ 4'0" from F.F.L		1 NOS. 15 amps socket with socket bottom @ 1'9" from F.F.L
	Wall light @ 8'0" from F.F.L		Switch box with 2nos. 5amps socket + switch with socket bottom @ 6" above countertop

TITLE OF THE PROJECT

PROJECT TYPOLOGY

CLIENT

LOCATION

PROJECT STATUS

:

:

:

:

:

ANBUMANI RESIDENCE

RESIDENCE - APARTMENT


Mr. ANBUMANI

ROYAPURAM, CHENNAI


ON-GOING

Kitchen electrical will be based on
Final kitchen Shop drawing

Only written dimensions should be followed, the drawing is not to be scaled.

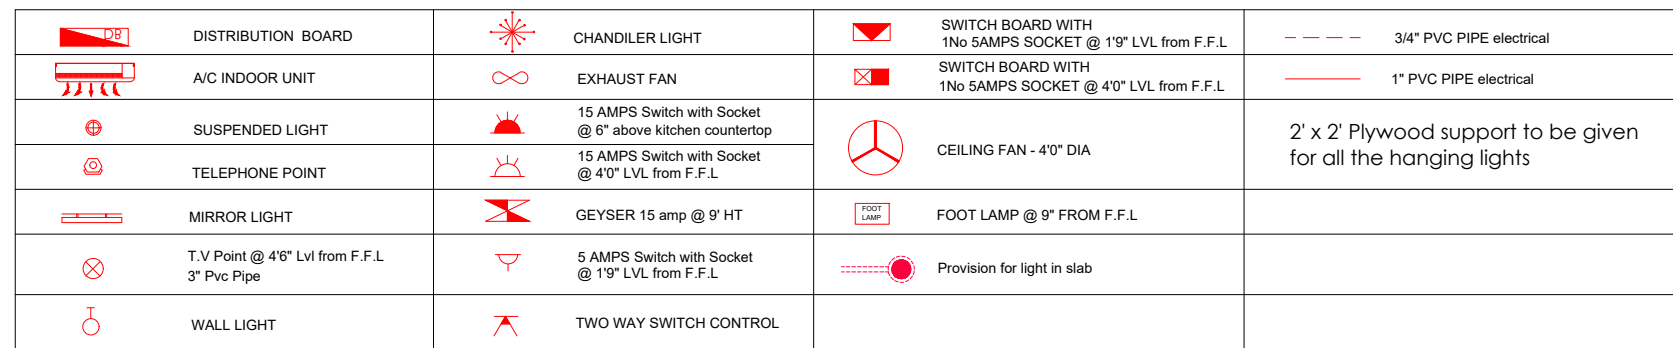


First Floor, 33, Ranjith Road
Kotturpuram, Chennai - 600 085
Tel: +91- 44 - 4230 3732/33
E-mail: mail@designworks.in
Web: www.designworks.in

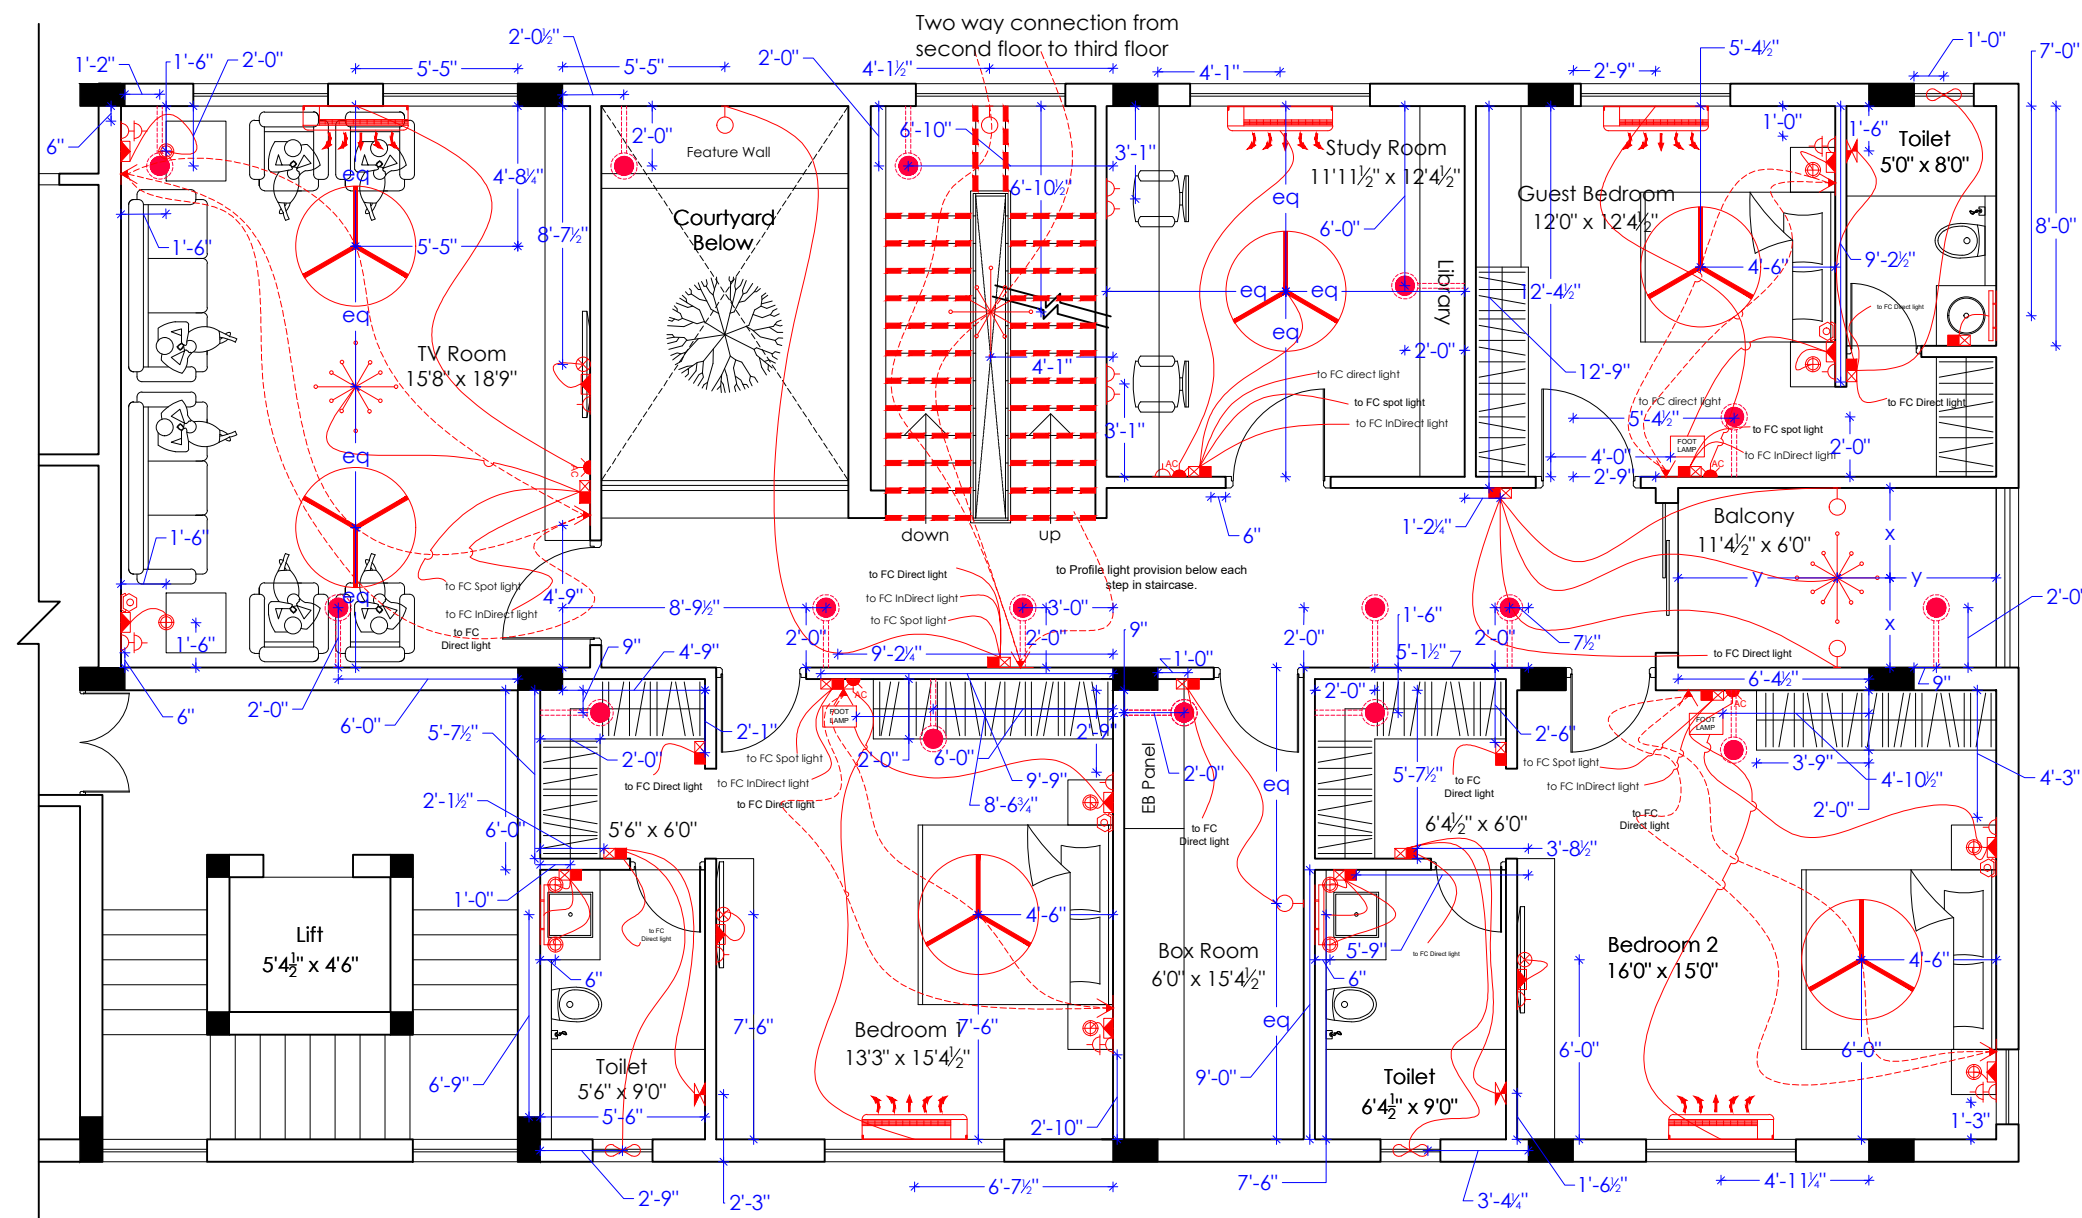

	DISTRIBUTION BOARD		CHANDILER LIGHT		SWITCH BOARD WITH 1No 5AMPS SOCKET @ 1'9" LVL from F.F.L		3/4" PVC PIPE electrical
	A/C INDOOR UNIT		EXHAUST FAN		SWITCH BOARD WITH 1No 5AMPS SOCKET @ 4'0" LVL from F.F.L		1" PVC PIPE electrical
	SUSPENDED LIGHT		15 AMPS Switch with Socket @ 6" above kitchen countertop		CEILING FAN - 4'0" DIA	2' x 2' Plywood support to be given for all the hanging lights	
	TELEPHONE POINT		15 AMPS Switch with Socket @ 4'0" LVL from F.F.L				
	MIRROR LIGHT		GEYSER 15 amp @ 9' HT		FOOT LAMP @ 9" FROM F.F.L		
	T.V Point @ 4'6" Lvl from F.F.L 3" Pvc Pipe		5 AMPS Switch with Socket @ 1'9" LVL from F.F.L		Provision for light in slab		
	WALL LIGHT		TWO WAY SWITCH CONTROL				

NOTE : Need to provide a dummy switch in switch board in every room

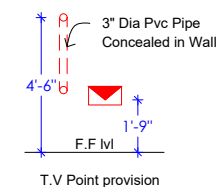

NOTES:
This drawing is the property of designworks & cannot be used or reproduced any form without their written permission.

Any discrepancy should be brought to the notice of the architects.

Only written dimensions should be followed, the drawing is not to be scaled.

For Discussion	☐	Site Copy	☐
For Approval	☐	Clients Copy	☐
Good For Construction	☐	Contractors Copy	☐


Drawn : Durgaa	Scale : NTS	Date: 16.07.22
Checked : Divya Sign :	dwg no :	

drawing :
Third floor plan - Electrical layout


project :
Proposed Residence for Mr.Anbumani @ Royapuram, Chennai

DESIGNWORKS
Architects | Interior Designers | Planners


First Floor, 33, Ranjith Road
Kotturpuram, Chennai - 600 085
Tel: +91- 44 - 4230 3732/33
E-mail: mail@designworks.in
Web: www.designworks.in

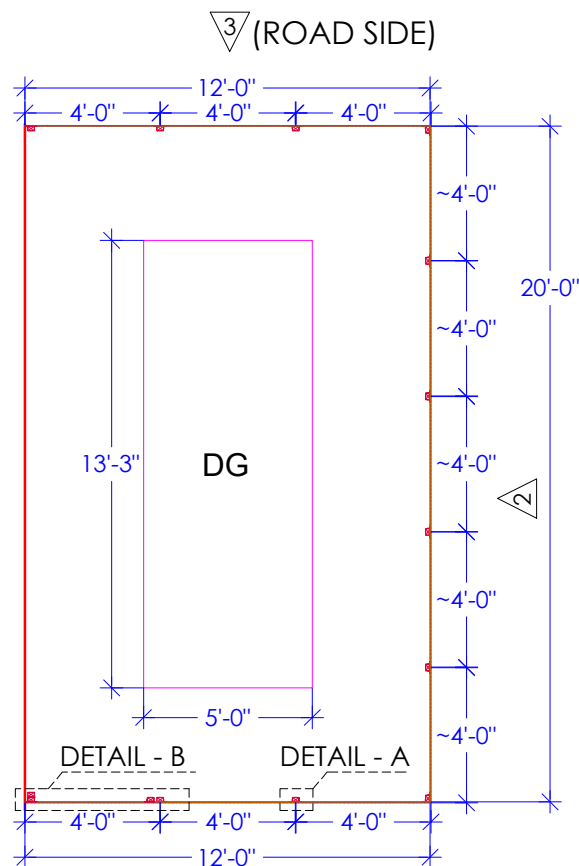


DG Platform - PLAN

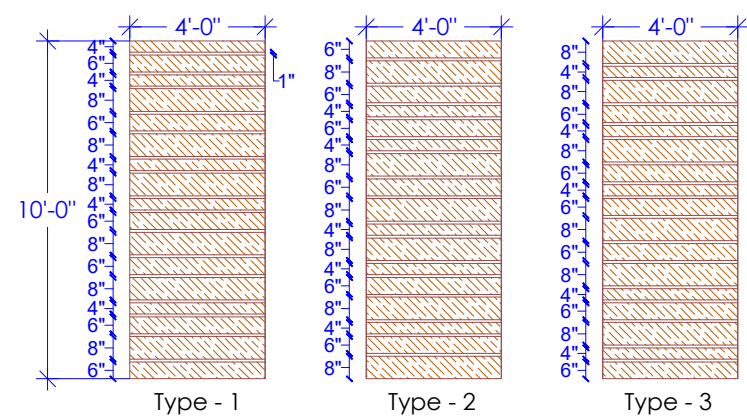


ELEVATION - 1

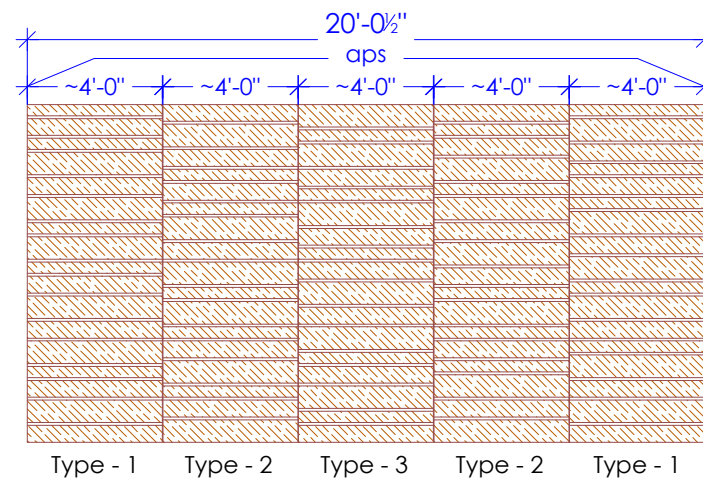


ELEVATION - 2

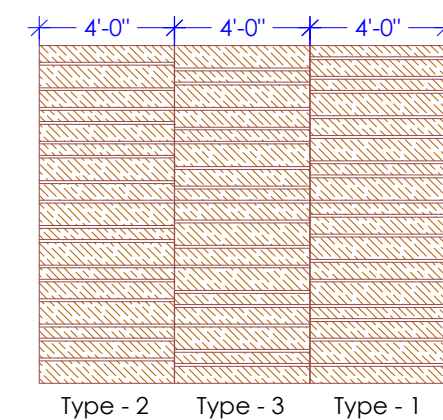


ELEVATION - 3

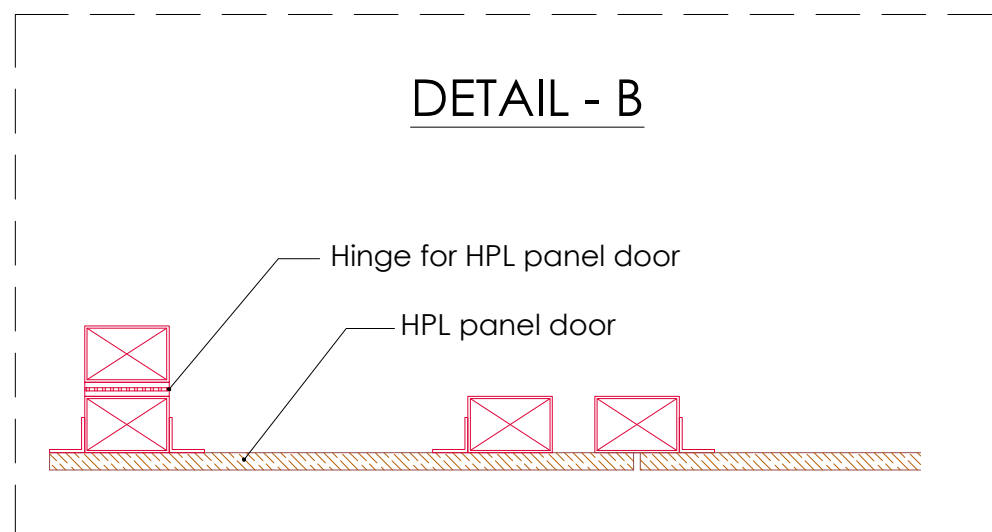

DETAIL - B

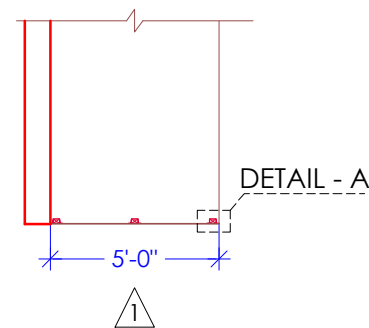


Storage - PLAN

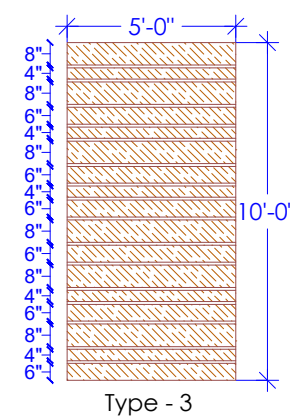

ELEVATION - 1

DETAIL - A

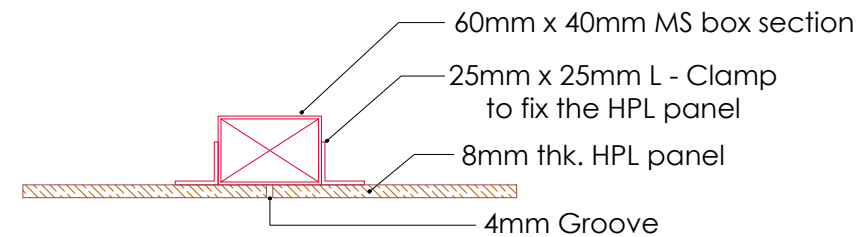

- HPL PANELS

NOTES:
This drawing is the property of designworks & cannot be used or reproduced any form without their written permission.

Any discrepancy should be brought to the notice of the architects.

Only written dimensions should be followed, the drawing is not to be scaled.

For Discussion	☐	Site Copy	☐
For Approval	☐	Clients Copy	☐
Good For Construction	☒	Contractors Copy	☐


Drawn : Durgaa	Scale : NTS	Date: 08.08.22
Checked : RajeshH Sign :	dwg no :	

drawing :
EXTERIOR - HPL PANEL DETAIL


project :
Proposed commercial -
Amma Naana @ ECR

DESIGNWORKS
Architects | Interior Designers | Planners

First Floor, 33, Ranjith Road
Kotturpuram, Chennai - 600 085
Tel: +91- 44 - 4230 3732/33
E-mail: mail@designworks.in
Web: www.designworks.in

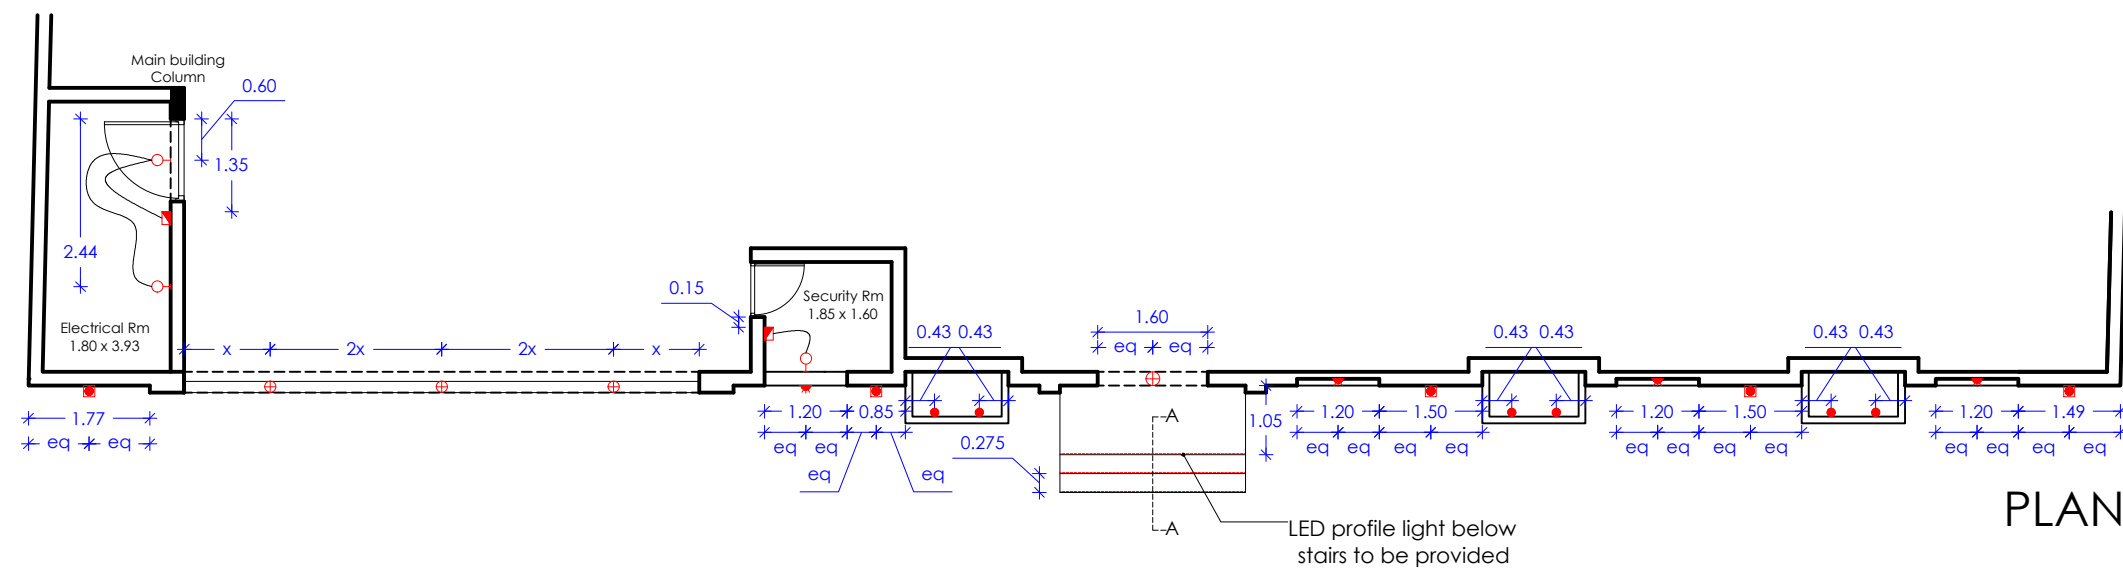


PLAN

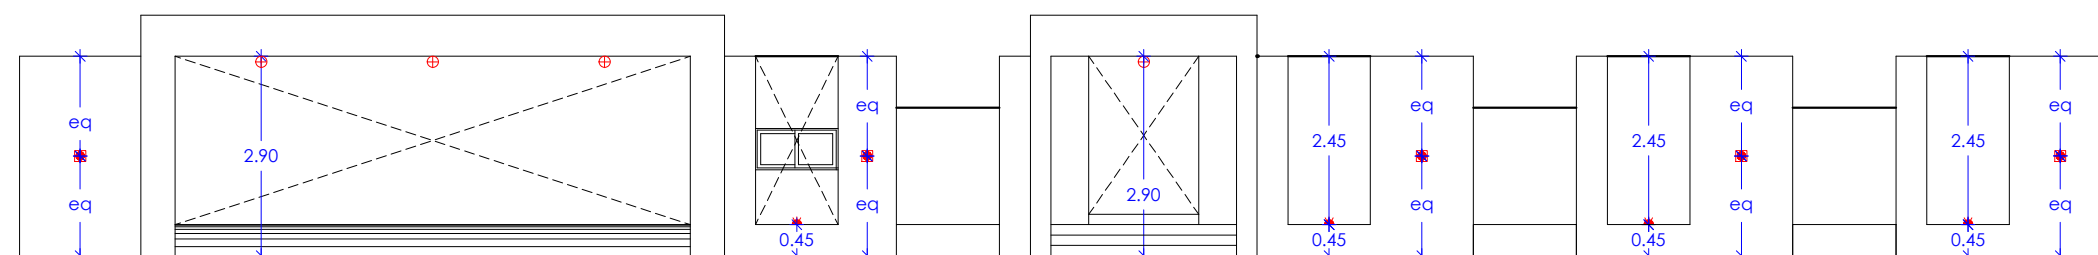

FRONT ELEVATION

	Surface mounted downlight	
	Two way surface mounted light	
	Surface mounted Spot light	

	Spike light
	Wall light
	Switch board with 1No 5 amps socket @ 4'0" LVL

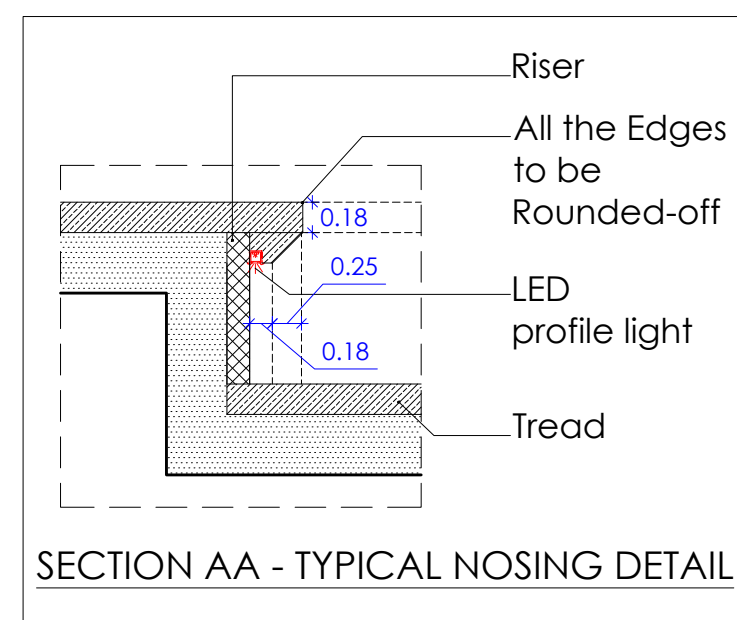

SECTION AA - TYPICAL NOSING DETAIL

NOTE : All the light switches should be connected to the Security room

NOTES:
This drawing is the property of designworks & cannot be used or reproduced any form without their written permission.
Any discrepancy should be brought to the notice of the architects.
Only written dimensions should be followed, the drawing is not to be scaled.

For Discussion	☐	Site Copy	☐
For Approval	☐	Clients Copy	☐
Good For Construction	☐	Contractors Copy	☐


Drawn : Durgaa	Scale : NTS	Date: 05.08.2022
Checked : Rajesh Sign :	dwg no :	
File Path :		

drawing:
East side compound wall - Electrical Layout

Project:
Proposed residential development for Ms. Nanditha @ E.C.R

DESIGNWORKS
Architects | Interior Designers | Planners
First Floor, 33,Ranjit Road, kotturpuram, Chennai - 600 085, India
Tel: +91- 44 - 4230 3731/32/33
Fax: +91- 44 - 42303734
E-mail: mail@designworks.in
Web: www.designworks.in

TITLE OF THE PROJECT	:	UDAY VILAS
PROJECT TYPOLOGY	:	HOSPITALITY - CLUBHOUSE
CLIENT	:	LANDMARK
LOCATION	:	GOPALAPURAM, CHENNAI
PROJECT STATUS	:	ON-GOING

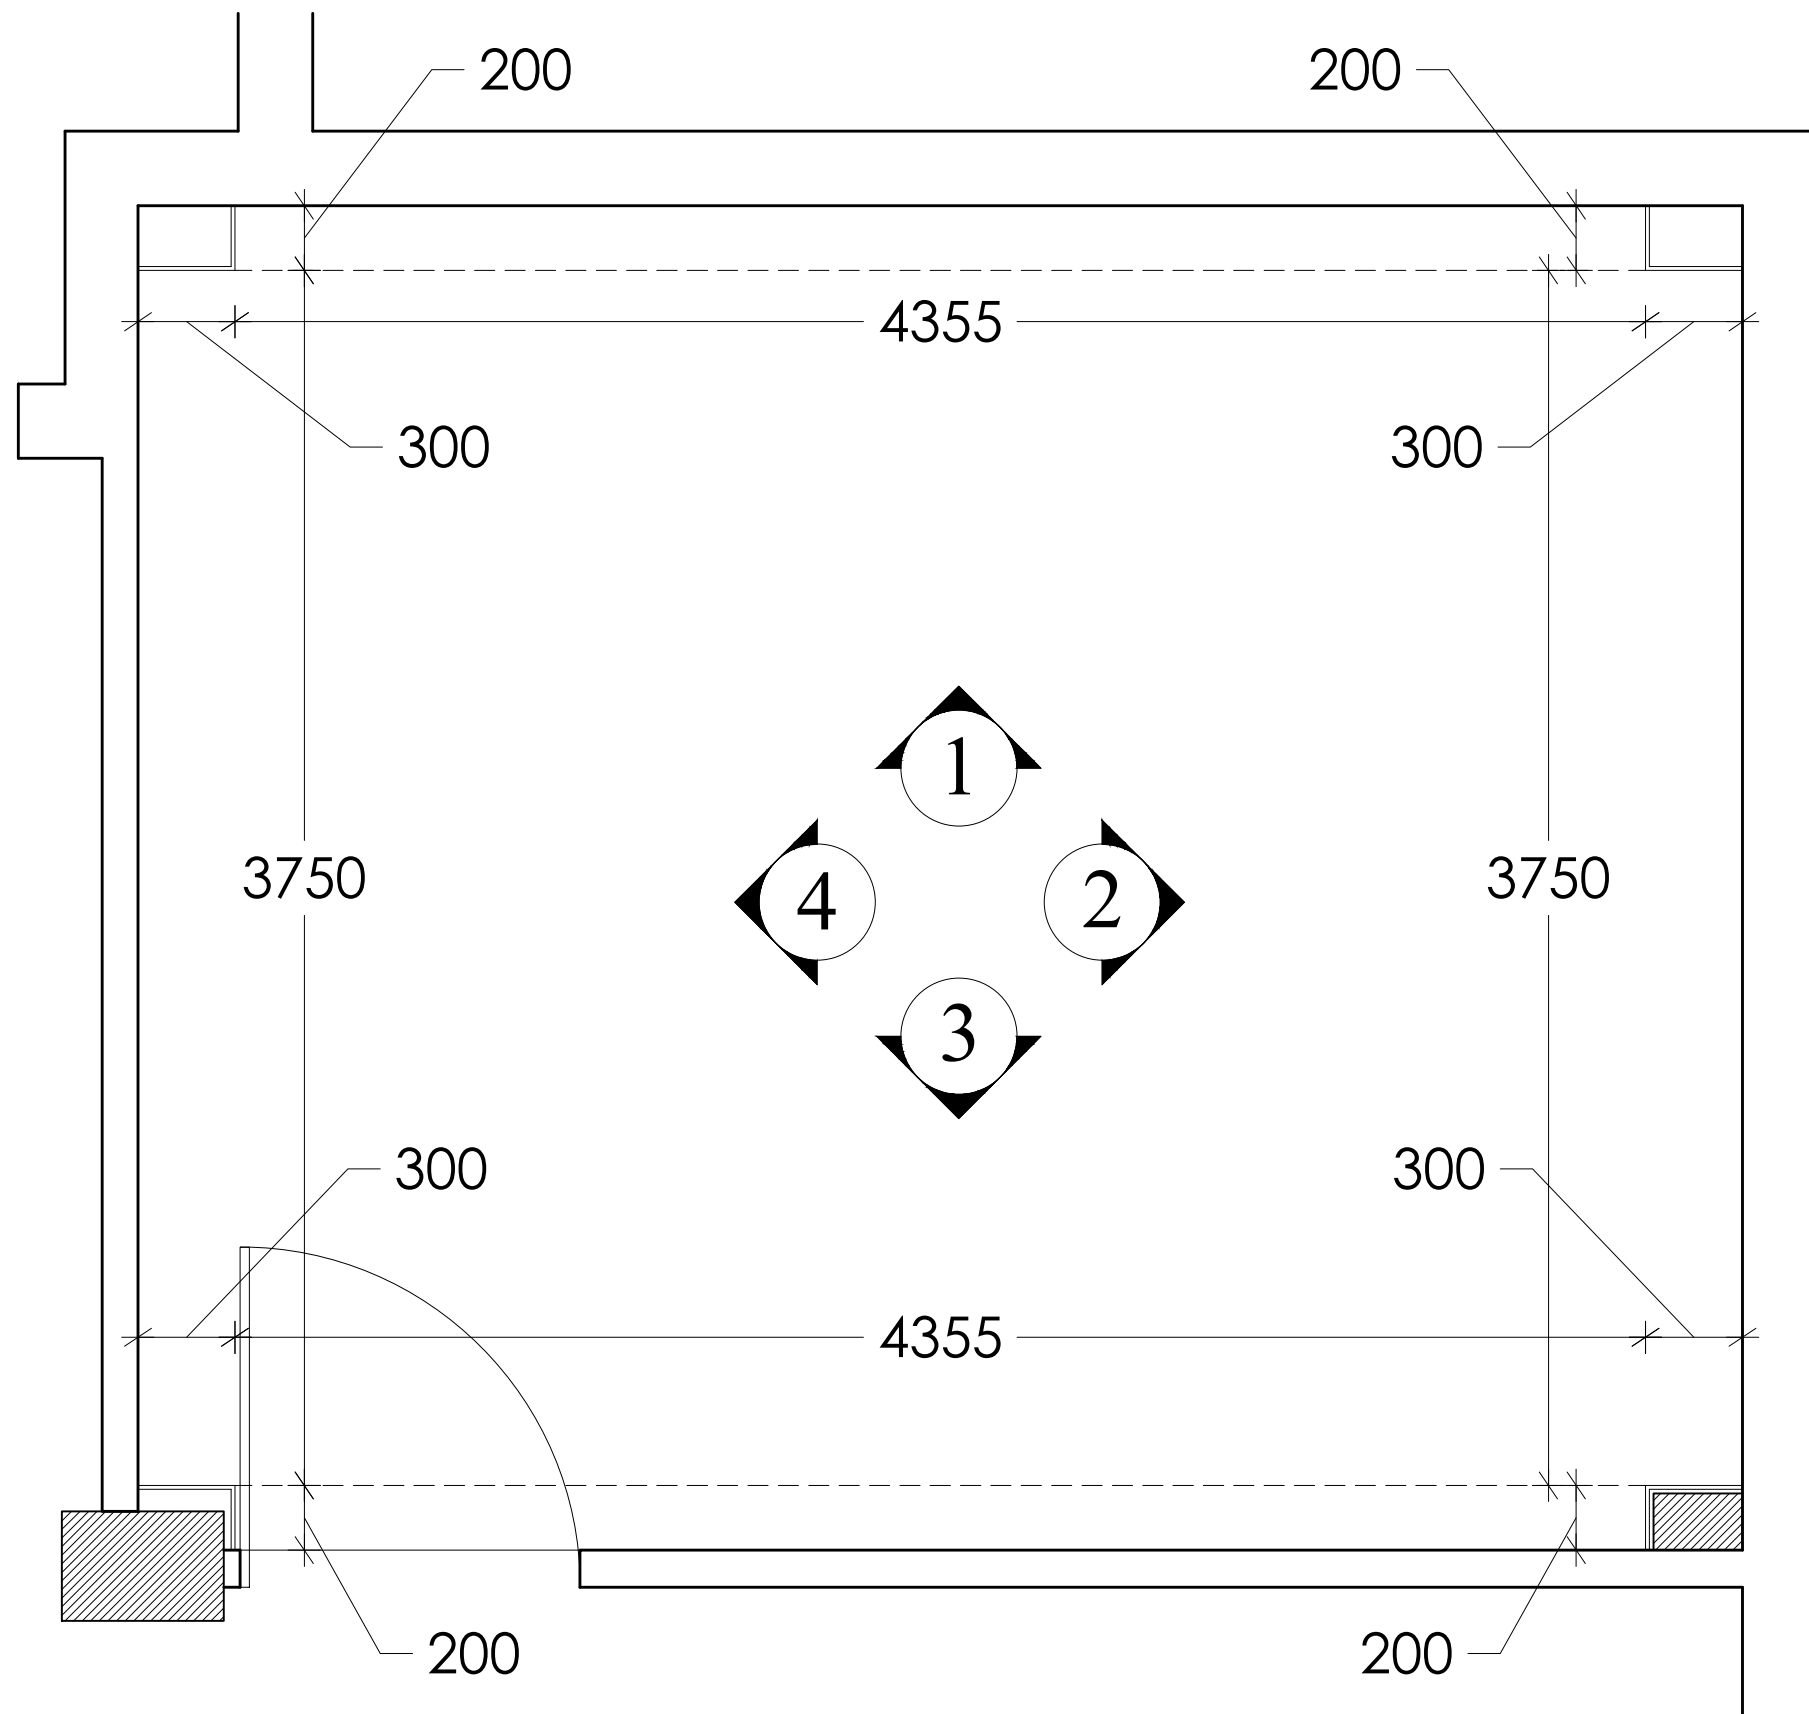

NOTES:
This drawing is the property of designworks & cannot be used or reproduced any form without their written permission.

Any discrepancy should be brought to the notice of the architects.

Only written dimensions should be followed, the drawing is not to be scaled.

For Discussion	☐	Site Copy	☐
For Approval	☐	Clients Copy	☐
Good For Construction	☐	Contractors Copy	☐


Drawn : Durgaa	Scale :	Date : 26.08'22
Checked : Divya Sign :	dwg no :	

drawing:
Clubhouse Lounge - Plan


project:
Proposed clubhouse for Uday Vilas
@ Gopalapuram, Chennai

DESIGNWORKS
Architects | Interior Designers | Planners


First Floor, 33,Ranjit Road,
kotturpuram, Chennai - 600 085, India
Tel: +91- 44 - 4230 3731/32/33
Fax: +91- 44 - 42303734
E-mail: mail@designworks.in
Web: www.designworks.in

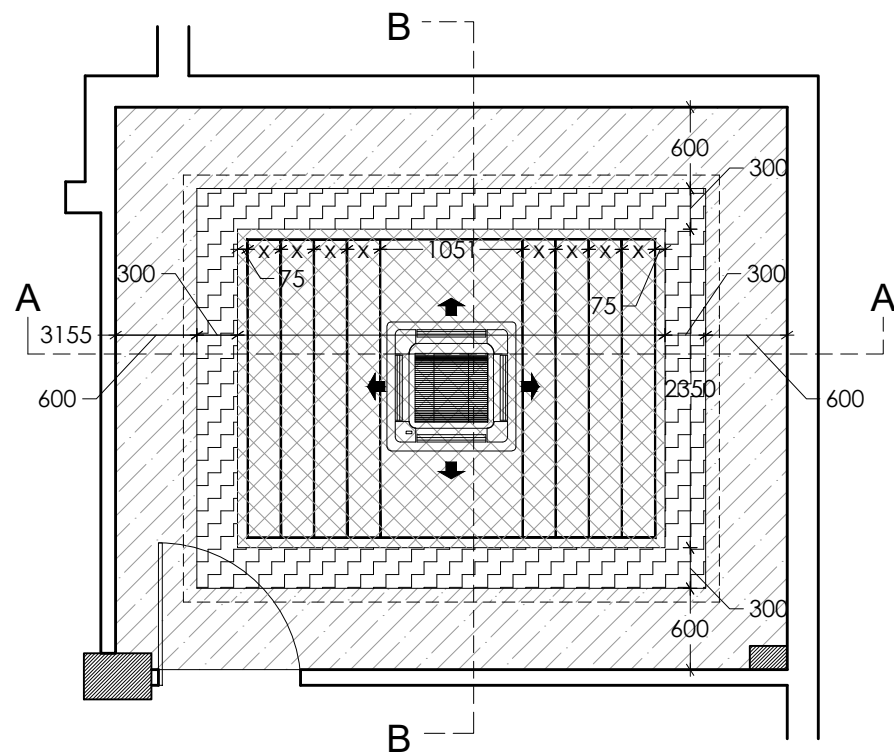


FALSE CEILING LAYOUT

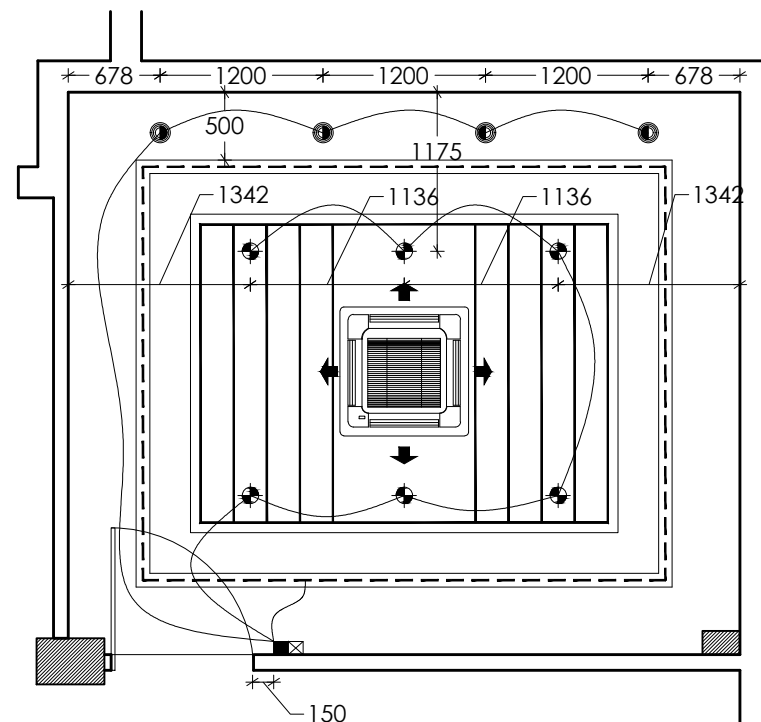


LIGHTING LAYOUT

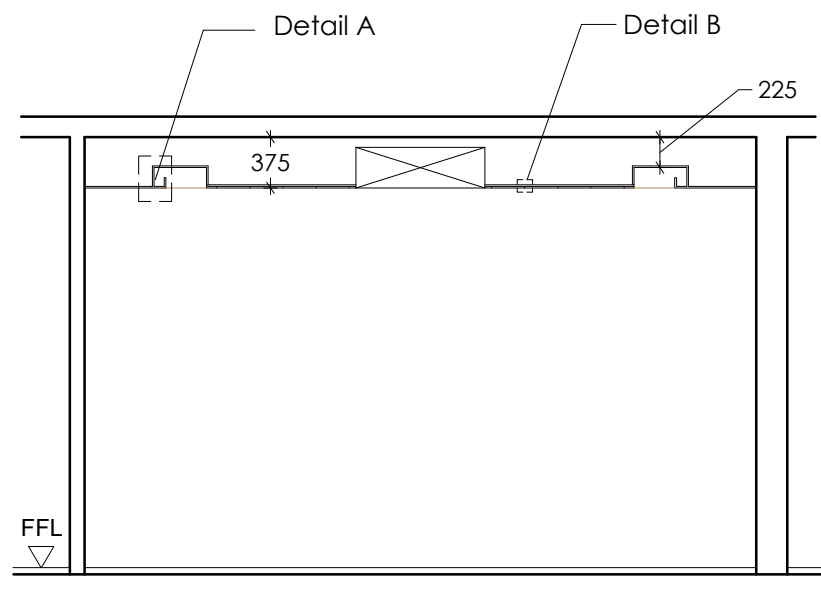



SECTION AA

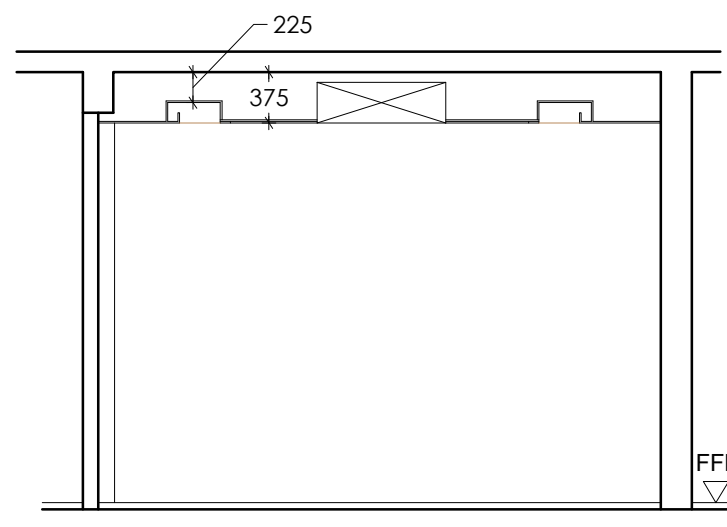

SECTION BB

   Gypsum board false ceiling @ 375 mm from slab bottom

 
 Gypsum board false ceiling @ 375 mm from slab

 Gypsum board false ceiling @ 225 mm from FFL


 7W LED Downlight

 3W Adjustable Spotlight

 LED Profile Light

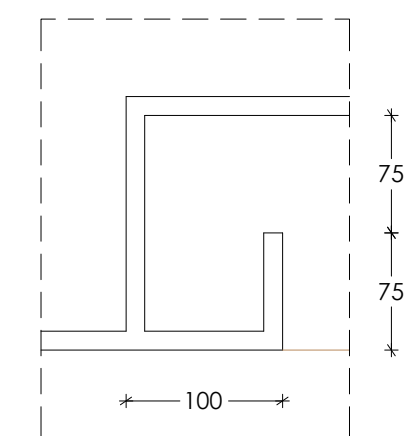

DETAIL A

 
 Gypsum board base
 10 mm groove
 Gypsum board false ceiling

DETAIL B

NOTES:
This drawing is the property of designworks & cannot be used or reproduced any form without their written permission.

Any discrepancy should be brought to the notice of the architects.

Only written dimensions should be followed, the drawing is not to be scaled.

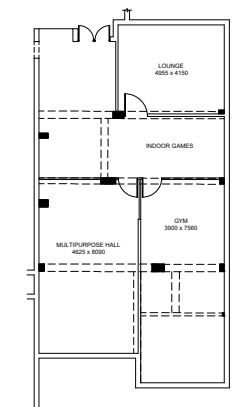

KEY PLAN

For Discussion	☐ Site Copy	☐
For Approval	☐ Clients Copy	☐
Good For Construction	☐ Contractors Copy	☐



Drawn : Durgaa	Scale:	Date: 23.08.'22
Checked : Divya	dwg no:	
Sign :		

drawing:
Clubhouse Lounge - False ceiling & lighting layout

project:
Proposed clubhouse for Uday Vilas @ Gopalapuram, Chennai

DESIGNWORKS
Architects | Interior Designers | Planners


First Floor, 33.Ranjit Road,
Kotturpuram, Chennai - 600 085, India
Tel: +91- 44 - 4230 3731/32/33
Fax: +91- 44 - 42303734
E-mail: mail@designworks.in
Web: www.designworks.in

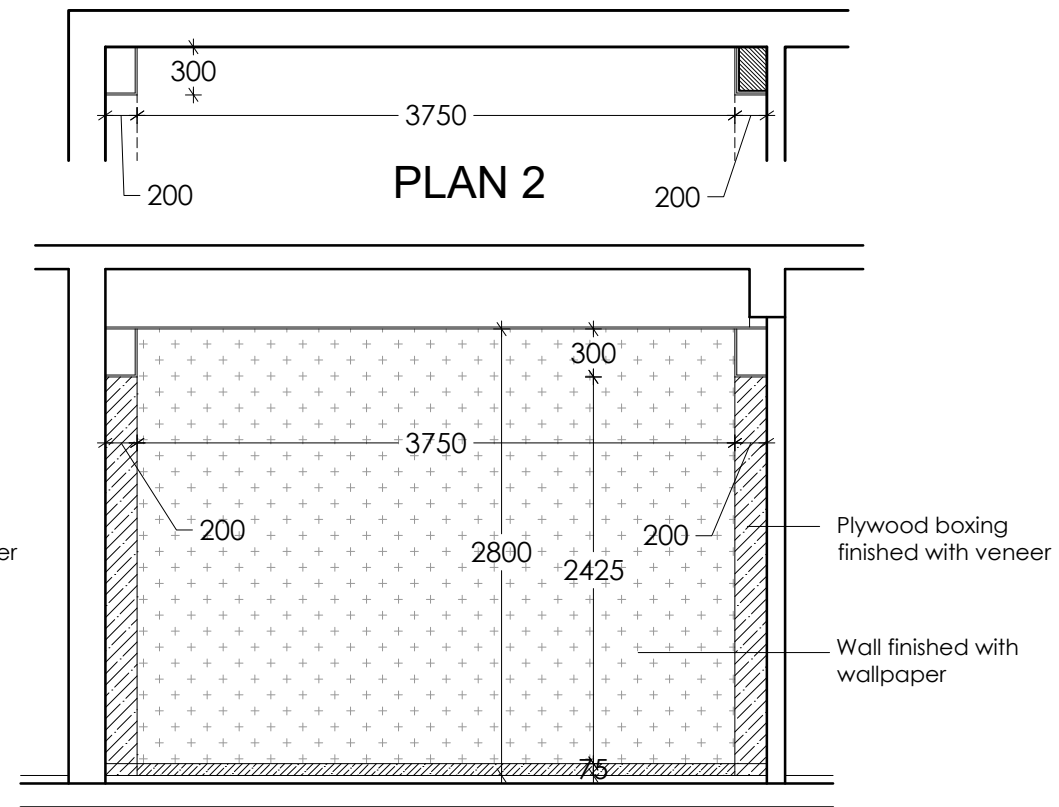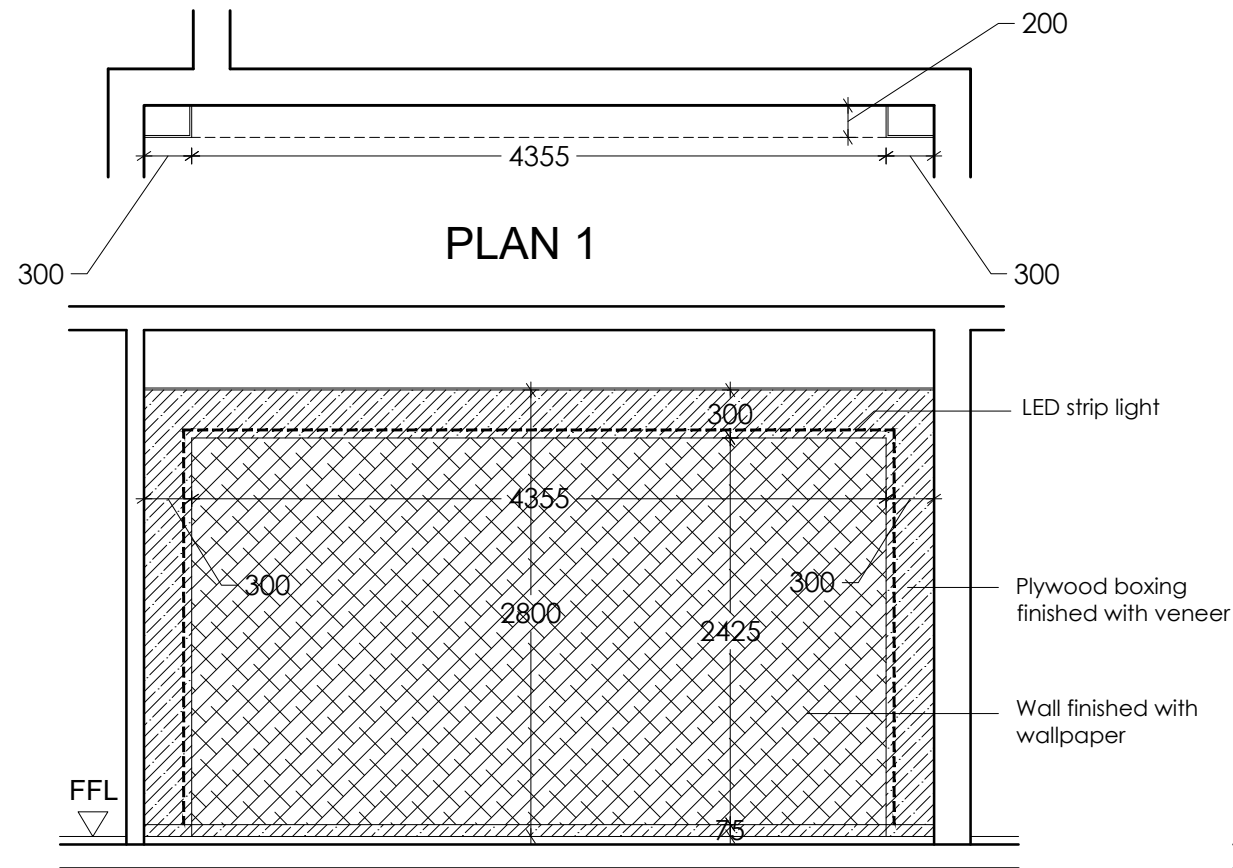

NOTES:
This drawing is the property of designworks & cannot be used or reproduced any form without their written permission.

Any discrepancy should be brought to the notice of the architects.

Only written dimensions should be followed, the drawing is not to be scaled.

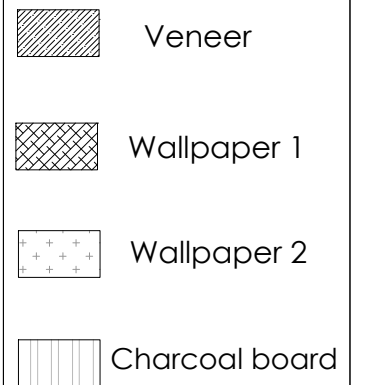



For Discussion	☐	Site Copy	☐
For Approval	☐	Clients Copy	☐
Good For Construction	☐	Contractors Copy	☐

Drawn : Durgaa	Scale :	Date : 26.08'22
Checked : Divya Sign :	dwg no :	

drawing:
Clubhouse Lounge - Wall elevations

project:
Proposed clubhouse for Uday Vilas @ Gopalapuram, Chennai


DESIGNWORKS
Architects | Interior Designers | Planners
First Floor, 33, Ranjit Road, Kotturpuram, Chennai - 600 085, India
Tel: +91- 44 - 4230 3731/32/33
Fax: +91- 44 - 42303734
E-mail: mail@designworks.in
Web: www.designworks.in

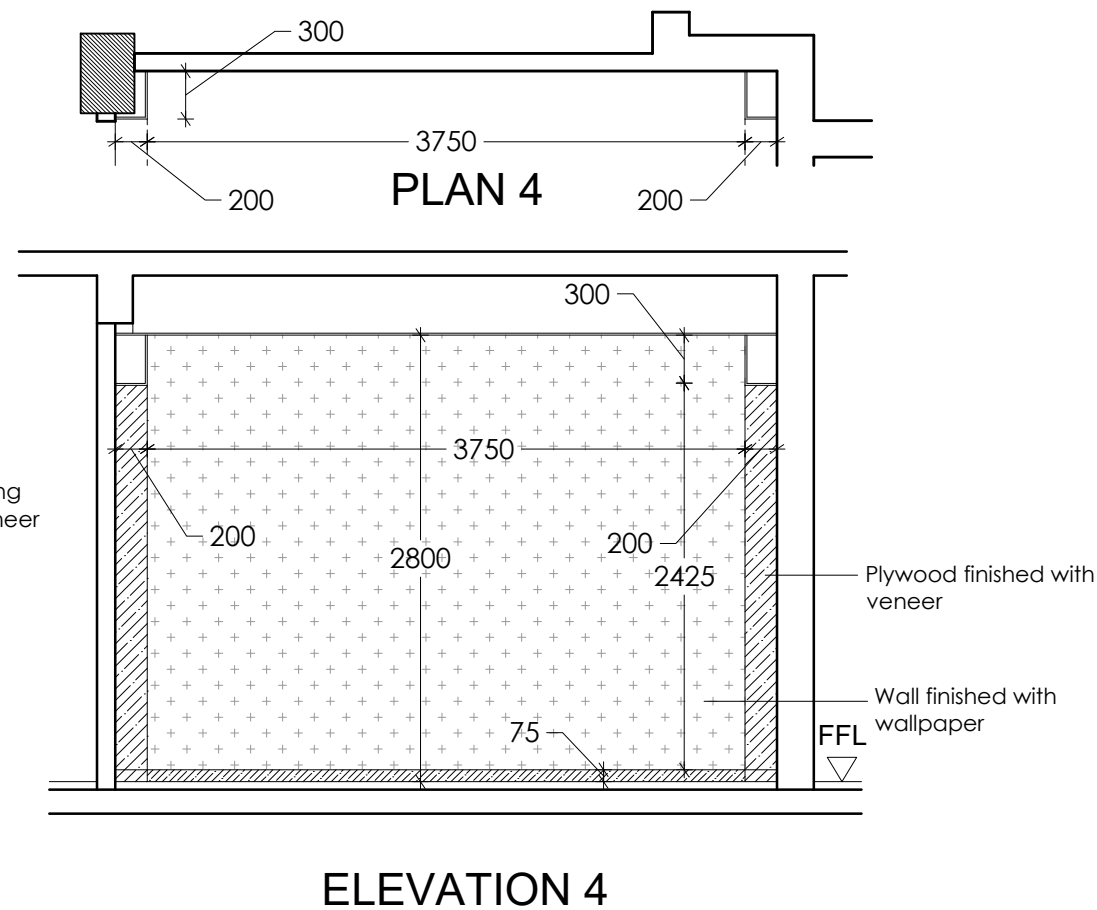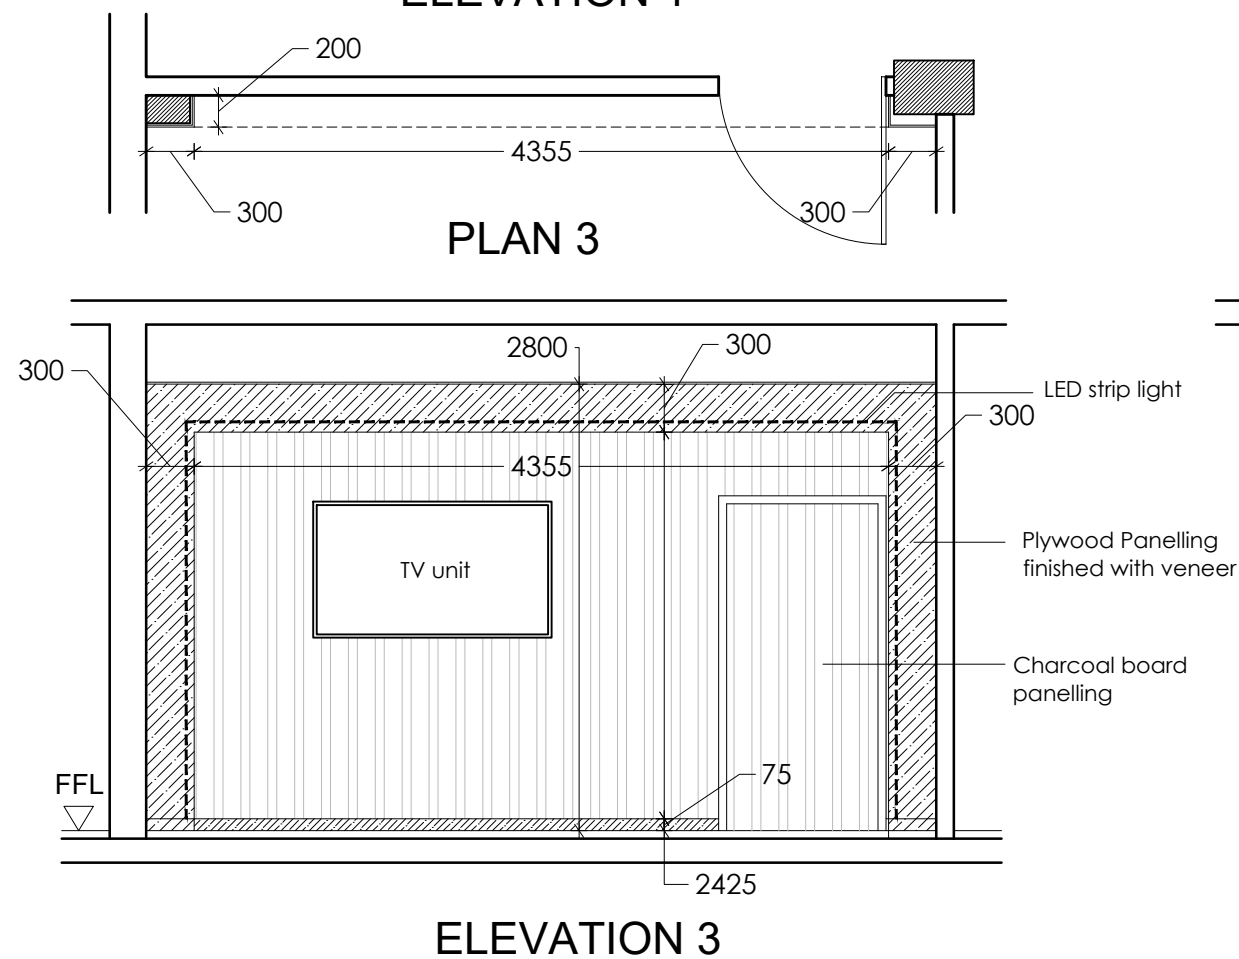

NOTES:
This drawing is the property of
designworks & cannot be used or
reproduced any form without their
written permission.

Any discrepancy should be brought
to the notice of the architects.

Only written dimensions should be
followed, the drawing is not to be
scaled.

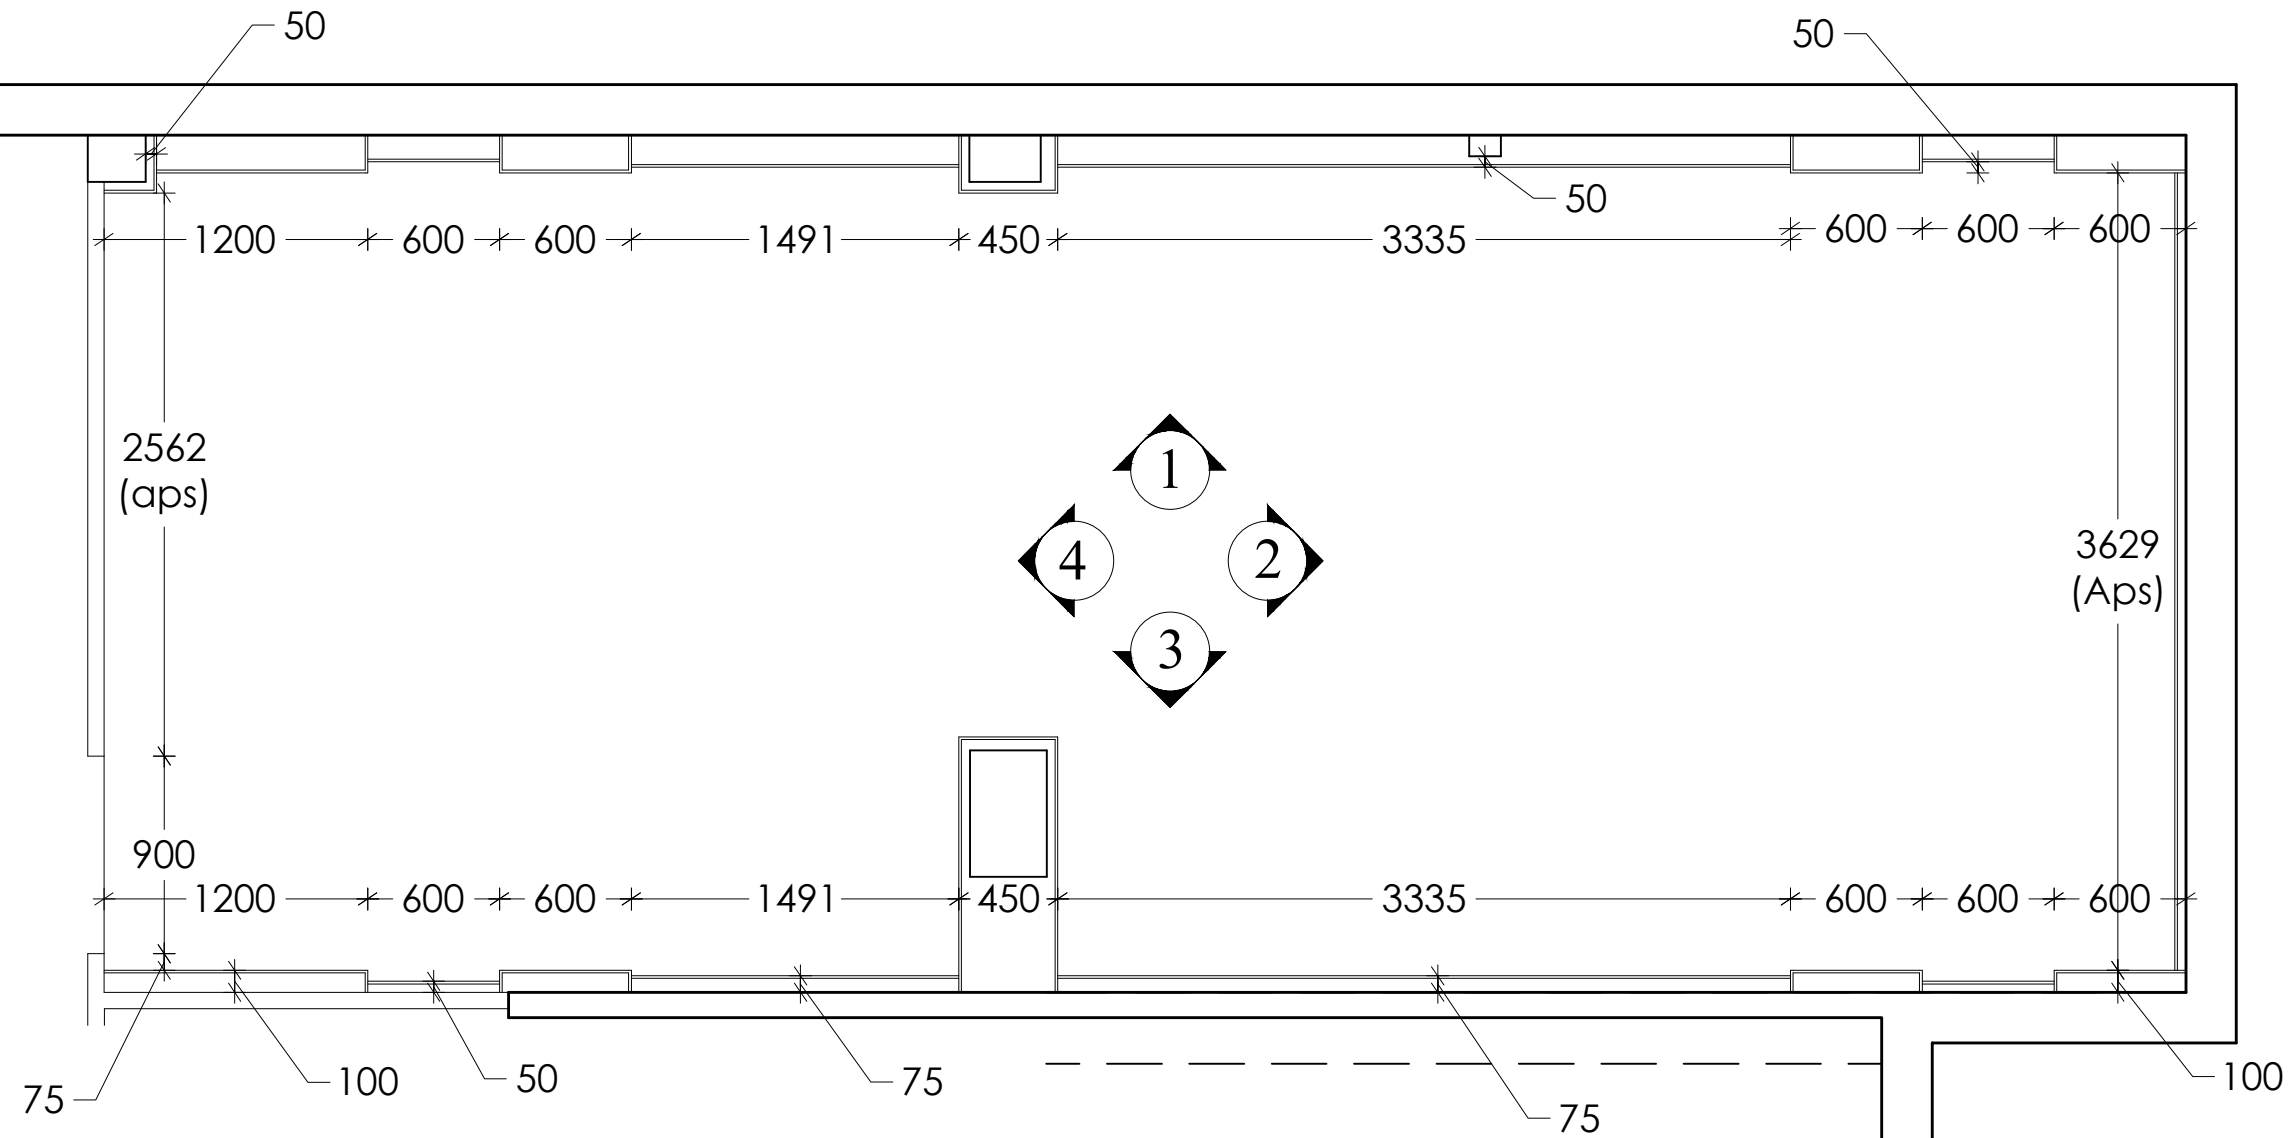

For Discussion	☐	Site Copy	☐
For Approval	☐	Clients Copy	☐
Good For Construction	☐	Contractors Copy	☐


Drawn : Durgaa	Scale :	Date : 05.09.22
Checked : Divya Sign :	dwg no :	

drawing:
Clubhouse Gym - Plan


project:
Proposed clubhouse for Uday Vilas
@ Gopalapuram, Chennai

DESIGNWORKS
Architects | Interior Designers | Planners


First Floor, 33.Ranjit Road,
kotturpuram, Chennai - 600 085, India
Tel: +91- 44 - 4230 3731/32/33
Fax: +91- 44 - 42303734
E-mail: mail@designworks.in
Web: www.designworks.in

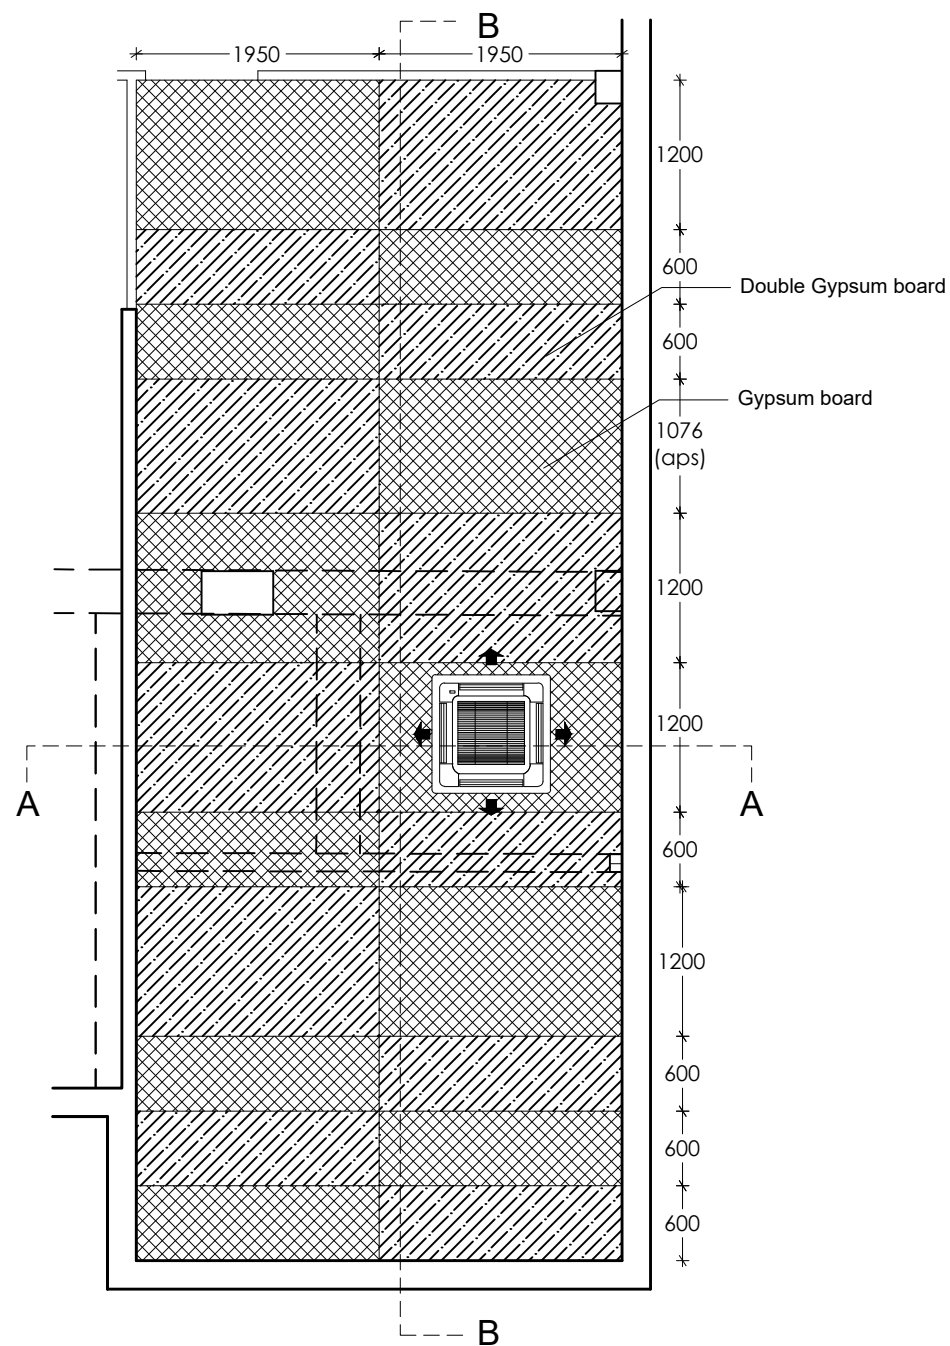


FALSE CEILING LAYOUT

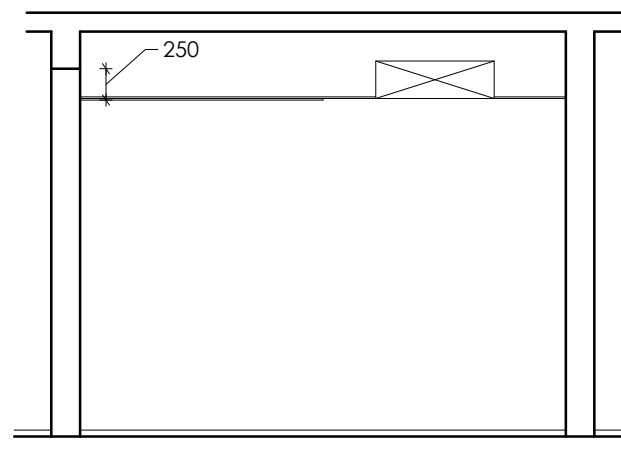

SECTION AA

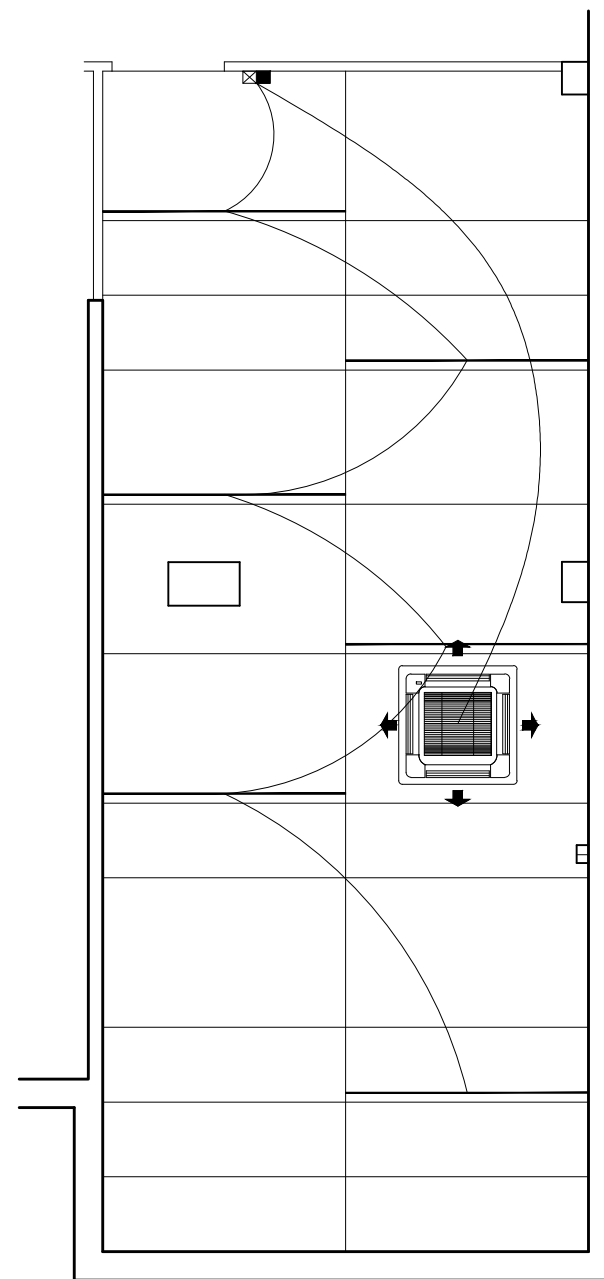

LIGHTING LAYOUT

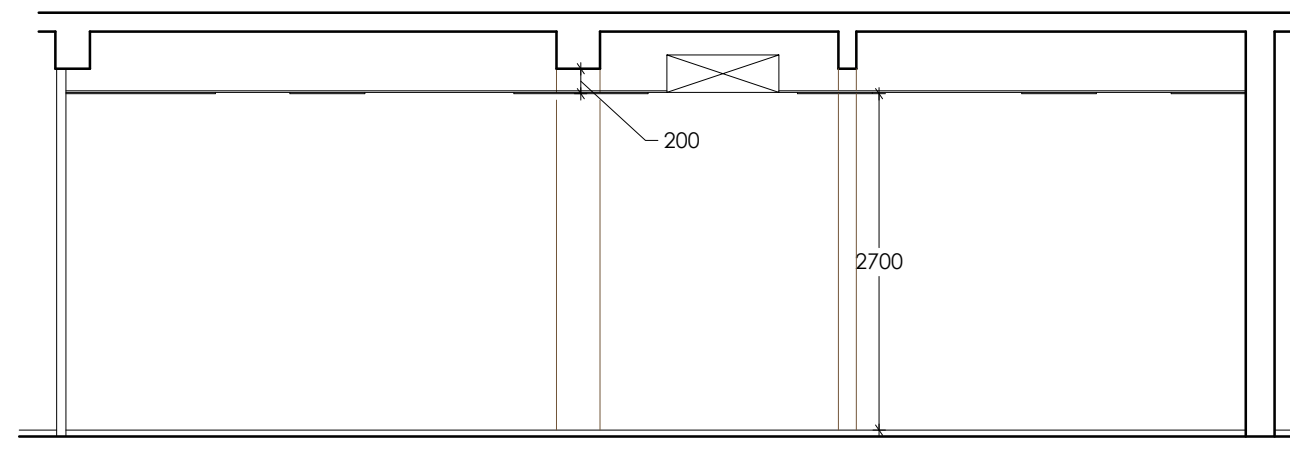

SECTION BB

Gypsum board false ceiling @ 250 mm from beam bottom


Gypsum board base

LED profile light

NOTES:
This drawing is the property of designworks & cannot be used or reproduced any form without their written permission.

Any discrepancy should be brought to the notice of the architects.

Only written dimensions should be followed, the drawing is not to be scaled.

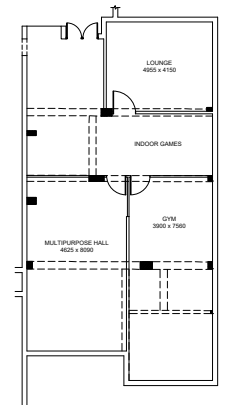

KEY PLAN

For Discussion	☐	Site Copy	☐
For Approval	☐	Clients Copy	☐
Good For Construction	☐	Contractors Copy	☐


Drawn : Durgaa	Scale :	Date : 25.08.'22
Checked : Divya Sign :	dwg no :	

drawing :
Clubhouse Gym - False ceiling & lighting layout


project :
Proposed clubhouse for Uday Vilas @ Gopalapuram, Chennai

DESIGNWORKS
Architects | Interior Designers | Planners


First Floor, 33,Ranjit Road,
Kotturpuram, Chennai - 600 085, India
Tel: +91- 44 - 4230 3731/32/33
Fax: +91- 44 - 42303734
E-mail: mail@designworks.in
Web: www.designworks.in

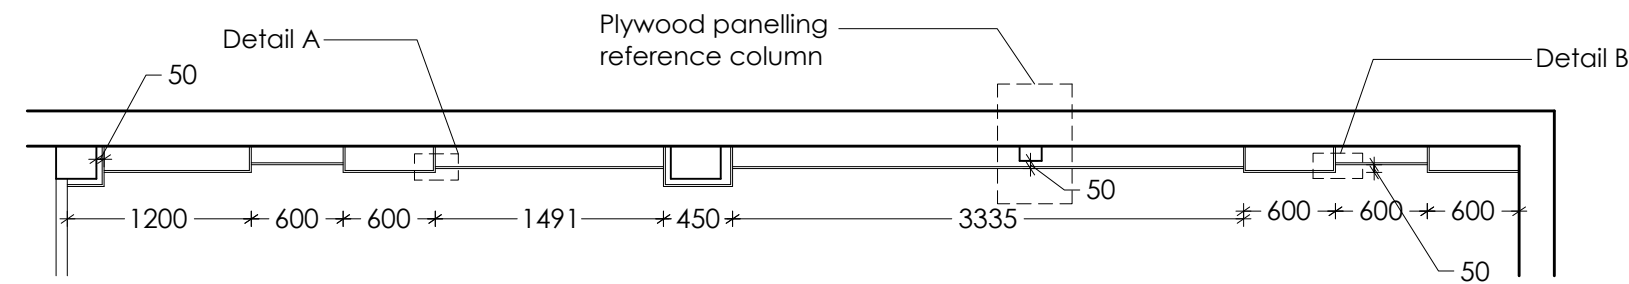


PLAN 1

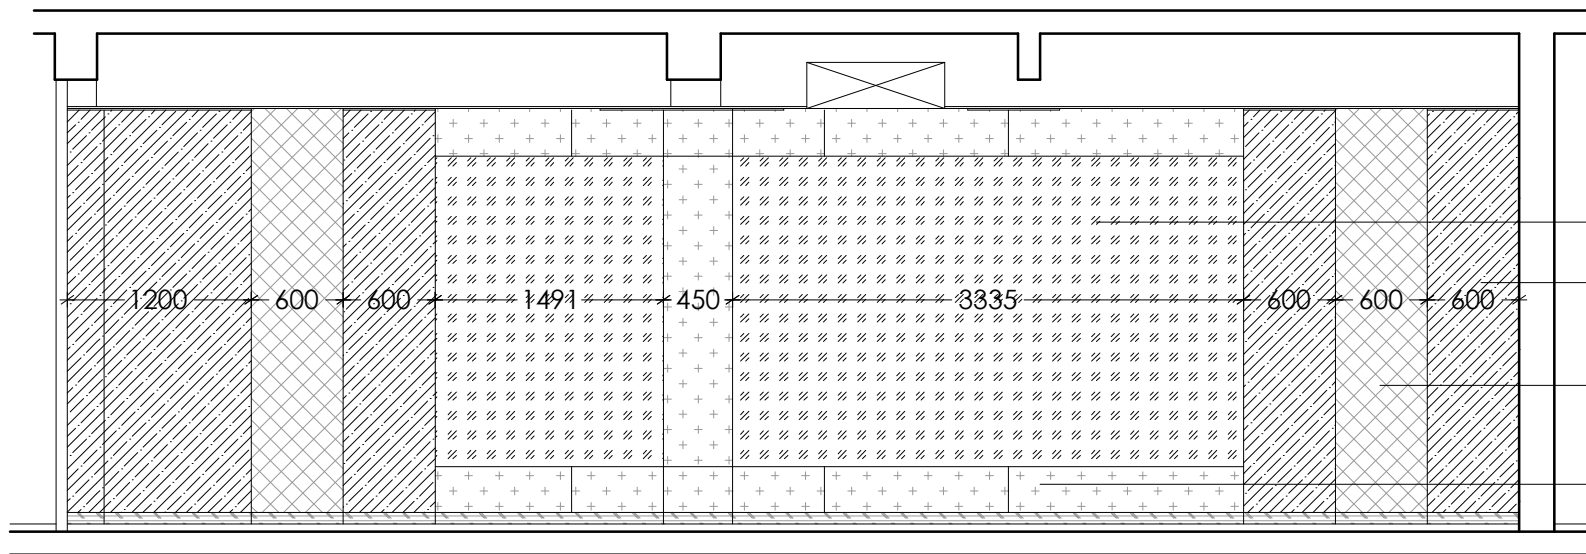


ELEVATION 1

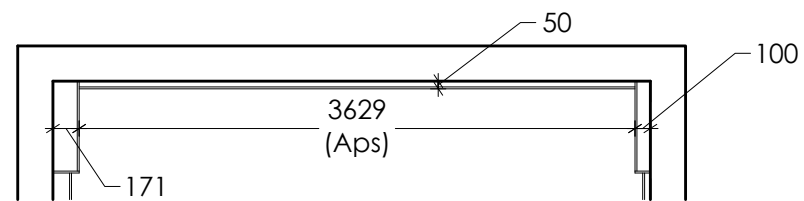


PLAN 2

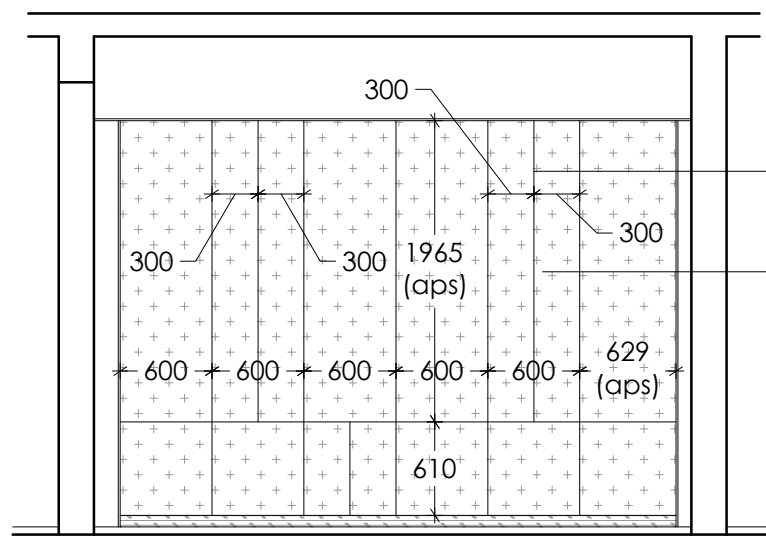


ELEVATION 2

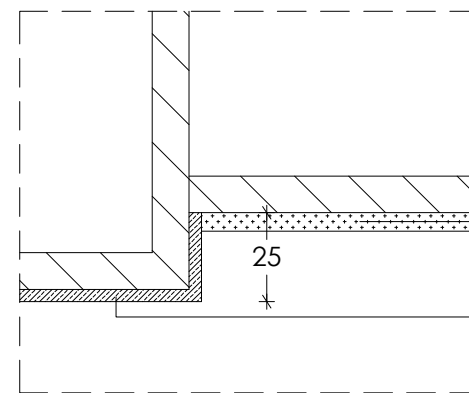


DETAIL A

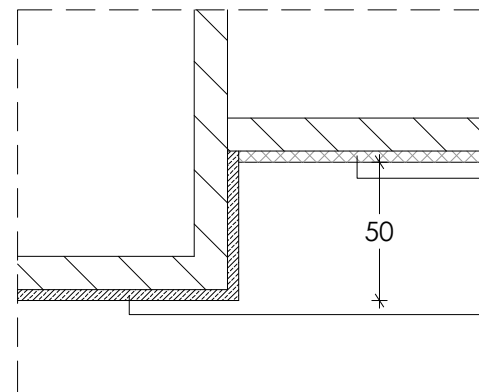


DETAIL B

 

Laminate 1

 

Laminate 2

 

Wall graphics



wooden skirting



Mirror

Mirror

Plywood Panelling
finished with Laminate 1

Graphics design

Plywood Panelling
finished with Laminate 2

6mm mirror pasted
over plywood

Plywood Panelling
finished with
Laminate 1

Plywood Panelling
finished with
graphics

Plywood Panelling
finished with
Laminate 1

NOTES:
This drawing is the property of
designworks & cannot be used or
reproduced any form without their
written permission.

Any discrepancy should be brought
to the notice of the architects.

Only written dimensions should be
followed, the drawing is not to be
scaled.


For Discussion	☐	Site Copy	☐
For Approval	☐	Clients Copy	☐
Good For Construction	☐	Contractors Copy	☐

Drawn : Durgaa	Scale :	Date : 16.09'22
Checked : Divya Sign :	dwg no :	


drawing:
Clubhouse Gym - Wall elevations

project:
Proposed Layout for Uday Vilas @
Gopalapuram, Chennai


DESIGNWORKS
Architects | Interior Designers | Planners
First Floor, 33,Ranjit Road,
Kotturpuram, Chennai - 600 085, India
Tel: +91- 44 - 4230 3731/32/33
Fax: +91- 44 - 42303734
E-mail: mail@designworks.in
Web: www.designworks.in

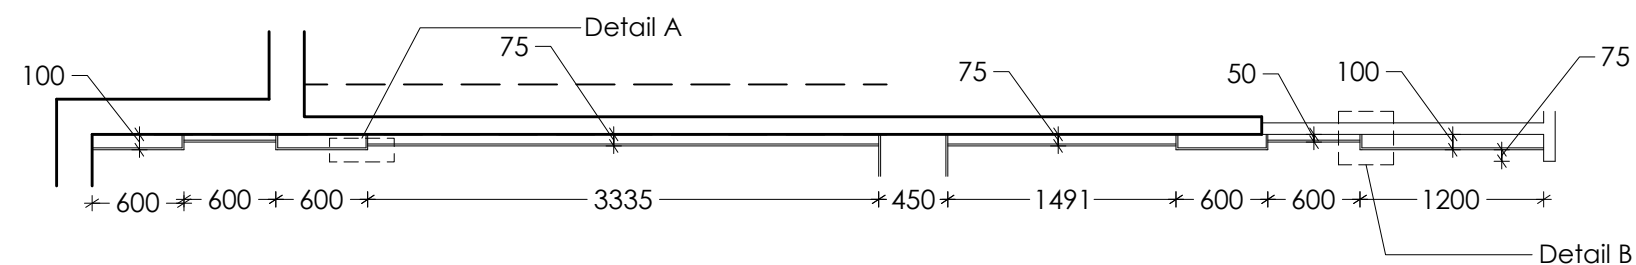


PLAN 3

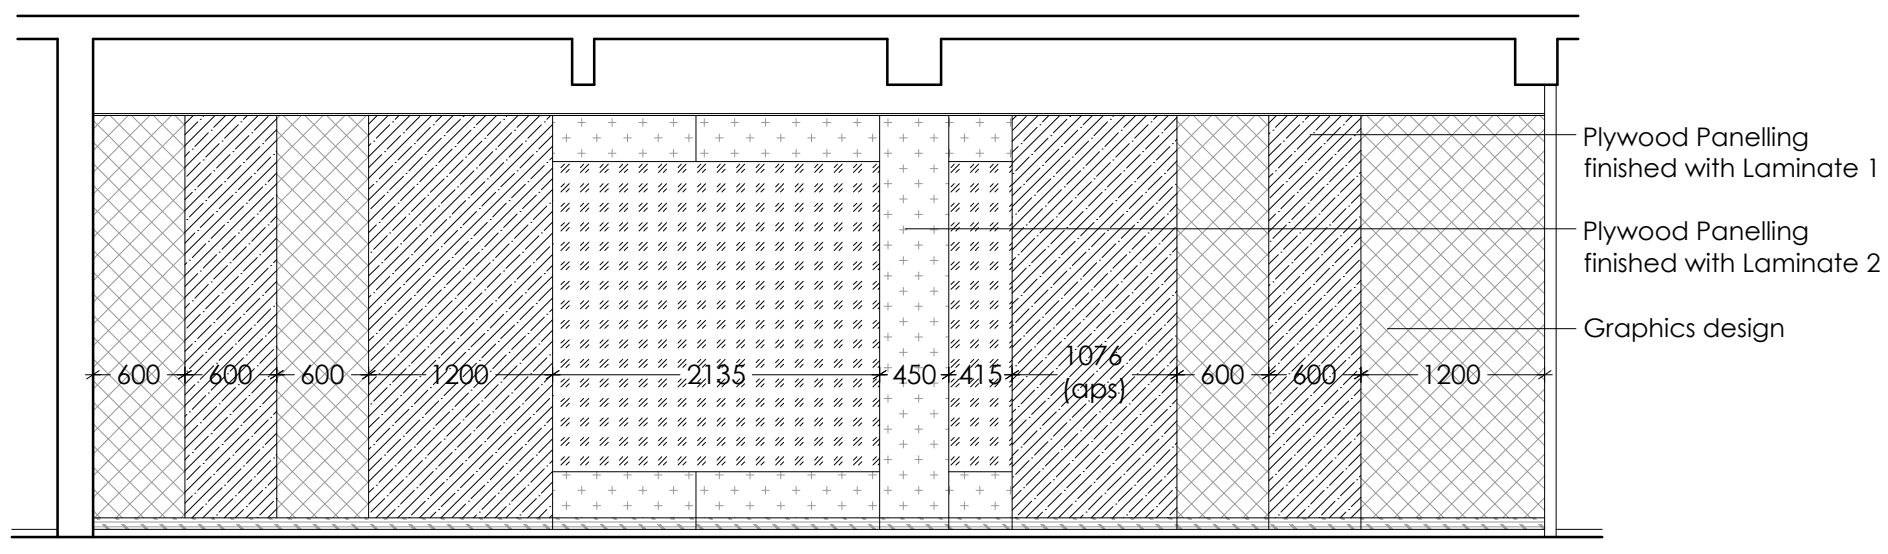


ELEVATION 3

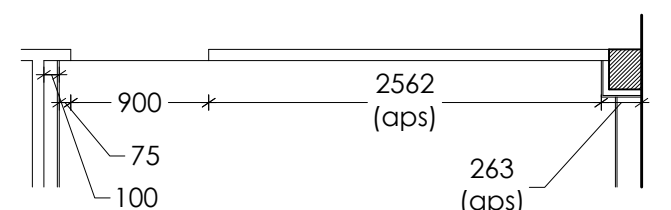


PLAN 4

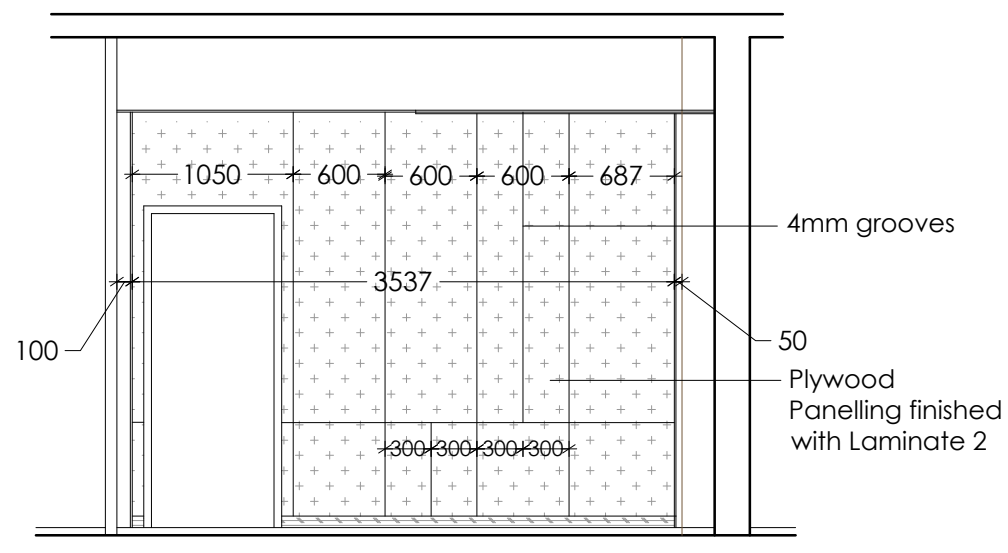


ELEVATION 4

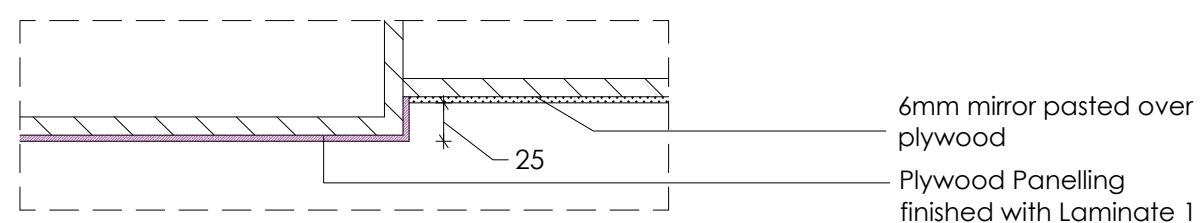


DETAIL A

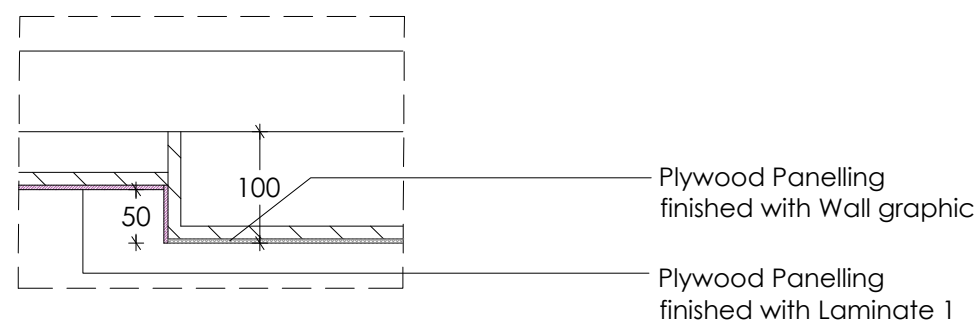


DETAIL B

  Laminate 1

  Laminate 2

 Wall graphics

  wooden skirting

 Mirror

NOTES:
This drawing is the property of designworks & cannot be used or reproduced any form without their written permission.

Any discrepancy should be brought to the notice of the architects.

Only written dimensions should be followed, the drawing is not to be scaled.


For Discussion	☐	Site Copy	☐
For Approval	☐	Clients Copy	☐
Good For Construction	☐	Contractors Copy	☐

Drawn : Durgaa	Scale :	Date : 16.09'22
Checked : Divya Sign :	dwg no:	

drawing:
Clubhouse Gym - Wall elevation

project:
Proposed Layout for Uday Vilas @ Gopalapuram, Chennai

DESIGNWORKS
Architects | Interior Designers | Planners
First Floor, 33, Ranjit Road,
Kotturpuram, Chennai - 600 085, India
Tel: +91- 44 - 4230 3731/32/33
Fax: +91- 44 - 42303734
E-mail: mail@designworks.in
Web: www.designworks.in

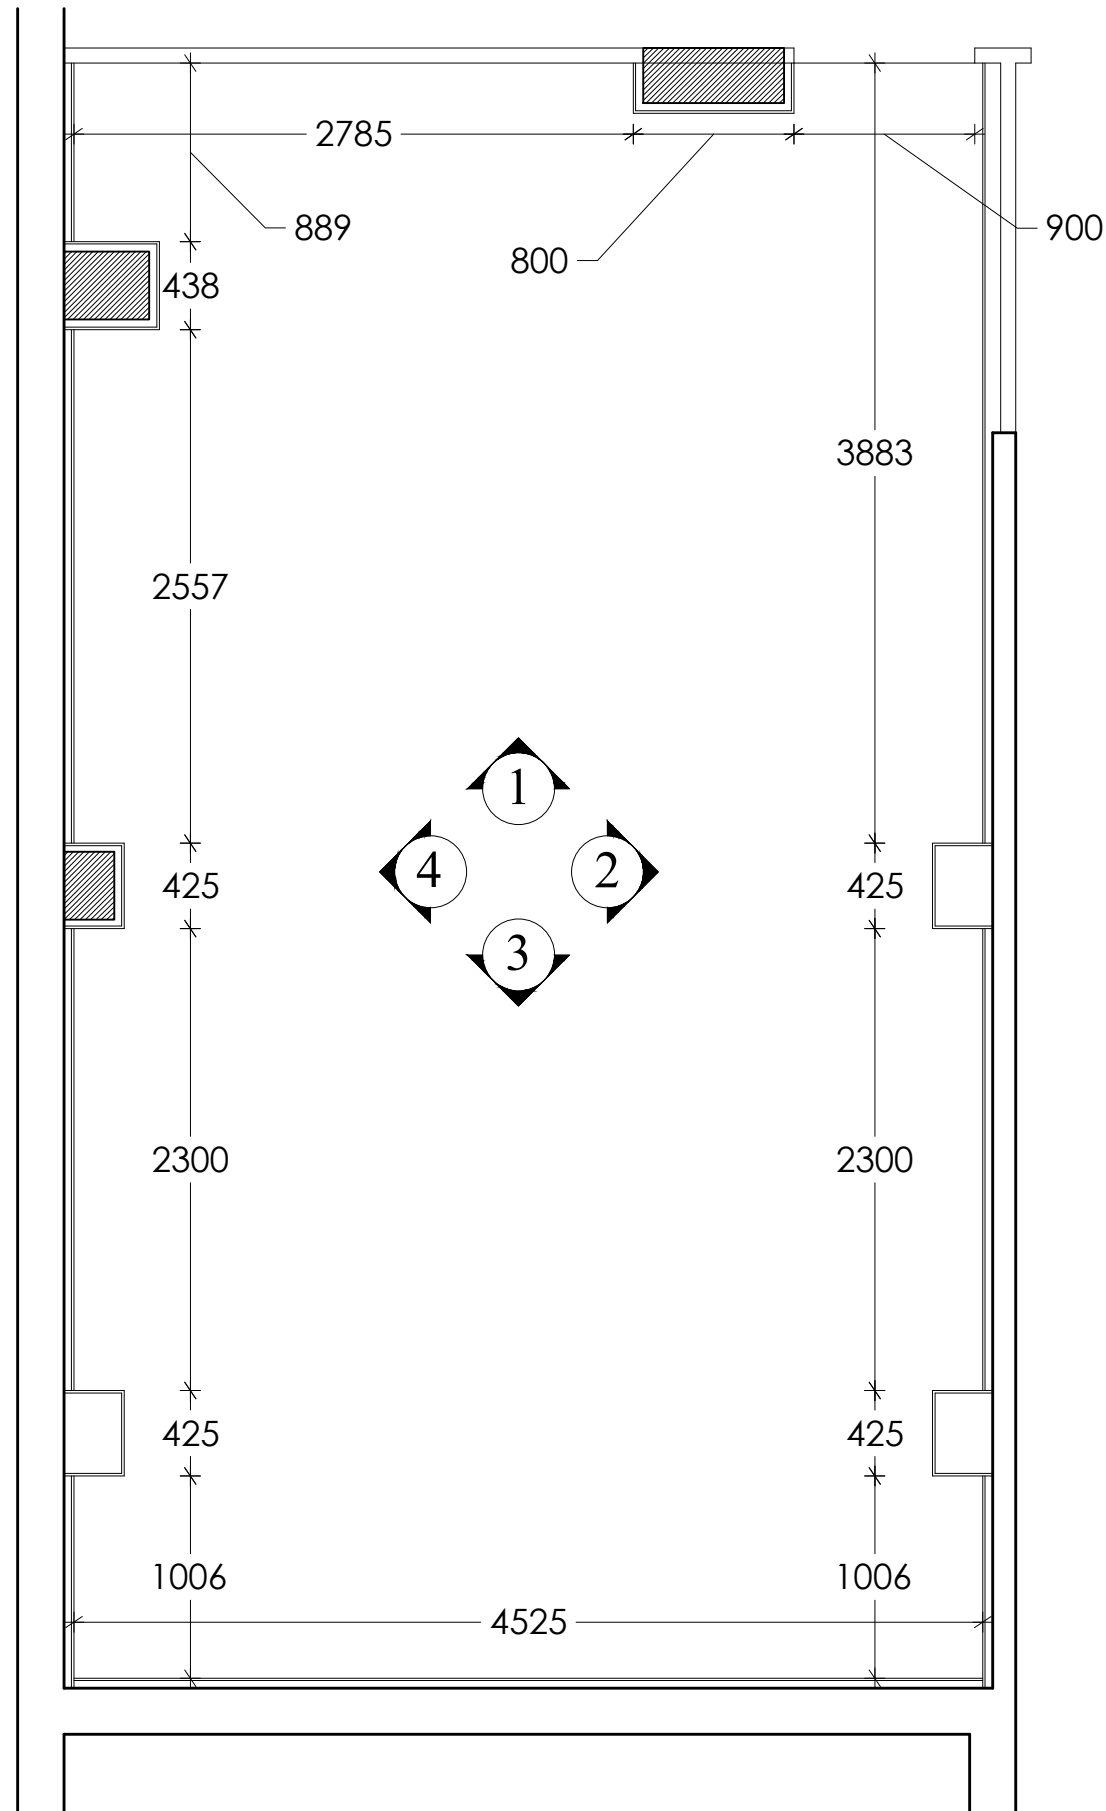

NOTES:
This drawing is the property of designworks & cannot be used or reproduced any form without their written permission.

Any discrepancy should be brought to the notice of the architects.

Only written dimensions should be followed, the drawing is not to be scaled.

For Discussion	☐	Site Copy	☐
For Approval	☐	Clients Copy	☐
Good For Construction	☐	Contractors Copy	☐


Drawn : Durgaa	Scale :	Date : 30.09.22
Checked : Divya Sign :	dwg no:	

drawing:
Clubhouse Multipurpose hall - Plan


project:
Proposed clubhouse for Uday Vilas
@ Gopalapuram, Chennai

DESIGNWORKS
Architects | Interior Designers | Planners


First Floor, 33, Ranjit Road,
kotturpuram, Chennai - 600 085, India
Tel: +91- 44 - 4230 3731/32/33
Fax: +91- 44 - 42303734
E-mail: mail@designworks.in
Web: www.designworks.in

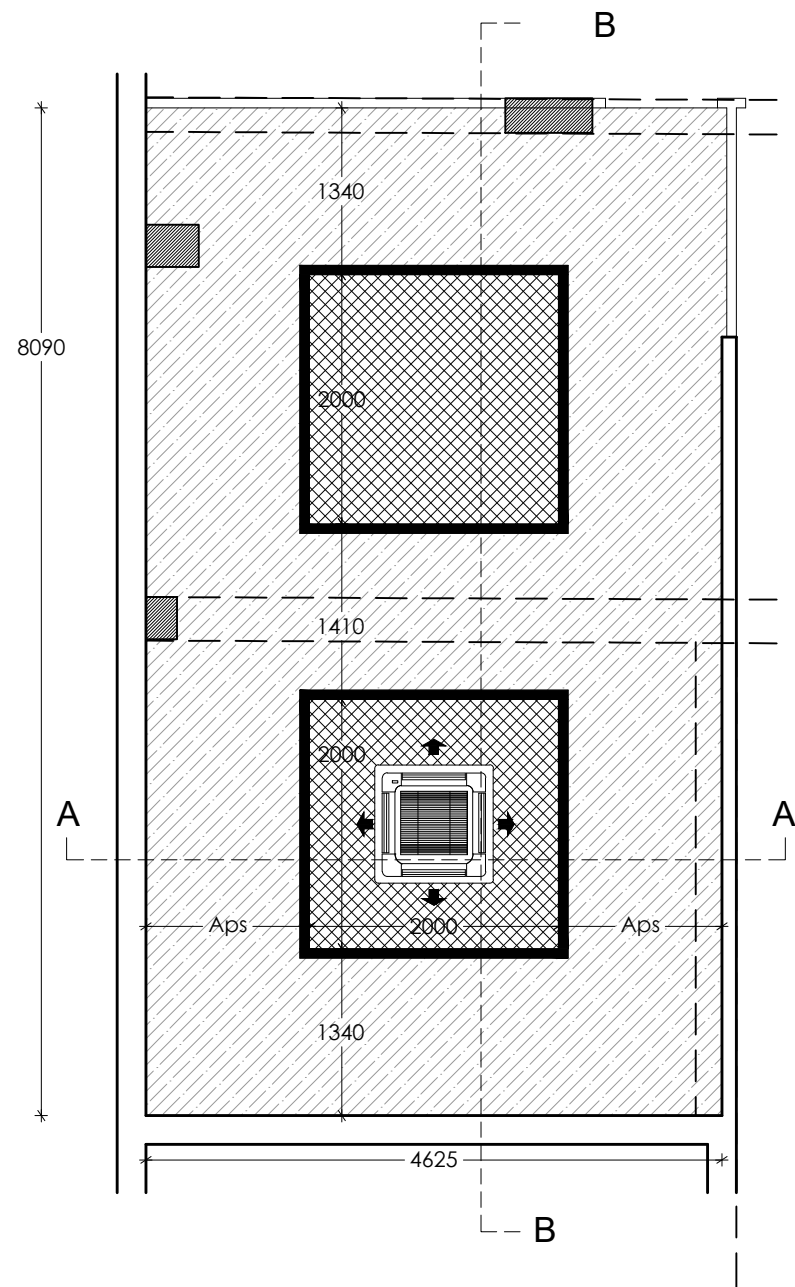


FALSE CEILING LAYOUT

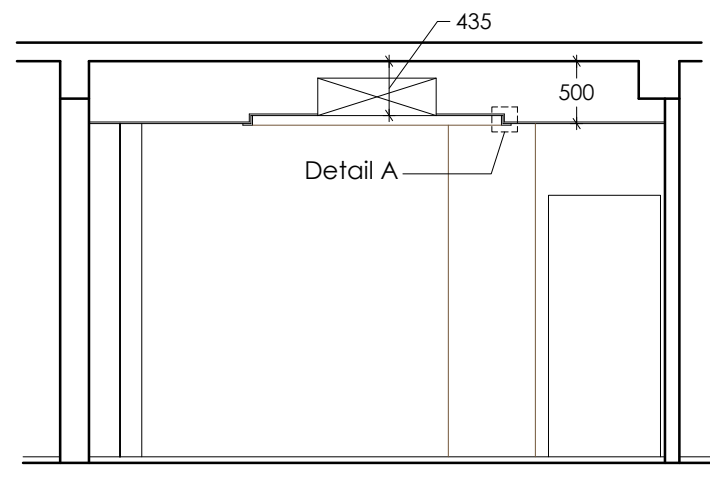

SECTION AA

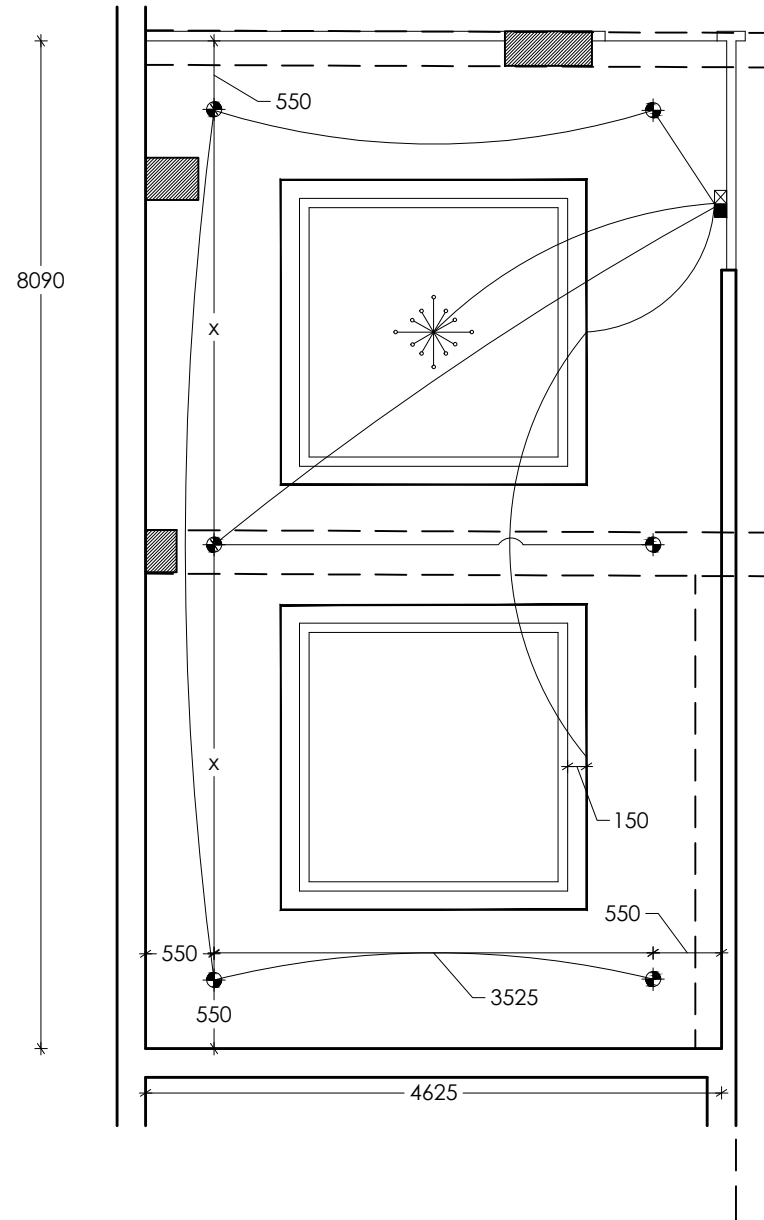


LIGHTING LAYOUT

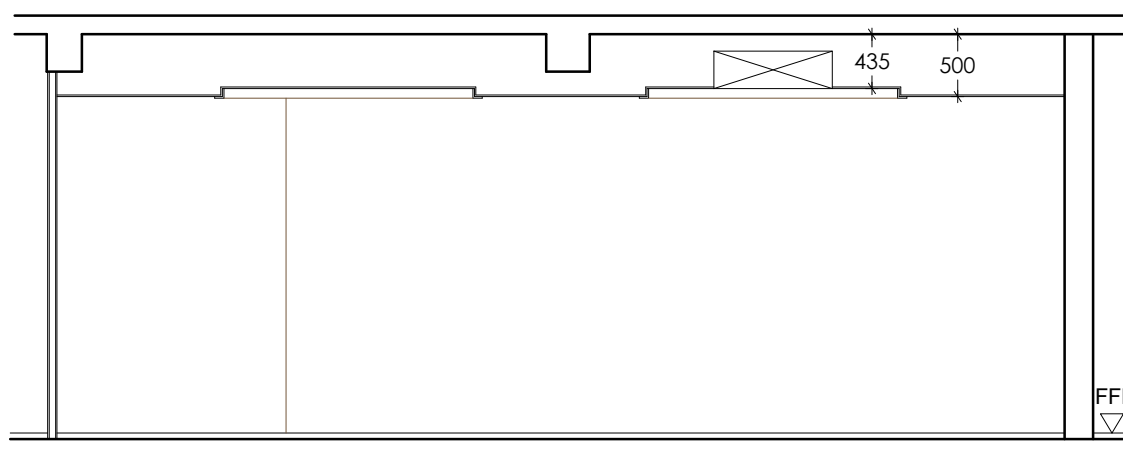

SECTION BB



 Gypsum board false ceiling @
435 mm from slab bottom



Gypsum board false ceiling @
500 mm from Slab bottom



7W LED Downlight




Chandelier



profile light



Switch Box, 1 Raw Power(6/16A)
@ 1200mm ht. from F.F.L

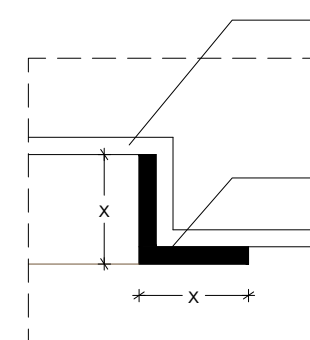


Gypsum board False
ceiling

Wooden beading

NOTES:
This drawing is the property of
designworks & cannot be used or
reproduced any form without their
written permission.

Any discrepancy should be brought
to the notice of the architects.

Only written dimensions should be
followed, the drawing is not to be
scaled.

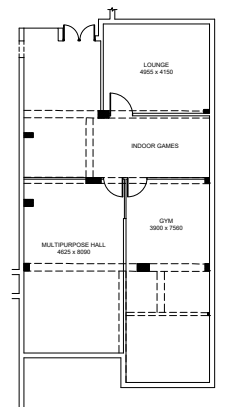

KEY PLAN

For Discussion	☐	Site Copy	☐
For Approval	☐	Clients Copy	☐
Good For Construction	☐	Contractors Copy	☐


Drawn : Durgaa	Scale :	Date : 24.08.'22
Checked : Divya	dwg no:	
Sign :		

drawing:
Clubhouse Multipurpose Hall -
False ceiling & lighting layout


project:
Proposed clubhouse for Uday Vilas
@ Gopalapuram, Chennai

DESIGNWORKS
Architects | Interior Designers | Planners


First Floor, 33,Ranjit Road,
Kotturpuram, Chennai - 600 085, India
Tel: +91- 44 - 4230 3731/32/33
Fax: +91- 44 - 42303734
E-mail: mail@designworks.in
Web: www.designworks.in

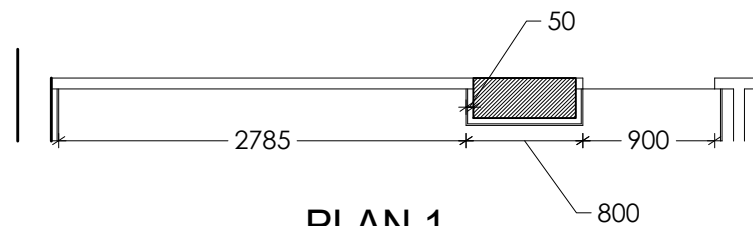


PLAN 1

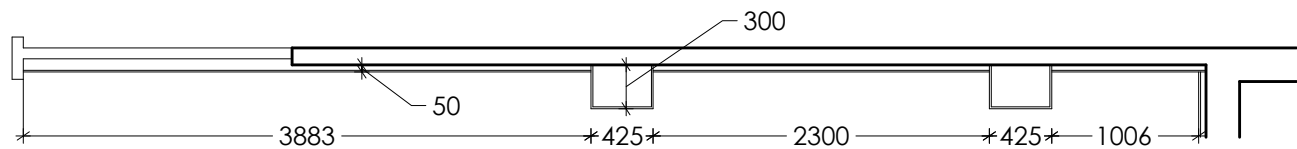


PLAN 2

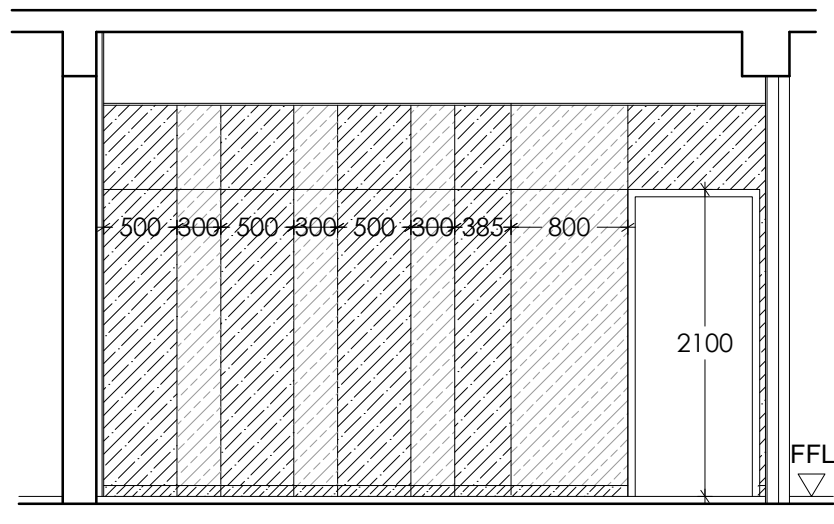


ELEVATION 1

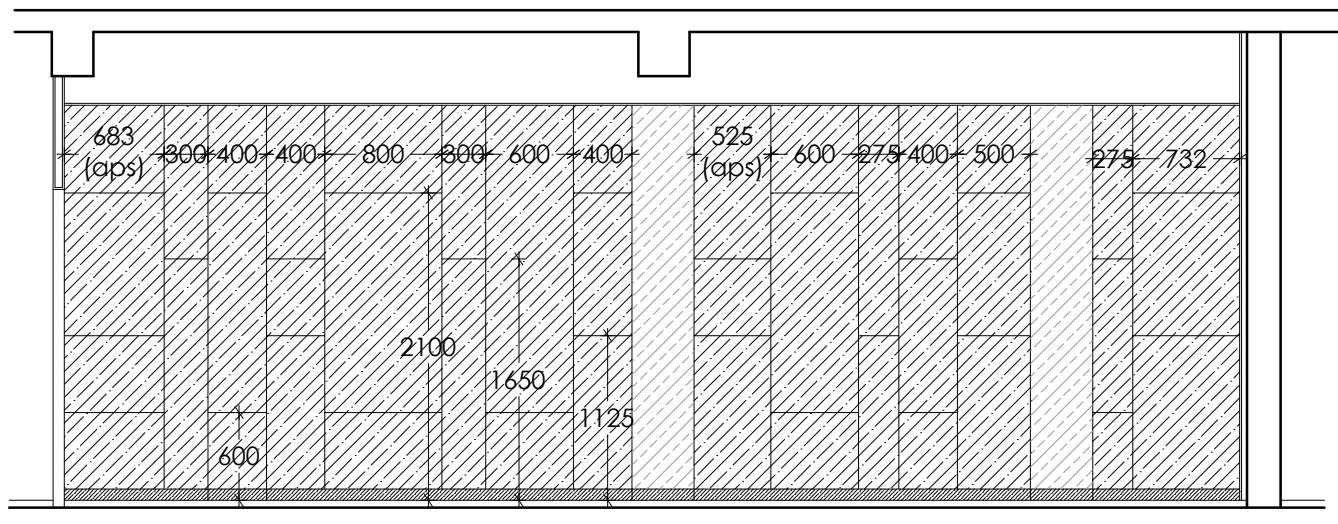


ELEVATION 2

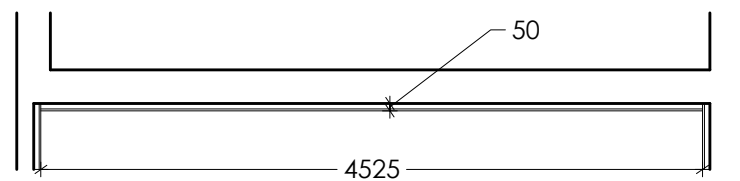


PLAN 3

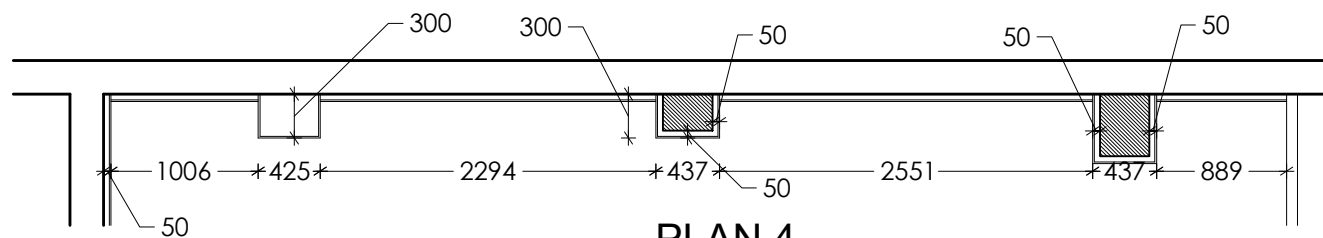

PLAN 4

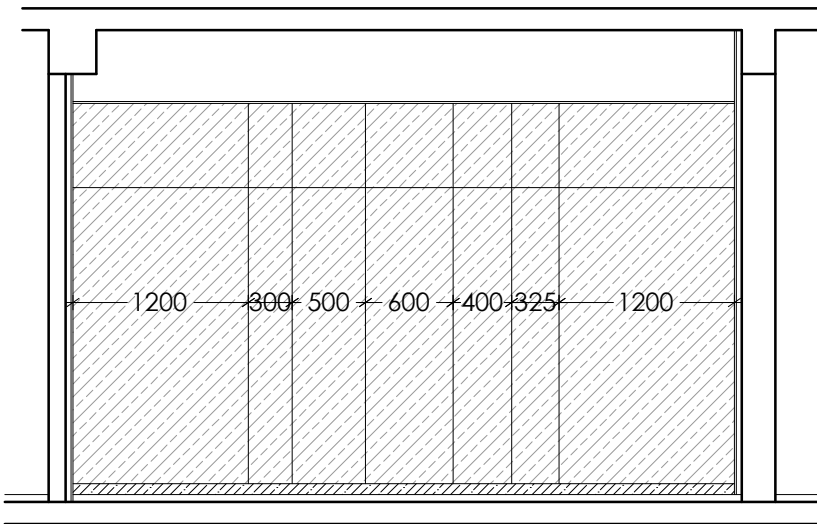

ELEVATION 3

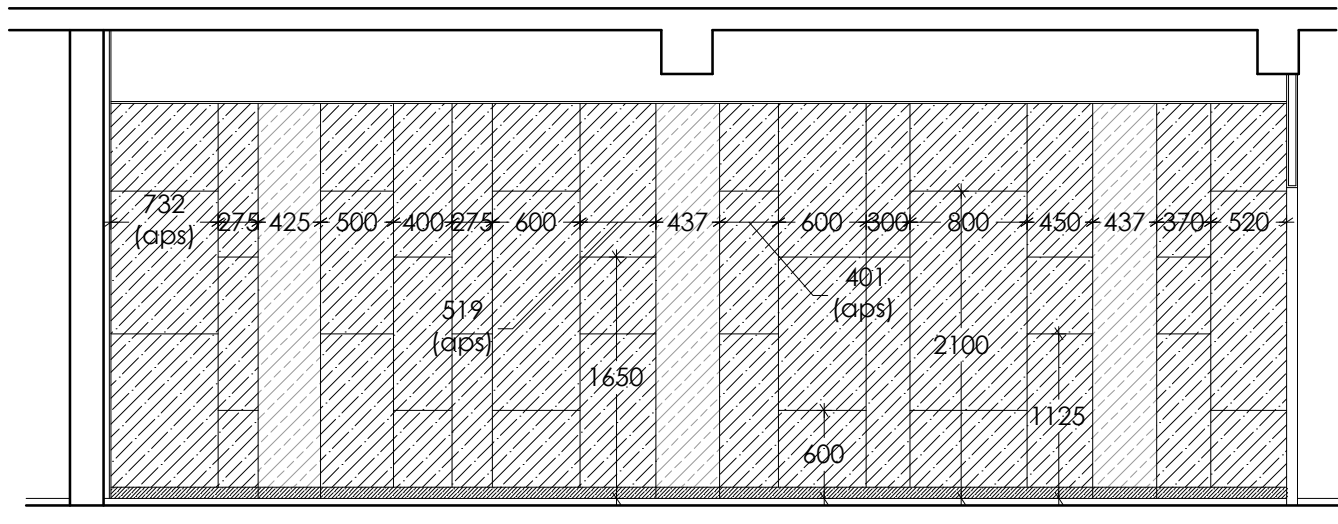

ELEVATION 4

NOTES:
This drawing is the property of designworks & cannot be used or reproduced any form without their written permission.
Any discrepancy should be brought to the notice of the architects.
Only written dimensions should be followed, the drawing is not to be scaled.


For Discussion	☐	Site Copy	☐
For Approval	☐	Clients Copy	☐
Good For Construction	☐	Contractors Copy	☐

Drawn : Durgaa	Scale:	Date : 01.09.'22
Checked : Divya	dwg no :	
Sign :		

drawing:
Clubhouse Multipurpose hall - Wall elevations

project:
Proposed clubhouse for Uday Vilas @ Gopalapuram, Chennai


DESIGNWORKS
Architects | Interior Designers | Planners
First Floor, 33,Ranjit Road, kotturpuram, Chennai - 600 085, India
Tel: +91- 44 - 4230 3731/32/33
Fax: +91- 44 - 42303734
E-mail: mail@designworks.in
Web: www.designworks.in

 


Laminate 1



 
Laminate 2




Glass

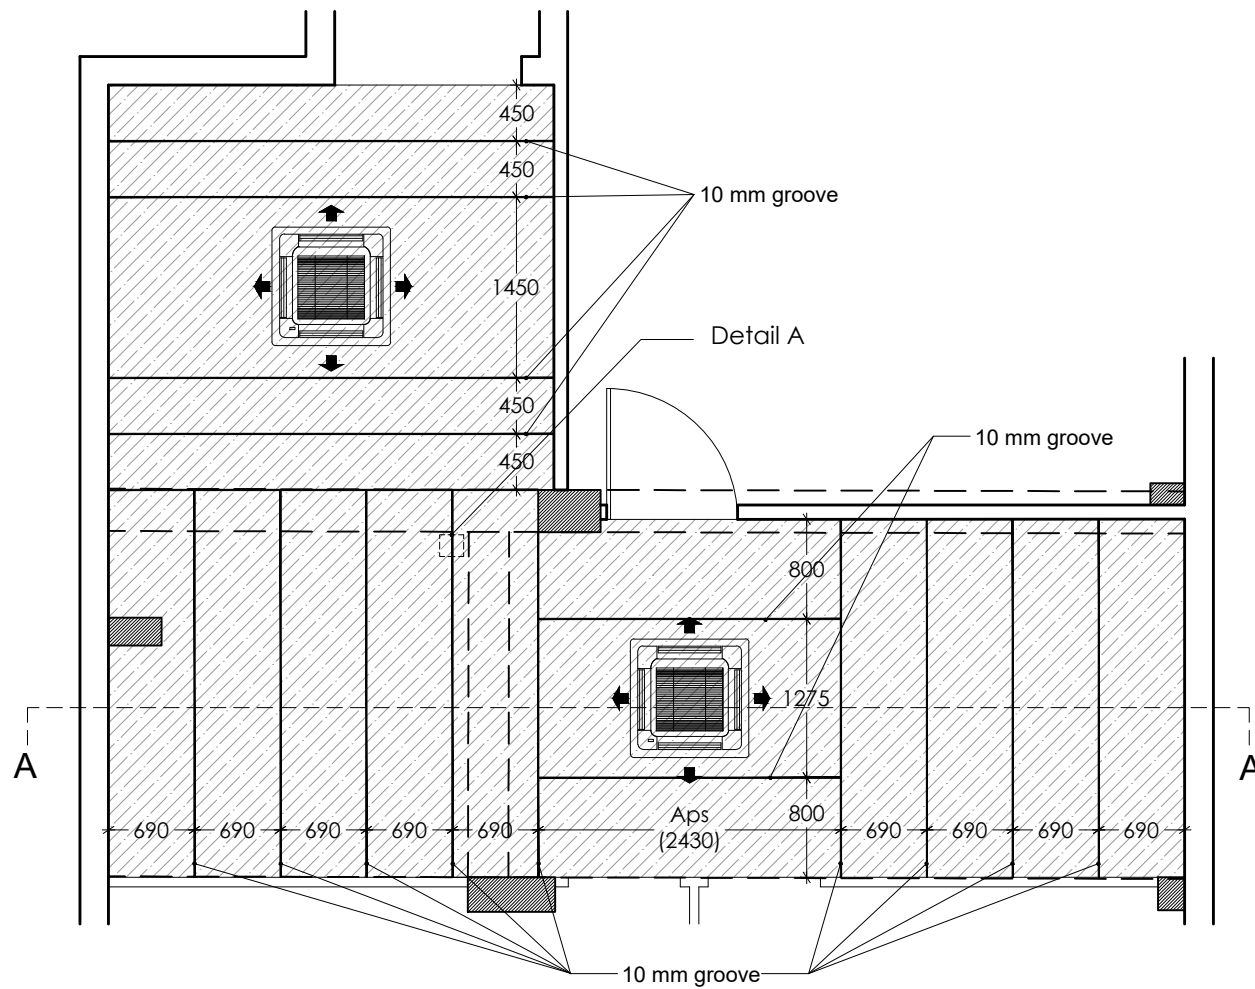


FALSE CEILING LAYOUT

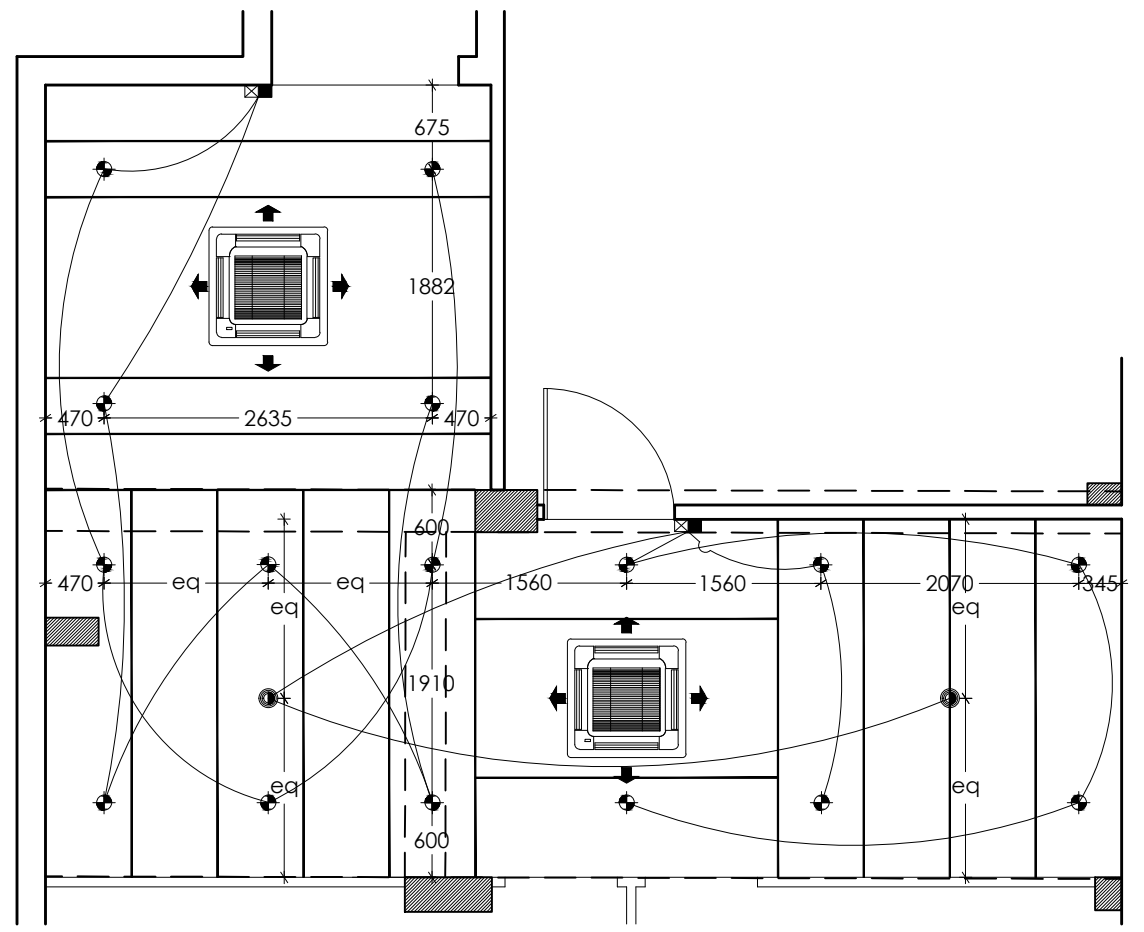

LIGHTING LAYOUT

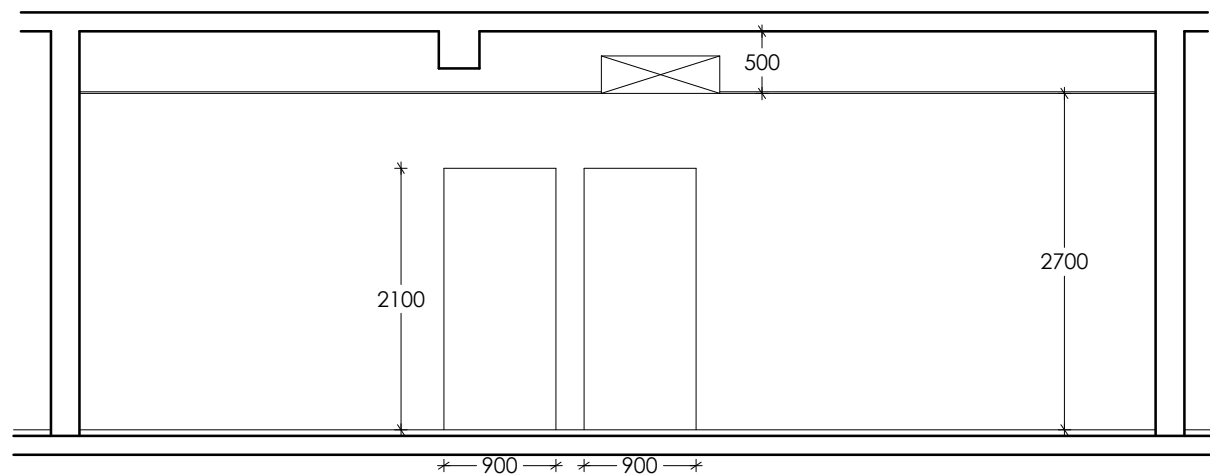

SECTION AA

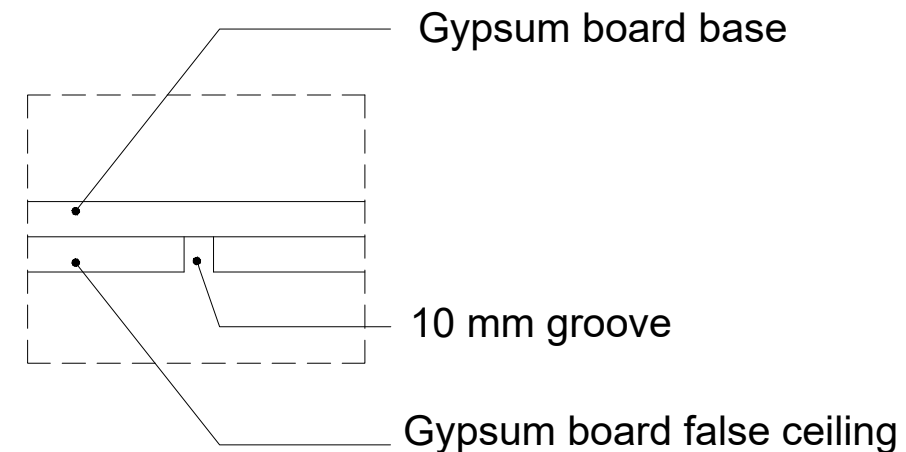


DETAIL A

NOTES:
This drawing is the property of designworks & cannot be used or reproduced any form without their written permission.

Any discrepancy should be brought to the notice of the architects.

Only written dimensions should be followed, the drawing is not to be scaled.

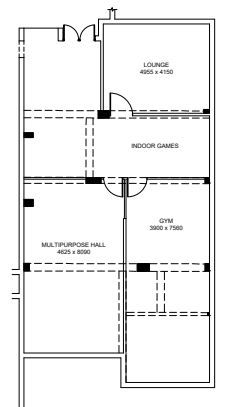

KEY PLAN

Gypsum board false ceiling @ 500 mm from slab bottom

7W LED Downlight

Suspended light

For Discussion	☐	Site Copy	☐
For Approval	☐	Clients Copy	☐
Good For Construction	☐	Contractors Copy	☐

Drawn : Durgaa	Scale :	Date : 25.08.'22
Checked : Divya Sign :	dwg no:	


drawing:
Clubhouse indoor game - False ceiling & lighting layout

project:
Proposed clubhouse for Uday Vilas @ Gopalapuram, Chennai

DESIGNWORKS
Architects | Interior Designers | Planners

First Floor, 33.Ranjit Road, kotturpuram, Chennai - 600 085, India
Tel: +91- 44 - 4230 3731/32/33
Fax: +91- 44 - 42303734
E-mail: mail@designworks.in
Web: www.designworks.in

TITLE OF THE PROJECT	:	SHIVAKUMAR RESIDENCE
PROJECT TYPOLOGY	:	RESIDENCE
CLIENT	:	Mr. SHIVAKUMAR
LOCATION	:	UTHANDI, ECR, CHENNAI
PROJECT STATUS	:	ON-GOING

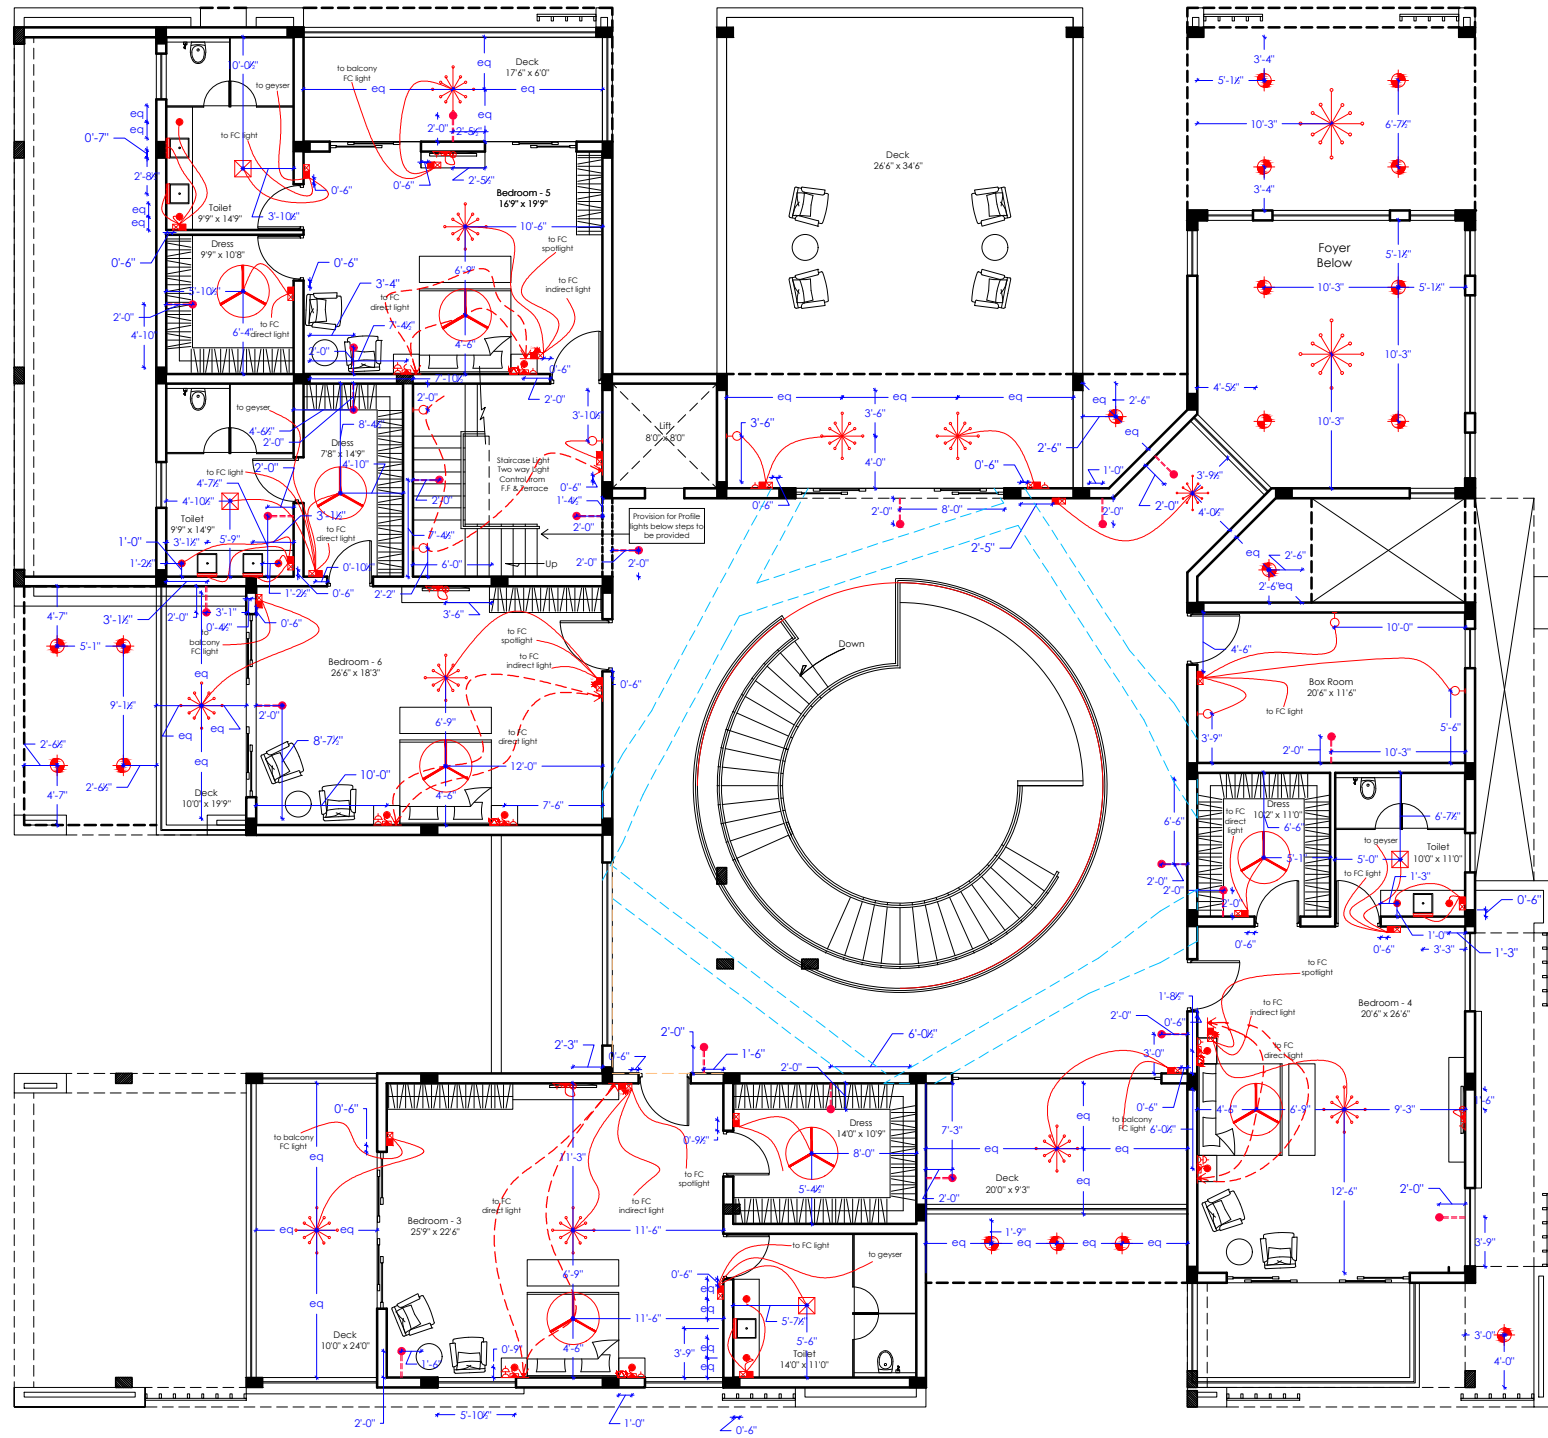

	Switch box with 1no. 6A socket with switch @ 4'0" from F.F.L.
	Switch box with 1no. 6A socket with switch @ 1'9" from F.F.L.
	1no. 6A socket with switch
	1no. 16/6A combined socket with switch @ 4'0" from F.F.L.
	AC switch @ 4'0" from F.F.L.

	1no. 16/6A combined socket with switch @ 1'9" from F.F.L.
	LED Downlight
	Suspended light
	Chandelier
	Mirror Light

	Exhaust
	Heater
	Wall light
	A.C Stabilizer
	DB

	Telephone point
	Bell Push
	Two way Switch Control
	T.V Point @ 4'6" Lvl 3" Pvc Pipe
	Buzzer

	Ceiling Fan
	Provision for light in slab

3" Dia Pvc Pipe
Concealed in Wall

F.F. Lvl

T.V Point provision

NOTE : ALL THE COMMON LIGHTS WILL BE CONNECTED TO THE SECURITY OFFICE.

NOTES:
This drawing is the property of designworks & cannot be used or reproduced any form without their written permission.

Any discrepancy should be brought to the notice of the architects.

Only written dimensions should be followed, the drawing is not to be scaled.

For Discussion	☐ Site Copy	☐
For Approval	☐ Clients Copy	☐
Good For Construction	☐ Contractors Copy	☐

Drawn : Durgaa	Scale : NTS	Date : 29.06.22
Checked : RajeshH	dwg no :	NORTH


File Path :

drawing:
First floor plan - Electrical layout

Project:
Proposed residential development for Mr. Shivakumar @ Uthandi, Chennai

DESIGNWORKS
Architects | Interior Designers | Planners

First Floor, 33.Ranjit Road,
kotturpuram, Chennai - 600 085, India
Tel: +91- 44 - 4230 3731/32/33
Fax: +91- 44 - 42303734
E-mail: mail@designworks.in
Web: www.designworks.in


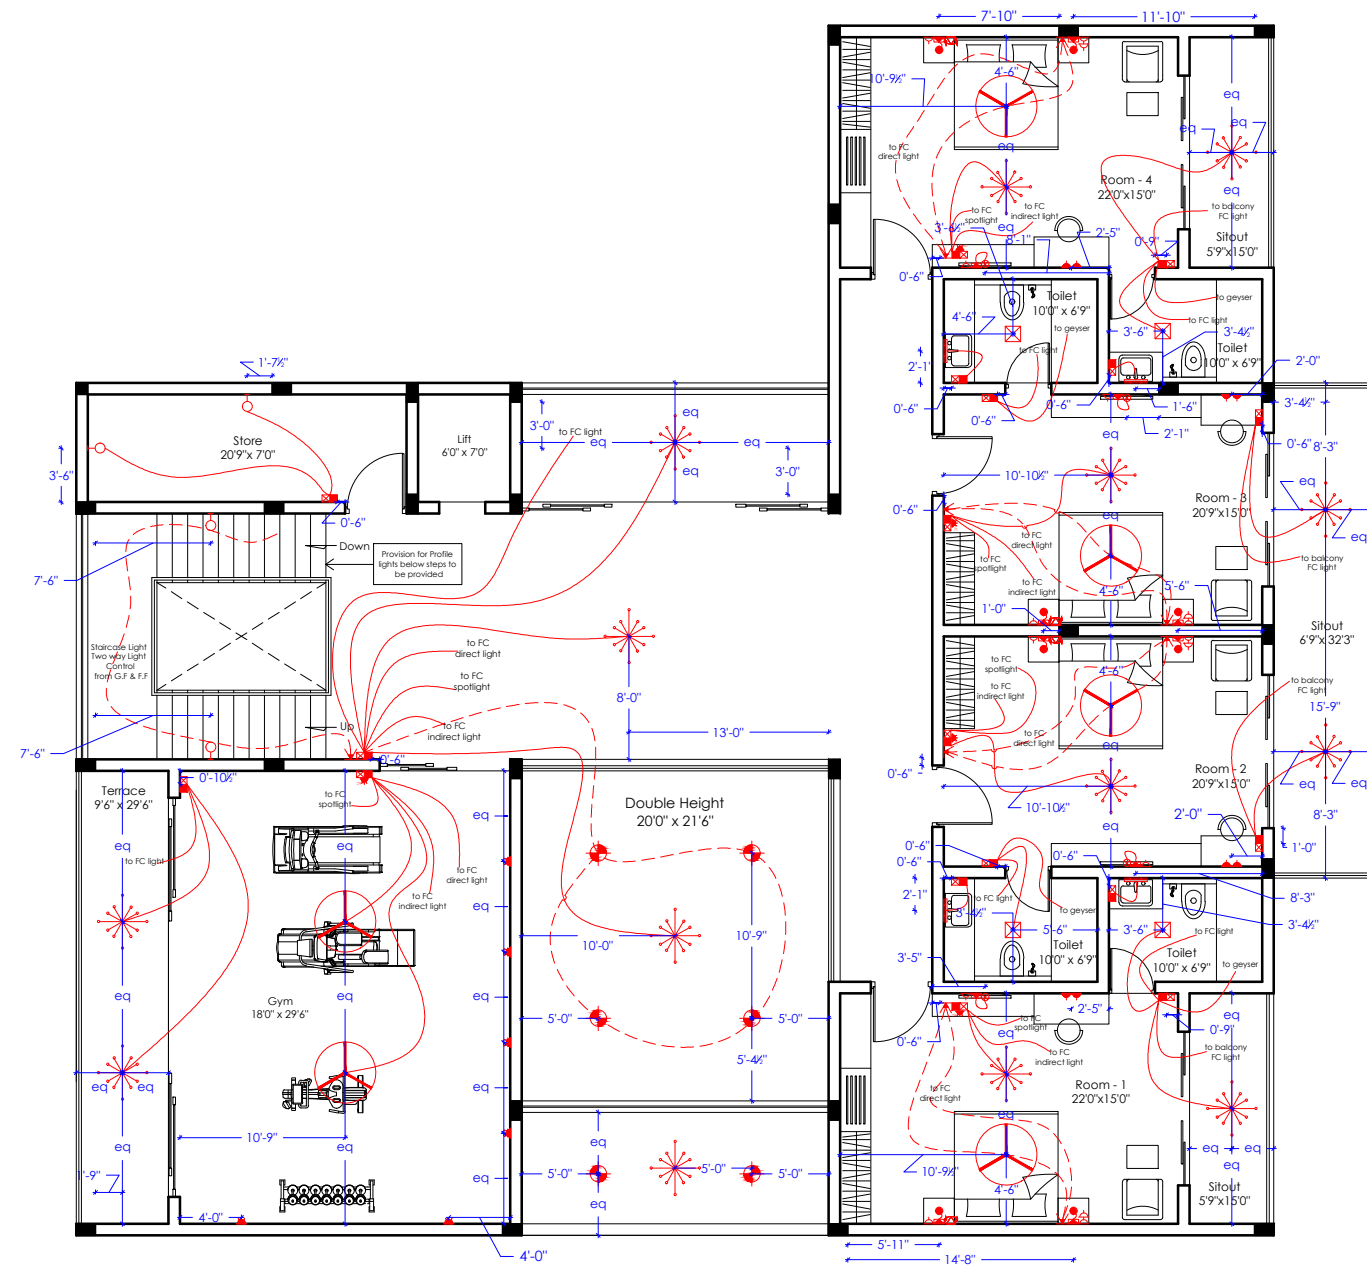


	Switch box with 1no. 6A socket with switch @ 4'0" from F.F.L.
	Switch box with 1no. 6A socket with switch @ 1'9" from F.F.L.
	1no. 6A socket with switch
	1no. 16/6A combined socket with switch @ 4'0" from F.F.L.
	AC switch @ 4'0" from F.F.L.

	1no. 16/6A combined socket with switch @ 1'9" from F.F.L.
	LED Downlight
	Suspended light
	Chandelier
	1no. 6A socket with switch @ 1'9" from F.F.L.

	Exhaust
	Heater
	Wall light
	A.C Stabilizer
	DB

	Telephone point
	Bell Push
	Two way Switch Control
	T.V Point @ 4'6" Lvl 3" Pvc Pipe
	Mirror Light

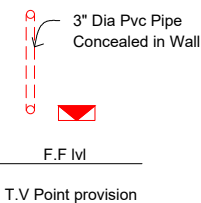 

NOTE : ALL THE COMMON LIGHTS WILL BE CONNECTED TO THE SECURITY OFFICE.

NOTES:
This drawing is the property of designworks & cannot be used or reproduced any form without their written permission.

Any discrepancy should be brought to the notice of the architects.

Only written dimensions should be followed, the drawing is not to be scaled.

For Discussion	☐	Site Copy	☐
For Approval	☐	Clients Copy	☐
Good For Construction	☐	Contractors Copy	☐


Drawn : Durgaa	Scale: NTS	Date: 29.06.'22
Checked : RajeshH Sign :	dwg no:	NORTH

File Path :


drawing:
Entertainment Block - First floor plan - Electrical layout

Project:
Proposed residential development for Mr. Shivkumar @ Uthandi, Chennai

DESIGNWORKS
Architects | Interior Designers | Planners
First Floor, 33.Ranjit Road, kotturpuram, Chennai - 600 085, India
Tel: +91- 44 - 4230 3731/32/33
Fax: +91- 44 - 42303734
E-mail: mail@designworks.in
Web: www.designworks.in

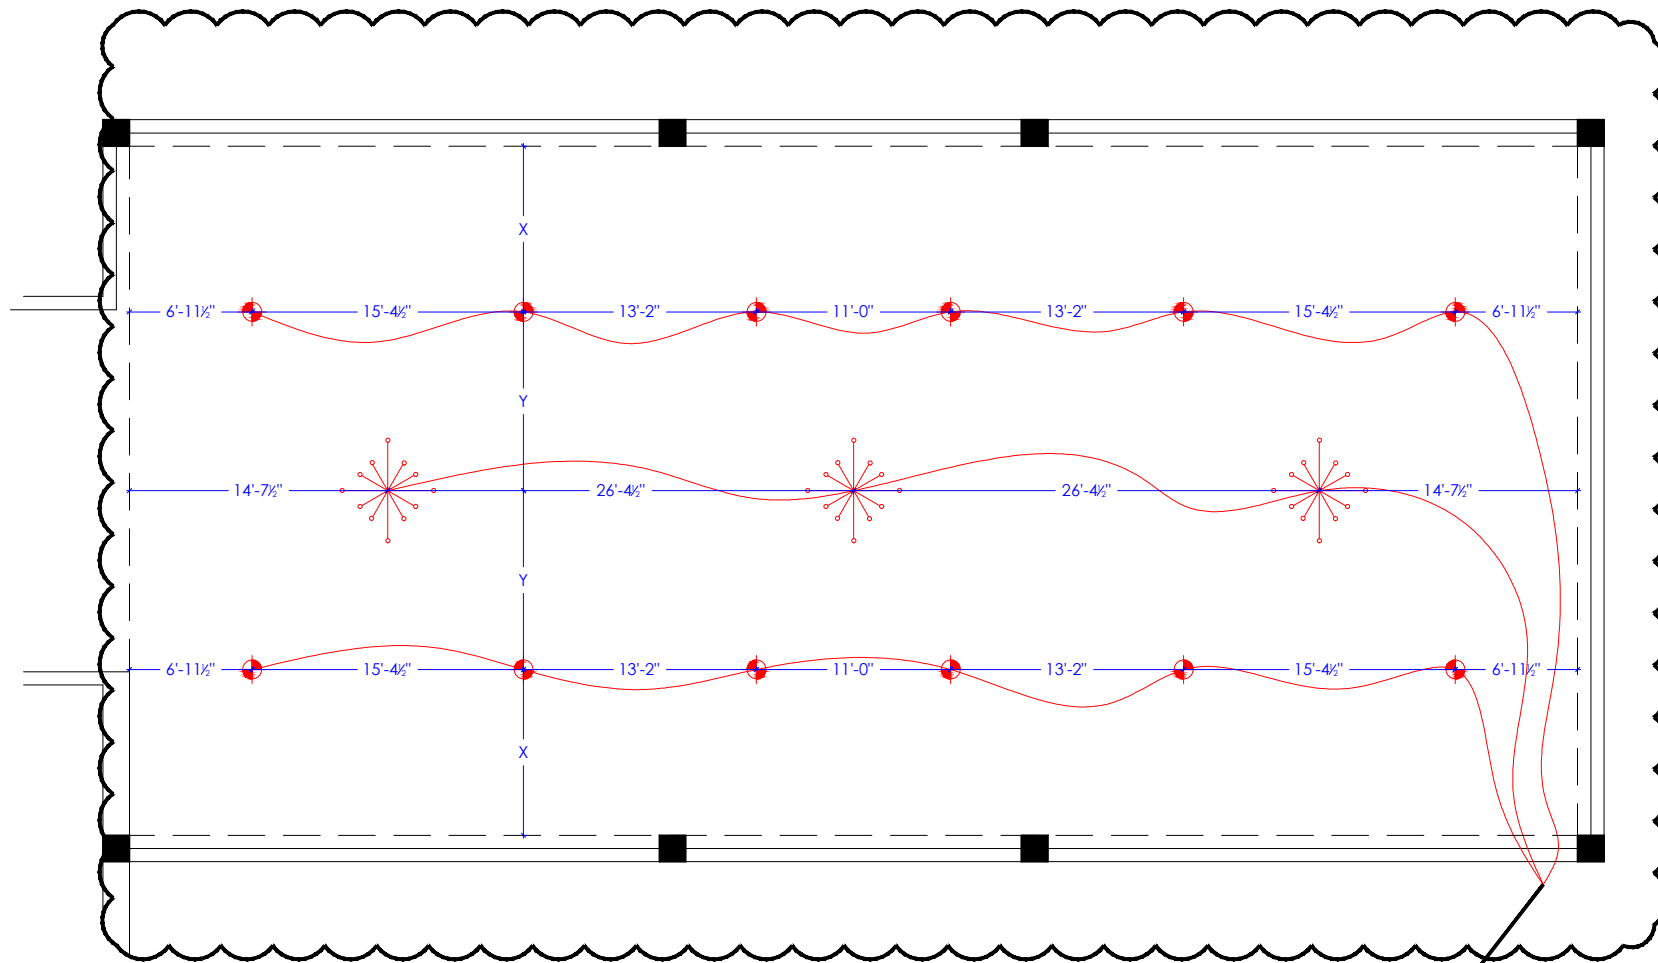

Lights will be connected to the security office

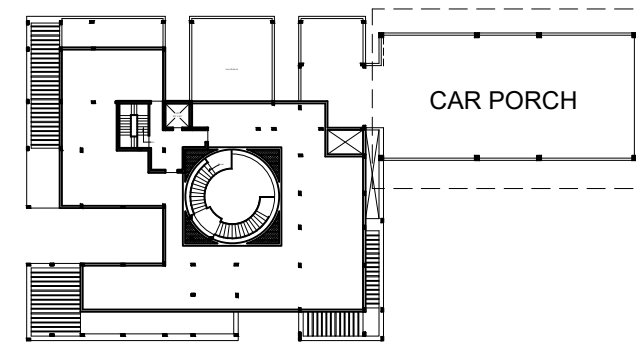

KEY PLAN

LEGEND



LED Downlight



Chandelier

NOTE :
ALL THE COMMON LIGHTS
WILL BE CONNECTED TO THE
SECURITY OFFICE.

NOTES:
This drawing is the property of designworks & cannot be used or reproduced any form without their written permission.

Any discrepancy should be brought to the notice of the architects.

Only written dimensions should be followed, the drawing is not to be scaled.

For Discussion	☐	Site Copy	☐
For Approval	☐	Clients Copy	☐
Good For Construction	☐	Contractors Copy	☐


Drawn : Durgaa	Scale: NTS	Date: 12.08.'22
Checked : RajeshH Sign :	dwg no :	NORTH
File Path :		

drawing :
Car Porch - Electrical layout


Project :
Proposed residential development for Mr. Shivkumar @ Uthandi, Chennai

DESIGNWORKS
Architects | Interior Designers | Planners
First Floor, 33,Ranjit Road,
kotturpuram, Chennai - 600 085, India
Tel: +91- 44 - 4230 3731/32/33
Fax: +91- 44 - 42303734
E-mail: mail@designworks.in
Web: www.designworks.in



TITLE OF THE PROJECT	:	SUBRAMANI RESIDENCE
PROJECT TYPOLOGY	:	HOME OFFICE
CLIENT	:	Mr. SUBRAMANI
LOCATION	:	ADYAR, CHENNAI
PROJECT STATUS	:	ON-GOING

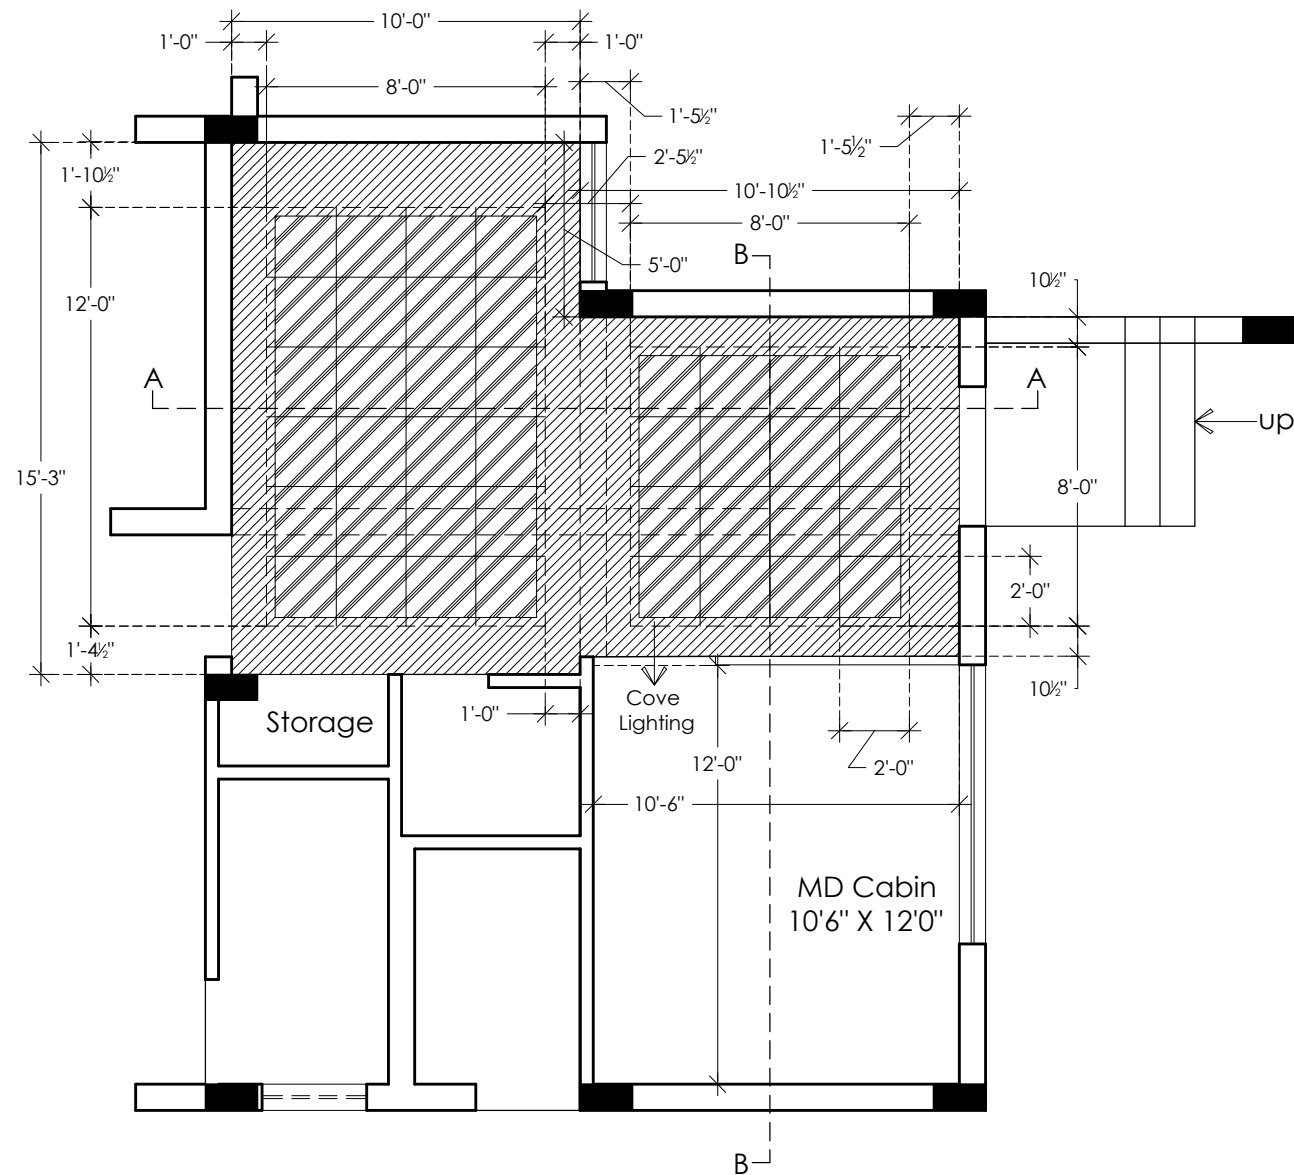


PLAN

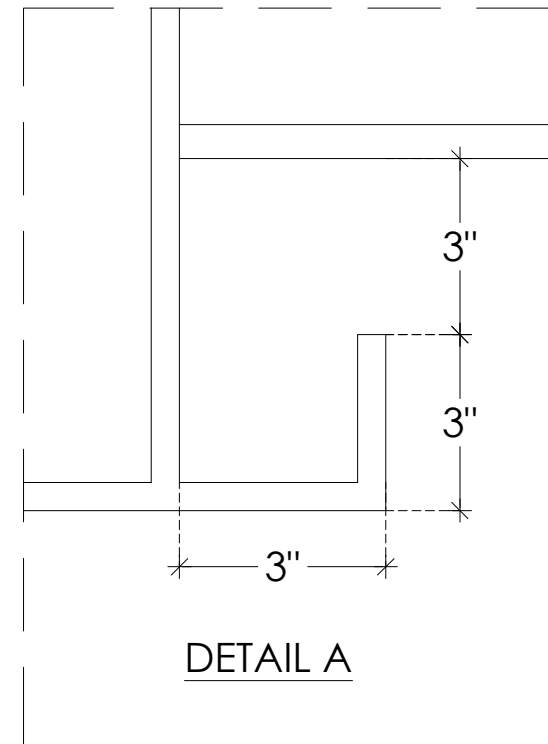


DETAIL A

  -  Gypsum board ceiling @ 1 feet below beam bottom
-  2' x 2' Veneer False ceiling @ 6 inches below beam bottom

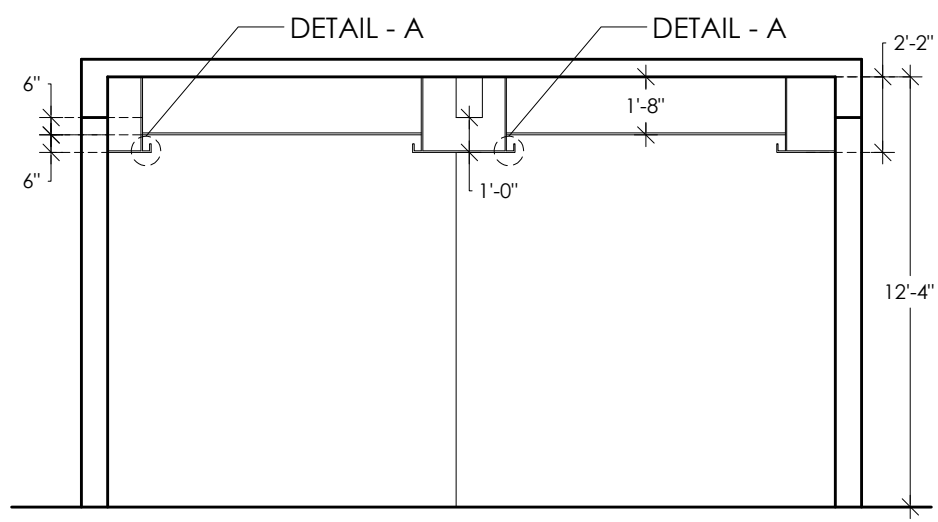

SECTION - AA

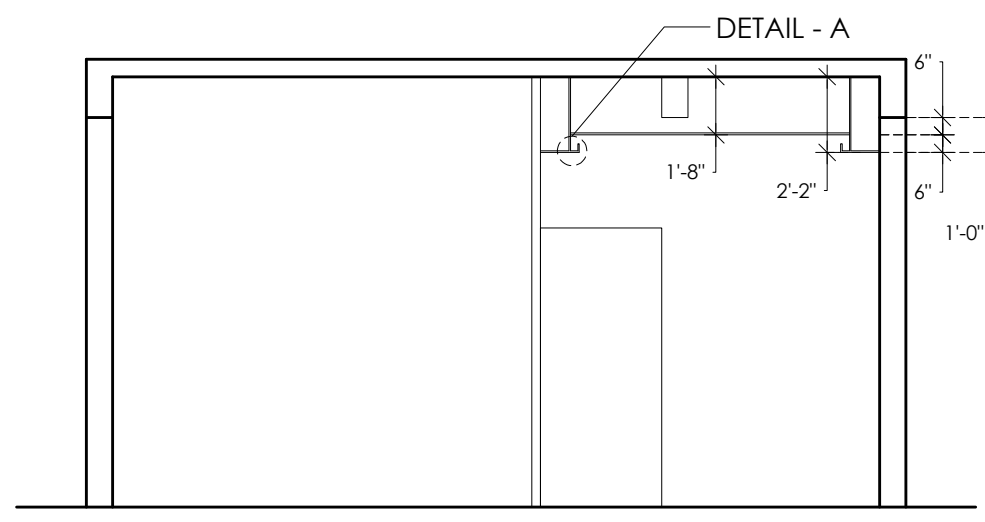

SECTION - BB

NOTES:
This drawing is the property of designworks & cannot be used or reproduced any form without their written permission.

Any discrepancy should be brought to the notice of the architects.

Only written dimensions should be followed, the drawing is not to be scaled.

For Discussion	☐	Site Copy	☐
For Approval	☐	Clients Copy	☐
Good For Construction	☐	Contractors Copy	☐


Drawn : Durgaa	Scale: NTS	Date: 27.07.'22
Checked : Rajesh Sign :	dwg no:	 N

drawing:
WORKSTATION & WAITING AREA
FALSE CEILING LAYOUT


project:
Proposed home office for
Mr.Subramani @ Adyar, Chennai

DESIGNWORKS
Architects | Interior Designers | Planners

First Floor, 33, Ranjith Road
Kotturpuram, Chennai - 600 085
Tel: +91- 44 - 4230 3732/33
E-mail: mail@designworks.in
Web: www.designworks.in

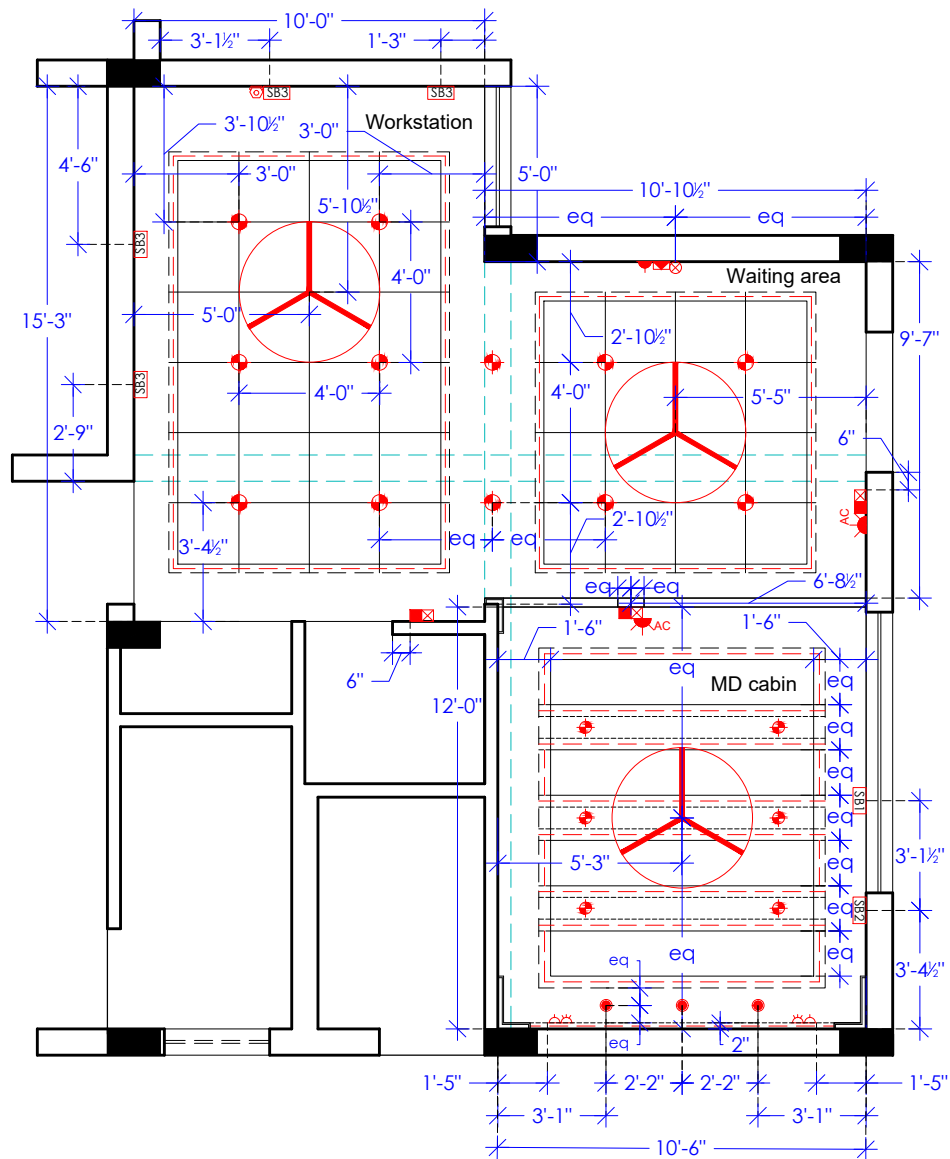


LIGHTING & ELECTRICAL LAYOUT

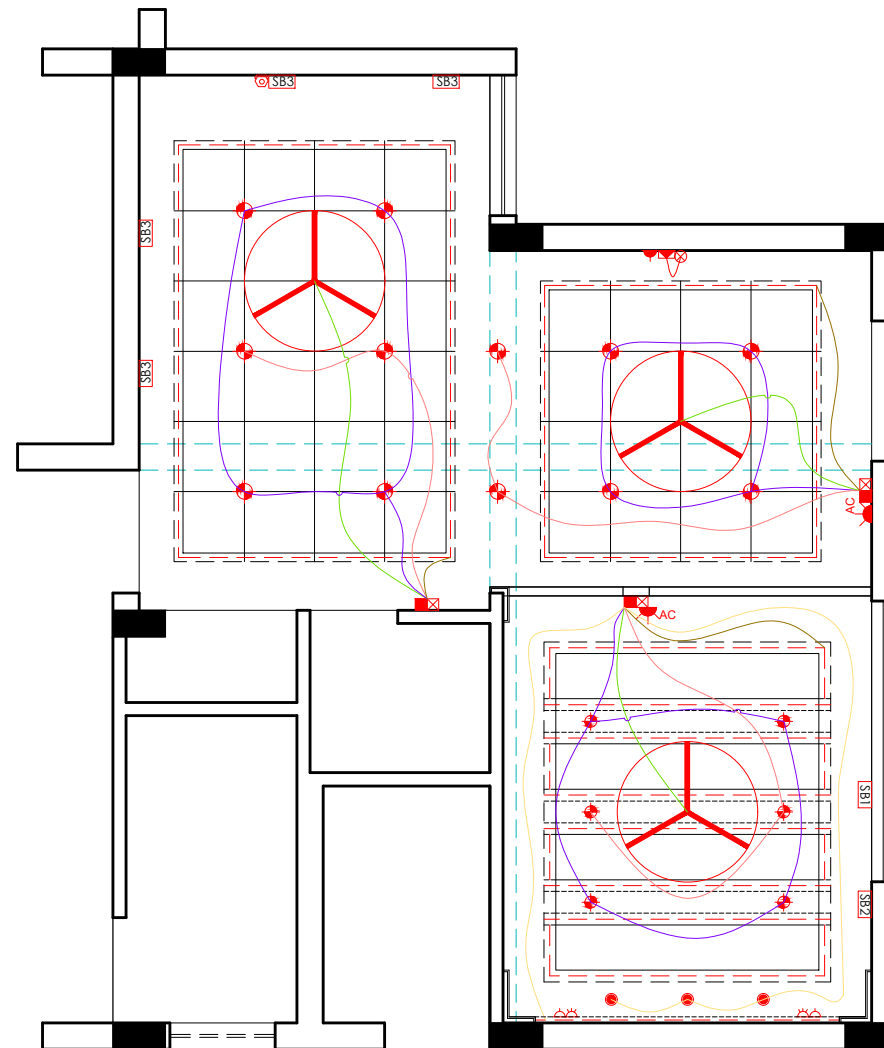

LOOPING LAYOUT

NOTE : Fans not be installed. Only provisions for fan has to be given above the false ceiling.

	Switch box @ 4'6" from F.F.L
	3nos. 5amps socket with switch with Socket bottom @ 1'9" from F.F.L + 1no. Telephone point + 1no. Data
	2nos. 5amps socket with switch with Socket bottom @ 2'6" from F.F.L + 2nos. Data
	2nos. 5amps socket with switch with Socket bottom @ 1'9" from F.F.L + 1no. Data
	1no. 5 amps socket with switch with Socket bottom @ 2'9" from F.F.L
	1no. 16/6 amps Combined socket with switch with Socket bottom @ 2'9" from F.F.L
	AC switch @ 4'6" from F.F.L.
	LED Strip light
	LED Downlight
	LED Spotlight
	Telephone Point @ 1'9" from F.F.L
	Switch box with 1no. 6A socket with switch @ 4'0" from F.F.L.
	1no. 6A socket with switch @ 4'0" from F.F.L
	Ceiling Fan

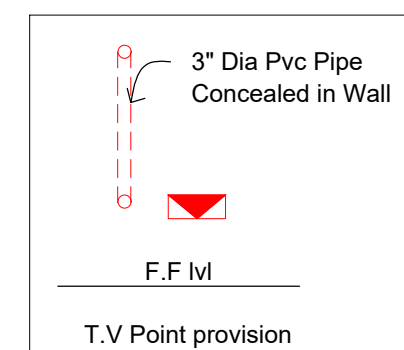

NOTES:
This drawing is the property of designworks & cannot be used or reproduced any form without their written permission.

Any discrepancy should be brought to the notice of the architects.

Only written dimensions should be followed, the drawing is not to be scaled.

For Discussion	☐	Site Copy	☐
For Approval	☐	Clients Copy	☐
Good For Construction	☐	Contractors Copy	☐


Drawn : Durgaa	Scale : NTS	Date: 13.09.22
Checked : Rajesh Sign :	dwg no:	

drawing :
HOME OFFICE
LIGHTING & ELECTRICAL LAYOUT


project:
Proposed Home office for
Mr.Subramani @ Adyar, Chennai

DESIGNWORKS
Architects | Interior Designers | Planners


First Floor, 33, Ranjith Road
Kotturpuram, Chennai - 600 085
Tel: +91- 44 - 4230 3732/33
E-mail: mail@designworks.in
Web: www.designworks.in

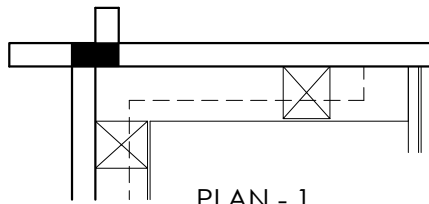


PLAN - 1

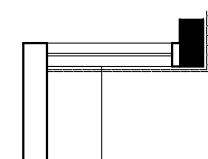


PLAN - 2

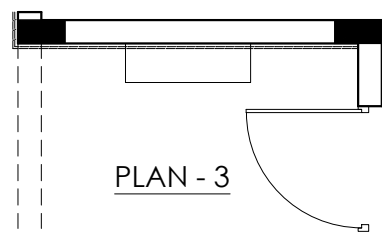


PLAN - 3

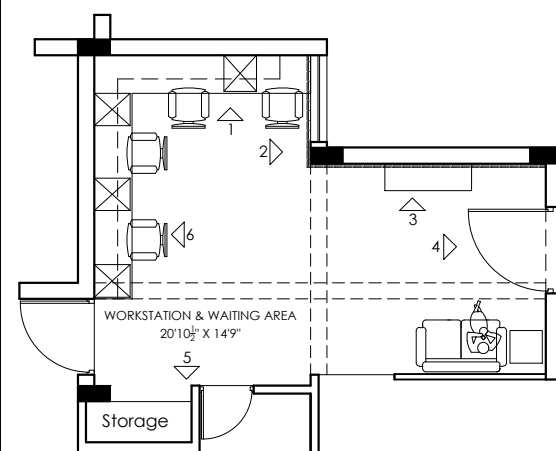


LAYOUT

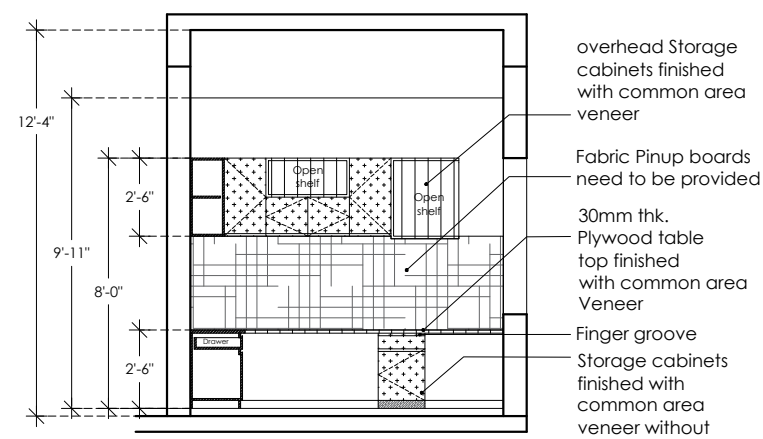


ELEVATION - 1

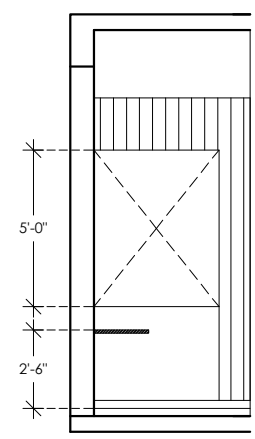


ELEVATION - 2

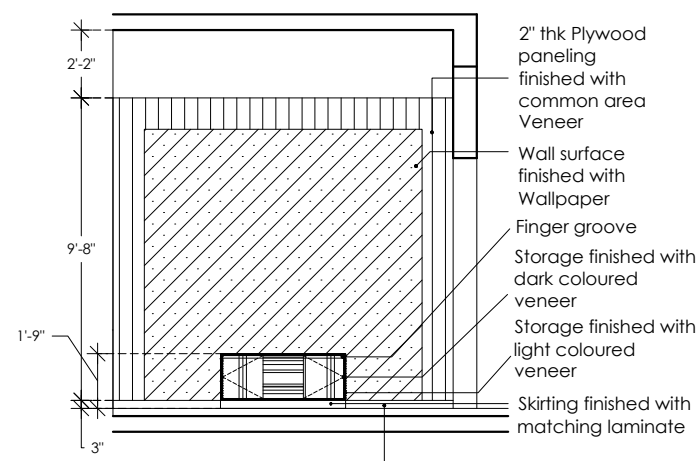


ELEVATION - 3

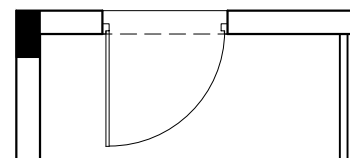


PLAN - 4

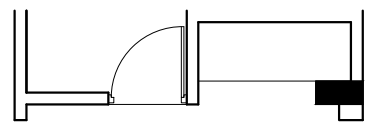


PLAN - 5

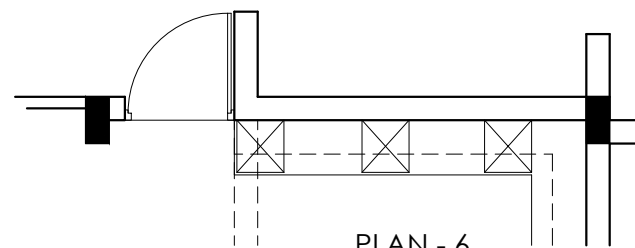


PLAN - 6

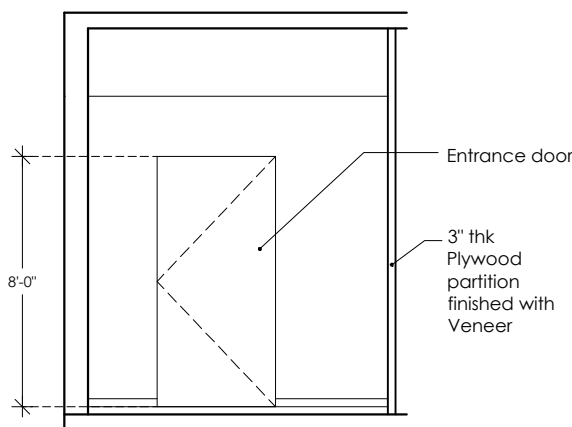

ELEVATION - 4

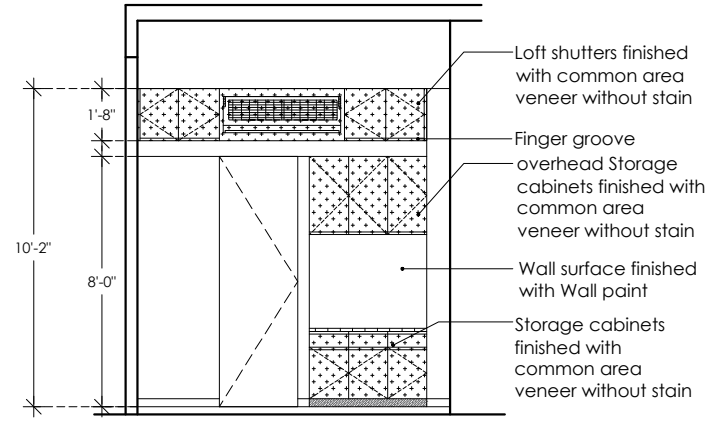

ELEVATION - 5

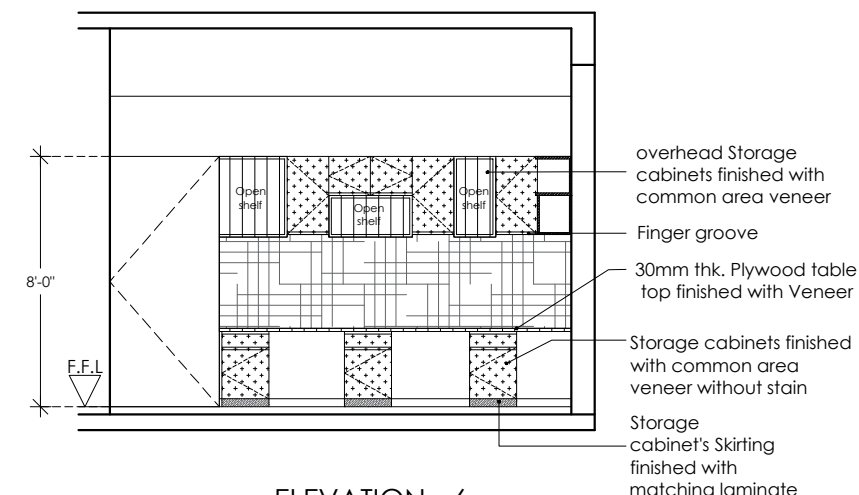

ELEVATION - 6

NOTES:
This drawing is the property of designworks & cannot be used or reproduced any form without their written permission.
Any discrepancy should be brought to the notice of the architects.
Only written dimensions should be followed, the drawing is not to be scaled.

For Discussion	☐	Site Copy	☐
For Approval	☐	Clients Copy	☐
Good For Construction	☐	Contractors Copy	☐

Drawn : Durgaa	Scale : NTS	Date : 15.09.22
Checked : Rajesh Sign :	dwg no :	

drawing:
Workstation wall elevations














project:
Proposed Home office for Mr.Subramani @ Adyar, Chennai

DESIGNWORKS
Architects | Interior Designers | Planners


First Floor, 33, Ranjith Road
Kotturpuram, Chennai - 600 085
Tel: +91- 44 - 4230 3732/33
E-mail: mail@designworks.in
Web: www.designworks.in

	Wallpaper		Common area veneer		Common area veneer without stain		Dark coloured veneer		Light coloured veneer		Storage Skirting
--	-----------	--	--------------------	--	----------------------------------	--	----------------------	--	-----------------------	--	------------------

NOTE : Finger grooves to be provided for all the shutters and drawers.

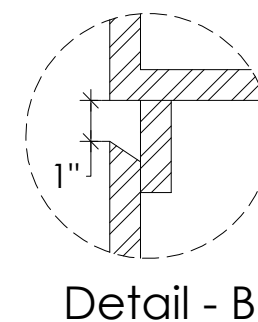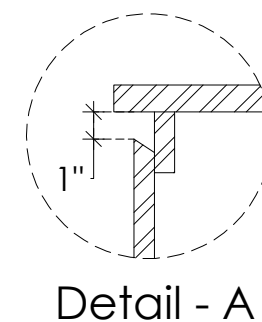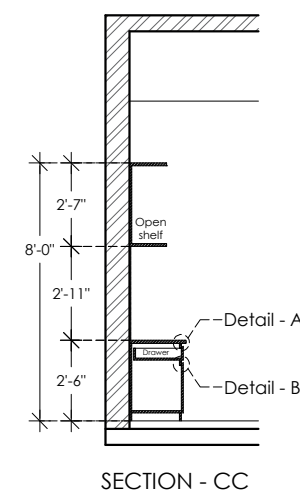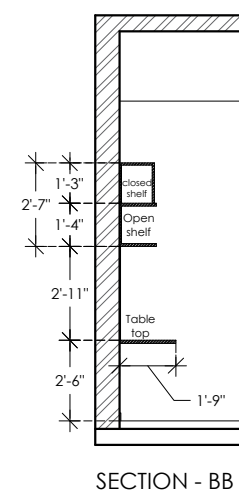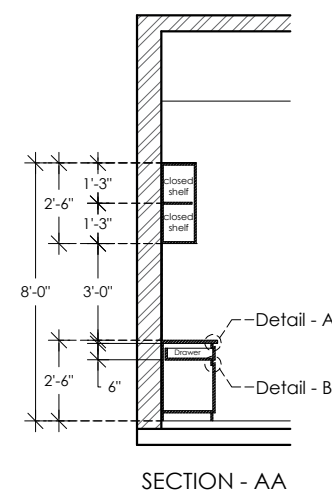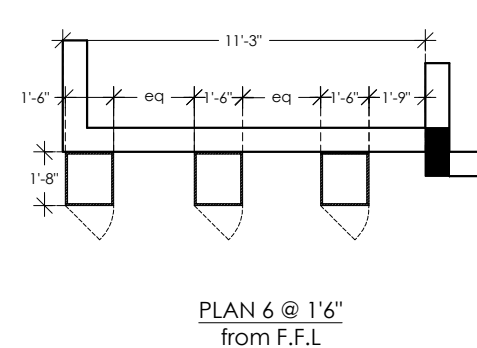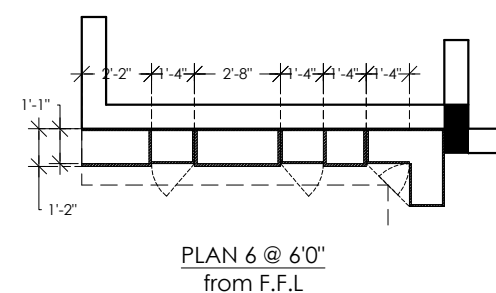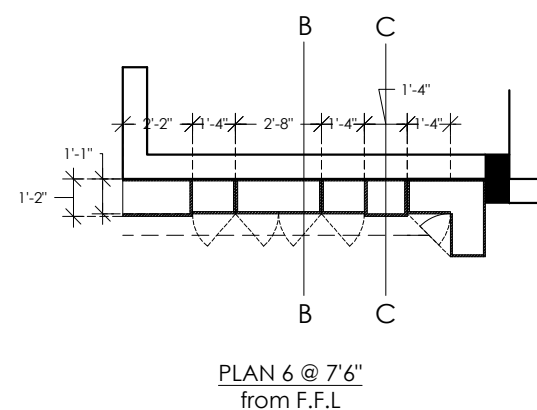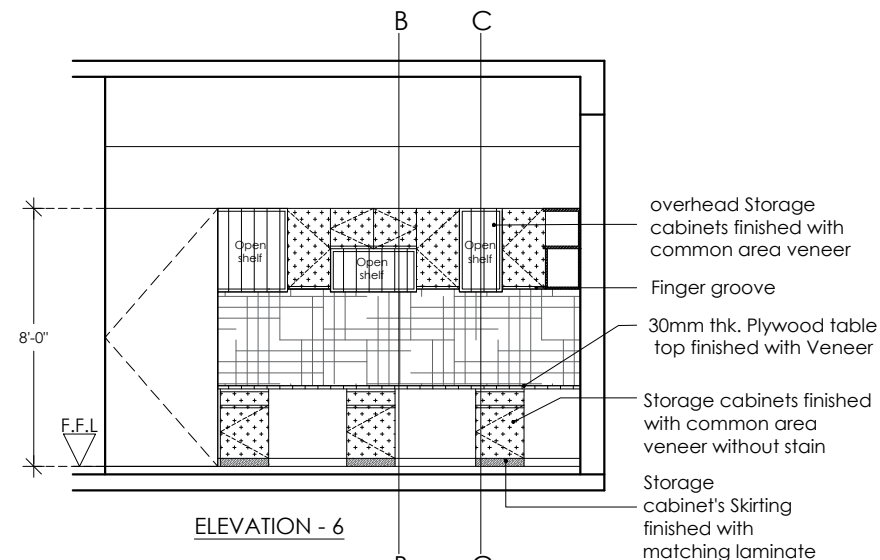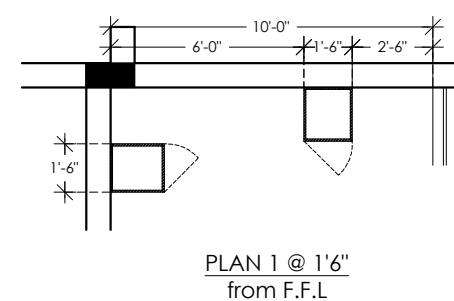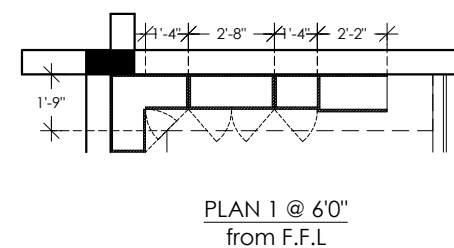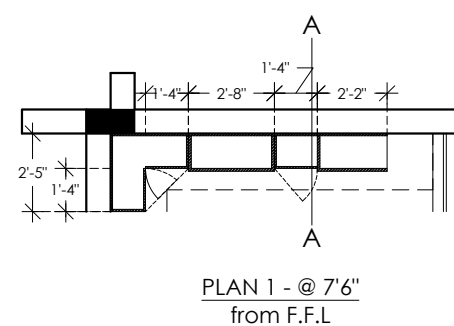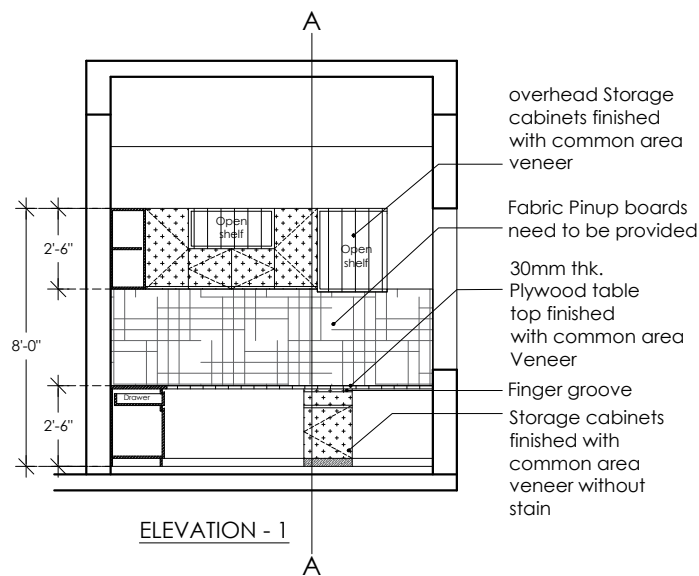

FINGER GROOVE DETAILS

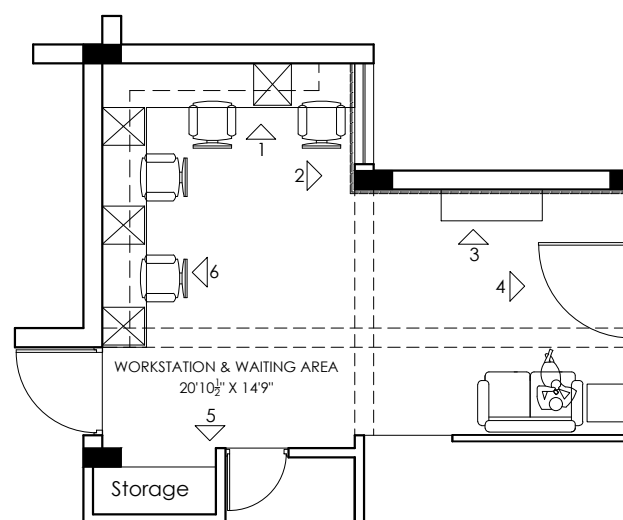

NOTES:
This drawing is the property of designworks & cannot be used or reproduced any form without their written permission.

Any discrepancy should be brought to the notice of the architects.

Only written dimensions should be followed, the drawing is not to be scaled.

For Discussion	☐ Site Copy	☐
For Approval	☐ Clients Copy	☐
Good For Construction	☐ Contractors Copy	☐

Drawn : Durgaa	Scale: NTS	Date: 15.09'22
Checked : Rajesh Sign :	dwg no:	

drawing:
Workstation cabinets detail

project:
Proposed Home office for Mr.Subramani @ Adyar, Chennai

DESIGNWORKS
Architects | Interior Designers | Planners









First Floor, 33, Ranjith Road
Kotturpuram, Chennai - 600 085
Tel: +91- 44 - 4230 3732/33
E-mail: mail@designworks.in
Web: www.designworks.in

Common area veneer


Common area veneer without stain

Storage Skirting


NOTE : Finger grooves to be provided for all the shutters and drawers.

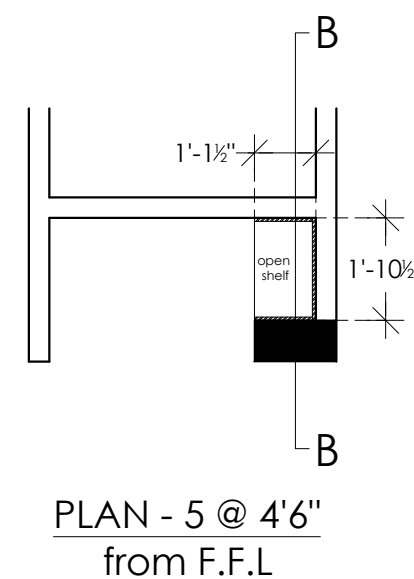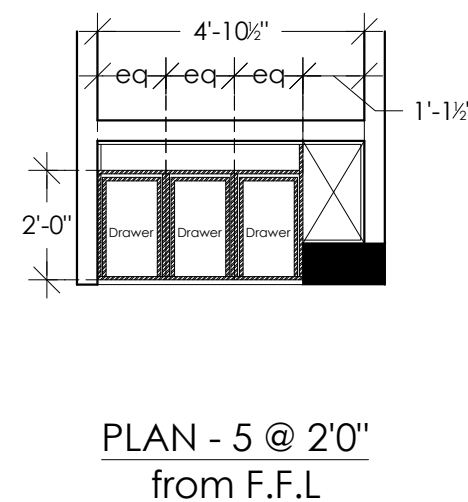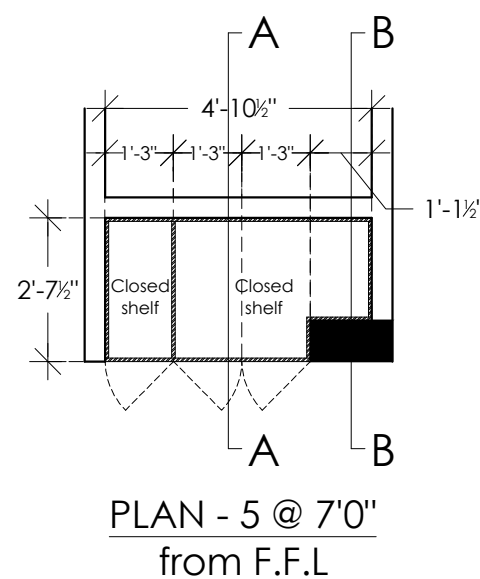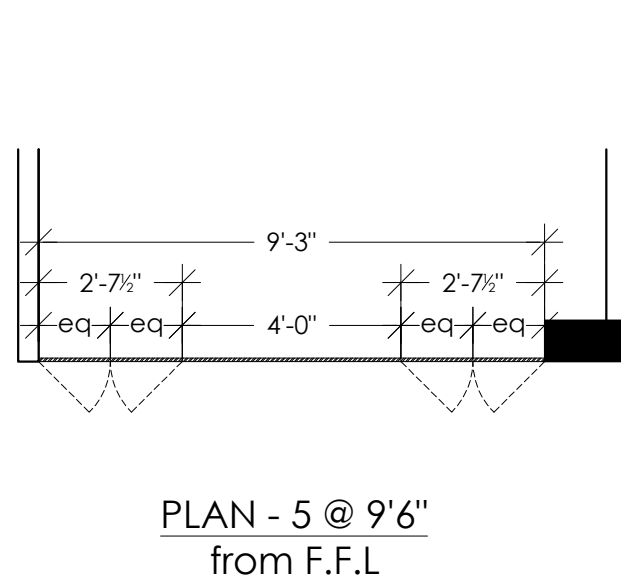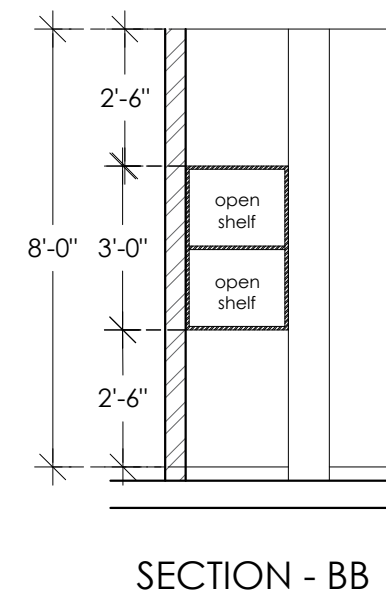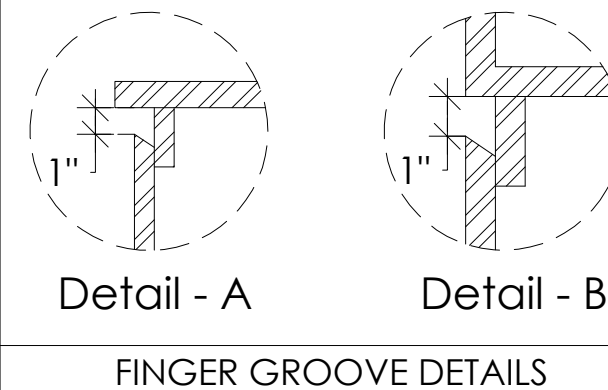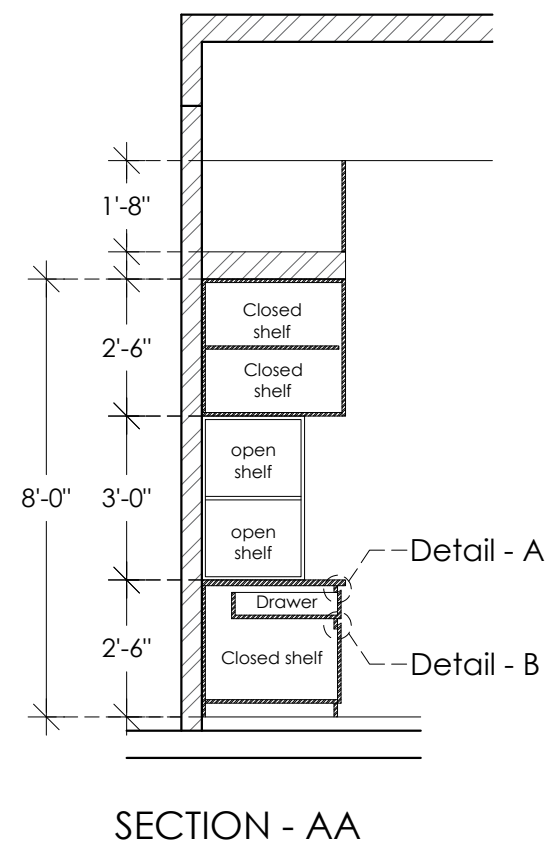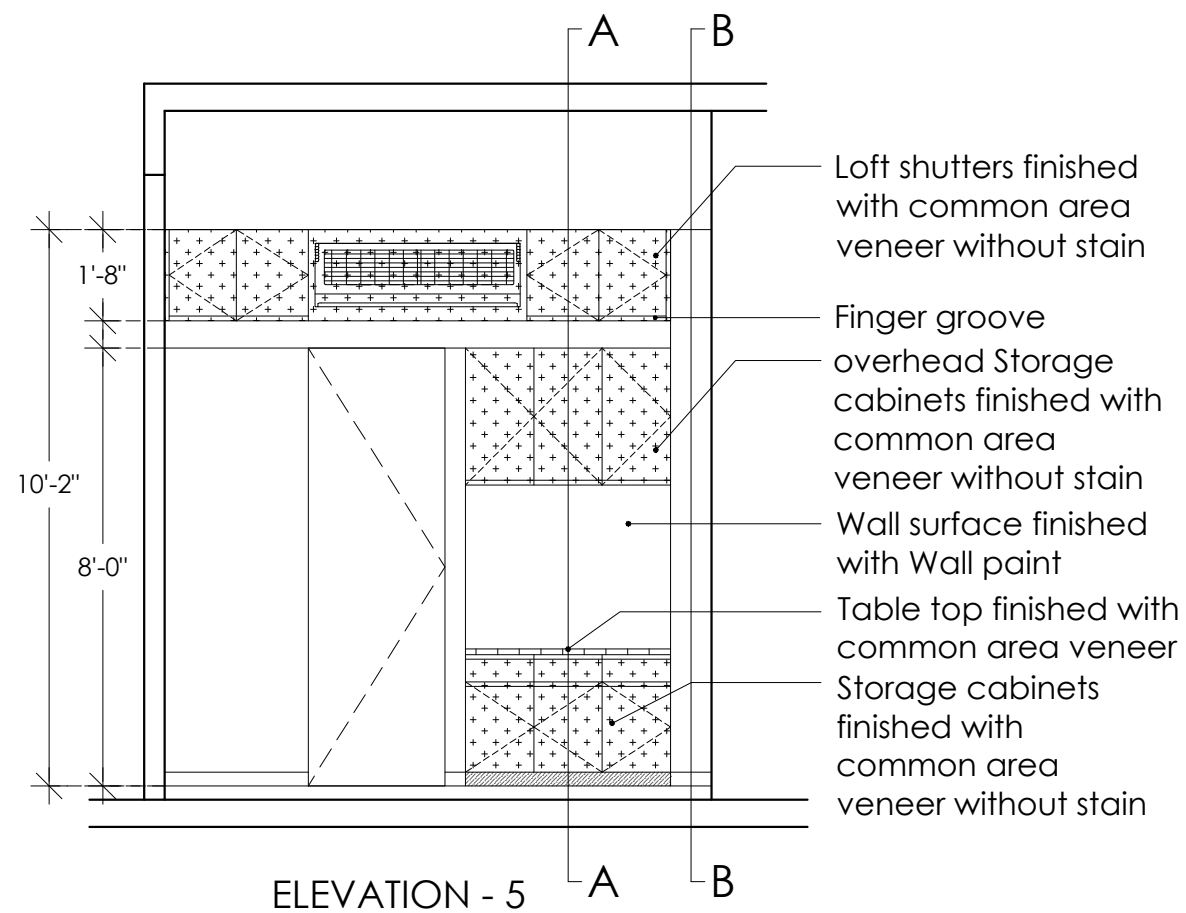

Common area veneer

 

Common area veneer without stain

 


Storage Skirting

NOTE : Finger grooves to be provided for all the shutters and drawers.

NOTES:
This drawing is the property of designworks & cannot be used or reproduced any form without their written permission.

Any discrepancy should be brought to the notice of the architects.

Only written dimensions should be followed, the drawing is not to be scaled.

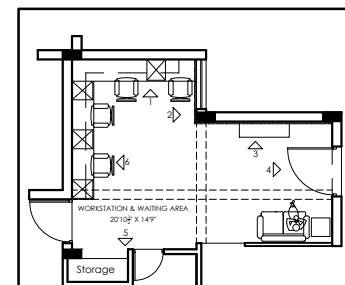

LAYOUT

For Discussion	☐ Site Copy	☐
For Approval	☐ Clients Copy	☐
Good For Construction	☐ Contractors Copy	☐








Drawn : Durgaa	Scale : NTS	Date : 15.09.22
Checked : Sign :	dwg no :	

drawing:
Storage area cabinets detail

project:
Proposed Residence for Mr.Subramani
@ Adyar, Chennai

DESIGNWORKS
Architects | Interior Designers | Planners

 First Floor, 33, Ranjith Road
Kotturpuram, Chennai - 600 085
Tel: +91-44-4230 3732/33
E-mail: mail@designworks.in
Web: www.designworks.in

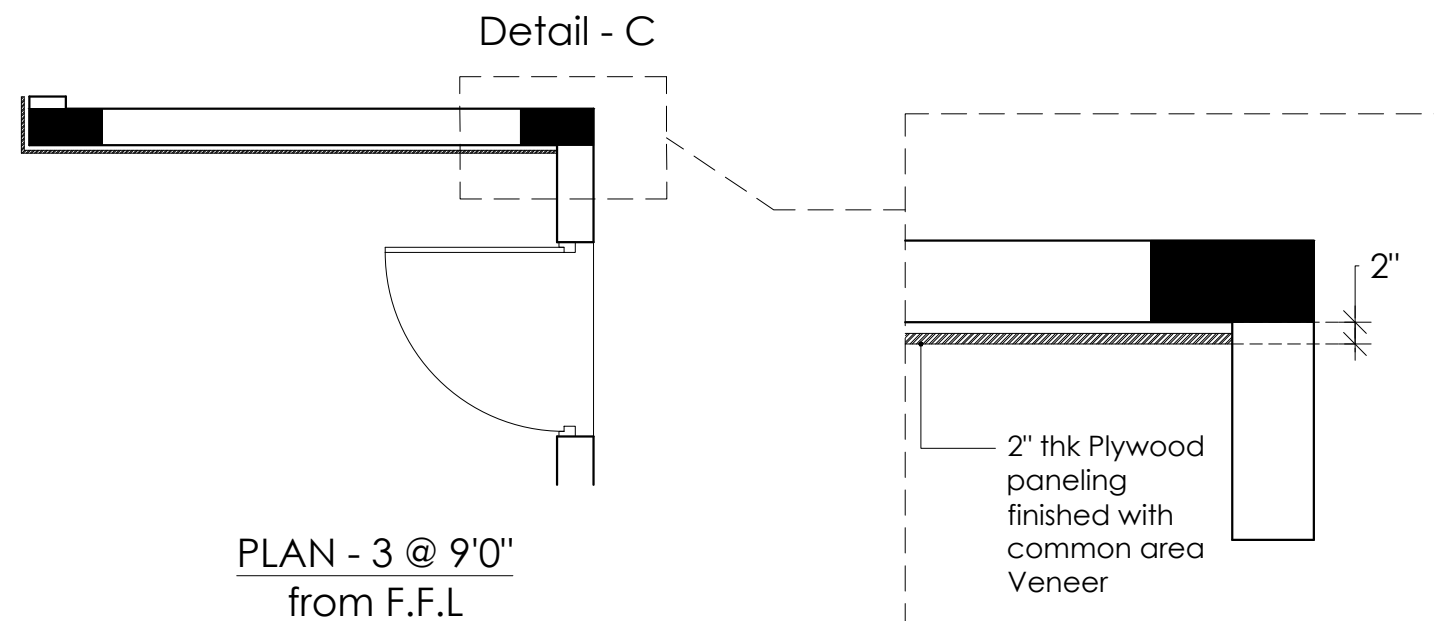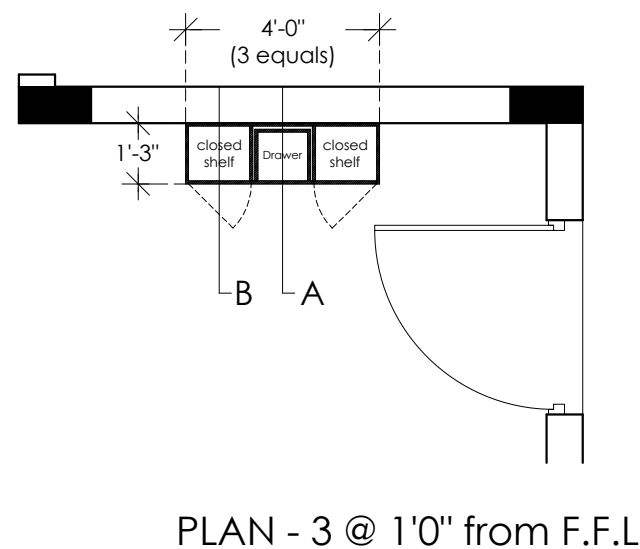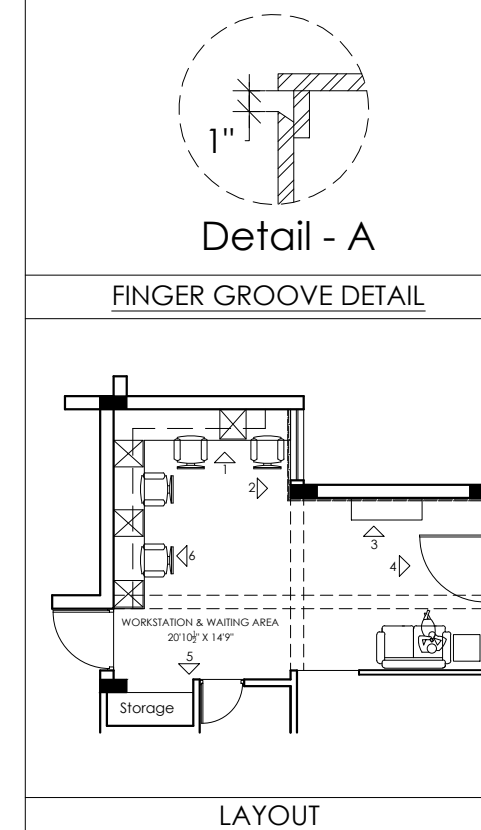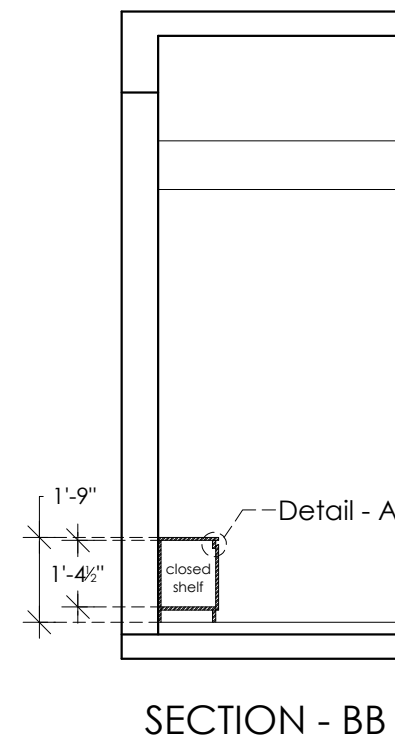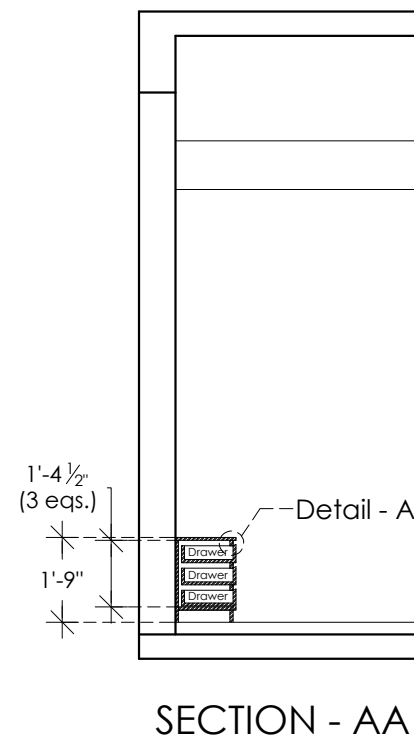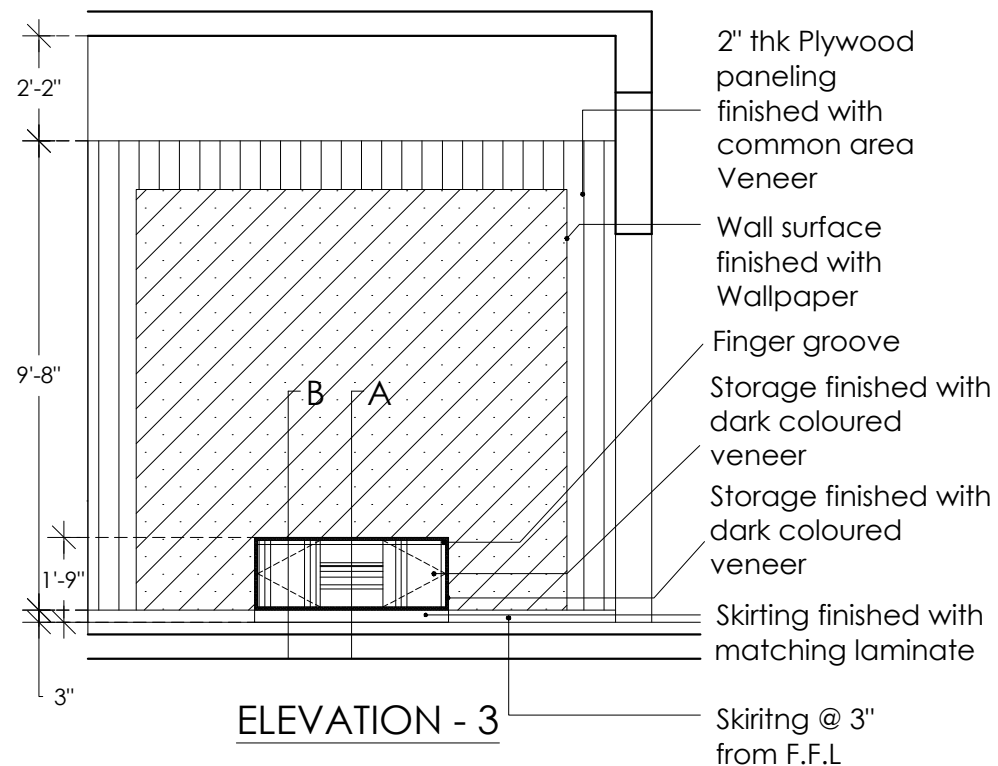

NOTE : Finger grooves to be provided for all the shutters and drawers.

NOTES:
This drawing is the property of designworks & cannot be used or reproduced any form without their written permission.

Any discrepancy should be brought to the notice of the architects.

Only written dimensions should be followed, the drawing is not to be scaled.

For Discussion	☐	Site Copy	☐
For Approval	☐	Clients Copy	☐
Good For Construction	☐	Contractors Copy	☐

Drawn : Durgaa	Scale : NTS	Date : 15.09.22
Checked : Rajesh Sign :	dwg no :	

drawing:
Waiting area storage cabinets & paneling detail

project:
Proposed Residence for Mr.Subramani @ Adyar, Chennai

DESIGNWORKS
Architects | Interior Designers | Planners

First Floor, 33, Ranjith Road
Kotturpuram, Chennai - 600 085
Tel: +91-44-4230 3732/33
E-mail: mail@designworks.in
Web: www.designworks.in

TITLE OF THE PROJECT

PROJECT TYPOLOGY

CLIENT

LOCATION

PROJECT STATUS

:

:

:

:

:

CHOO LAIMEDU RESIDENCE

RESIDENCE - APARTMENT

Mr. JAYARAJ


CHOO LAIMEDU, CHENNAI

ON-GOING

NOTES:
This drawing is the property of
designworks & cannot be used or
reproduced any form without their
written permission.

Any discrepancy should be brought
to the notice of the architects.

Only written dimensions should be
followed, the drawing is not to be
scaled.

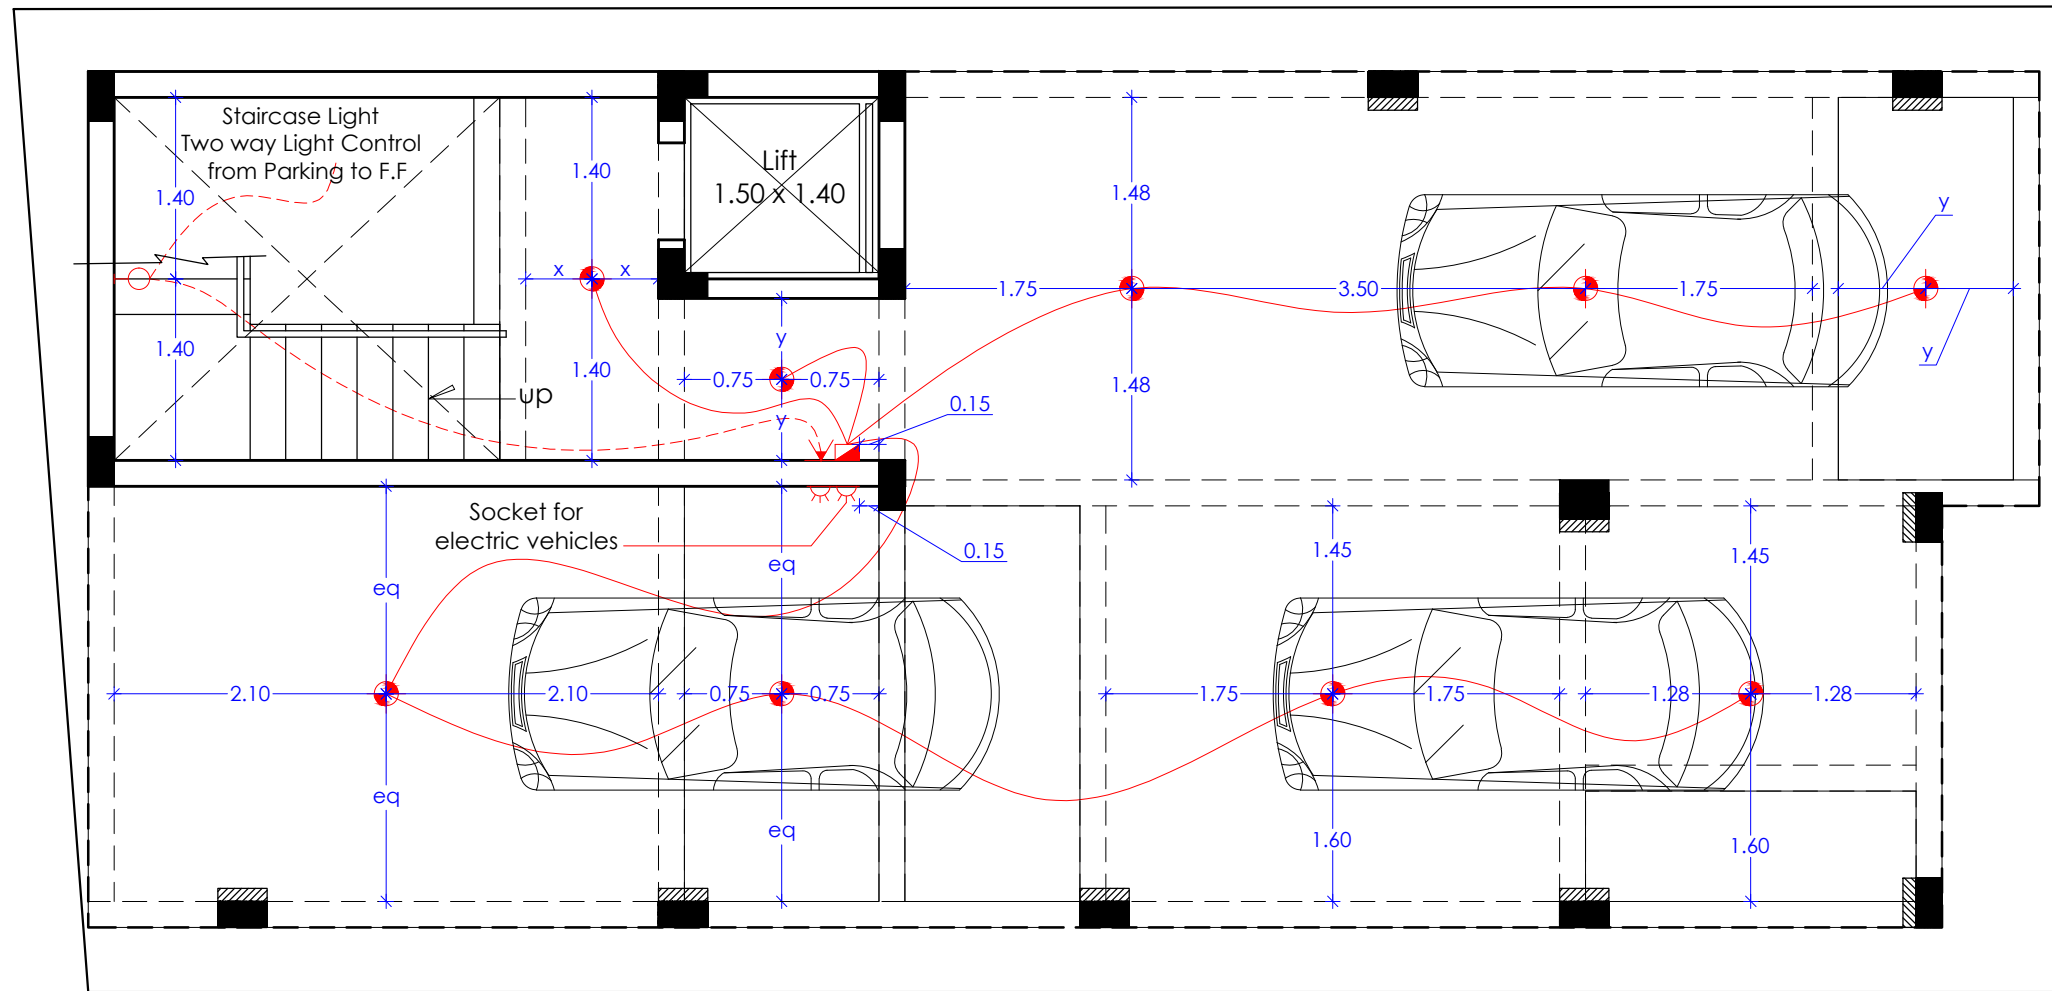

	LED Downlight
	Two way Switch Control
	Wall light

	Switch Board With 1No. 5 AMPS socket @4'0" LVL.
	15 AMPS Switch with Socket @4'0" LVL.

For Discussion	☐	Site Copy	☐
For Approval	☐	Clients Copy	☐
Good For Construction	☐	Contractors Copy	☐


Drawn : Durgaa	Scale : NTS	Date : 12.10.22
Checked : Rajesh Sign :	dwg no:	NORTH 

drawing:
Stilt Floor Plan
Electrical drawing


project:
Proposed Residence @
Choolaimedu, Chennai

DESIGNWORKS
Architects | Interior Designers | Planners

First Floor, 33, Ranjith Road
Kotturpuram, Chennai - 600 085.
Tel: +91 - 44 - 4230 3732/33
E-mail: mail@designworks.in
Web: www.designworks.in

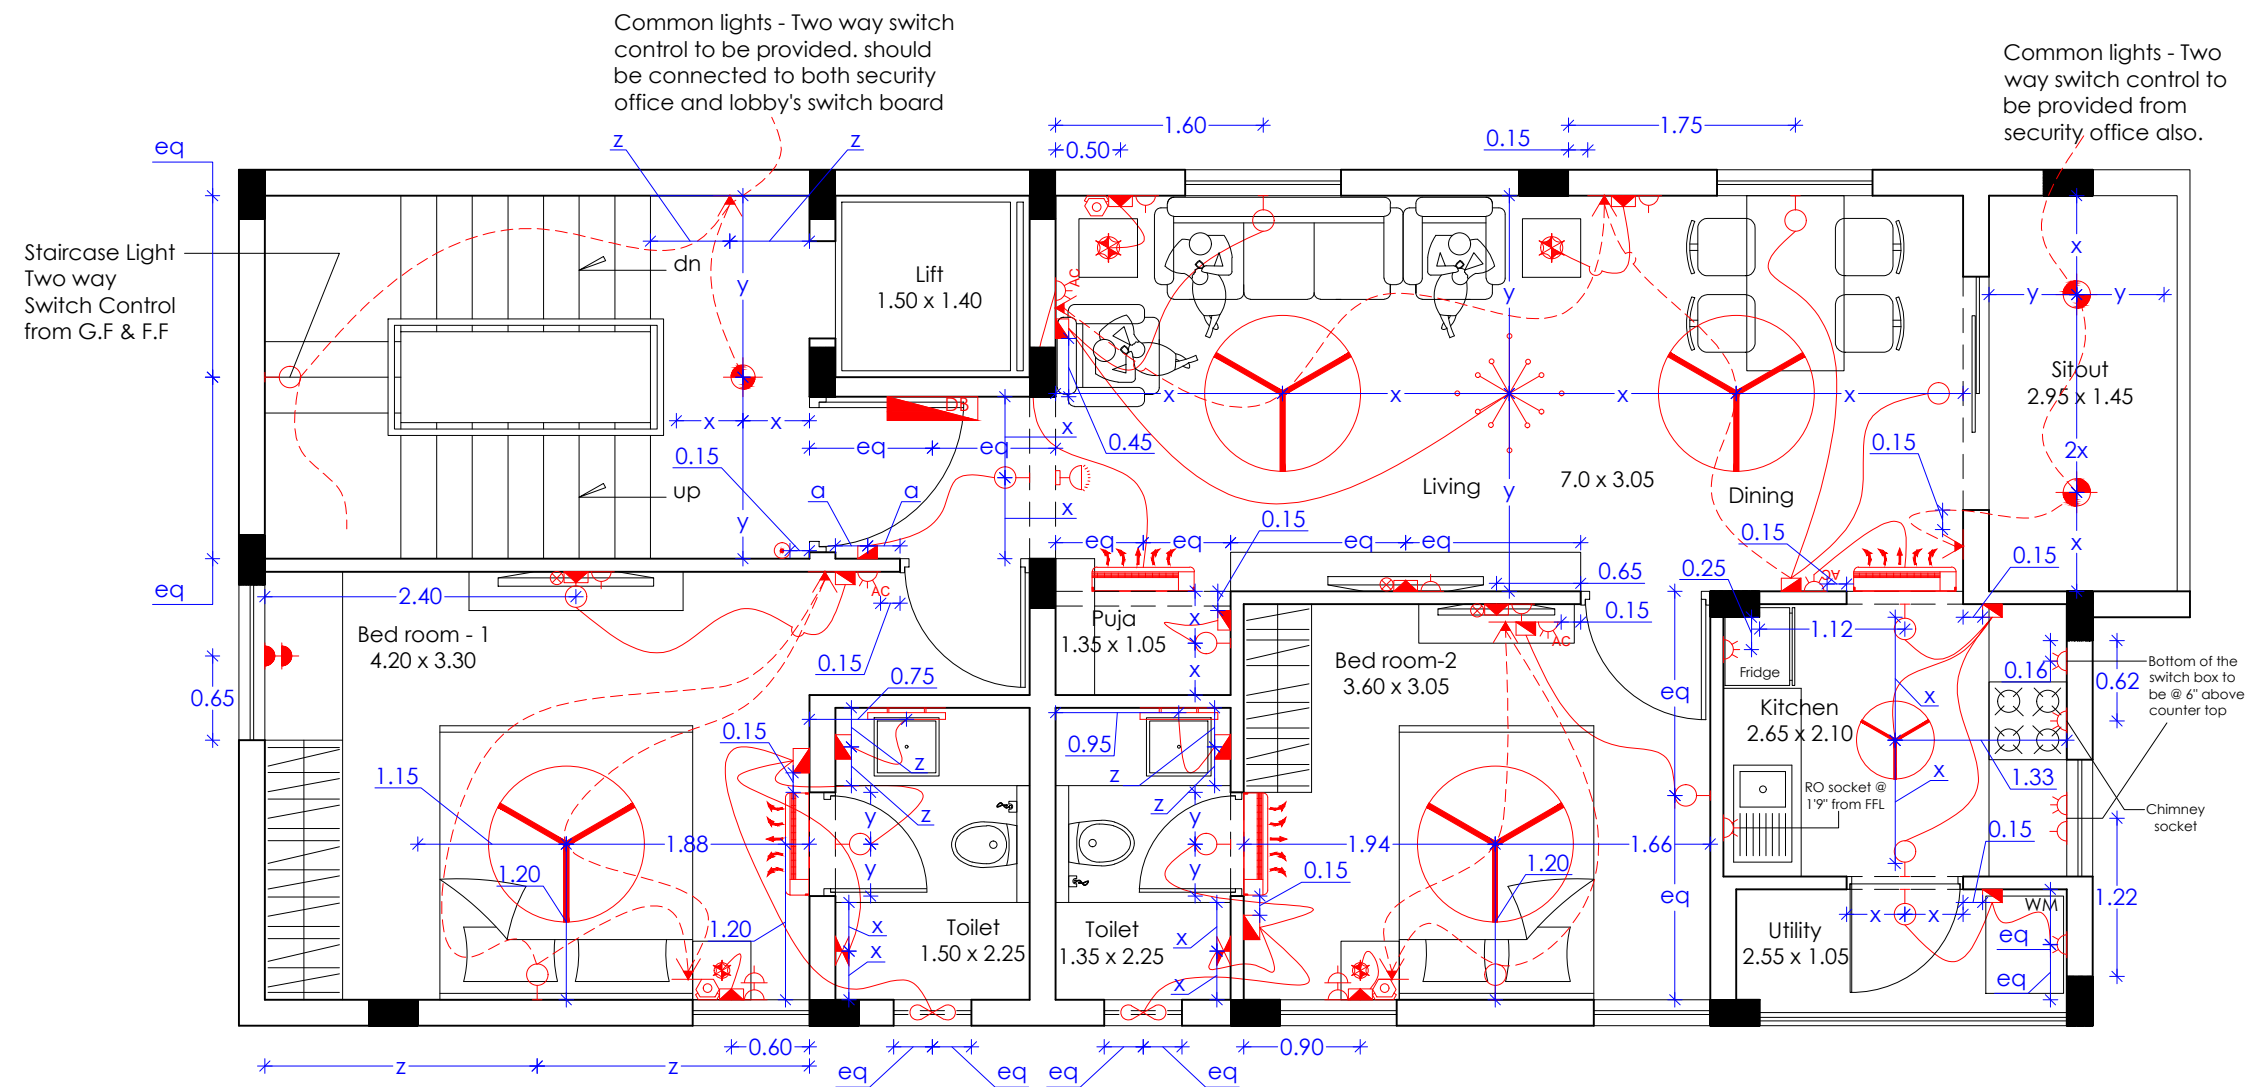

	DISTRIBUTION BOARD		CHANDILER LIGHT		SWITCH BOARD WITH 1No 5AMPS SOCKET @ 1'9" LVL		3/4" PVC PIPE electrical
	A/C INDOOR UNIT		EXHAUST FAN		SWITCH BOARD WITH 1No 5AMPS SOCKET @ 4'0" LVL		1" PVC PIPE electrical
	TABLE LAMP		15 AMPS Switch with Socket		CEILING LIGHT		CEILING FAN
	TELEPHONE POINT		GEYSER 15 amp @ 9' HT		TWO WAY SWITCH CONTROL		5 AMPS Switch with Socket @ 1'9"
	MIRROR LIGHT		5 AMPS Switch with Socket		BUZZER		
	T.V Point @ 4'6" Lvl 3" Pvc Pipe		WALL LIGHT		BELL PUSH SWITCH		

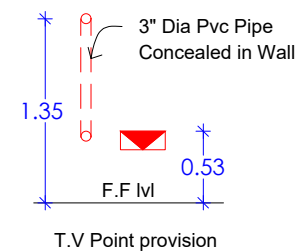

NOTES:
This drawing is the property of designworks & cannot be used or reproduced any form without their written permission.

Any discrepancy should be brought to the notice of the architects.

Only written dimensions should be followed, the drawing is not to be scaled.

For Discussion	☐	Site Copy	☐
For Approval	☐	Clients Copy	☐
Good For Construction	☐	Contractors Copy	☐

Drawn : Durgaa	Scale : NTS	Date : 12.10.22
Checked : Divya	dwg no:	NORTH
Sign :		

drawing:
First Floor Plan
Electrical drawing

project:
Proposed Residence @
Choolaimedu, Chennai

DESIGNWORKS
Architects | Interior Designers | Planners

First Floor, 33, Ranjith Road
Kotturpuram, Chennai - 600 085.
Tel: +91- 44 - 4230 3732/33
E-mail: mail@designworks.in
Web: www.designworks.in


NOTE : Need to provide a dummy switch in switch board in every room

TITLE OF THE PROJECT	:	YERCAUD RESIDENCE
PROJECT TYPOLOGY	:	RESIDENCE
CLIENT	:	Mr. SHIVAKUMAR
LOCATION	:	YERCAUD
PROJECT STATUS	:	ON-GOING

NOTES:
This drawing is the property of designworks & cannot be used or reproduced any form without their written permission.

Any discrepancy should be brought to the notice of the architects.


Only written dimensions should be followed, the drawing is not to be scaled.

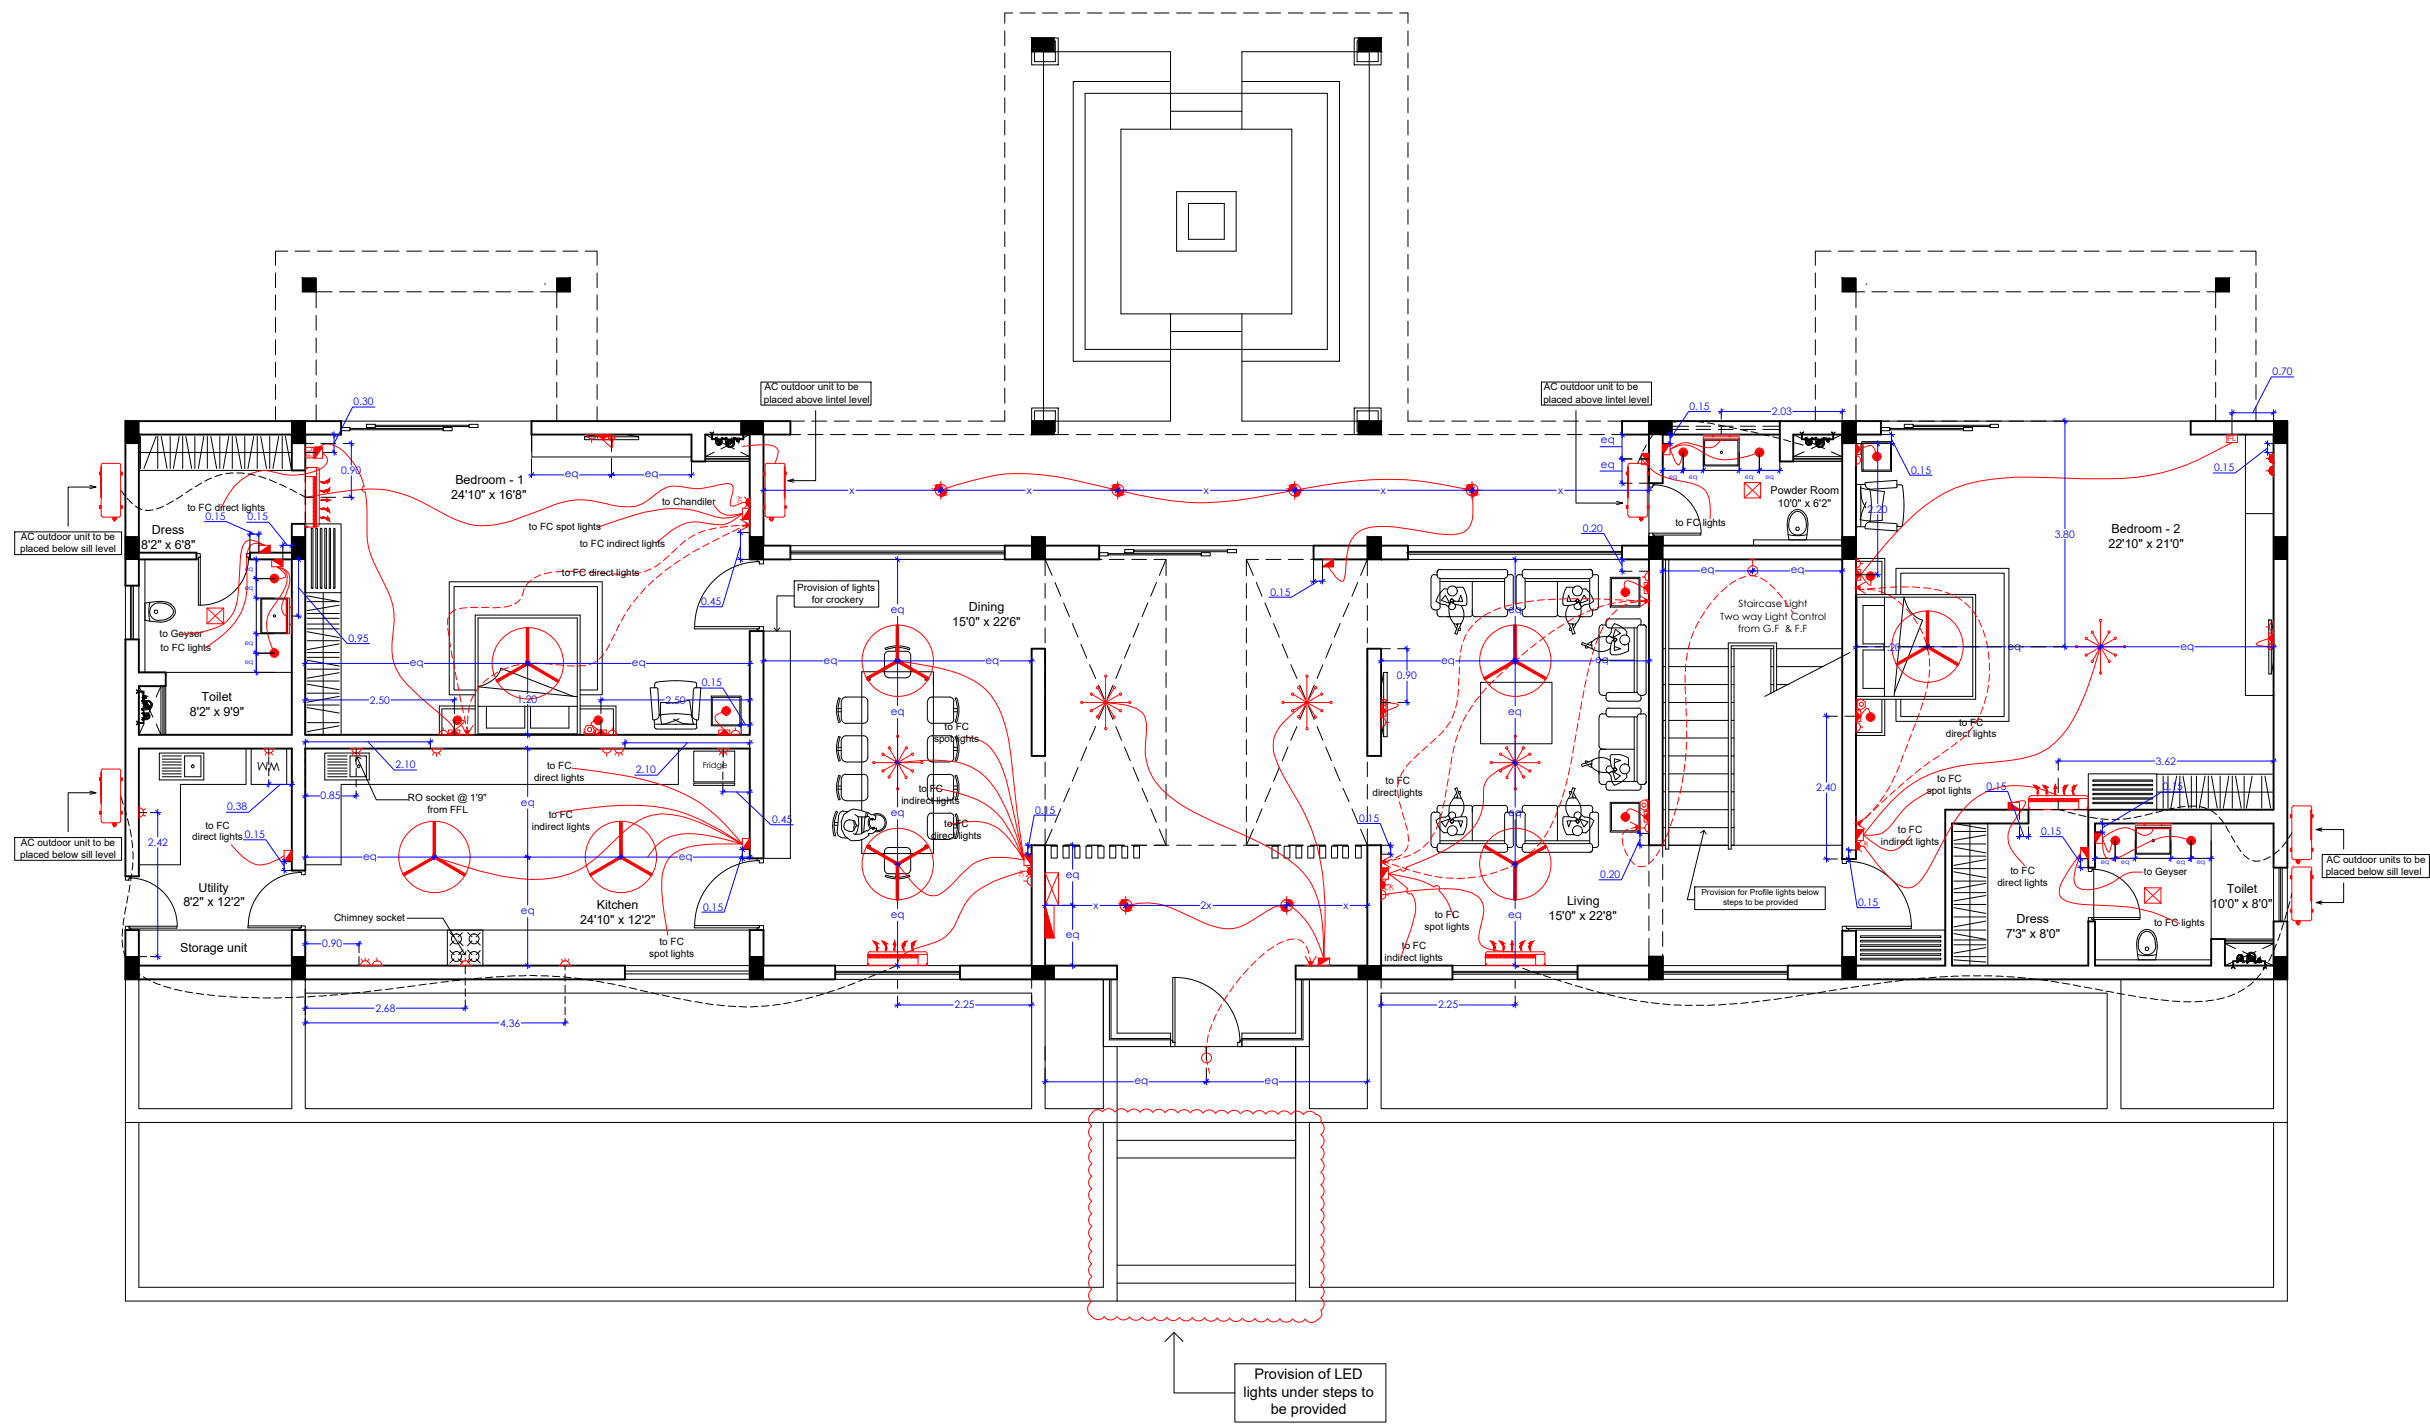

Provision of LED lights under steps to be provided

	DISTRIBUTION BOARD		CHANDLER LIGHT		SWITCH BOARD WITH 1No 5AMPS SOCKET @ 1'9" LVL		3/4" PVC PIPE electrical
	A/C INDOOR UNIT		FLOOR LAMP		SWITCH BOARD WITH 1No 5AMPS SOCKET @ 4'0" LVL		1" PVC PIPE electrical
	SUSPENDED LIGHT		15 AMPS Switch with Socket		AC Stabilizer		CEILING FAN
	TELEPHONE POINT		GEYSER 15 amp @ 9' HT		TWO WAY SWITCH CONTROL		A/C INDOOR UNIT
	MIRROR LIGHT		5 AMPS Switch with Socket		AC socket		
	T.V Point @ 4'6" Lvl 3" Pvc Pipe		5 AMPS Switch with Socket @ 1'9" LVL		WALL LIGHT		

NOTE : Need to provide a dummy switch in switch board in every room

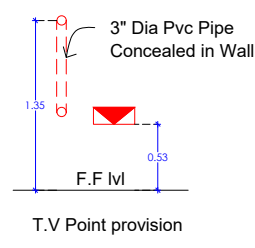

For Discussion	☐	Site Copy	☐
For Approval	☐	Clients Copy	☐
Good For Construction	☐	Contractors Copy	☐

Drawn : Durgaa	Scale : NTS	Date : 20.08/22
Checked : Rajesh	Sign :	dwg no:
File Path:		

drawing:
GROUND FLOOR PLAN - ELECTRICAL LAYOUT

project:
PROPOSED RESIDENTIAL DEVELOPMENT FOR
Mr. SHIVAKUMAR @ YERCAUD


DESIGNWORKS
Architects | Interior Designers | Planners

First Floor, 33.Ranjit Road,
kotturpuram, Chennai - 600 085, India
Tel: +91- 44 - 4230 3731/32/33
Fax: +91- 44 - 42303734
E-mail: mail@designworks.in
Web: www.designworks.in

NOTES:
This drawing is the property of designworks & cannot be used or reproduced any form without their written permission.


Any discrepancy should be brought to the notice of the architects.

Only written dimensions should be followed, the drawing is not to be scaled.

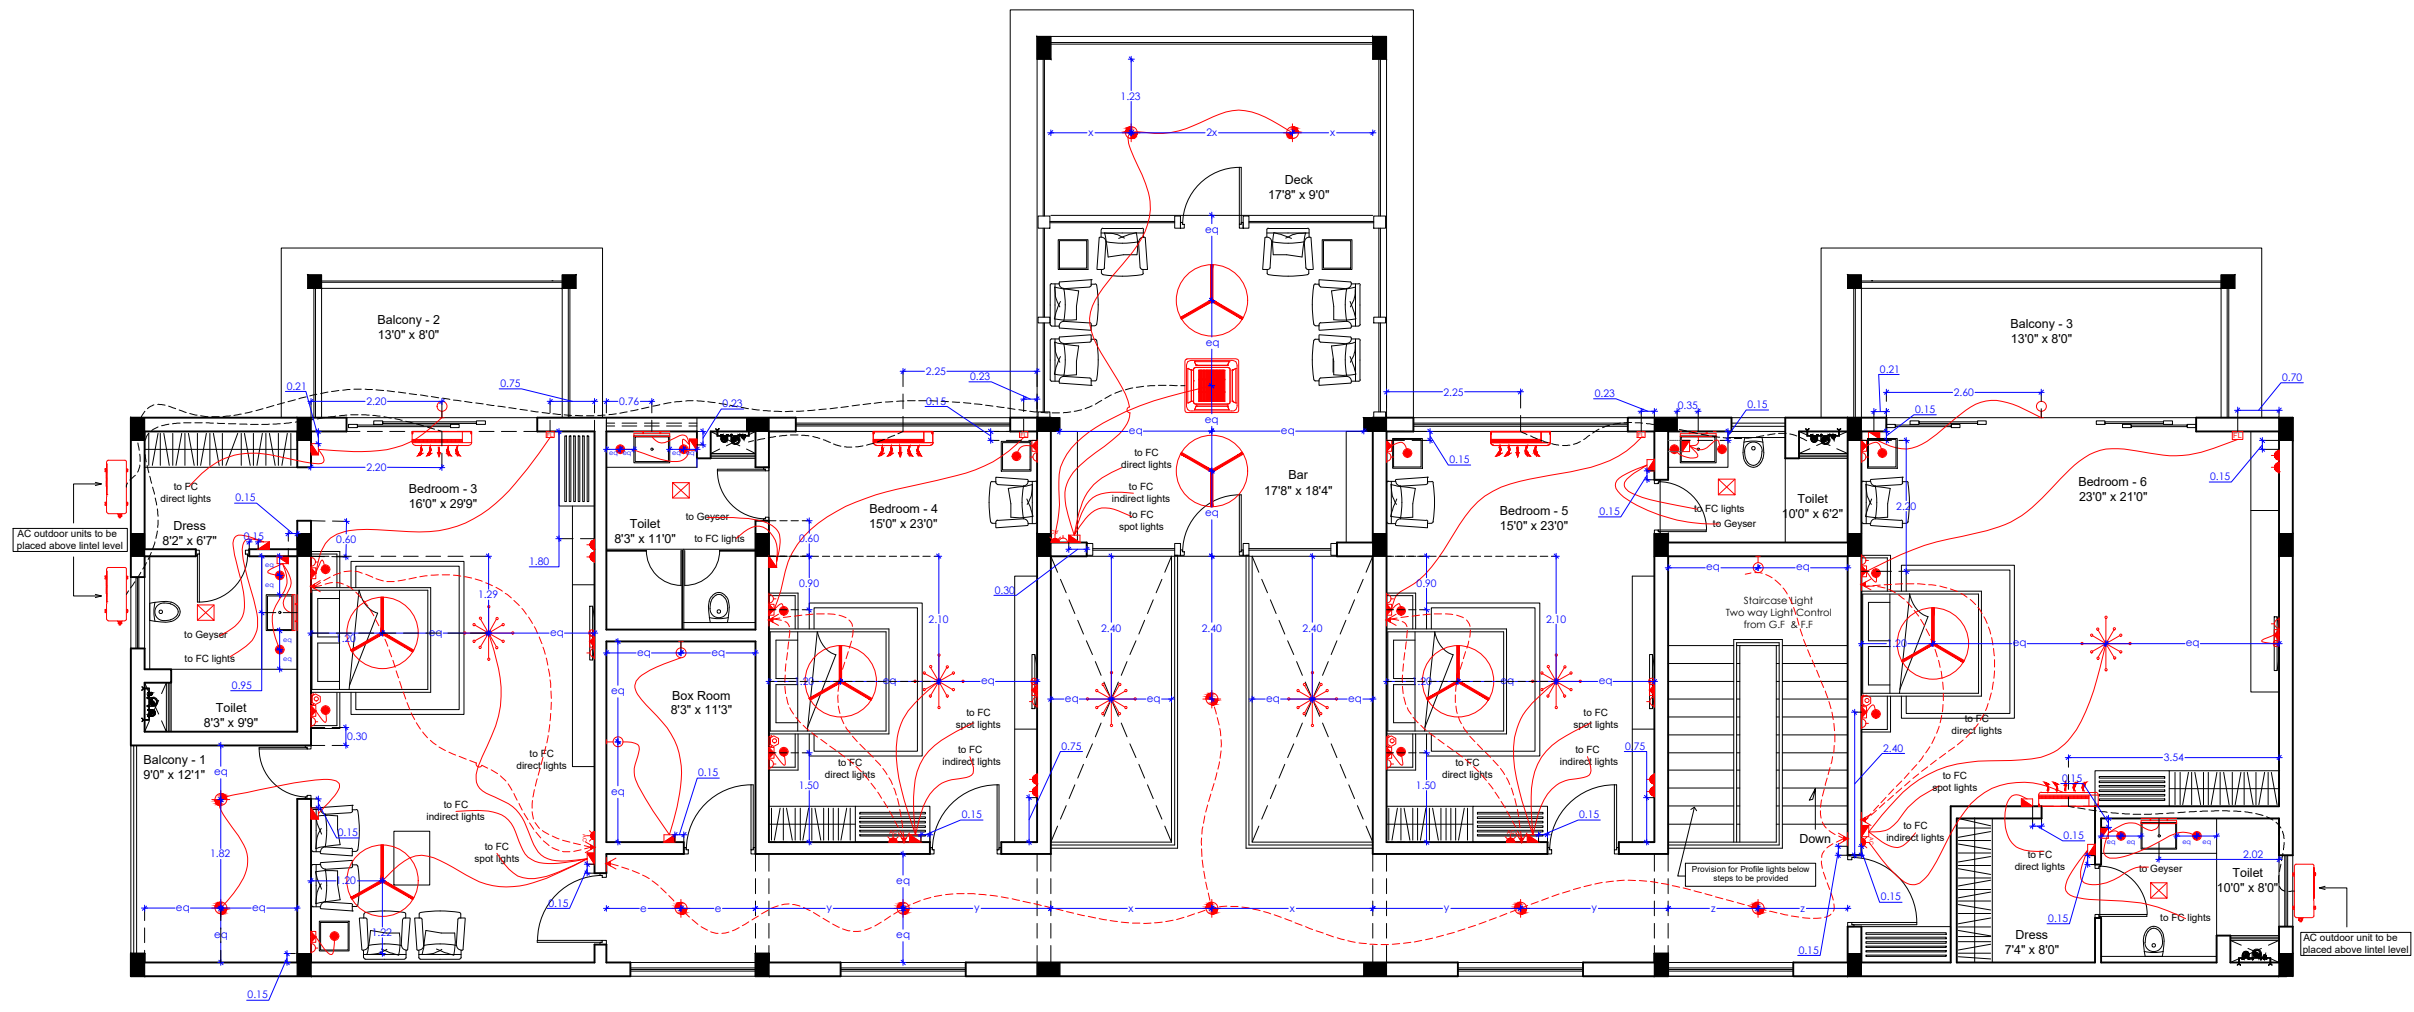

	DISTRIBUTION BOARD		CHANDLER LIGHT		SWITCH BOARD WITH 1No 5AMPS SOCKET @ 1'9" LVL		3/4" PVC PIPE electrical
	A/C INDOOR UNIT		FLOOR LAMP		SWITCH BOARD WITH 1No 5AMPS SOCKET @ 4'0" LVL		1" PVC PIPE electrical
	SUSPENDED LIGHT		15 AMPS Switch with Socket		AC Stabilizer		CEILING FAN
	TELEPHONE POINT		GEYSER 15 amp @ 9' HT		TWO WAY SWITCH CONTROL		A/C INDOOR UNIT
	MIRROR LIGHT		5 AMPS Switch with Socket		AC socket		
	T.V Point @ 4'6" Lvl 3" Pvc Pipe		5 AMPS Switch with Socket @ 1'9" LVL		WALL LIGHT		

NOTE : Need to provide a dummy switch in switch board in every room

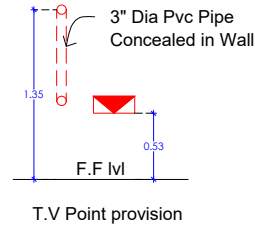

For Discussion	☐	Site Copy	☐
For Approval	☐	Clients Copy	☐
Good For Construction	☐	Contractors Copy	☐


Drawn : Durgaa	Scale : NTS	Date : 20.08/22
Checked : Rajesh	Sign :	dwg no:
File Path:		

drawing:
FIRST FLOOR PLAN -
ELECTRICAL LAYOUT


project:
PROPOSED RESIDENTIAL
DEVELOPMENT FOR
Mr. SHIVAKUMAR @ YERCAUD

DESIGNWORKS
Architects | Interior Designers | Planners


First Floor, 33.Ranjit Road,
kotturpuram, Chennai - 600 085, India
Tel: +91- 44 - 4230 3731/32/33
Fax: +91- 44 - 42303734
E-mail: mail@designworks.in
Web: www.designworks.in

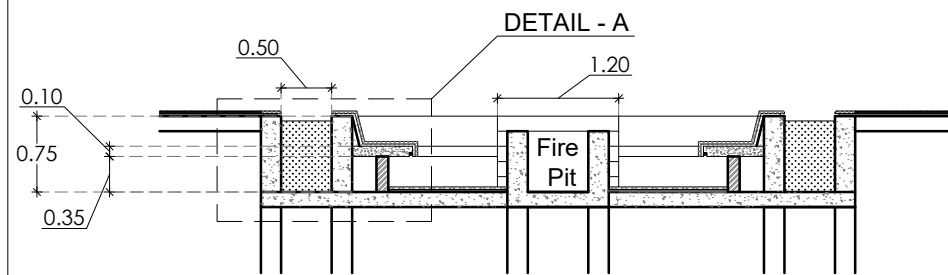


SECTION - AA

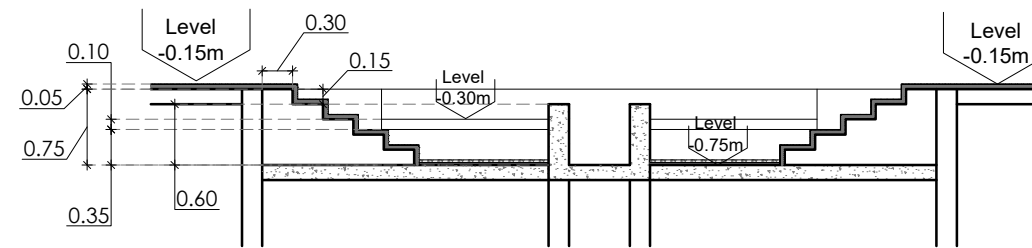

SECTION - BB

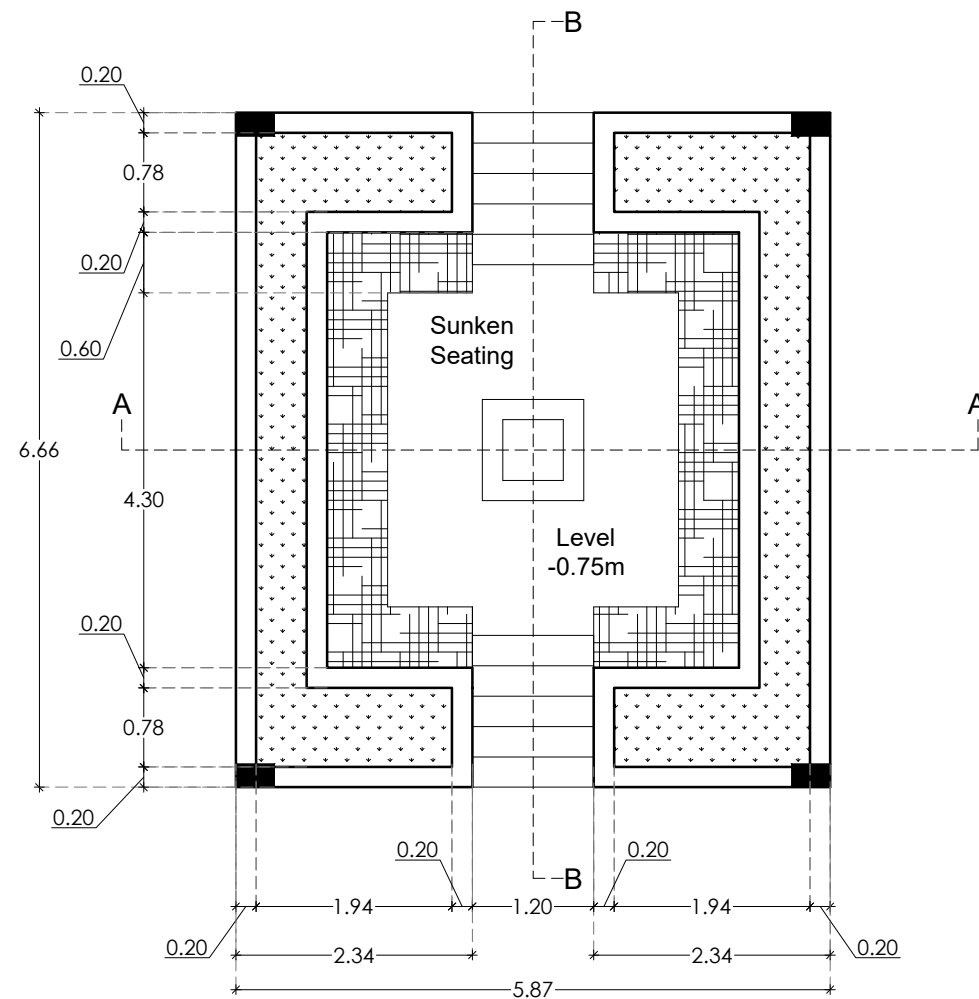

PLAN

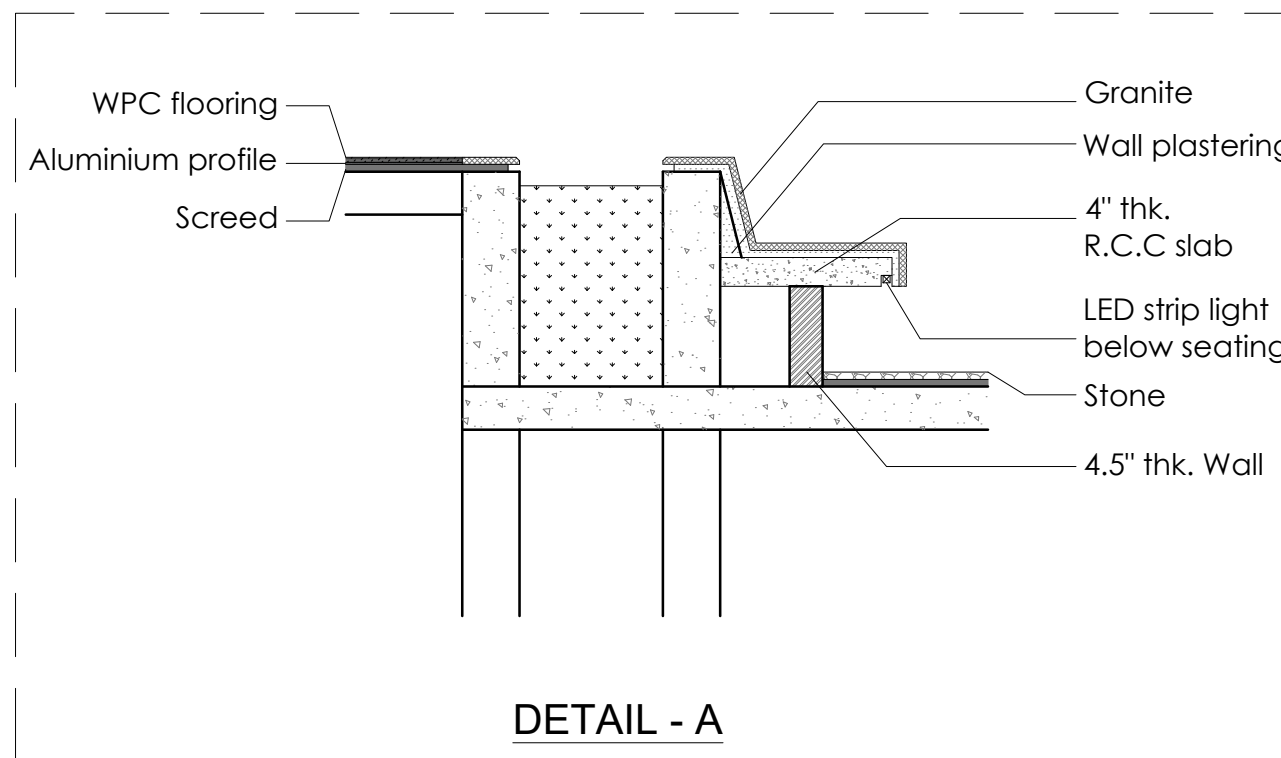

DETAIL - A

NOTES:
This drawing is the property of designworks & cannot be used or reproduced any form without their written permission.
Any discrepancy should be brought to the notice of the architects.
Only written dimensions should be followed, the drawing is not to be scaled.


For Discussion	☐	Site Copy	☐
For Approval	☐	Clients Copy	☐
Good For Construction	☐	Contractors Copy	☐

Drawn : Durgaa	Scale : NTS	Date: 21.09.22
Checked : RajeshH	dwg no:	
Sign :		
File Path:		


drawing:
SUNKEN SEATING DETAIL

project:
PROPOSED RESIDENTIAL
DEVELOPMENT FOR
MR. SHIVAKUMAR @ YERCAUD


DESIGNWORKS
Architects | Interior Designers | Planners
First Floor, 33,Ranjit Road,
kotturpuram, Chennai - 600 085, India
Tel: +91- 44 - 4230 3731/32/33
Fax: +91- 44 - 42303734
E-mail: mail@designworks.in
Web: www.designworks.in

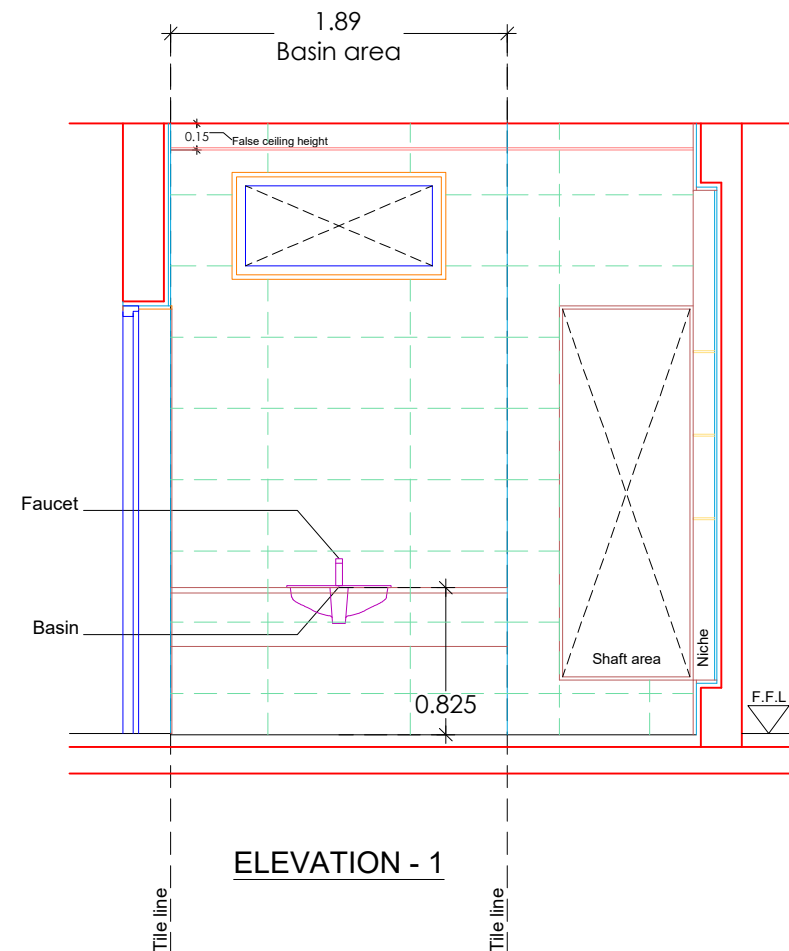


ELEVATION - 1

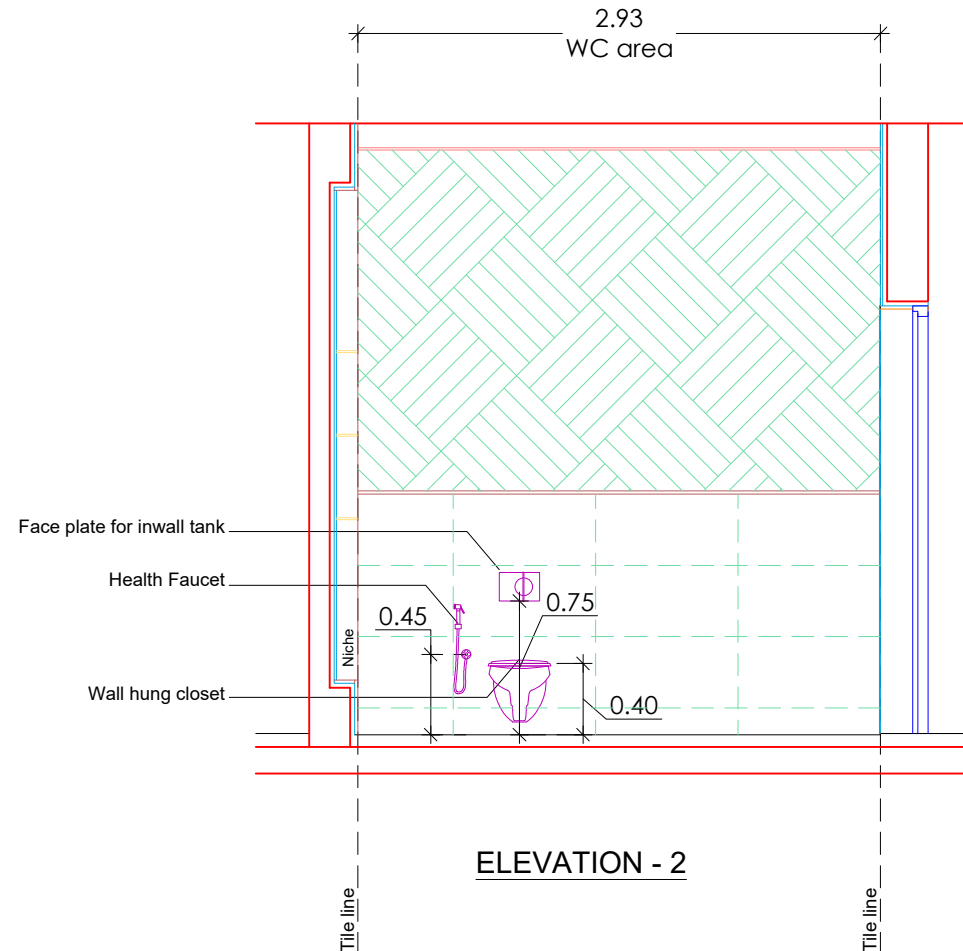

ELEVATION - 2

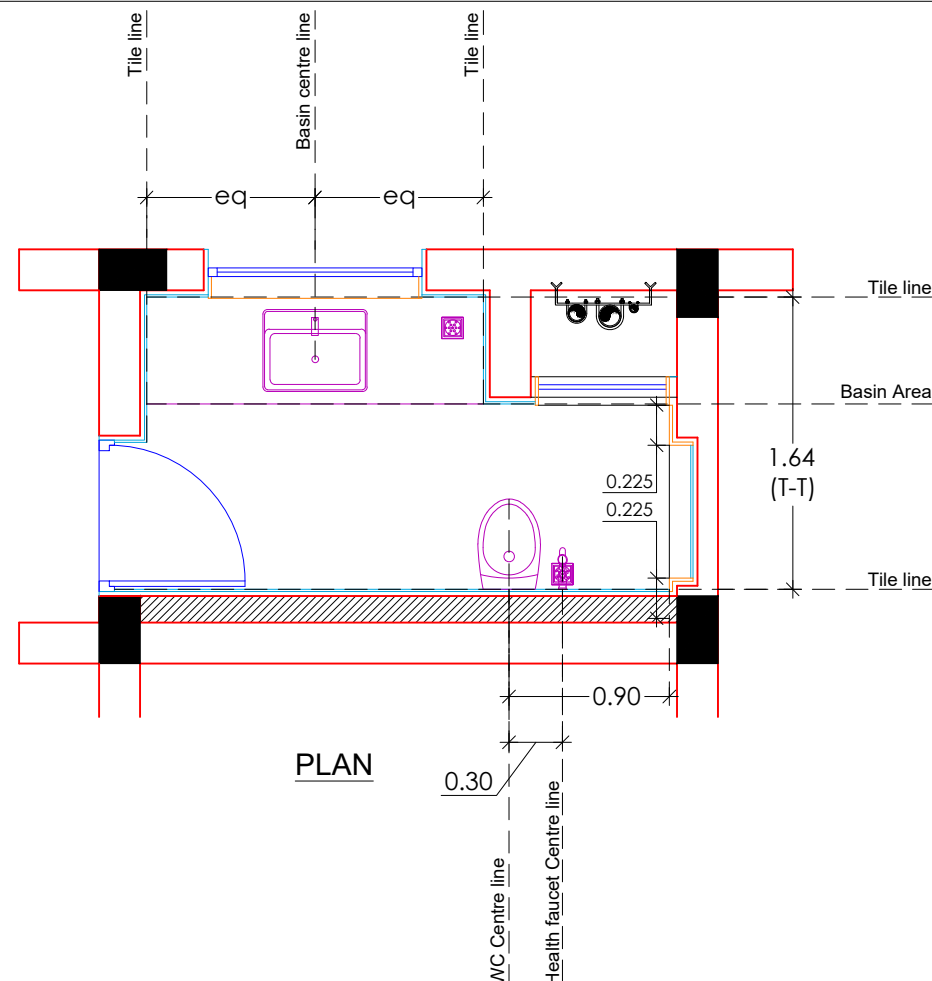

PLAN

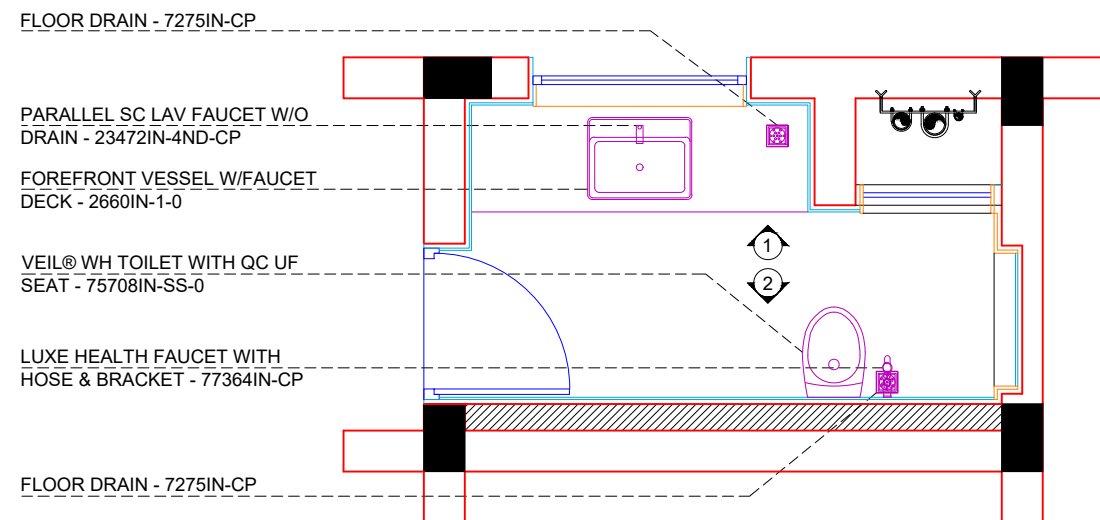

NOTES:
This drawing is the property of designworks & cannot be used or reproduced any form without their written permission.
Any discrepancy should be brought to the notice of the architects.
Only written dimensions should be followed, the drawing is not to be scaled.


For Discussion	☐	Site Copy	☐
For Approval	☐	Clients Copy	☐
Good For Construction	☐	Contractors Copy	☐

Drawn : Durgaa	Scale : NTS	Date : 29.09.22
Checked : Divya	dwg no:	
Sign :		


File Path:
drawing:
POWDER TOILET - PLUMBING LAYOUT

project:
PROPOSED RESIDENTIAL
DEVELOPMENT FOR
MR. SHIVAKUMAR @ YERCAUD


DESIGNWORKS
Architects | Interior Designers | Planners
First Floor, 33.Ranjit Road,
kotturpuram, Chennai - 600 085, India
Tel: +91- 44 - 4230 3731/32/33
Fax: +91- 44 - 42303734
E-mail: mail@designworks.in
Web: www.designworks.in

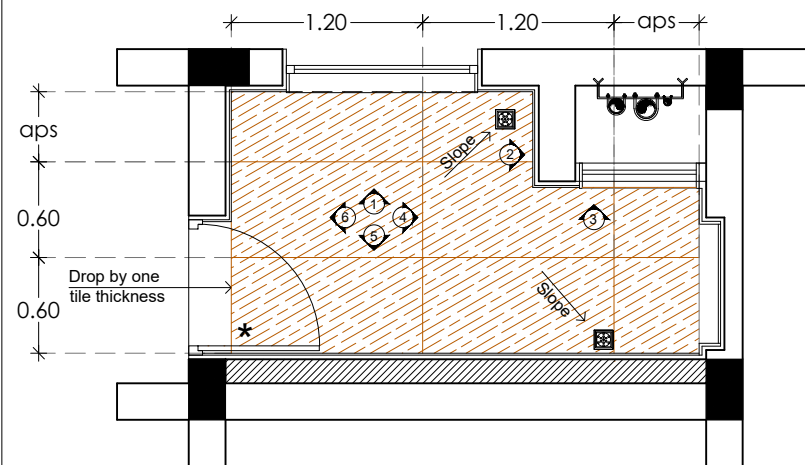


FLOORING TILE LAYOUT

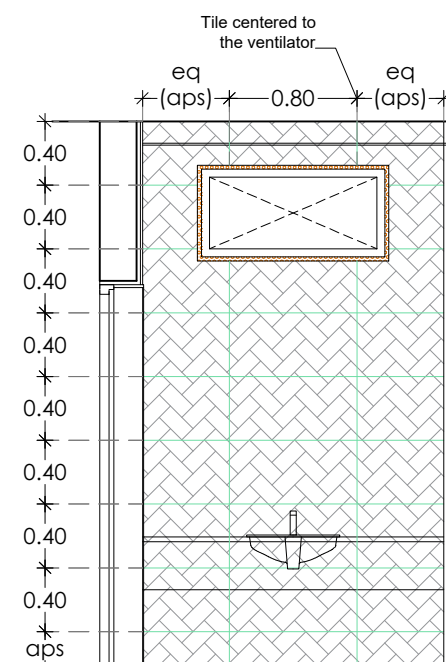


ELEVATION - 1

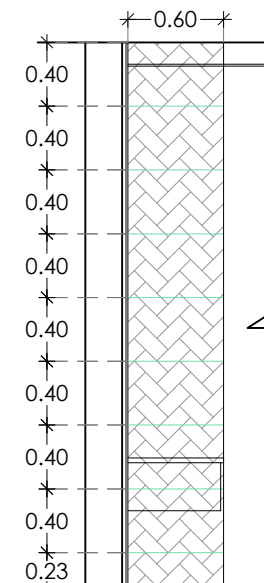

ELEVATION - 2

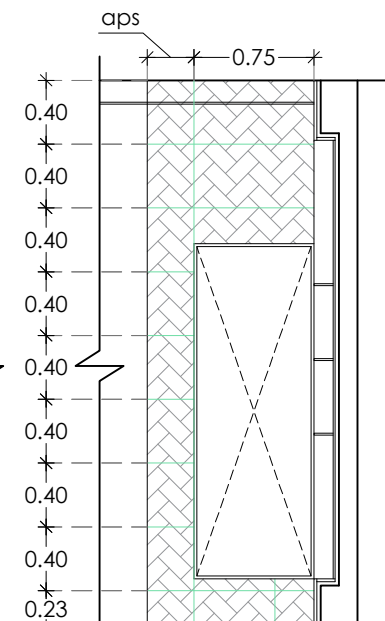

ELEVATION - 3

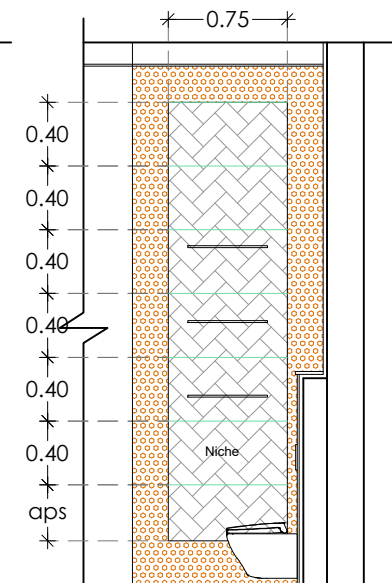

ELEVATION - 4



Wallpaper




Astoria Cement 400 X 800mm




Granite



Knightwood teak 600 x 1200mm

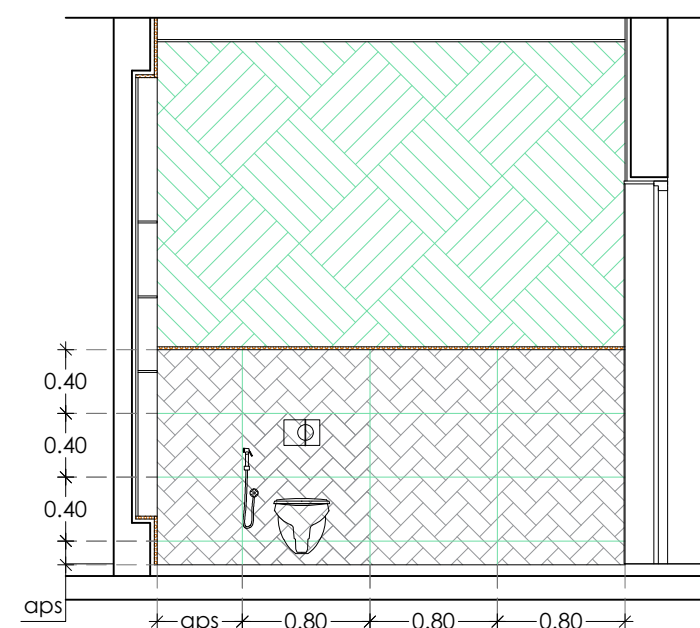

ELEVATION - 5

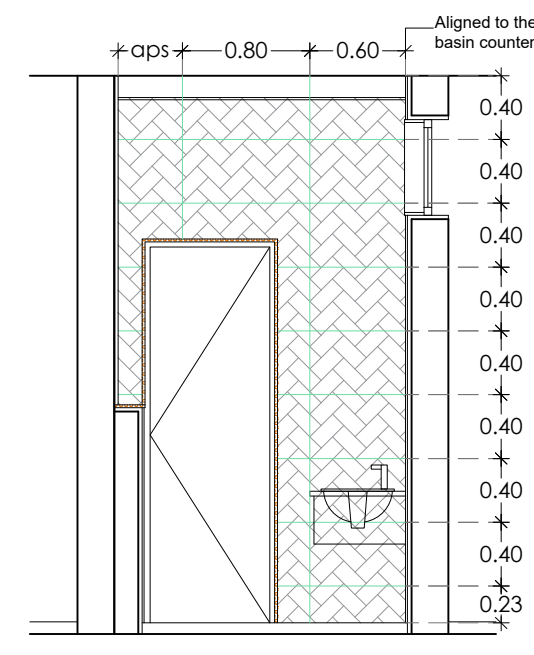

ELEVATION - 6

NOTES:
This drawing is the property of designworks & cannot be used or reproduced any form without their written permission.

Any discrepancy should be brought to the notice of the architects.

Only written dimensions should be followed, the drawing is not to be scaled.

For Discussion	☐	Site Copy	☐
For Approval	☐	Clients Copy	☐
Good For Construction	☐	Contractors Copy	☐

Drawn : Durgaa	Scale : NTS	Date: 29.09'22
Checked : Divya	dwg no :	
Sign :		


File Path:

drawing :
POWDER TOILET - TILE LAYOUT


project :
PROPOSED RESIDENTIAL
DEVELOPMENT FOR
Mr. SHIVAKUMAR @ YERCAUD

DESIGNWORKS
Architects | Interior Designers | Planners


First Floor, 33.Ranjit Road,
kotturpuram, Chennai - 600 085, India
Tel: +91- 44 - 4230 3731/32/33
Fax: +91- 44 - 42303734
E-mail: mail@designworks.in
Web: www.designworks.in

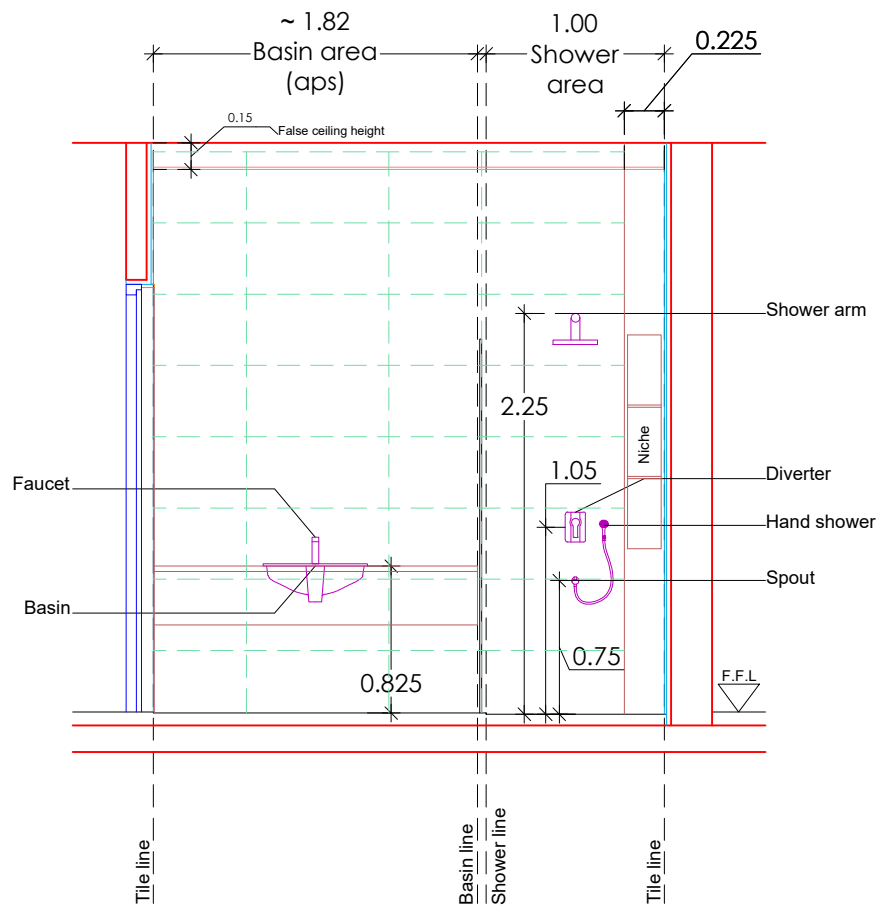


ELEVATION - 1

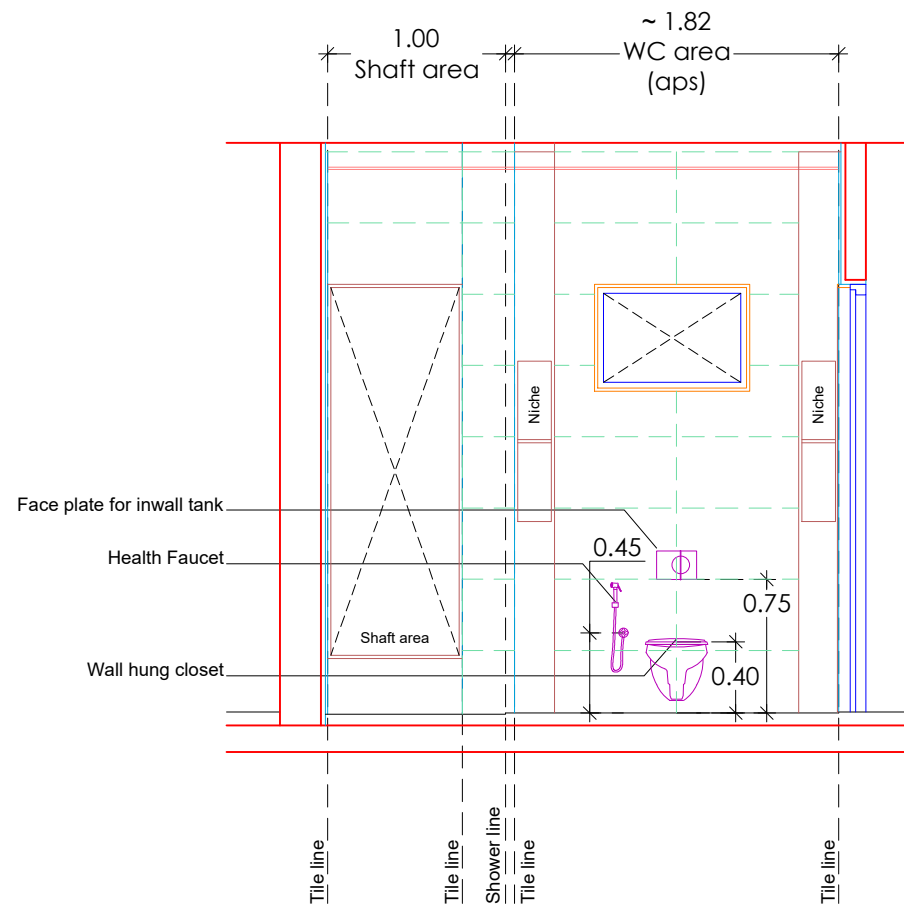

ELEVATION - 2

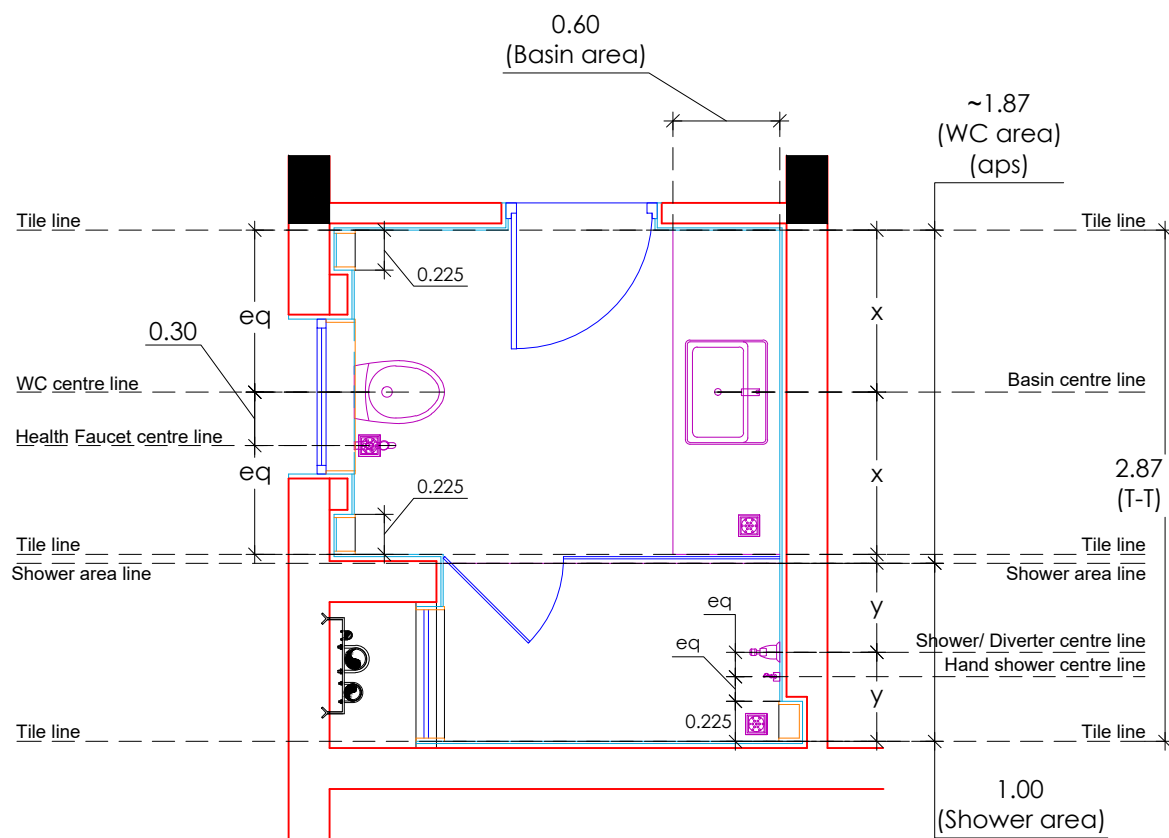

PLAN

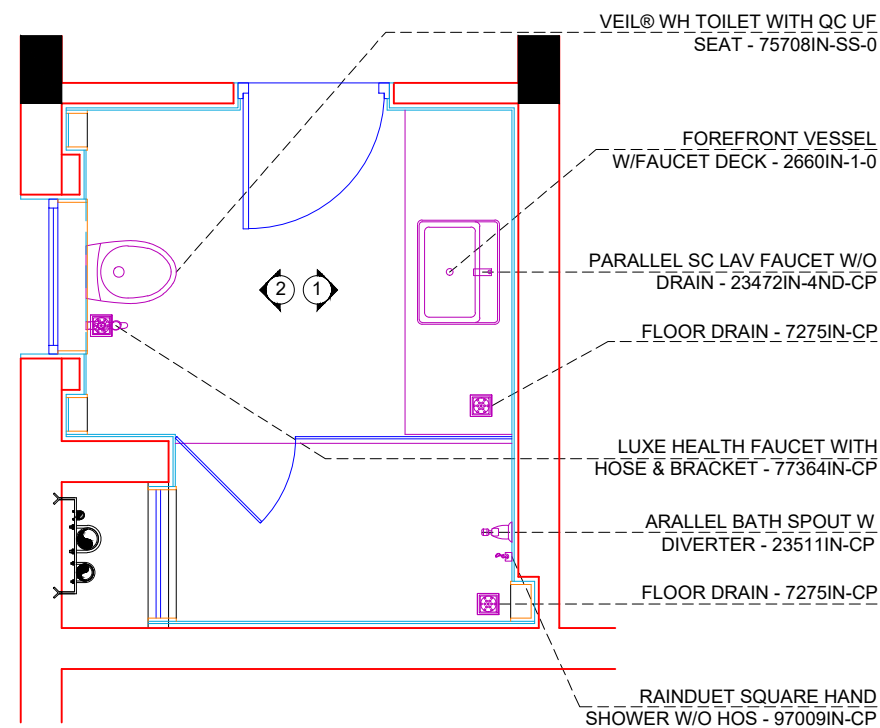

NOTES:
This drawing is the property of designworks & cannot be used or reproduced any form without their written permission.
Any discrepancy should be brought to the notice of the architects.
Only written dimensions should be followed, the drawing is not to be scaled.


For Discussion	☐	Site Copy	☐
For Approval	☐	Clients Copy	☐
Good For Construction	☐	Contractors Copy	☐

Drawn : Durgaa	Scale : NTS	Date: 29.09'22
Checked : Divya	dwg no :	
Sign :		


File Path:
drawing :
TOILET 1 - PLUMBING LAYOUT

project :
PROPOSED RESIDENTIAL
DEVELOPMENT FOR
Mr. SHIVAKUMAR @ YERCAUD


DESIGNWORKS
Architects | Interior Designers | Planners
First Floor, 33, Ranjit Road,
Kotturpuram, Chennai - 600 085, India
Tel: +91- 44 - 4230 3731/32/33
Fax: +91- 44 - 42303734
E-mail: mail@designworks.in
Web: www.designworks.in

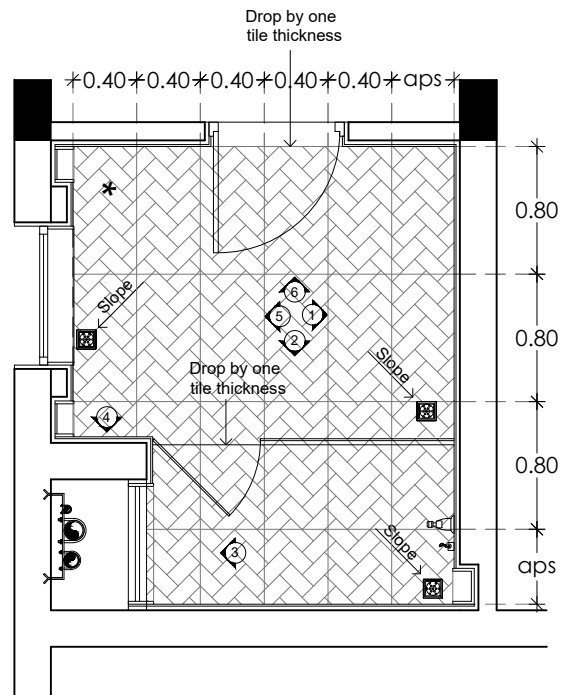


FLOORING TILE LAYOUT

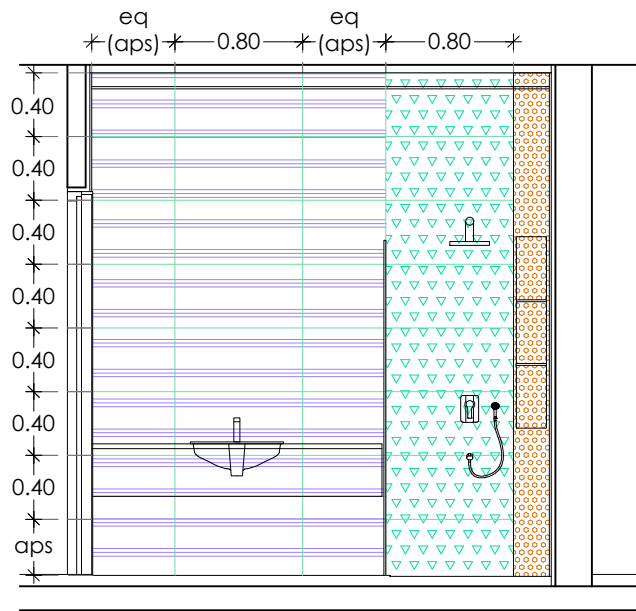

ELEVATION - 1

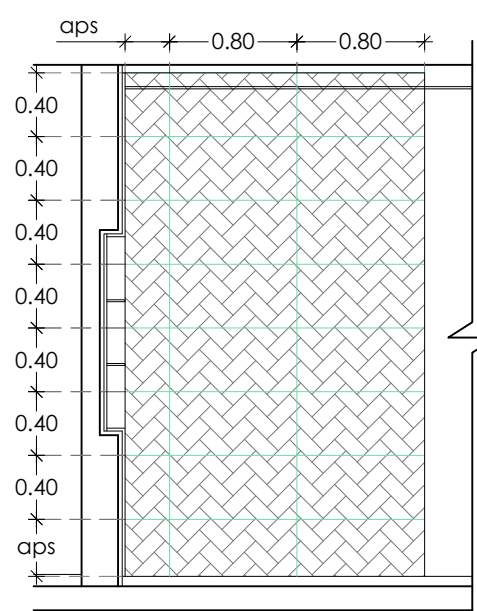


ELEVATION - 2

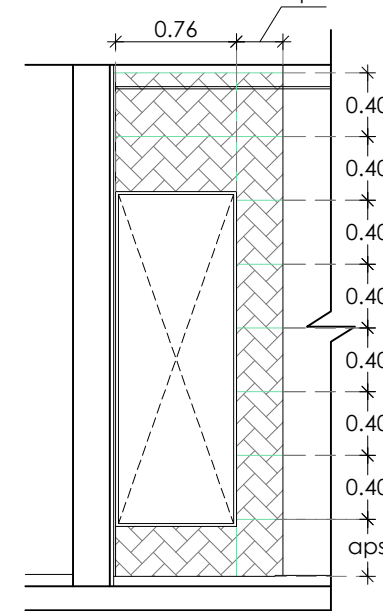


ELEVATION - 3



 
Astoria Gris 400 X 800mm




Astoria Cement 400 X 800mm

 


Granite

 


Astoria Decor 400 x 800mm

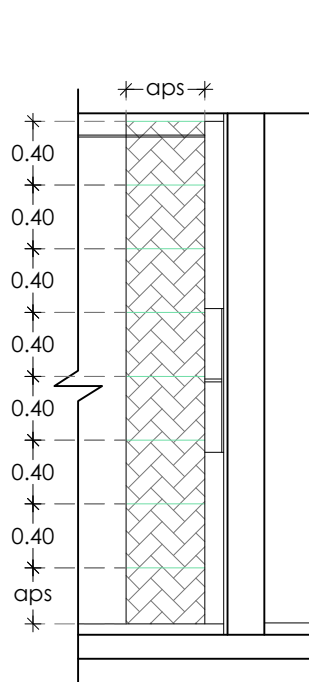

ELEVATION - 4

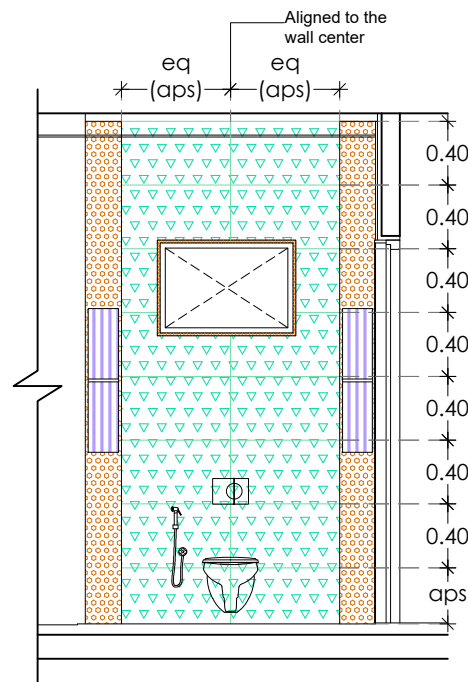

ELEVATION - 5

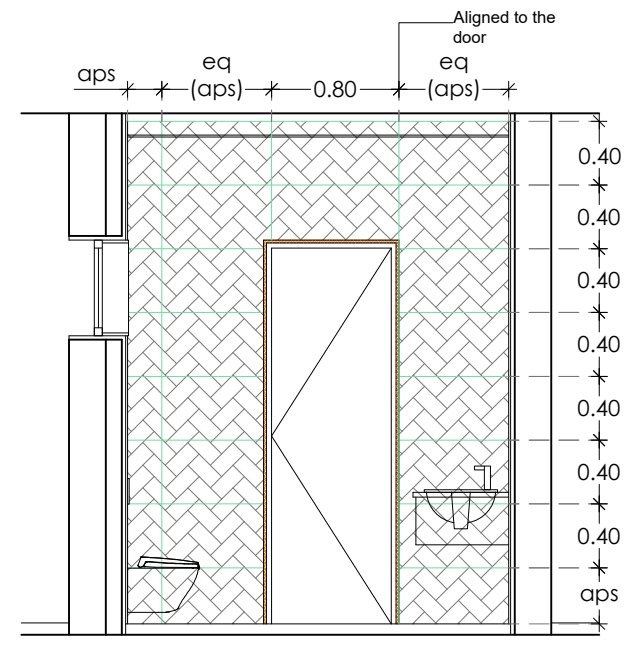

ELEVATION - 6

NOTES:
This drawing is the property of designworks & cannot be used or reproduced any form without their written permission.

Any discrepancy should be brought to the notice of the architects.

Only written dimensions should be followed, the drawing is not to be scaled.

For Discussion	☐	Site Copy	☐
For Approval	☐	Clients Copy	☐
Good For Construction	☐	Contractors Copy	☐


Drawn : Durgaa	Scale : NTS	Date : 29.09.22
Checked : Divya	dwg no :	
Sign :		
File Path:		

drawing :
TOILET 1 - TILE LAYOUT


project :
PROPOSED RESIDENTIAL
DEVELOPMENT FOR
Mr. SHIVAKUMAR @ YERCAUD

DESIGNWORKS
Architects | Interior Designers | Planners


First Floor, 33.Ranjit Road,
kotturpuram, Chennai - 600 085, India
Tel: +91- 44 - 4230 3731/32/33
Fax: +91- 44 - 42303734
E-mail: mail@designworks.in
Web: www.designworks.in

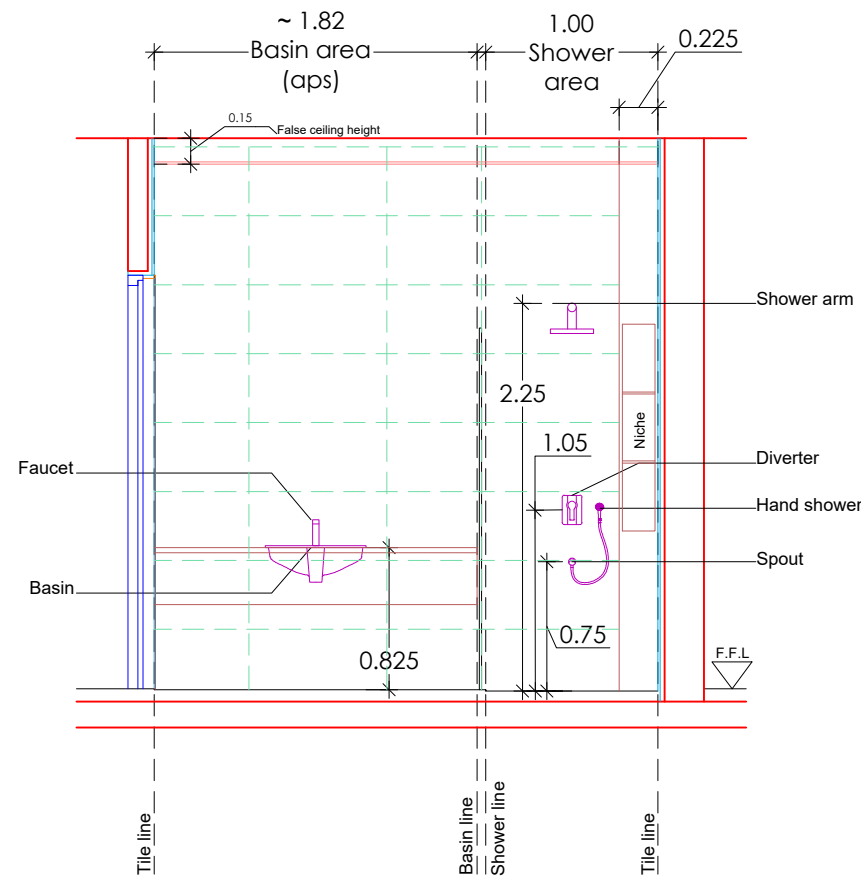

ELEVATION - 1

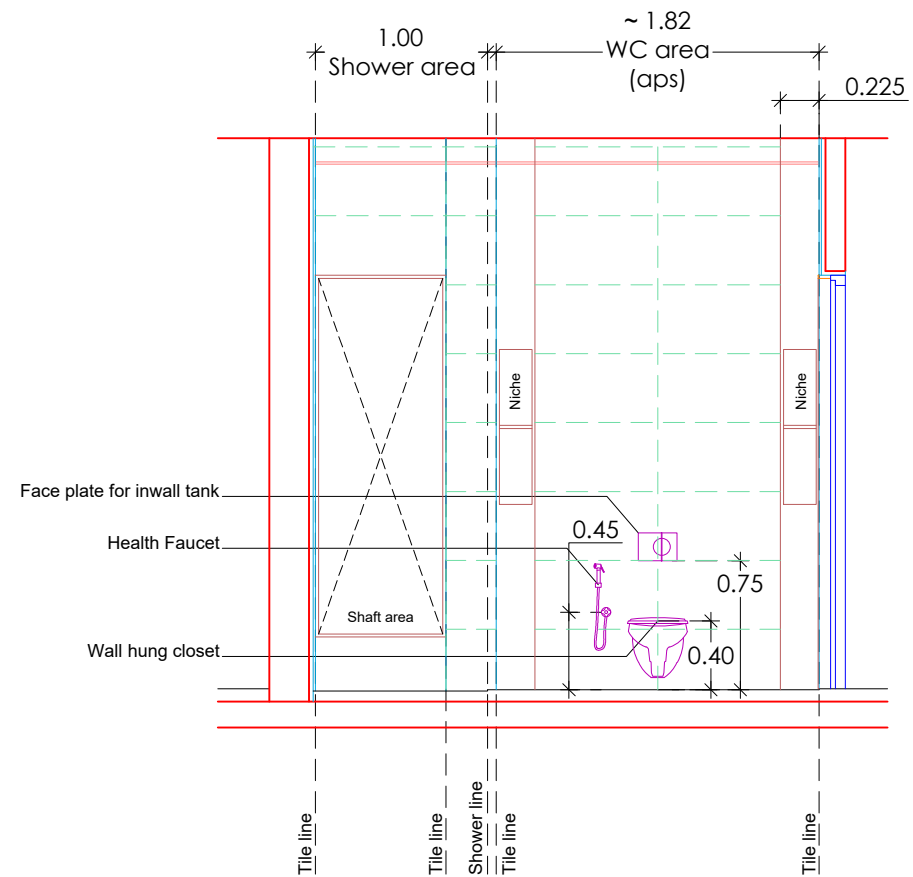

ELEVATION - 2

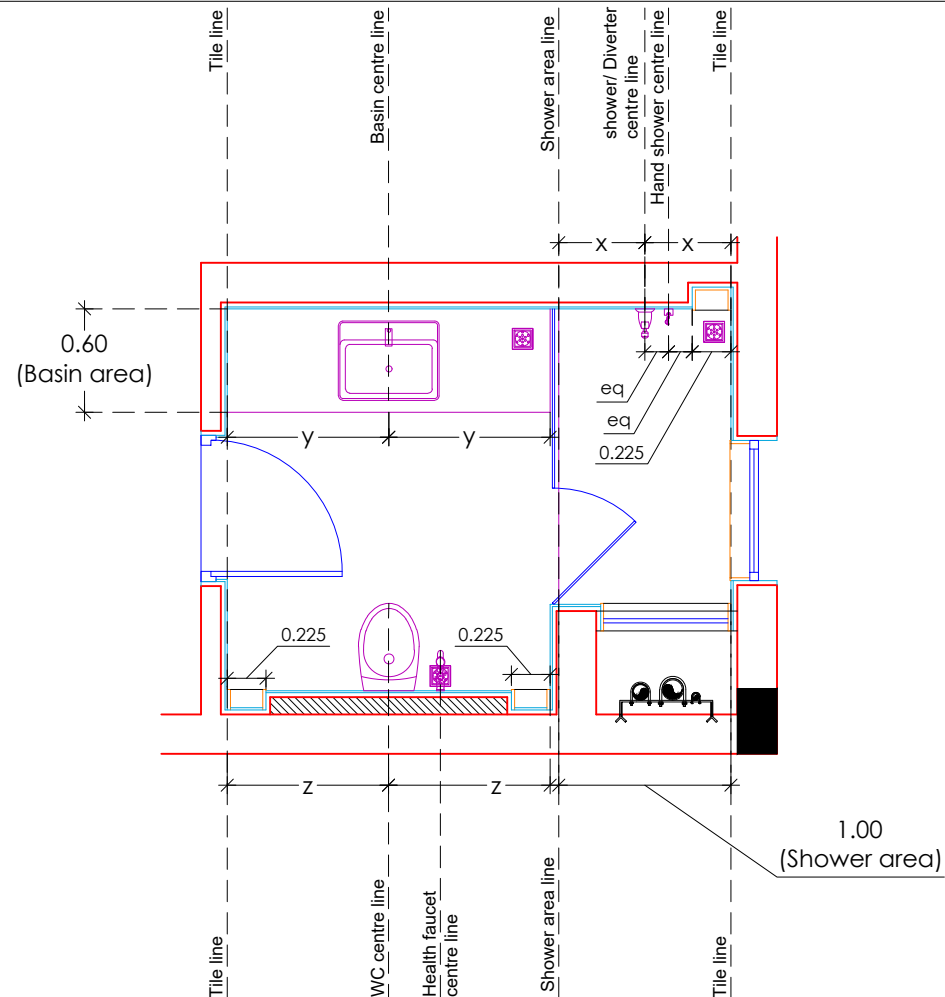

ARALLEL BATH SPOUT W/
DIVERTER - 23511IN-CP

FLOOR DRAIN - 7275IN-CP

PARALLEL SC LAV FAUCET W/O
DRAIN - 23472IN-4ND-CP

FOREFRONT VESSEL W/FAUCET
DECK - 2660IN-1-0

RAINDUET SQUARE HAND
SHOWER W/O HOS - 97009IN-CP

VEIL® WH TOILET WITH QC UF
SEAT - 75708IN-SS-0

LUXE HEALTH FAUCET WITH
HOSE & BRACKET - 77364IN-CP

FLOOR DRAIN - 7275IN-CP

NOTES:
This drawing is the property of
designworks & cannot be used or
reproduced any form without their
written permission.

Any discrepancy should be brought
to the notice of the architects.

Only written dimensions should be
followed, the drawing is not to be
scaled.

For Discussion	☐	Site Copy	☐
For Approval	☐	Clients Copy	☐
Good For Construction	☐	Contractors Copy	☐


Drawn : Durgaa	Scale : NTS	Date: 29.09'22
Checked : Divya Sign :	dwg no :	
File Path:		

drawing :
TOILET 2 - PLUMBING LAYOUT


project :
PROPOSED RESIDENTIAL
DEVELOPMENT FOR
Mr. SHIVAKUMAR @ YERCAUD

DESIGNWORKS
Architects | Interior Designers | Planners


First Floor, 33.Ranjit Road,
kotturpuram, Chennai - 600 085, India
Tel: +91- 44 - 4230 3731/32/33
Fax: +91- 44 - 42303734
E-mail: mail@designworks.in
Web: www.designworks.in

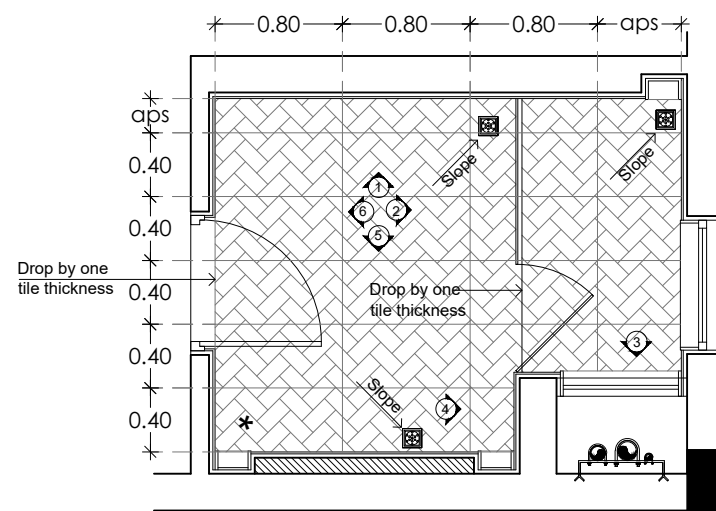


FLOORING TILE LAYOUT

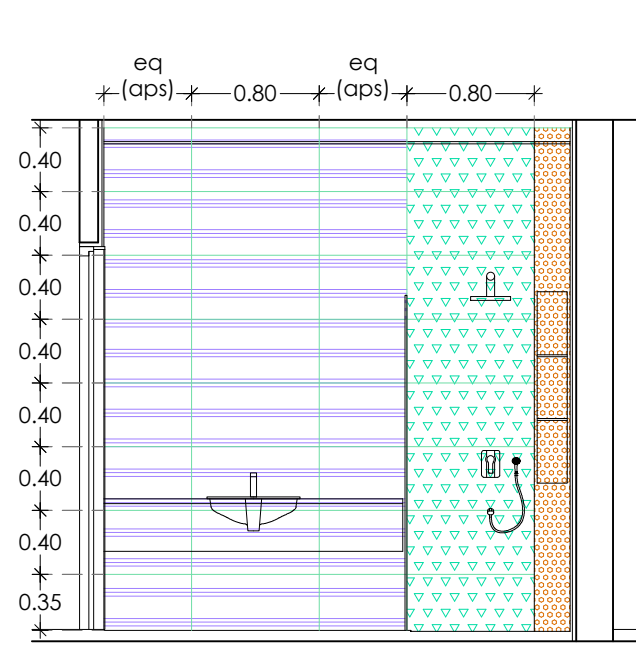

ELEVATION - 1

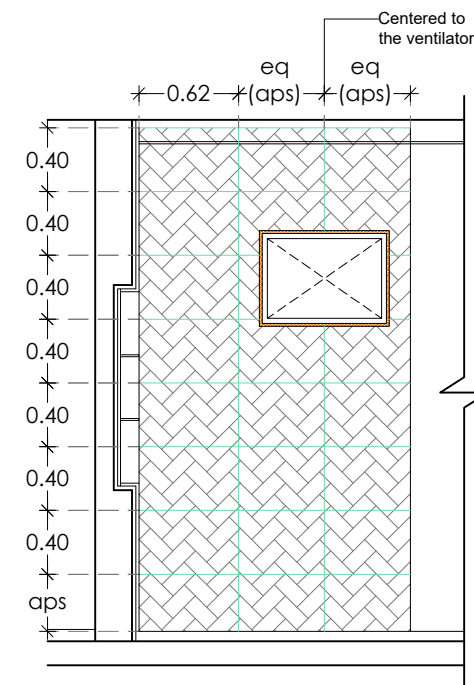

ELEVATION - 2

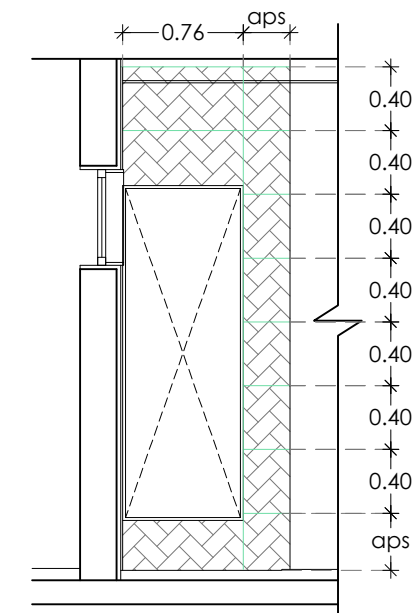

ELEVATION - 3



 
Astoria Gris 400 X 800mm




Astoria Cement 400 X 800mm




Granite




Astoria Decor 400 x 800mm

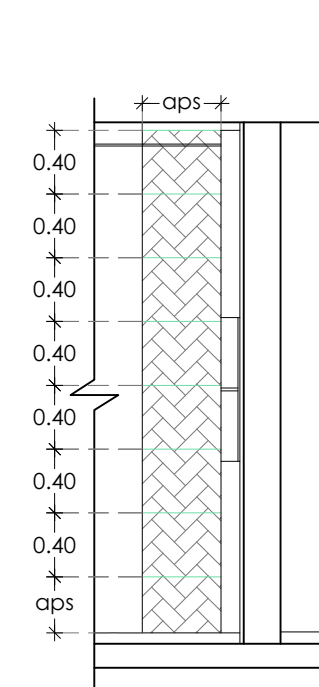

ELEVATION - 4

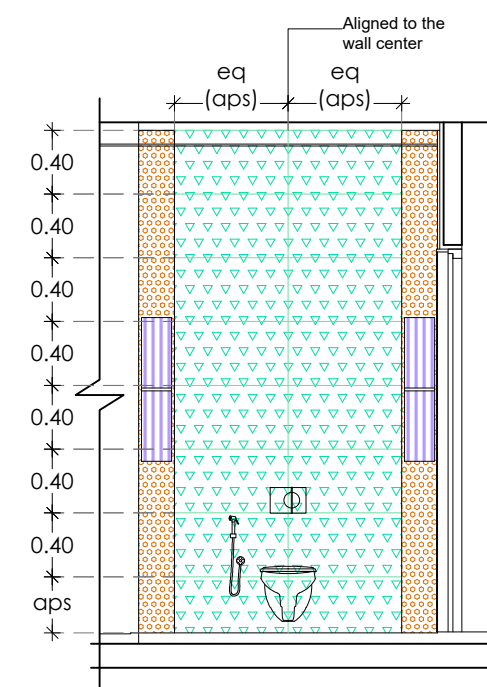

ELEVATION - 5

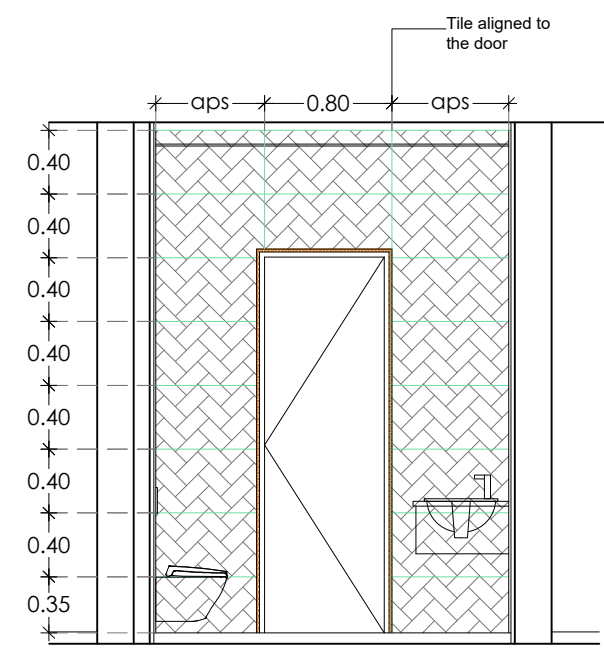

ELEVATION - 6

NOTES:
This drawing is the property of designworks & cannot be used or reproduced any form without their written permission.

Any discrepancy should be brought to the notice of the architects.

Only written dimensions should be followed, the drawing is not to be scaled.


For Discussion	☐ Site Copy	☐
For Approval	☐ Clients Copy	☐
Good For Construction	☐ Contractors Copy	☐

Drawn : Durgaa	Scale : NTS	Date: 29.09'22
Checked : Divya	dwg no :	
Sign :		
File Path:		


drawing :
TOILET 2 - TILE LAYOUT

project :
PROPOSED RESIDENTIAL
DEVELOPMENT FOR
Mr. SHIVAKUMAR @ YERCAUD


DESIGNWORKS
Architects | Interior Designers | Planners
First Floor, 33.Ranjit Road,
kotturpuram, Chennai - 600 085, India
Tel: +91- 44 - 4230 3731/32/33
Fax: +91- 44 - 42303734
E-mail: mail@designworks.in
Web: www.designworks.in

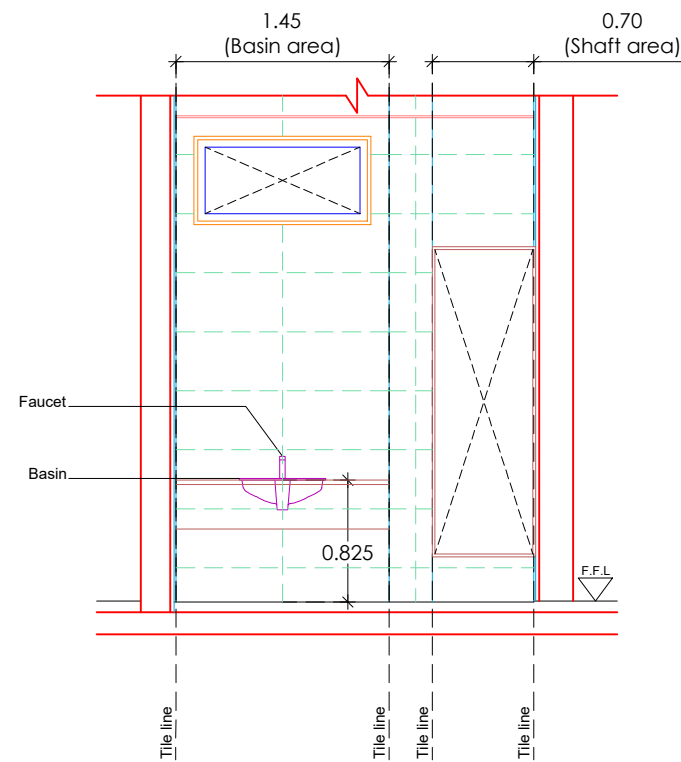


ELEVATION - 1

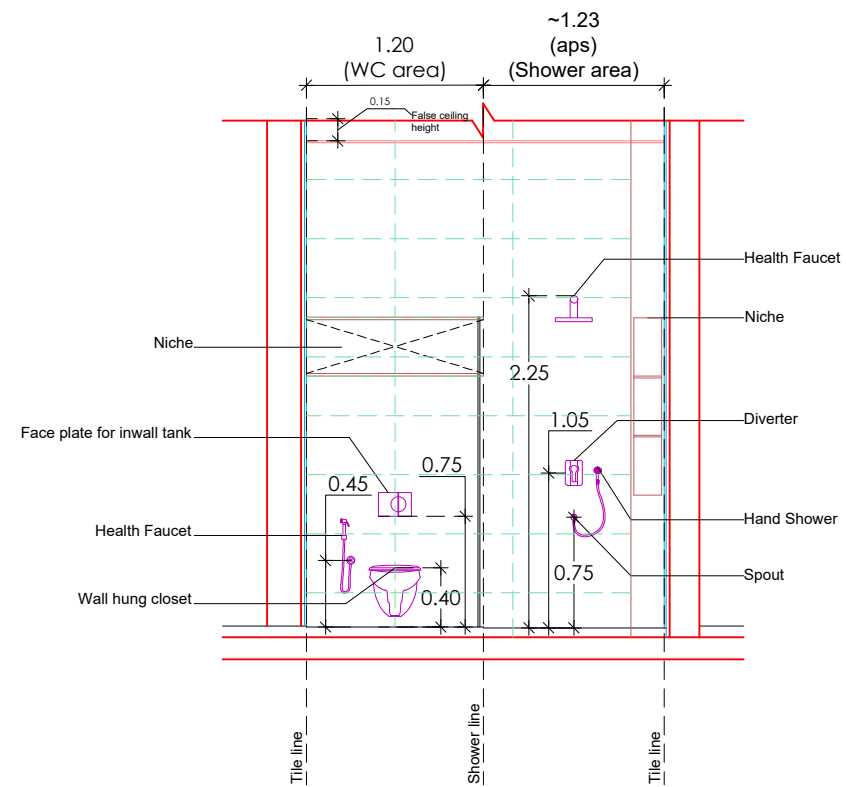

ELEVATION - 2

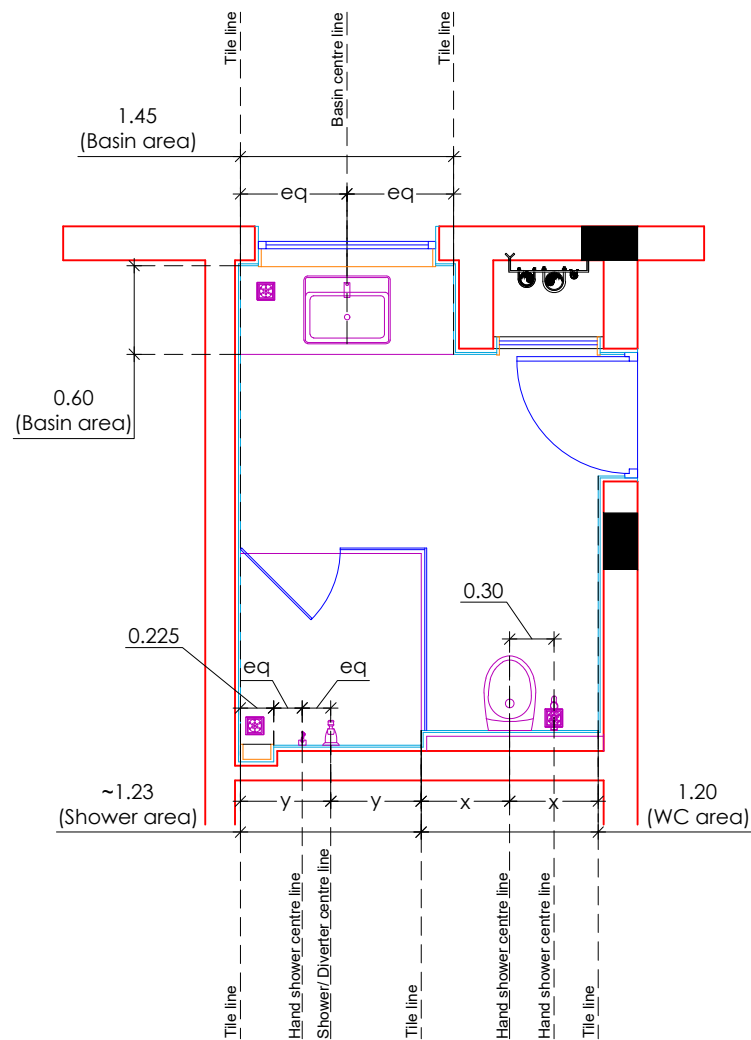

PLAN

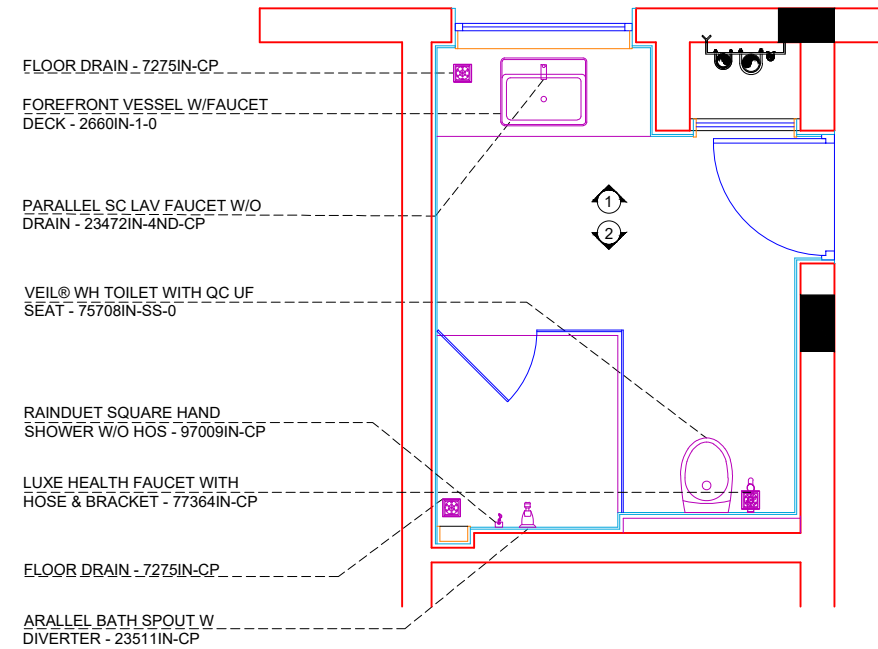

NOTES:
This drawing is the property of designworks & cannot be used or reproduced any form without their written permission.

Any discrepancy should be brought to the notice of the architects.

Only written dimensions should be followed, the drawing is not to be scaled.

For Discussion	☐	Site Copy	☐
For Approval	☐	Clients Copy	☐
Good For Construction	☐	Contractors Copy	☐





Drawn : Durgaa	Scale : NTS	Date: 29.09'22
Checked : Divya Sign :	dwg no :	
File Path:		

drawing :
TOILET 4 - PLUMBING LAYOUT

project :
PROPOSED RESIDENTIAL
DEVELOPMENT FOR
Mr. SHIVAKUMAR @ YERCAUD

DESIGNWORKS
Architects | Interior Designers | Planners

First Floor, 33.Ranjit Road,
kotturpuram, Chennai - 600 085, India
Tel: +91- 44 - 4230 3731/32/33
Fax: +91- 44 - 42303734
E-mail: mail@designworks.in
Web: www.designworks.in

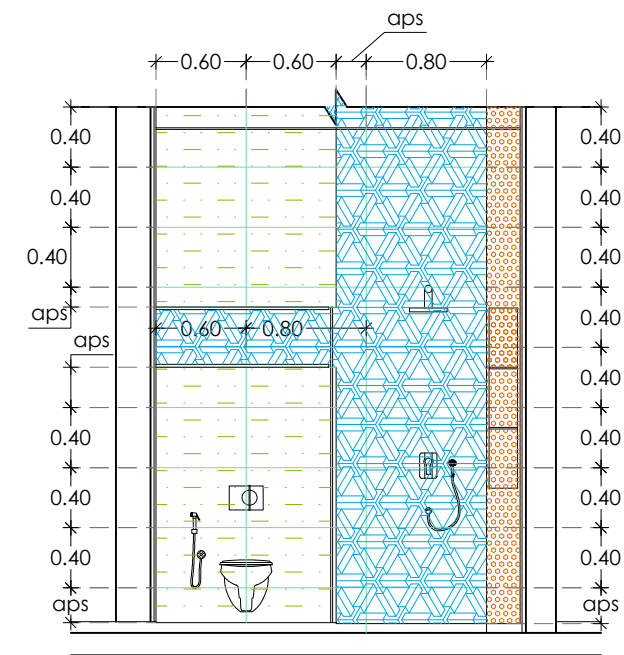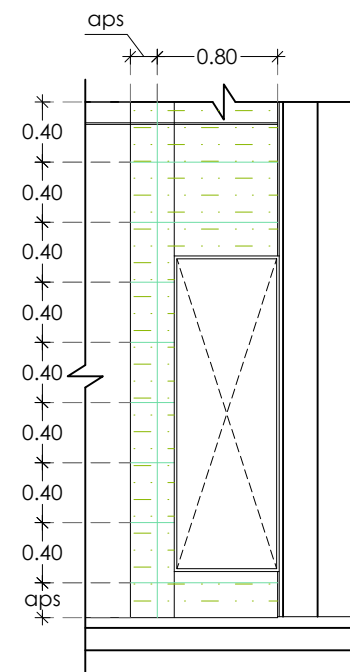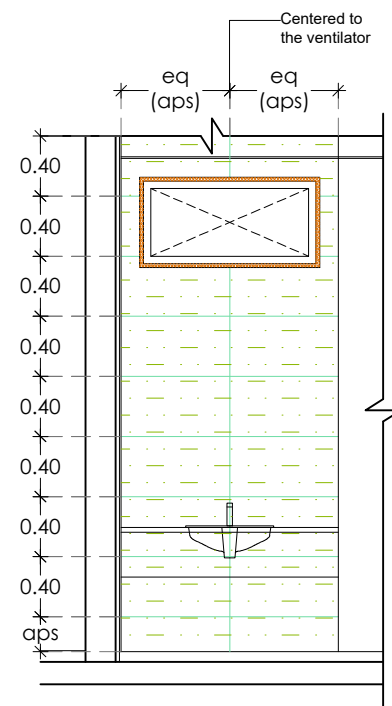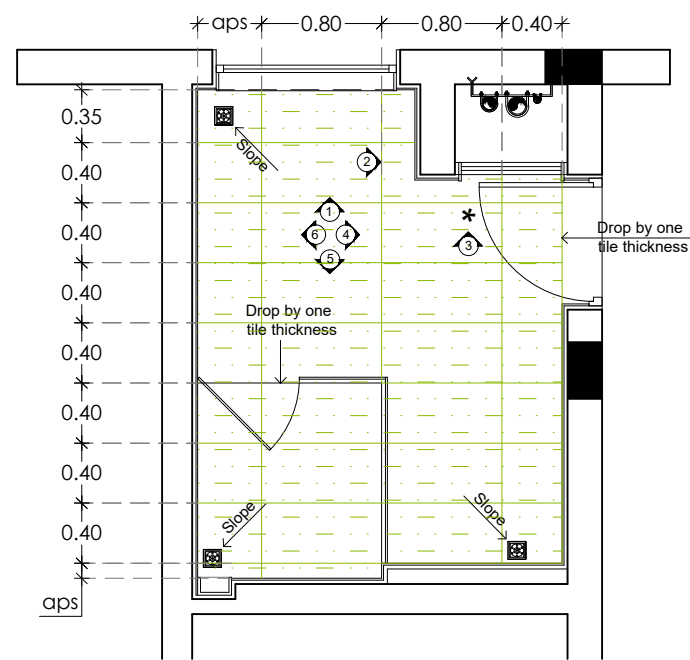

NOTES:

 
NOTES:
This drawing is the property of
designworks & cannot be used or
reproduced any form without their
written permission.

Any discrepancy should be brought to the notice of the architects.


Only written dimensions should be followed, the drawing is not to be scaled.






Munich Mist 400 X 800mm



Cantera Decor 400 X 800mm

 

Granite

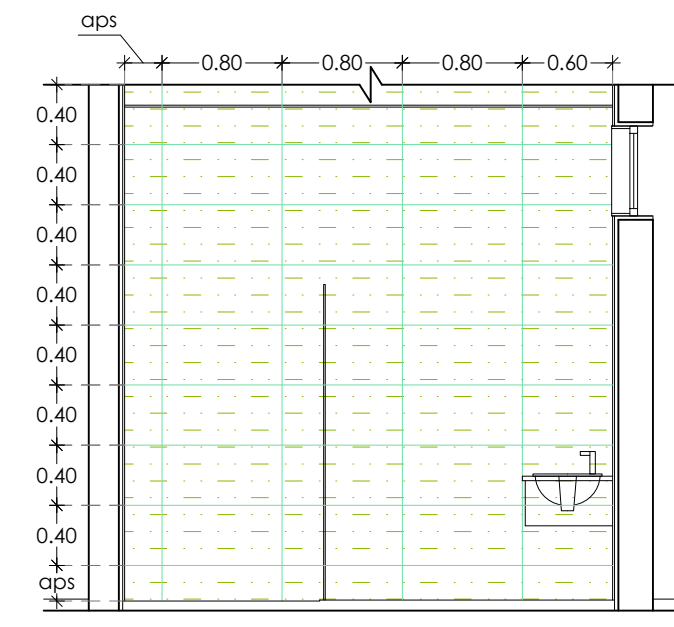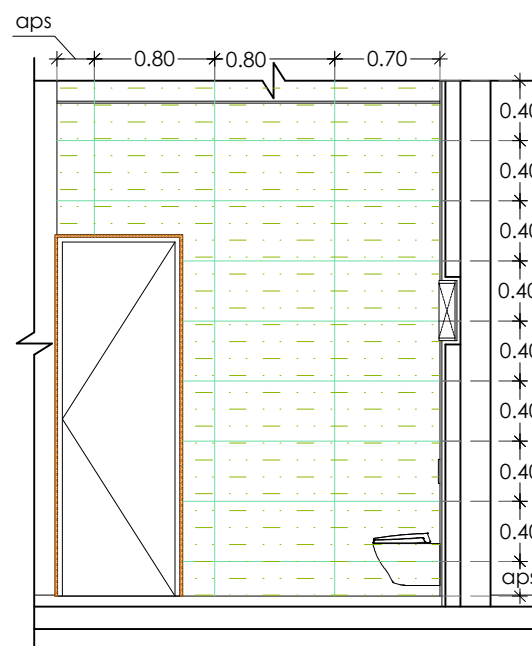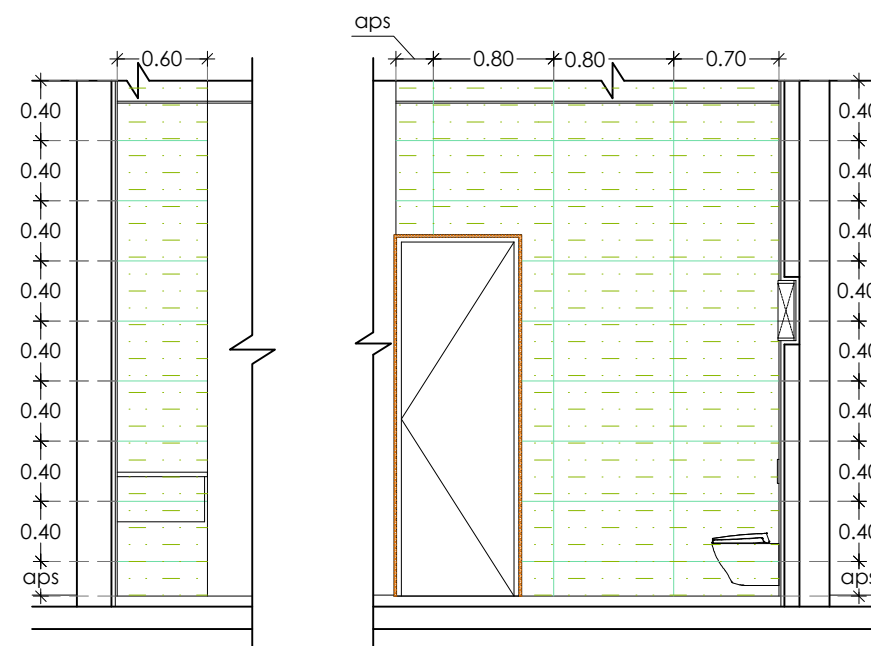

For Discussion	☐	Site Copy	☐
For Approval	☐	Clients Copy	☐
Good For Construction	☐	Contractors Copy	☐

Drawn : Durgaa	Scale : NTS	Date: 29.09.'22
Checked : Divya Sign :	dwg no :	

File Path:

drawing :

TOILET 4 - TILE LAYOUT

project :

PROPOSED RESIDENTIAL
DEVELOPMENT FOR
Mr. SHIVAKUMAR @ YERCAUD



Architects | Interior Designers | Planners

First Floor, 33.Ranjit Road,

kotturpuram, Chennai - 600 085, India
Tel.: +91-44-4222-2721/22/23

Fax: +91 - 44 - 42303734

E-mail: mail@designworks.in

Web: www.designworks.in




Drawn : Durgaa	Scale : NTS	Date: 29.09.'22
Checked : Divya Sign :	dwg no :	


drawing :
TOILET 5 - PLUMBING LAYOUT

DESIGNWORKS
Architects | Interior Designers | Planners


First Floor, 33, Ranjit Road,
Kotturpuram, Chennai - 600 085, India
Tel: +91-44-4230 3731/32/33
Fax: +91-44-42303734
E-mail: mail@designworks.in
Web: www.designworks.in

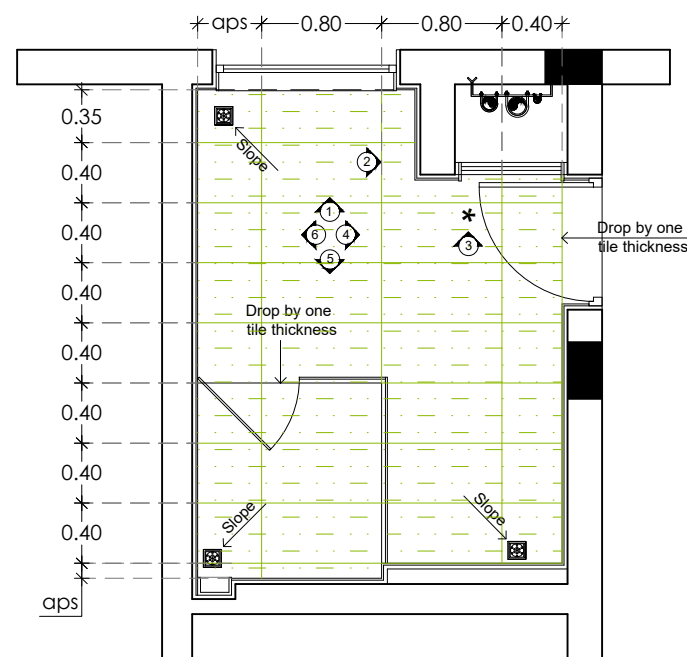


FLOORING TILE LAYOUT

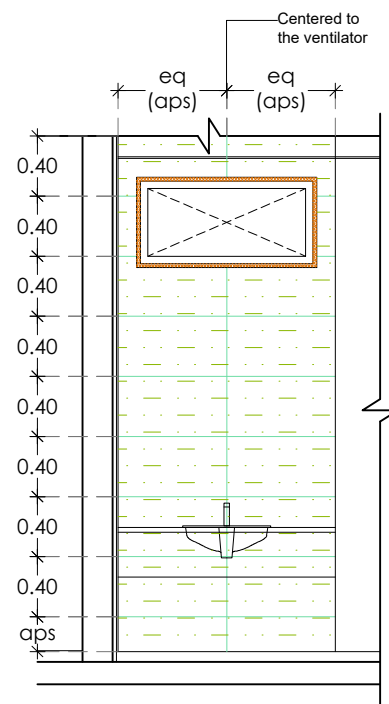

ELEVATION - 1

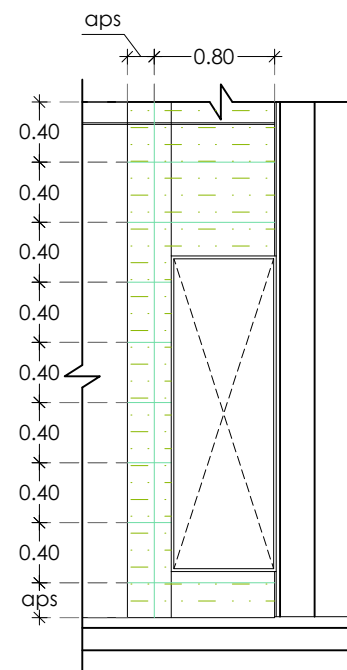


ELEVATION - 3

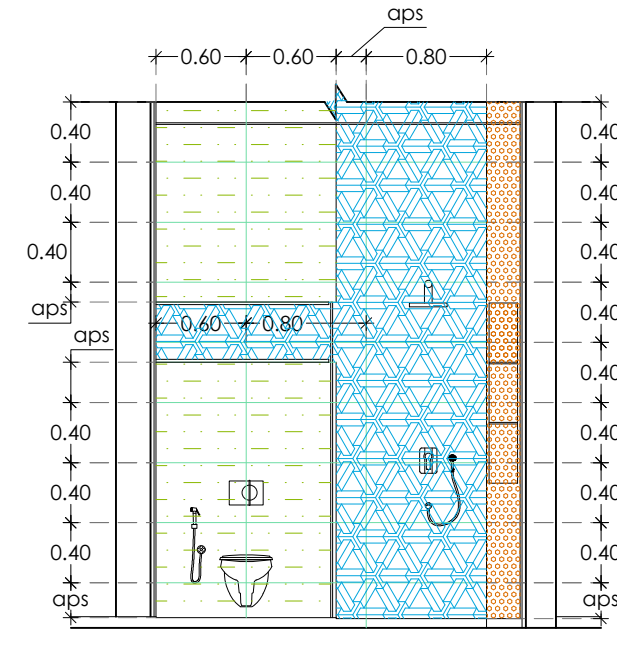

ELEVATION - 5



 
Munich Mist 400 X 800mm




Cantera Decor 400 X 800mm




Granite

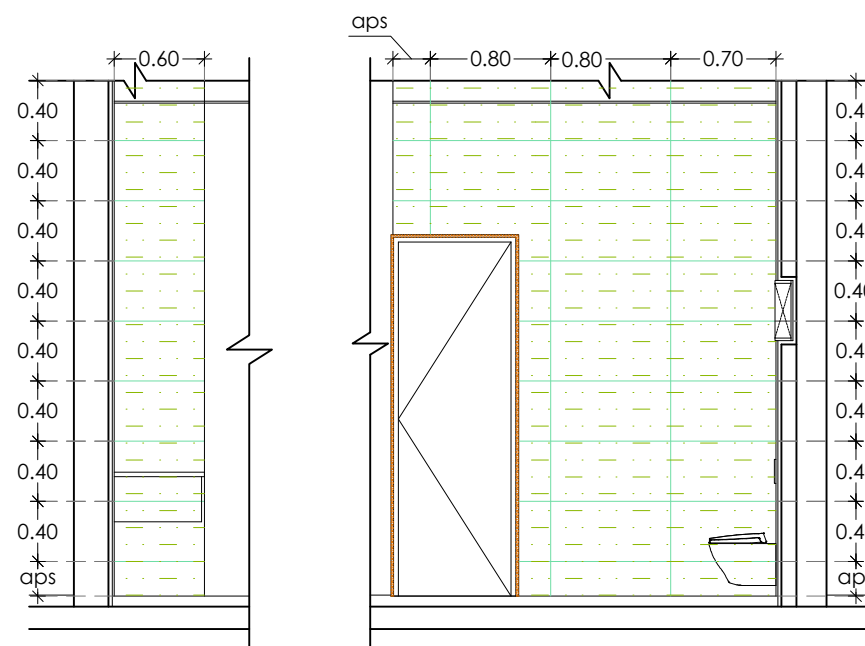

ELEVATION - 2

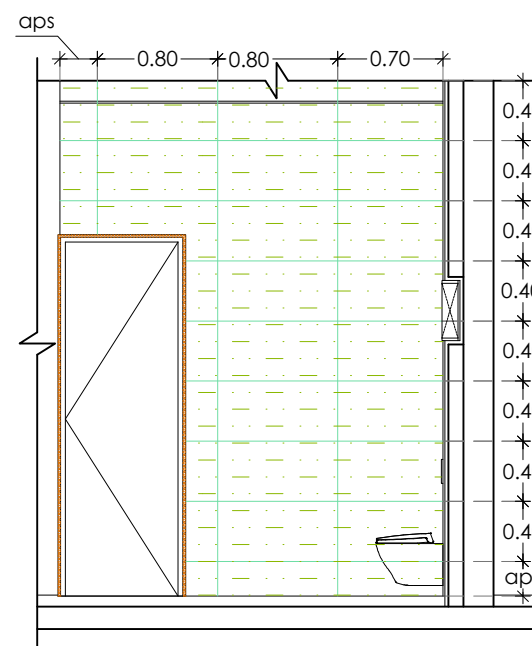

ELEVATION - 4

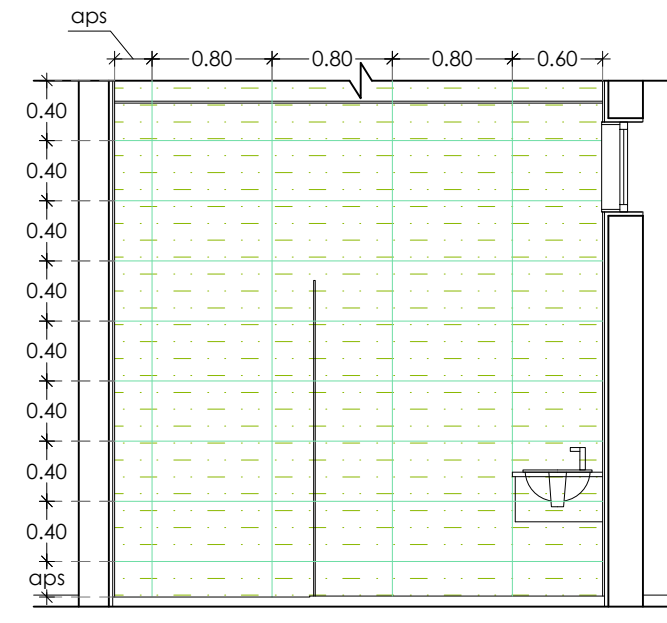

ELEVATION - 6

NOTES:
This drawing is the property of designworks & cannot be used or reproduced any form without their written permission.

Any discrepancy should be brought to the notice of the architects.

Only written dimensions should be followed, the drawing is not to be scaled.

For Discussion	☐	Site Copy	☐
For Approval	☐	Clients Copy	☐
Good For Construction	☐	Contractors Copy	☐

Drawn : Durgaa	Scale : NTS	Date: 29.09'22
Checked : Divya	dwg no :	
Sign :		

File Path:

drawing :
TOILET 4 - TILE LAYOUT

project :
PROPOSED RESIDENTIAL
DEVELOPMENT FOR
Mr. SHIVAKUMAR @ YERCAUD

DESIGNWORKS
Architects | Interior Designers | Planners

First Floor, 33.Ranjit Road,
kotturpuram, Chennai - 600 085, India
Tel: +91- 44 - 4230 3731/32/33
Fax: +91- 44 - 42303734
E-mail: mail@designworks.in
Web: www.designworks.in

CRITICAL OVERVIEW OF THE FIRM

DESIGNWORKS extended a great opportunity and an overall delightful experience for me to work with. I had a lot to grasp and learn from each and every project there. The warm and amicable environment in the firm gave me an opportunity to experience good work culture and explore so much with regards to not just interior design, but also civil & architecture.

The amount of dedication, hard work and passion towards every single project, each and everyone shows on the project, inspired me a lot and gave me a chance to understand how an architectural/designer firm actually works, how an architect/designer work, the types of works one has to work on as a designer/architect and how to work in an efficient way together as a team. From concept development, client meetings, the amount of importance given to a client and their requirements, site visits, the drawings, presentations, detailings, materials selection, vendor meetings, to deadlines & project completion there was so much for me to discover and learn.

I understood that along with the theoretical knowledge, one has to actually step deep down into the field; work on numerous projects, meet clients and vendors, visit sites, should have good communication skills and networking with people, keep oneself updated with the new design trends, materials, fittings and fixtures related to the field, be in touch with other architects/designers to acquire practical knowledge and experience.

I'm thankful and grateful to all my senior & junior architects/designers who took time to listen, teach me without judging and for helping me in all possible ways to obtain the required skills and knowledge to the utmost.